


Bar To be used as guidance only

mm	1000	3000	5000	
mm	2000	6000	8000	
M	5	15	25	
M	10	30	50	70



WP RAIN WATER PIPES TO THE INTERNAL
COURTYARD ELEVATIONS SHOWN
INDICATIVE. EXACT NUMBER AND POSITION
SUBJECT TO CONFIRMATION WITH THE
SPECIALIST SUB-CONTRACTORS.

 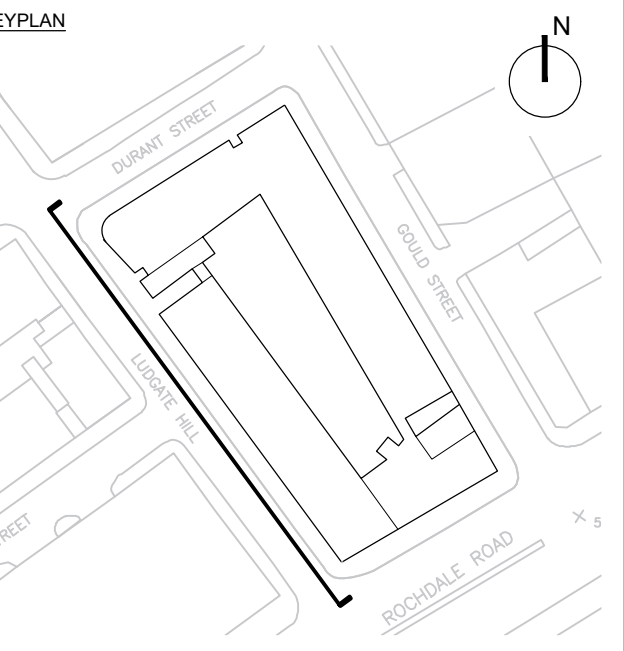


A	04/11/2021	For Planning		AD	CL
/	15/10/2021	Preliminary First Issue		AD	CL
Rev	Date	Revision Description		Drm	Chk

Project Name Red Building Manchester		North
Client THOMASONS		
Drawing Title Existing & Proposed West Elevation (Roof Parapet Line Comparison)		Client Job No Client No DMVR Job No 3832
Drawing Reference. 3832-DR-002		Revision A
Drawing Date 15.10.2021	Scale 1:100 @A1	Drawn By AD
Drawing Status FOR PLANNING		Checked By CL

First Floor
16-18 Hatton Garden
London EC1 N 8AT

020 7570 3779
mail@dmwr.co.uk
www.dmwr.co.uk


DMWR
Architects

Fourth Floor
41 Spring Gardens
Manchester M2 2BG

0161 413 4656
mail@dmwr.co.uk
www.dmwr.co.uk