

Ventilation Notes

1.

This drawing shall be read in conjunction with all other services, Architectural drawings, project specifications and contract documentation.
2.

All ductwork to DW144/DW154 (where applicable).
3.

Flex to be used only straight-all bends to be rigid.
4.

Fire collars to be located in accordance with fire strategy drawing requirements.
5.

All diffusers and grilles to be supported by structure.
6.

In positions of restricted headroom, ducts may be supported with flat bar formed to duct shape with fixings at sides on bent lugs.
7.

All references to specific manufacturers are made for design specification purposes, installed equipment should be of equal standard and approved.
 - A switch interlock in each kitchen and a built in humidistat located as part of the central fan. The humidistat will monitor the air in the extract ducts and operate automatically as and when the air quality requires changing. This is to run on a programmed period of time once the switch has been switched off.
8.

All Heat Recovery Units to be fitted with 22mm condensate drains.
9.




The mechanical ventilation heat recovery unit shall be arranged with interlocks, to initiate a 'boosted' level of ventilation as follows:
 - A switch interlock in each kitchen and a built in humidistat located as part of the central fan. The humidistat will monitor the air in the extract ducts and operate automatically as and when the air quality requires changing. This is to run on a programmed period of time once the switch has been switched off.
10.

The fan unit shall be complete with a local wall mounted isolator, located conveniently within the storage cupboard.
11.

A minimum of 4ach/hr shall be provided to provide purge ventilation in line with Part F of the building regulations.

Ventilation Legend

- Supply Air Flow
- Extract Air Flow
- PIR Detector
- VCD
Volume control damper
(M = Motorised)
- FD
Fire damper
- ATT
Attenuator (CT = Cross talk)
- C
Controller for heat recovery units
- Internal Bedrooms
- 4 air changes/hour

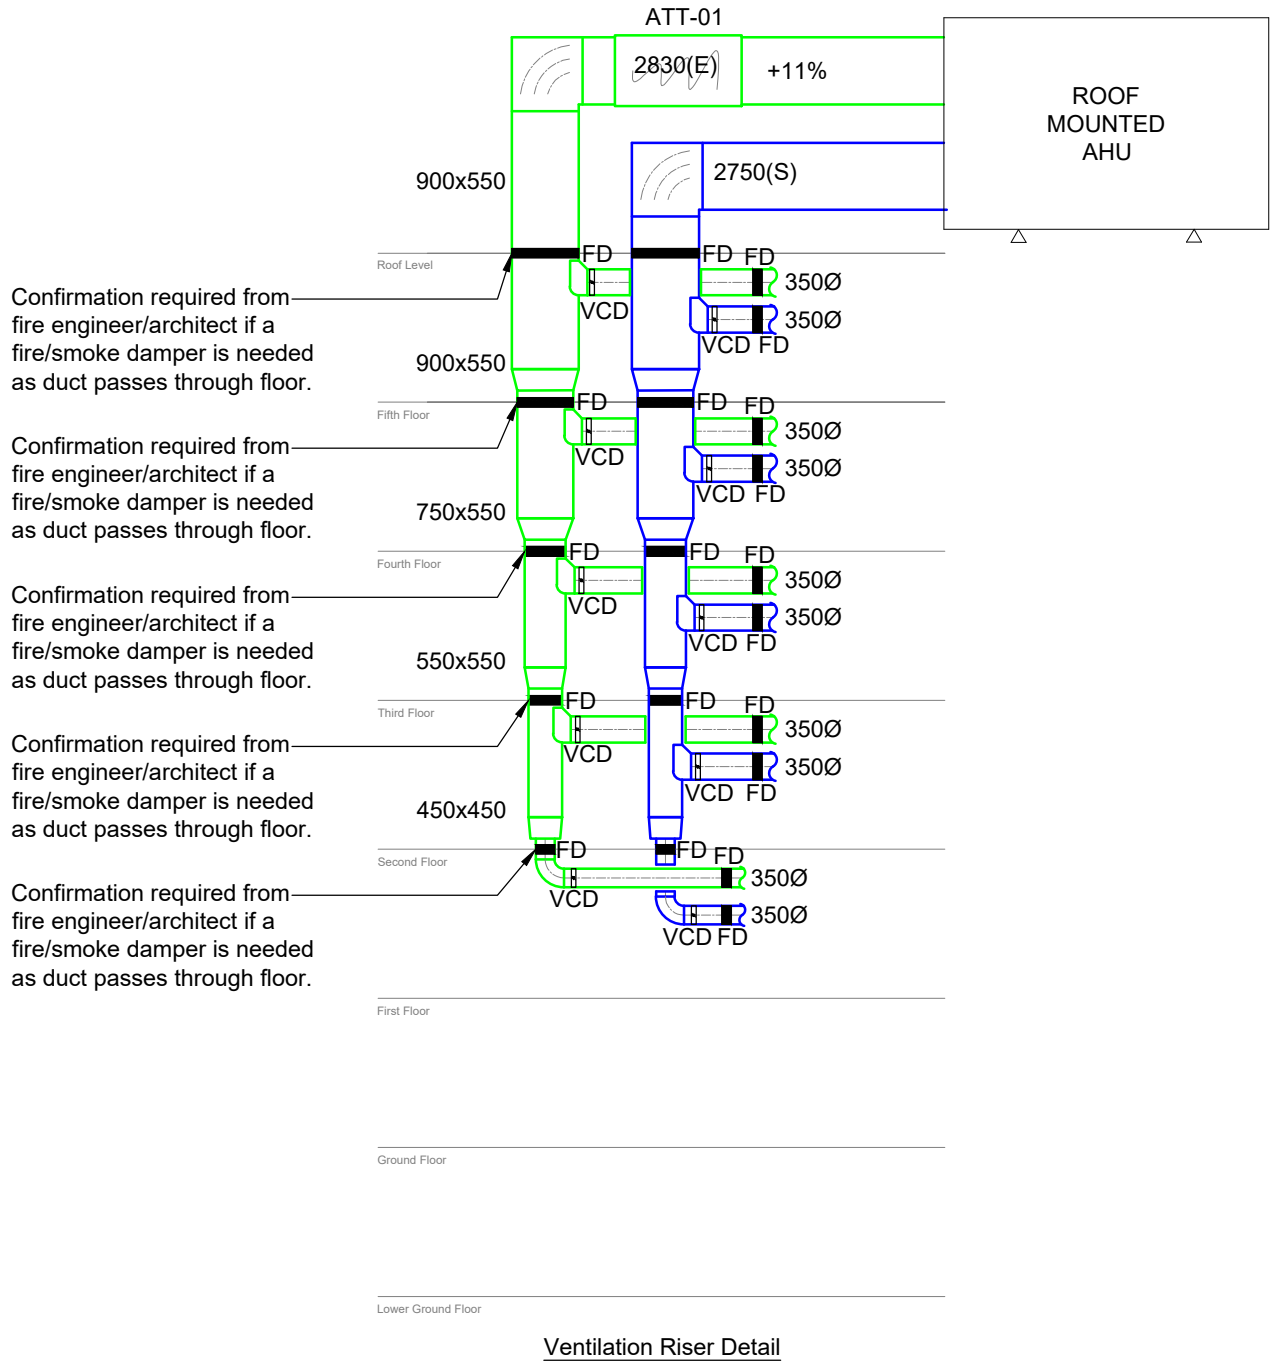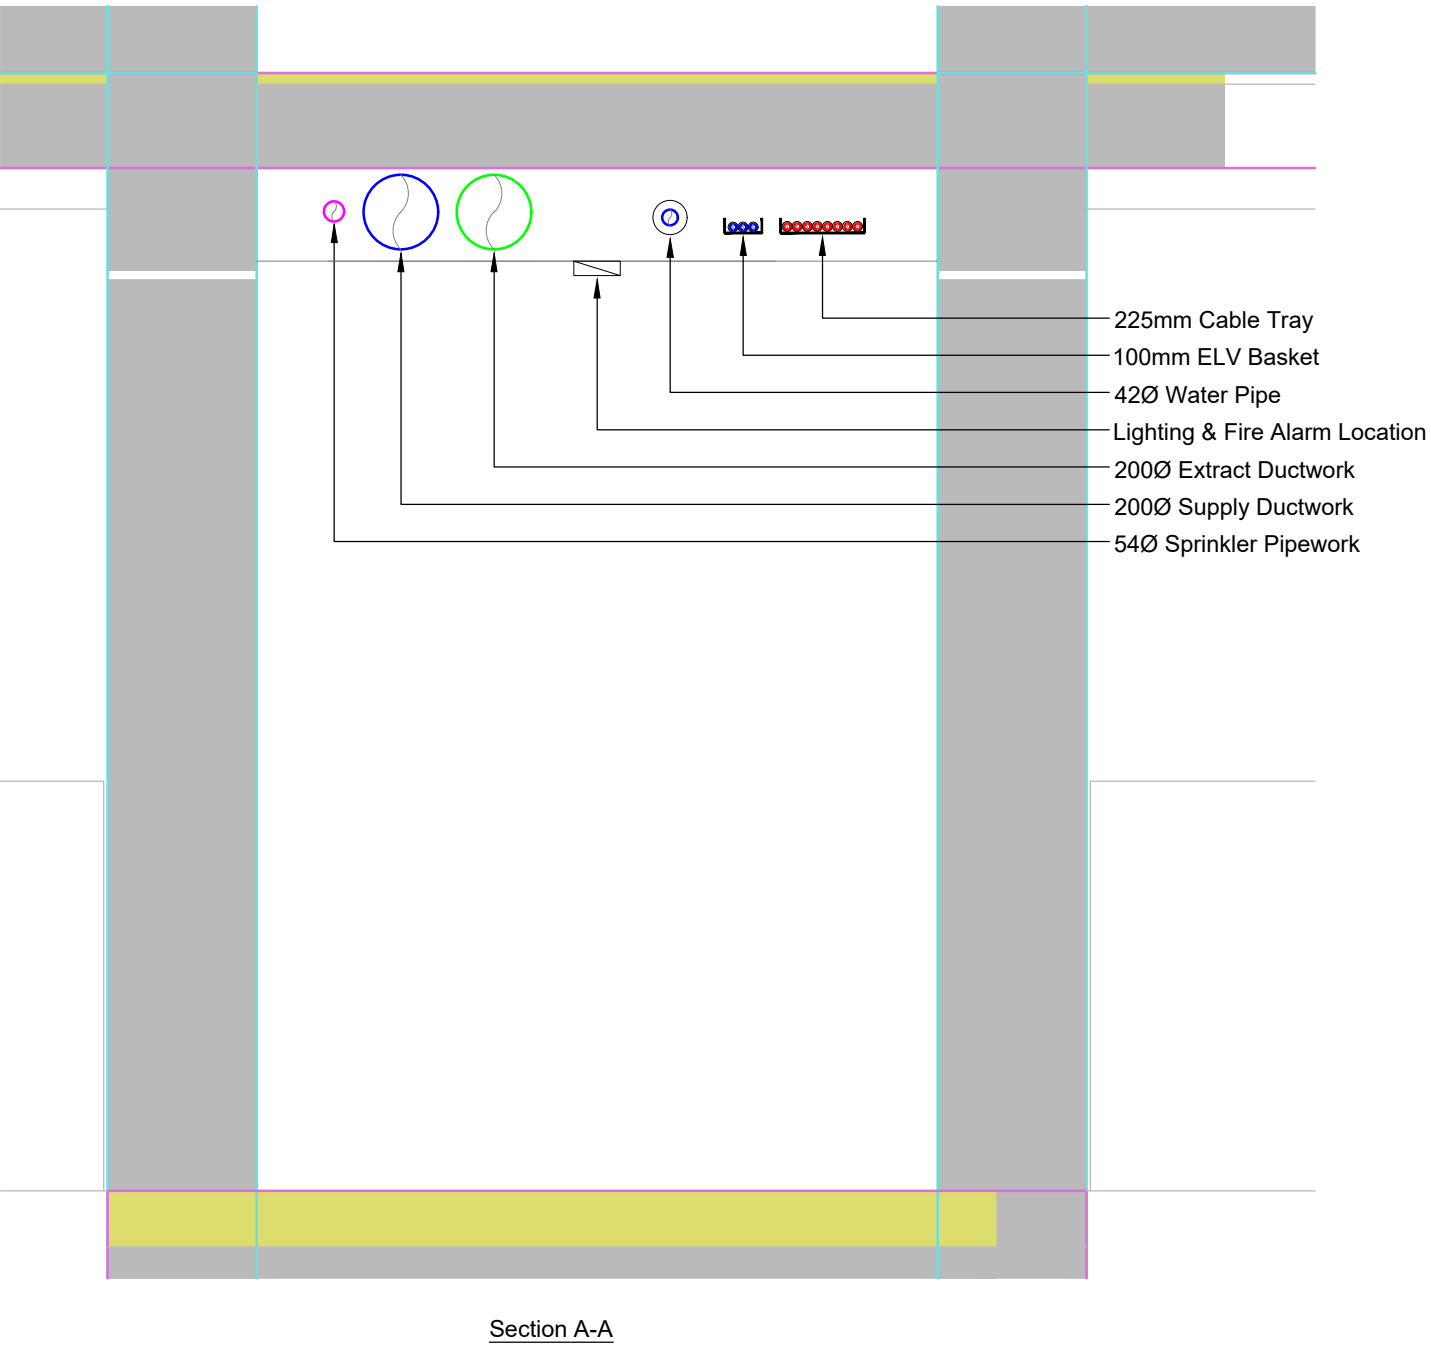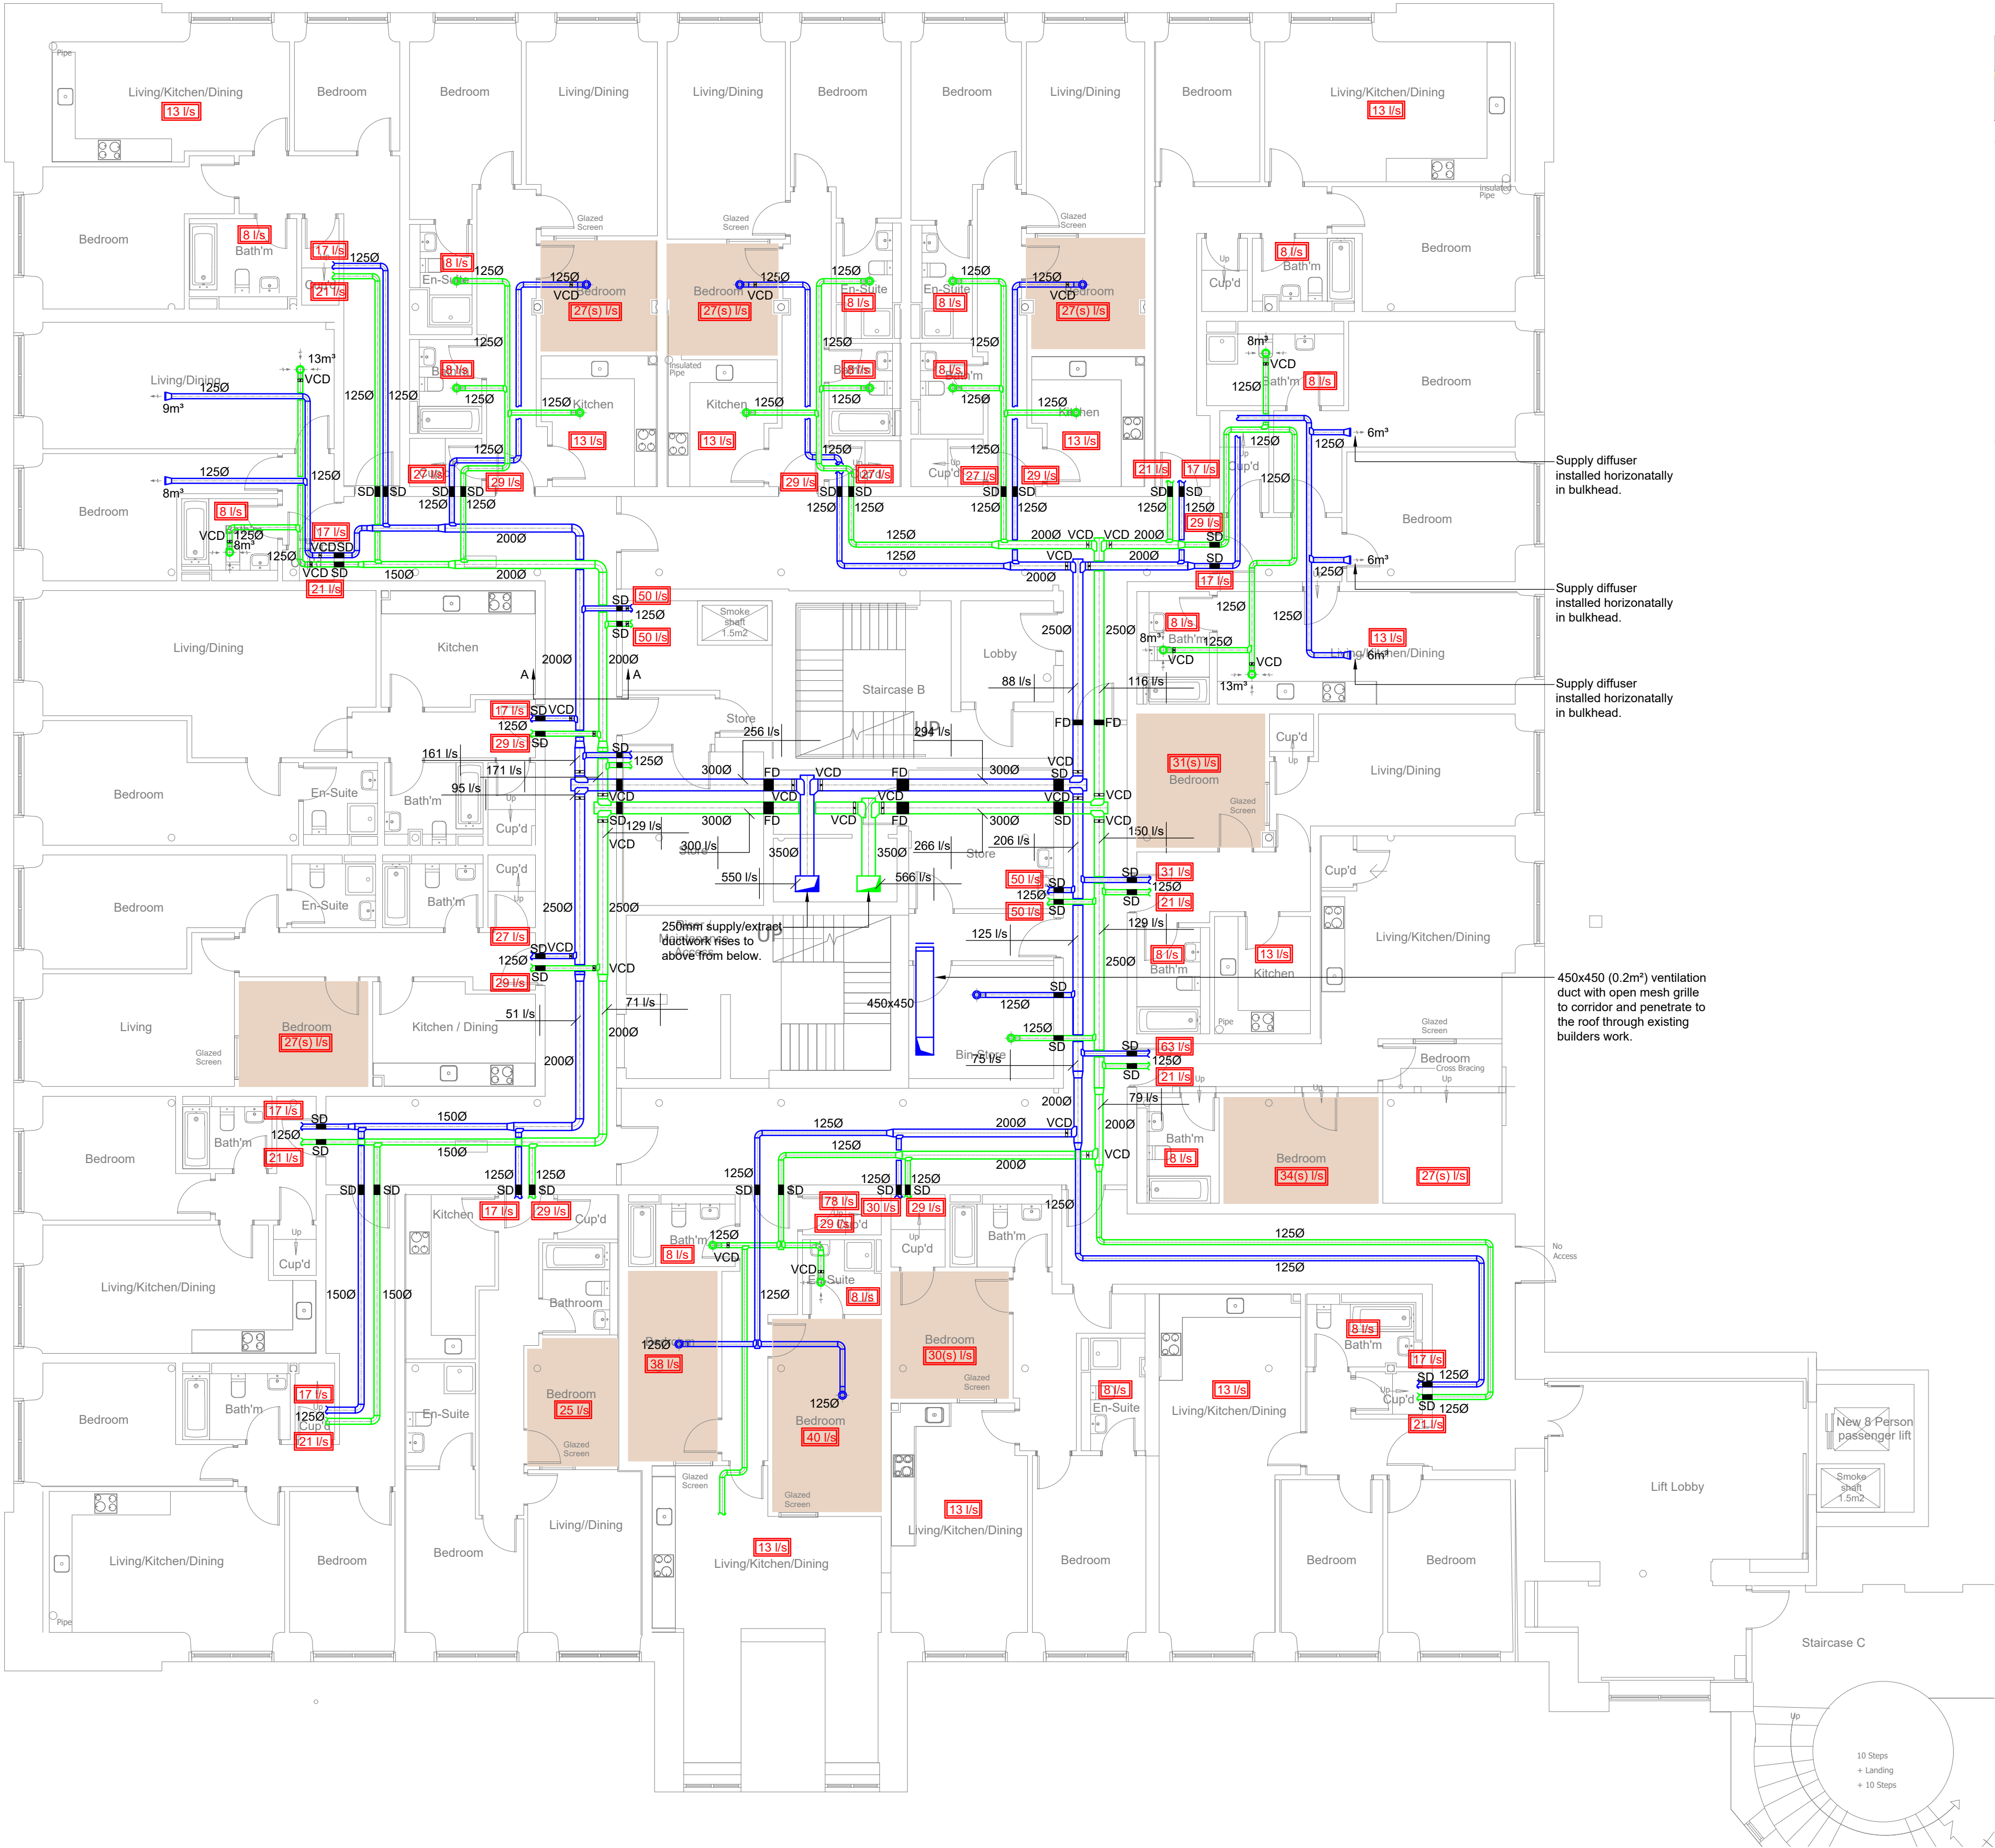

C3	NG	20.05.21	Contract Issue.
C2	NG	15.04.21	Contract Issue.
C1	NG	19.03.21	Contract Issue.
P3	JM	15.03.21	Preliminary Issue.
P2	JM	26.02.21	Preliminary Issue.
P1	JM	15.01.21	Preliminary Issue.
Rev	By	Date	Description

FRP
Advisory

TACE

THE ASSOCIATES CONSULTING ENGINEERS
Portland House
Stanley Green Business Park
Oak Green
Cheshire M60
Salford S6 4RT
T: 0161 488 8429
F: 0161 488 0488
E: info@tace.co.uk
W: www.tace.co.uk

Client		
FRP Advisory		
Project		
Victoria Mill Manchester		
Drawing Title		
Proposed Ventilation Layout First Floor		
Drawn		
JL	11.02.21	Cad File VMM-TCE-XX-01-DR-M-57001 Rev C3.dwg
Checked		
JM	xx.xx.21	External Ref. -
Approved		
JM	xx.xx.21	Scale 1:100 at A1
Job No.		
PA1484	VMM-TCE-XX-01-DR-M-57001	Rev C3