


HEAT PUMP SCHEDULE (OUTDOOR)

REF	AREA SERVED	MANUFACTURER	MODEL	REFRIGERANT	ELECTRICAL DETAILS (VPh/Hz)	SIZE (WxDxH)	WEIGHT (kg)	NOISE (SOUND PRESSURE - dBA)
C01	GROUND FLOOR	mitsubishi	PURY-P350YNW-A1	R410A	400/3/50, 19.5A FLC	1240x740x1858	273	62
C02	GROUND FLOOR	mitsubishi	PURY-P400YNW-A1	R410A	400/3/50, 19.5A FLC	1240x740x1858	273	65
C03	GROUND FLOOR COMMS ROOM	mitsubishi	PUHZ-ZRP35VKA2	R32	230/1/50, 13.1A FLC	809x300x630	46	46
C04	FIRST FLOOR	mitsubishi	PURY-P350YNW-A1	R410A	400/3/50, 19.5A FLC	1240x740x1858	273	62
C05	FIRST FLOOR	mitsubishi	PURY-P400YNW-A1	R410A	400/3/50, 19.5A FLC	1240x740x1858	273	65
C06	FIRST FLOOR COMMS ROOM	mitsubishi	PUHZ-ZRP35VKA2	R32	230/1/50, 13.1A FLC	809x300x630	46	46
C07	SECOND FLOOR	mitsubishi	PURY-P350YNW-A1	R410A	400/3/50, 19.5A FLC	1240x740x1858	273	62
C08	SECOND FLOOR	mitsubishi	PURY-P400YNW-A1	R410A	400/3/50, 19.5A FLC	1240x740x1858	273	65
C09	SECOND FLOOR COMMS ROOM	mitsubishi	PUHZ-ZRP35VKA2	R32	230/1/50, 13.1A FLC	809x300x630	46	46
C10	THIRD FLOOR	mitsubishi	PURY-P350YNW-A1	R410A	400/3/50, 19.5A FLC	1240x740x1858	273	62
C11	THIRD FLOOR	mitsubishi	PURY-P400YNW-A1	R410A	400/3/50, 19.5A FLC	1240x740x1858	273	65
C12	THIRD FLOOR COMMS ROOM	mitsubishi	PUHZ-ZRP35VKA2	R32	230/1/50, 13.1A FLC	809x300x630	46	46

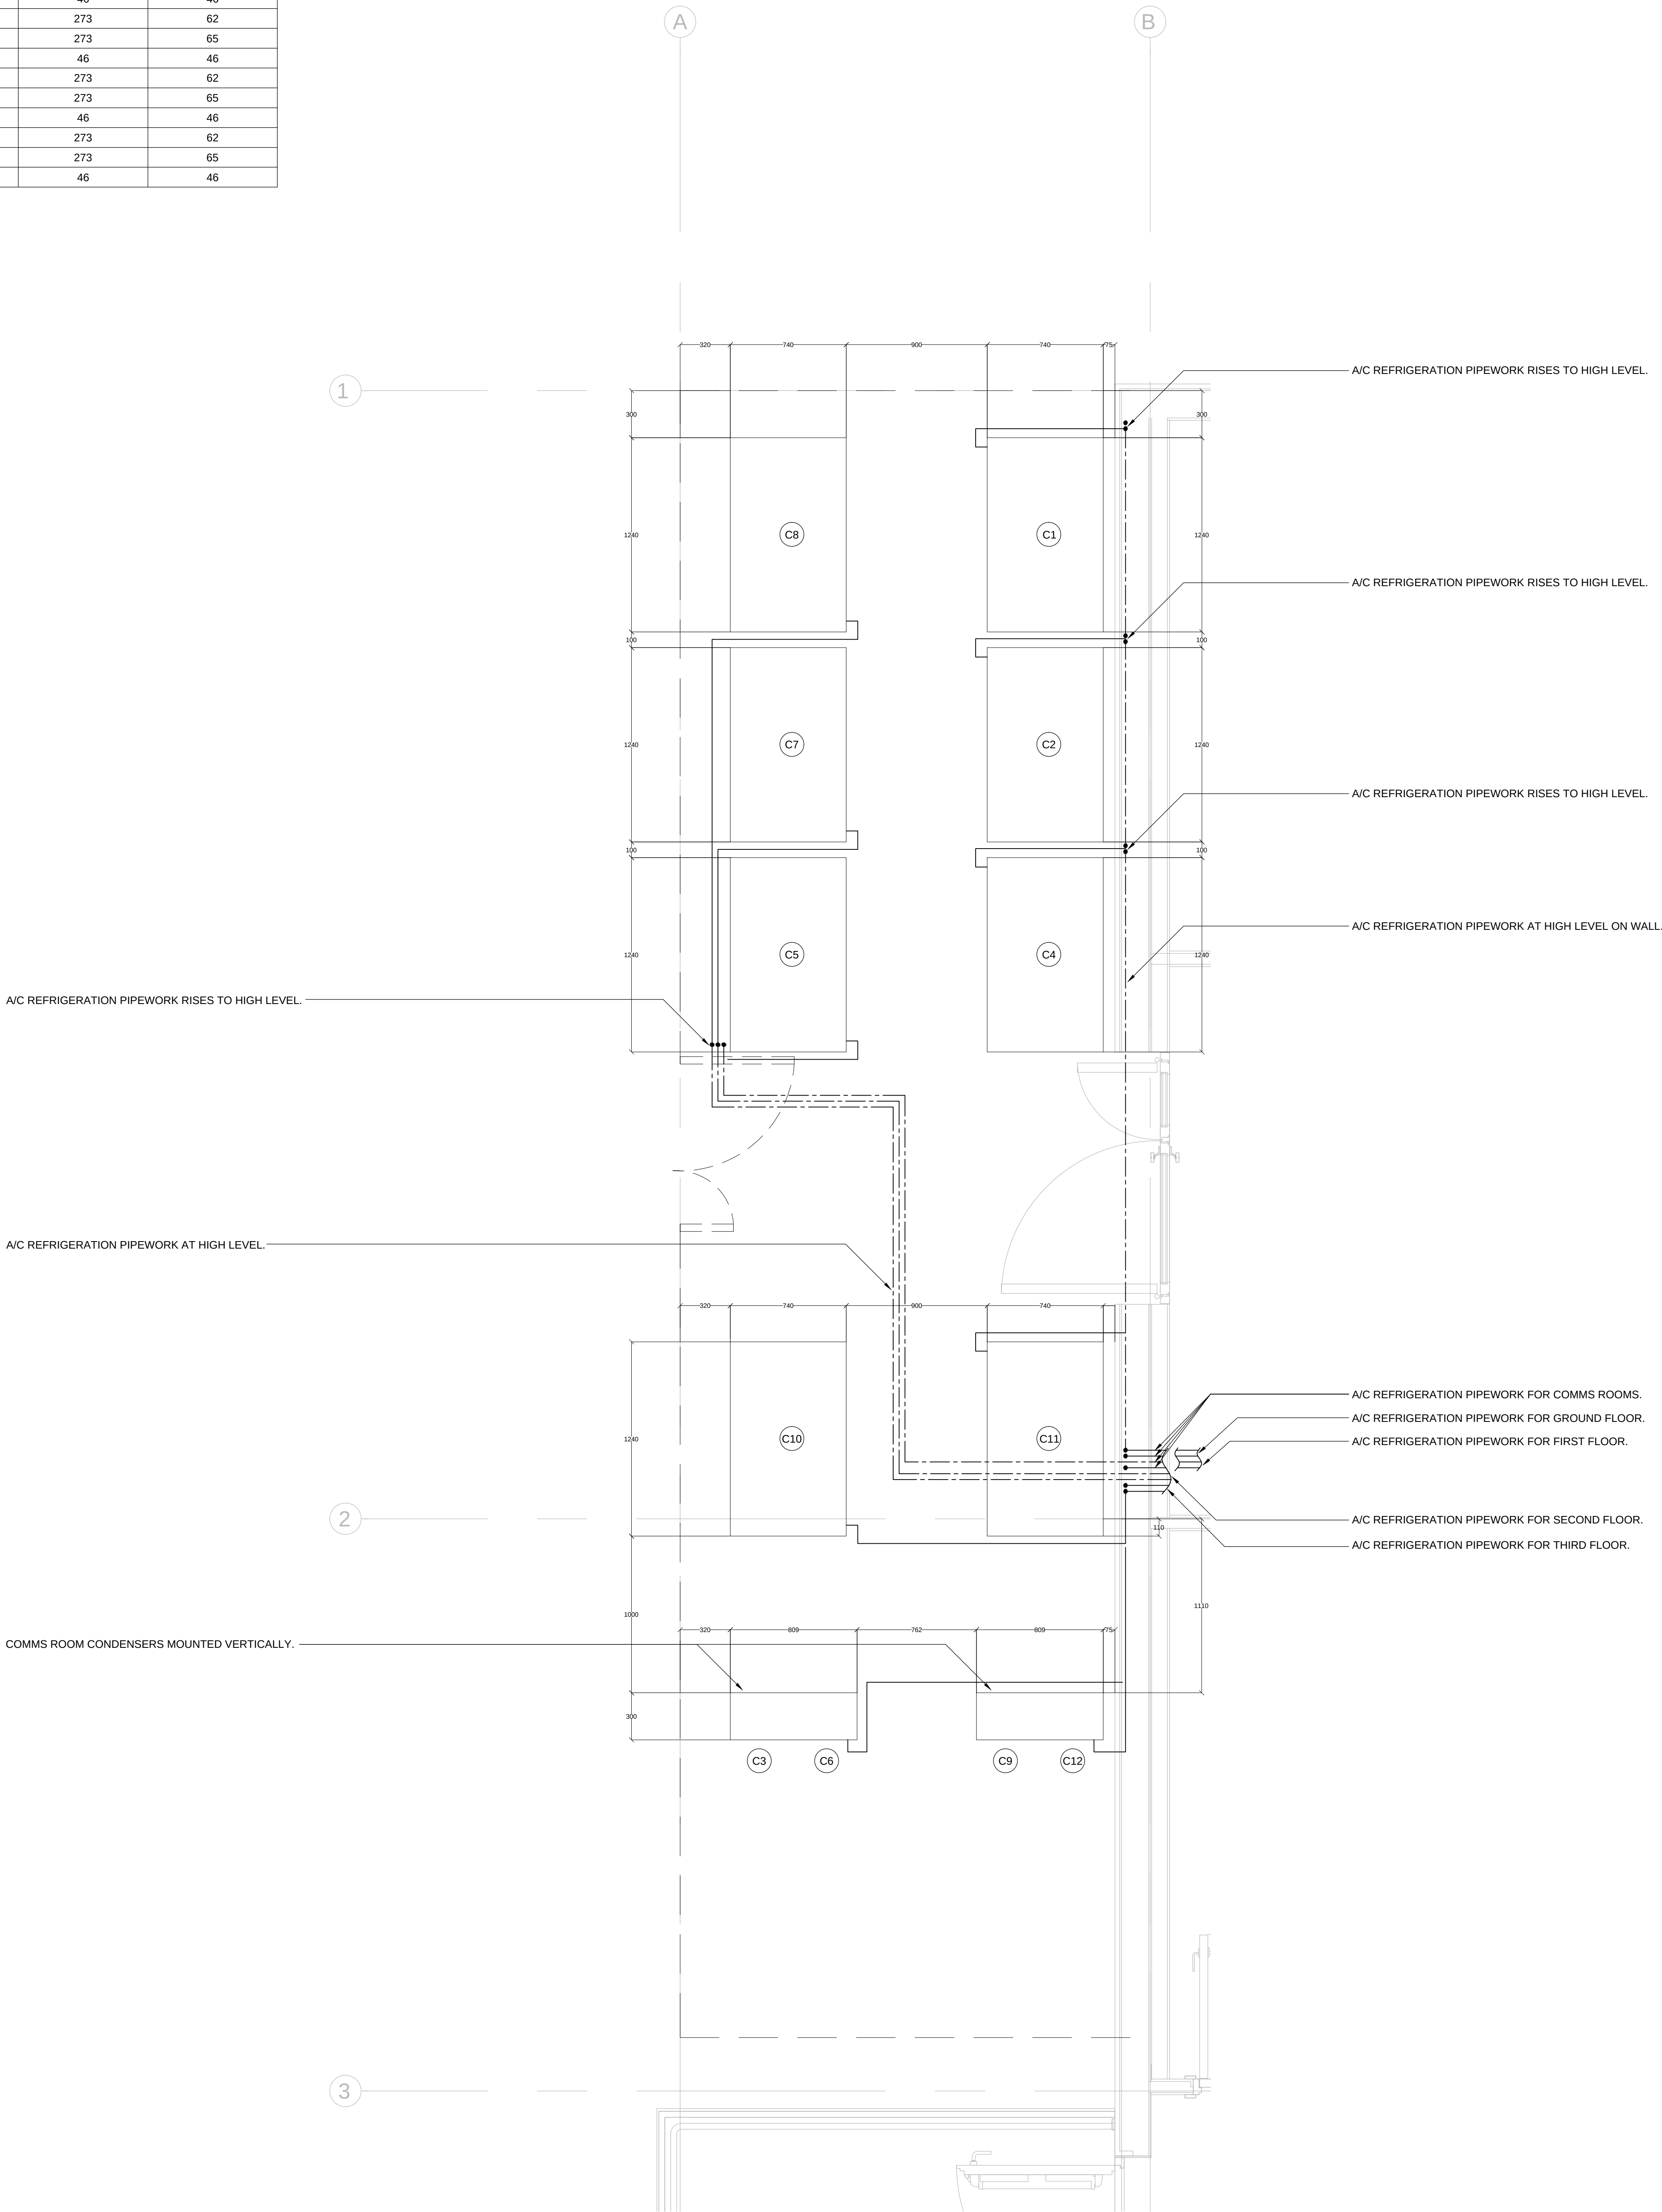

THIS DRAWING IS THE PROPERTY OF YORKSHIRE BUILDING SERVICES. IT MUST NOT BE REPRODUCED IN PART OR WHOLE NOR DESIGN USED WITHOUT WRITTEN CONSENT. DO NOT SCALE FROM THIS DRAWING.

NOTES

THIS DRAWING SHALL BE READ IN CONJUNCTION WITH THE ASSOCIATED ELECTRICAL SERVICES AND ARCHITECTS LAYOUT DRAWINGS TOGETHER WITH THE MECHANICAL SPECIFICATION.

ALL MECHANICAL INSTALLATIONS SHALL BE CO-ORDINATED AND FULLY INTEGRATED WITH THE ELECTRICAL SERVICES, ARCHITECTURAL FEATURES, AND STRUCTURAL ELEMENTS etc.

THE MECHANICAL CONTRACTOR SHALL FAMILIARISE ELECTRICAL SERVICES DETAILS, MECHANICAL SERVICES DETAILS AND ALL ELEVATION DRAWINGS PRODUCED.

B	DB	24/01/21	DB	CONDENSER DIMENSIONS FOR SET OUT ADDED
A	AG	15/12/20	GW	1. FIRST ISSUE
Rev	By	Date	Apr	Details

PRELIMINARY



YORKSHIRE BUILDING SERVICES LTD
ACCESS WORKS, MARTIN STREET,
BIRSTALL, BATLEY, WF17 9PJ

Tel: 01924 471955
Fax: 01924 477508

Web: www.ybsltd.co.uk

PROJECT

NMGH
MODULAR
OFFICES

DRAWING TITLE

EXTERNAL CONDENSER
LAYOUT
SHEET 1 OF 1

SCALE 1 : 50 @ A0 DATE 15/12/20

DRAWN AG CHECKED GW

DRAWING No.

20-074-YBS-OB-EX-DR-M-5701

LAYOUT BASED ON DWG No : 2167-ESS-00-00-DR-W-1000 - Layout Plan
DATE RECEIVED : 4th September 2020
PREPARED BY : ESS MODULAR