




1 Section B - Lighting at 9th Floor
1 : 100

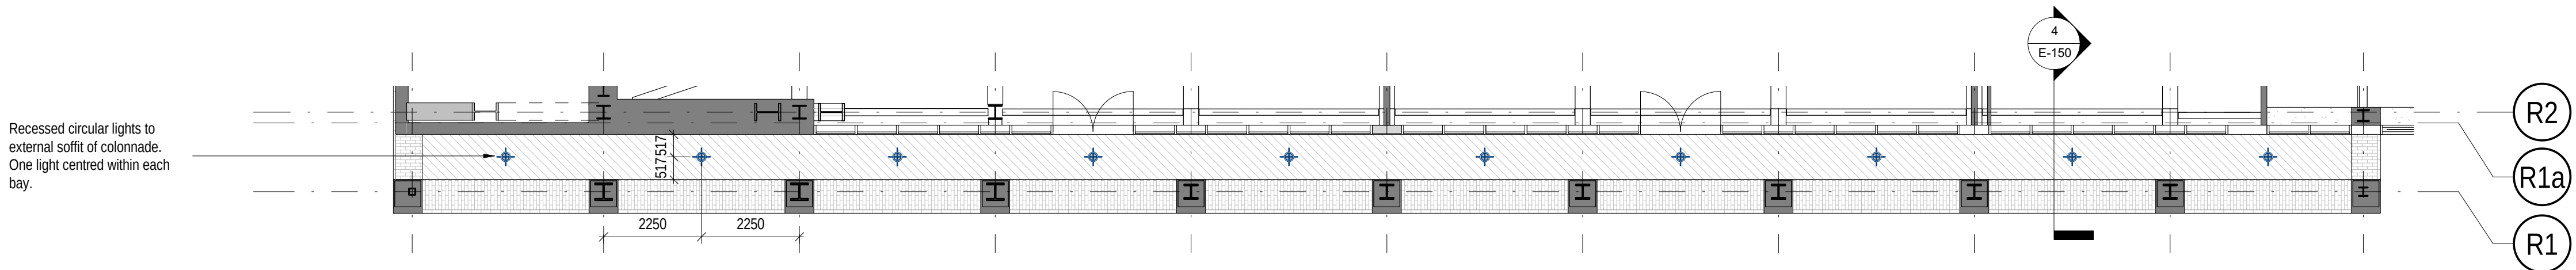


2 Partial RCP - Ground Floor Lighting
1 : 100

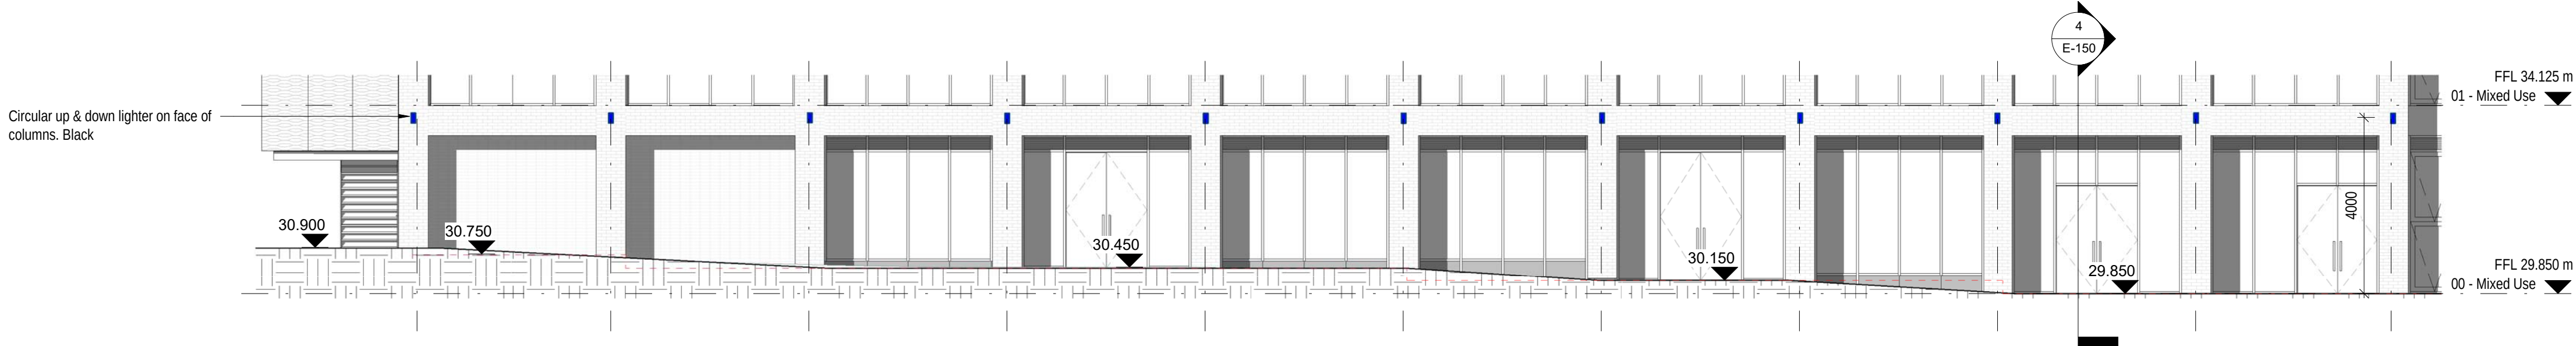

3 Zone 6 - Partial East Elevation - Ground Floor Lighting Option B
1 : 100

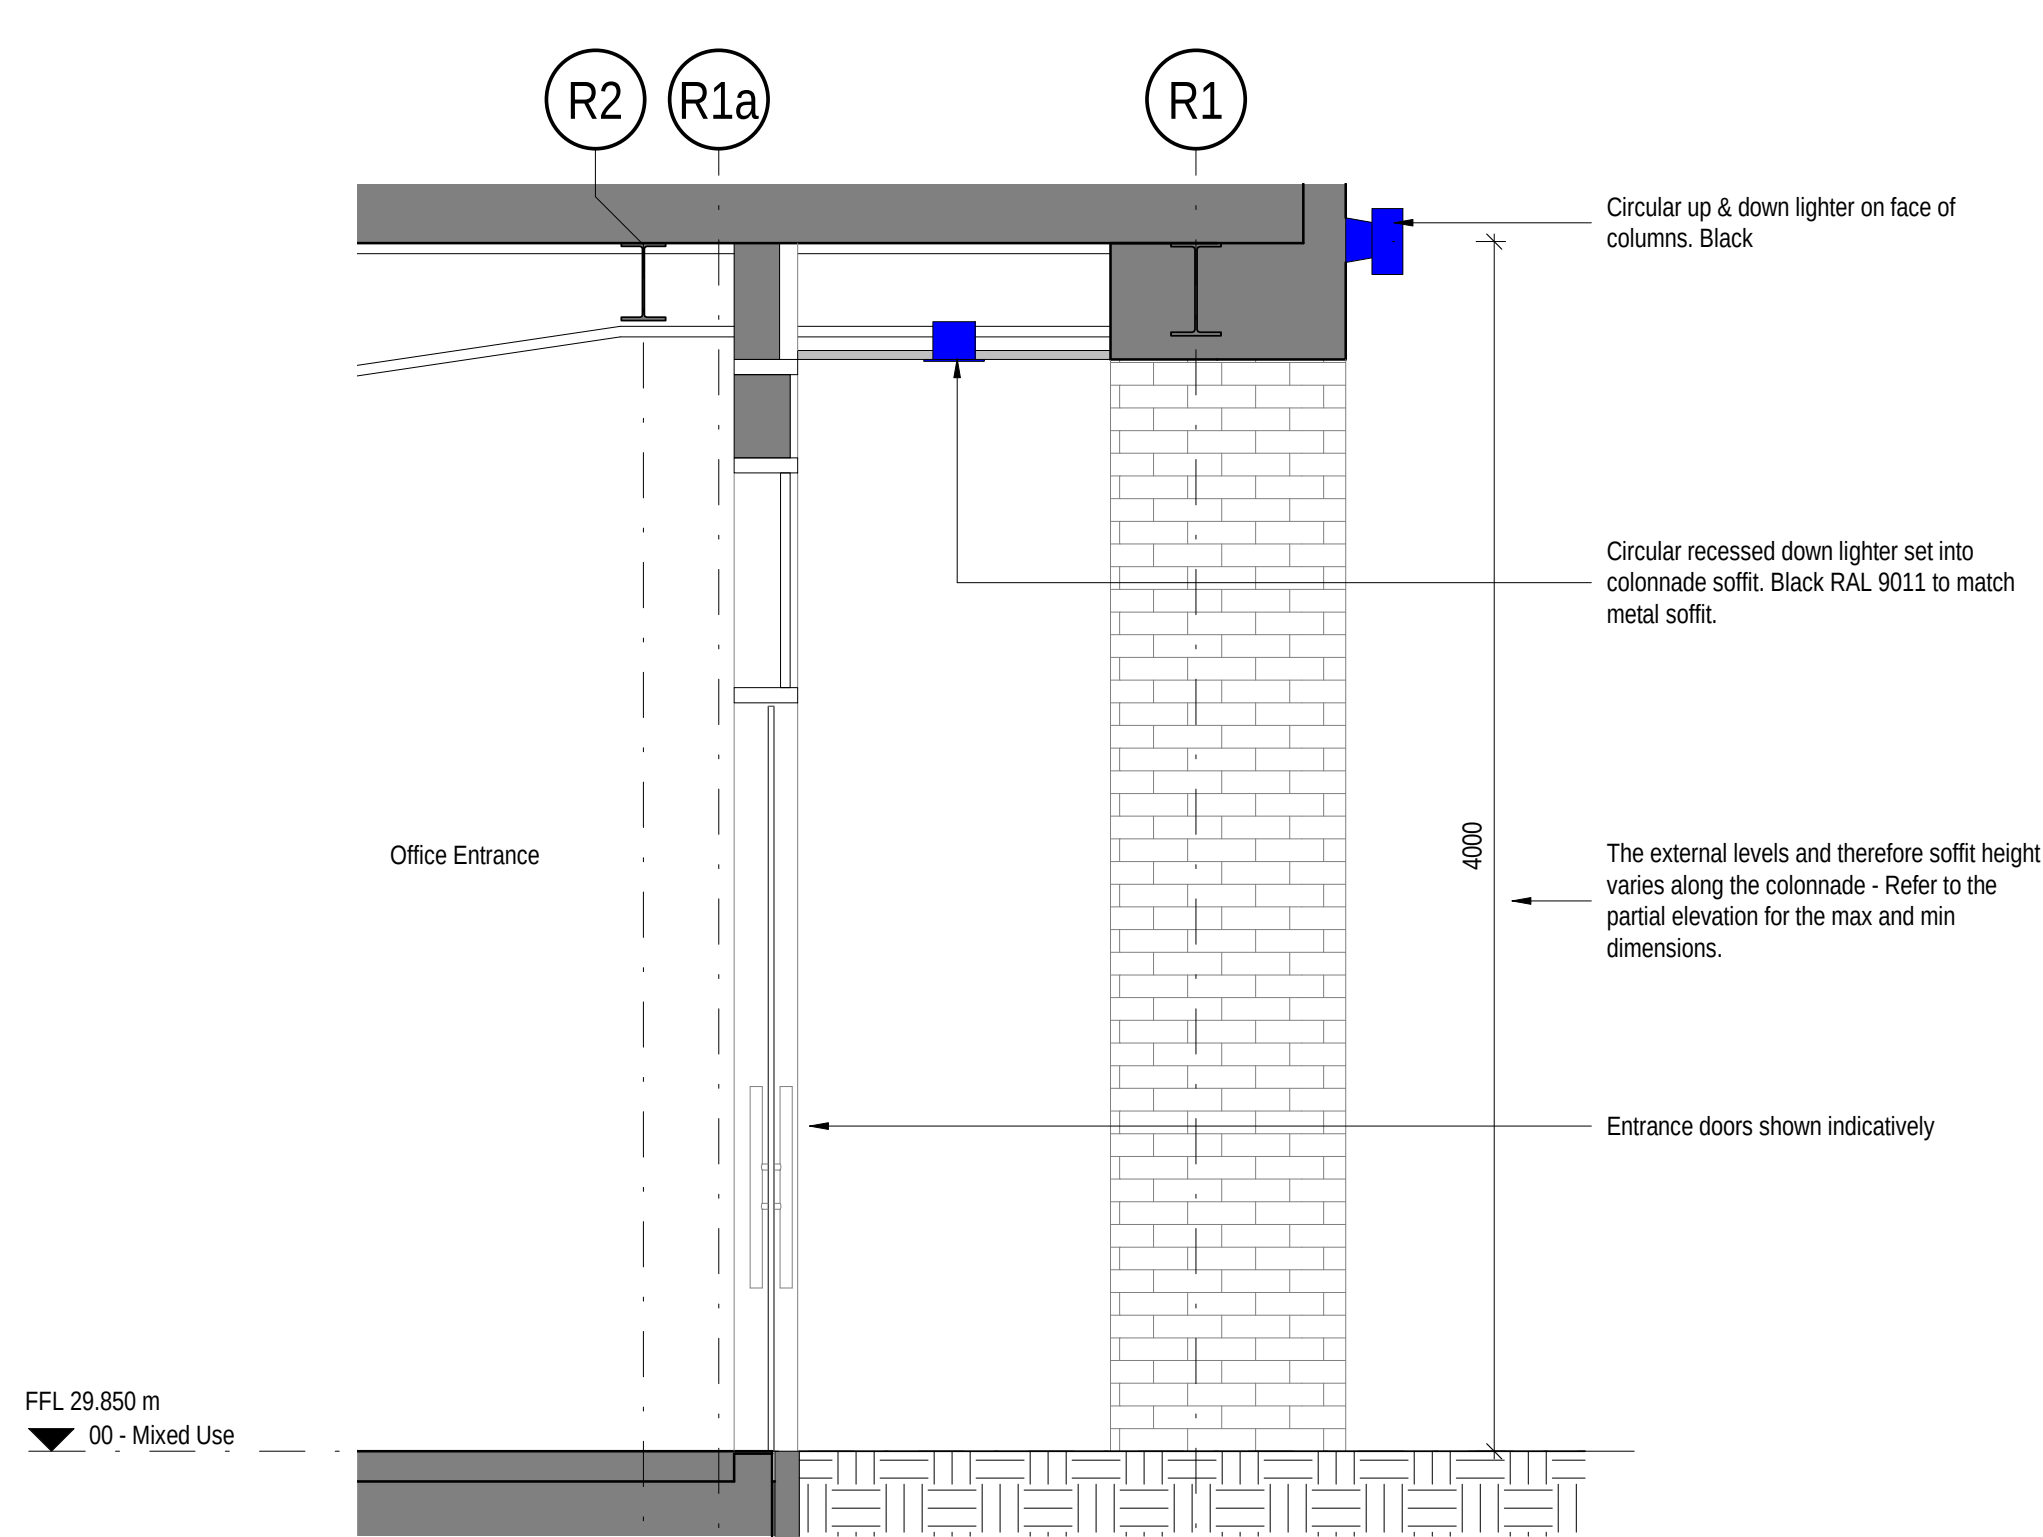

4 Zone 6 - Section A - Lighting at Ground Floor
1 : 25

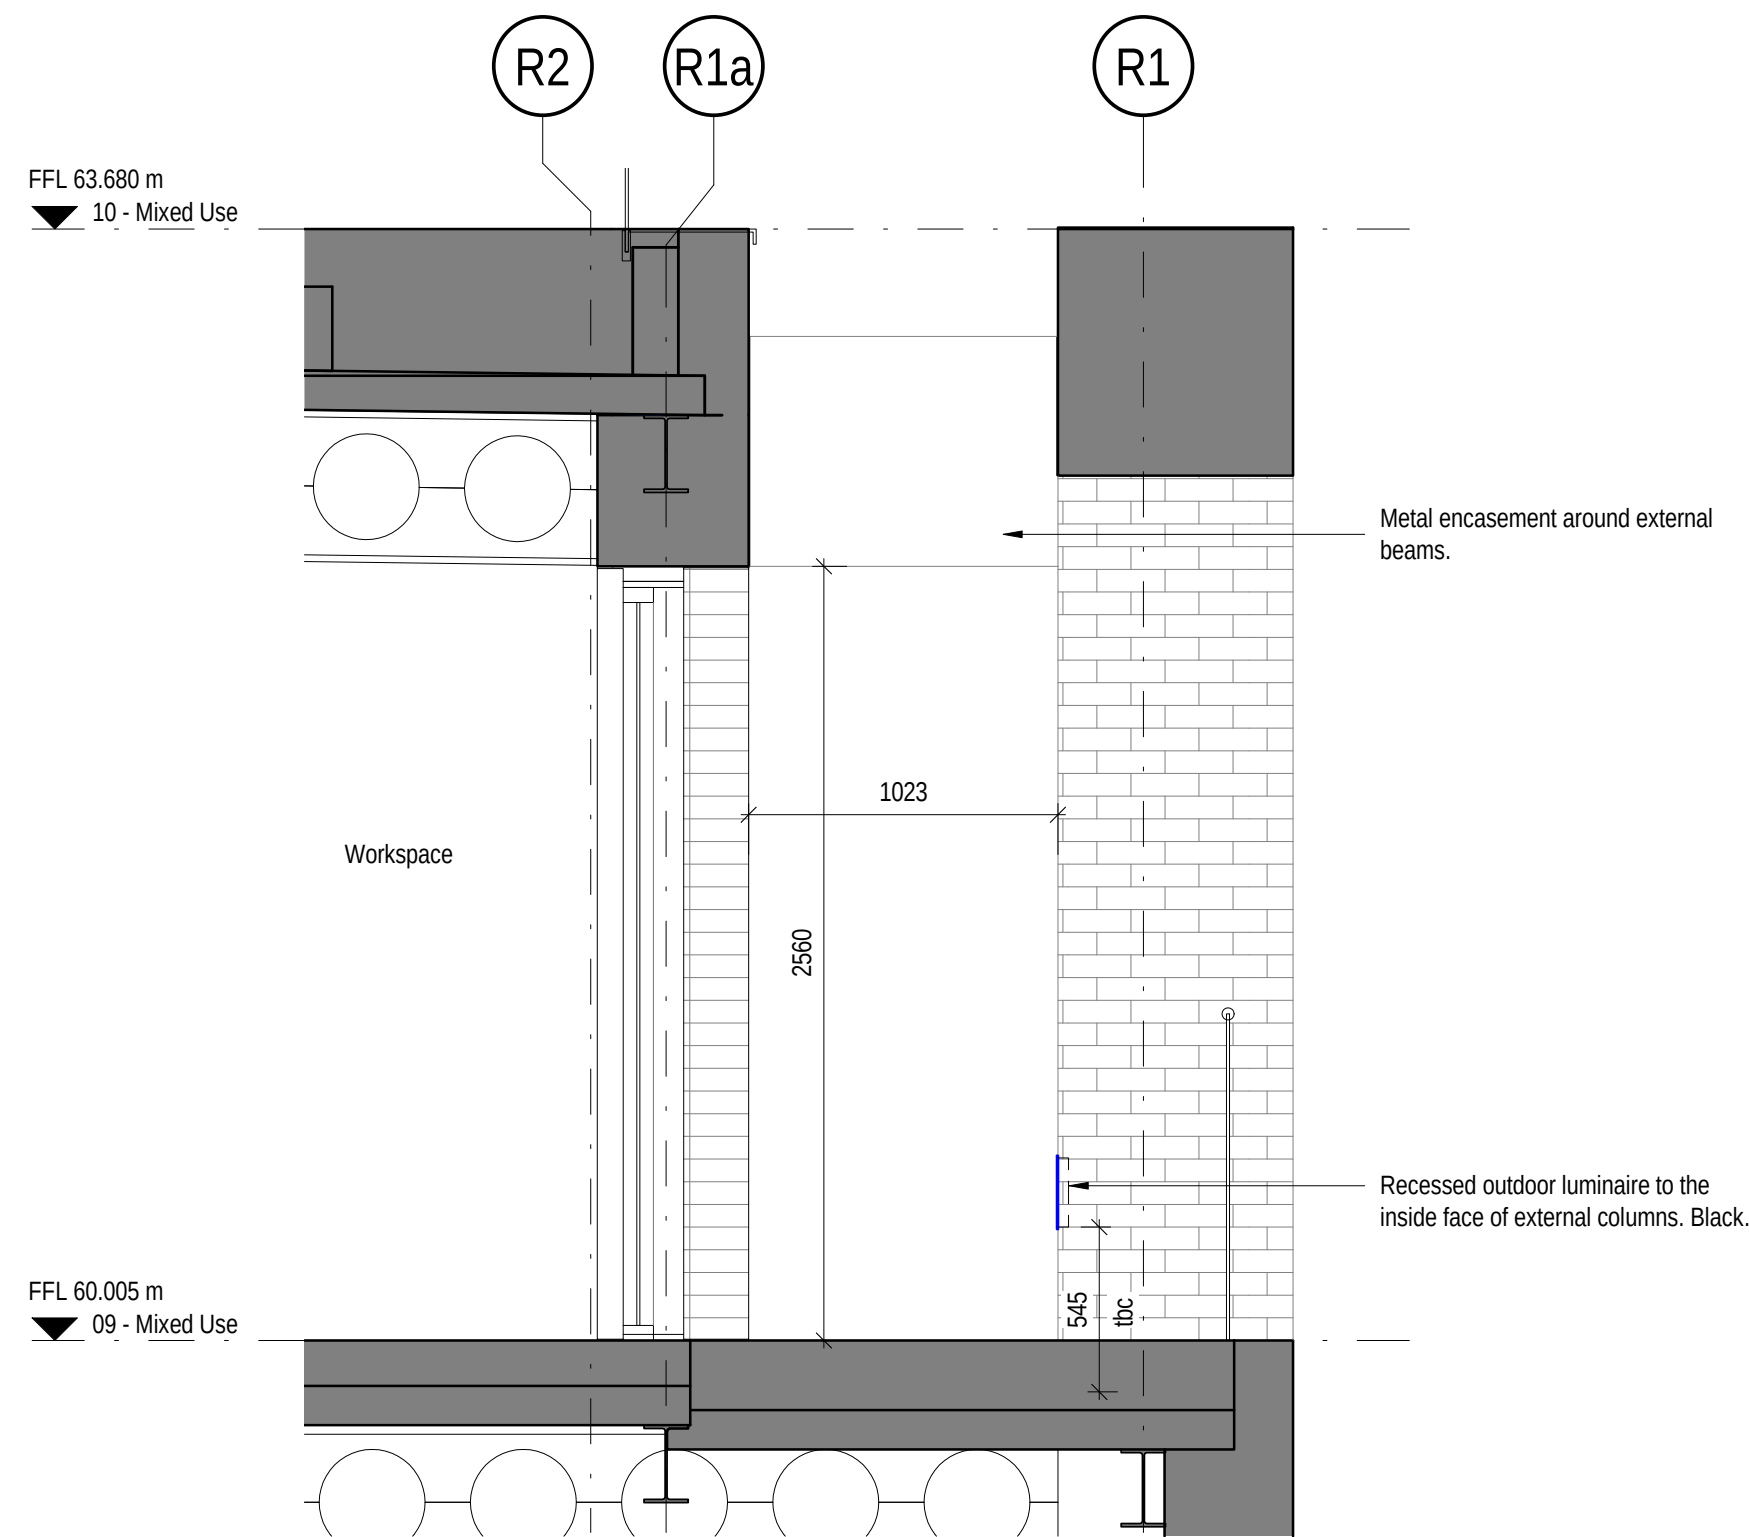

5 Zone 6 - Section A - Lighting at 9th Floor
1 : 25

Notes

Do not scale from this drawing.

All dimensions are to be checked prior to construction and any discrepancies are to be identified to the Architect.

Copyright reserved.

For external street lighting refer to M&E drawings.

B 21/04/21 Level 09 lighting changed,
A 01/03/21 Initial issue.

JB
CLH

Revisions

Status

INFORMATION

Client

Bowmer + Kirkland

Project

OGS
Manchester
Zone 6

Title

External Building Lighting
Proposal

Scale	Size	Date	Drawn	Checked
As indicated	A1	03/01/21	CLH	NS

3DReid
www.3DReid.com
Architecture Interiors Masterplanning

3D
REID

Drawing No.

190239-3DR-Z6-XX-DR-E-150

Rev.

B