



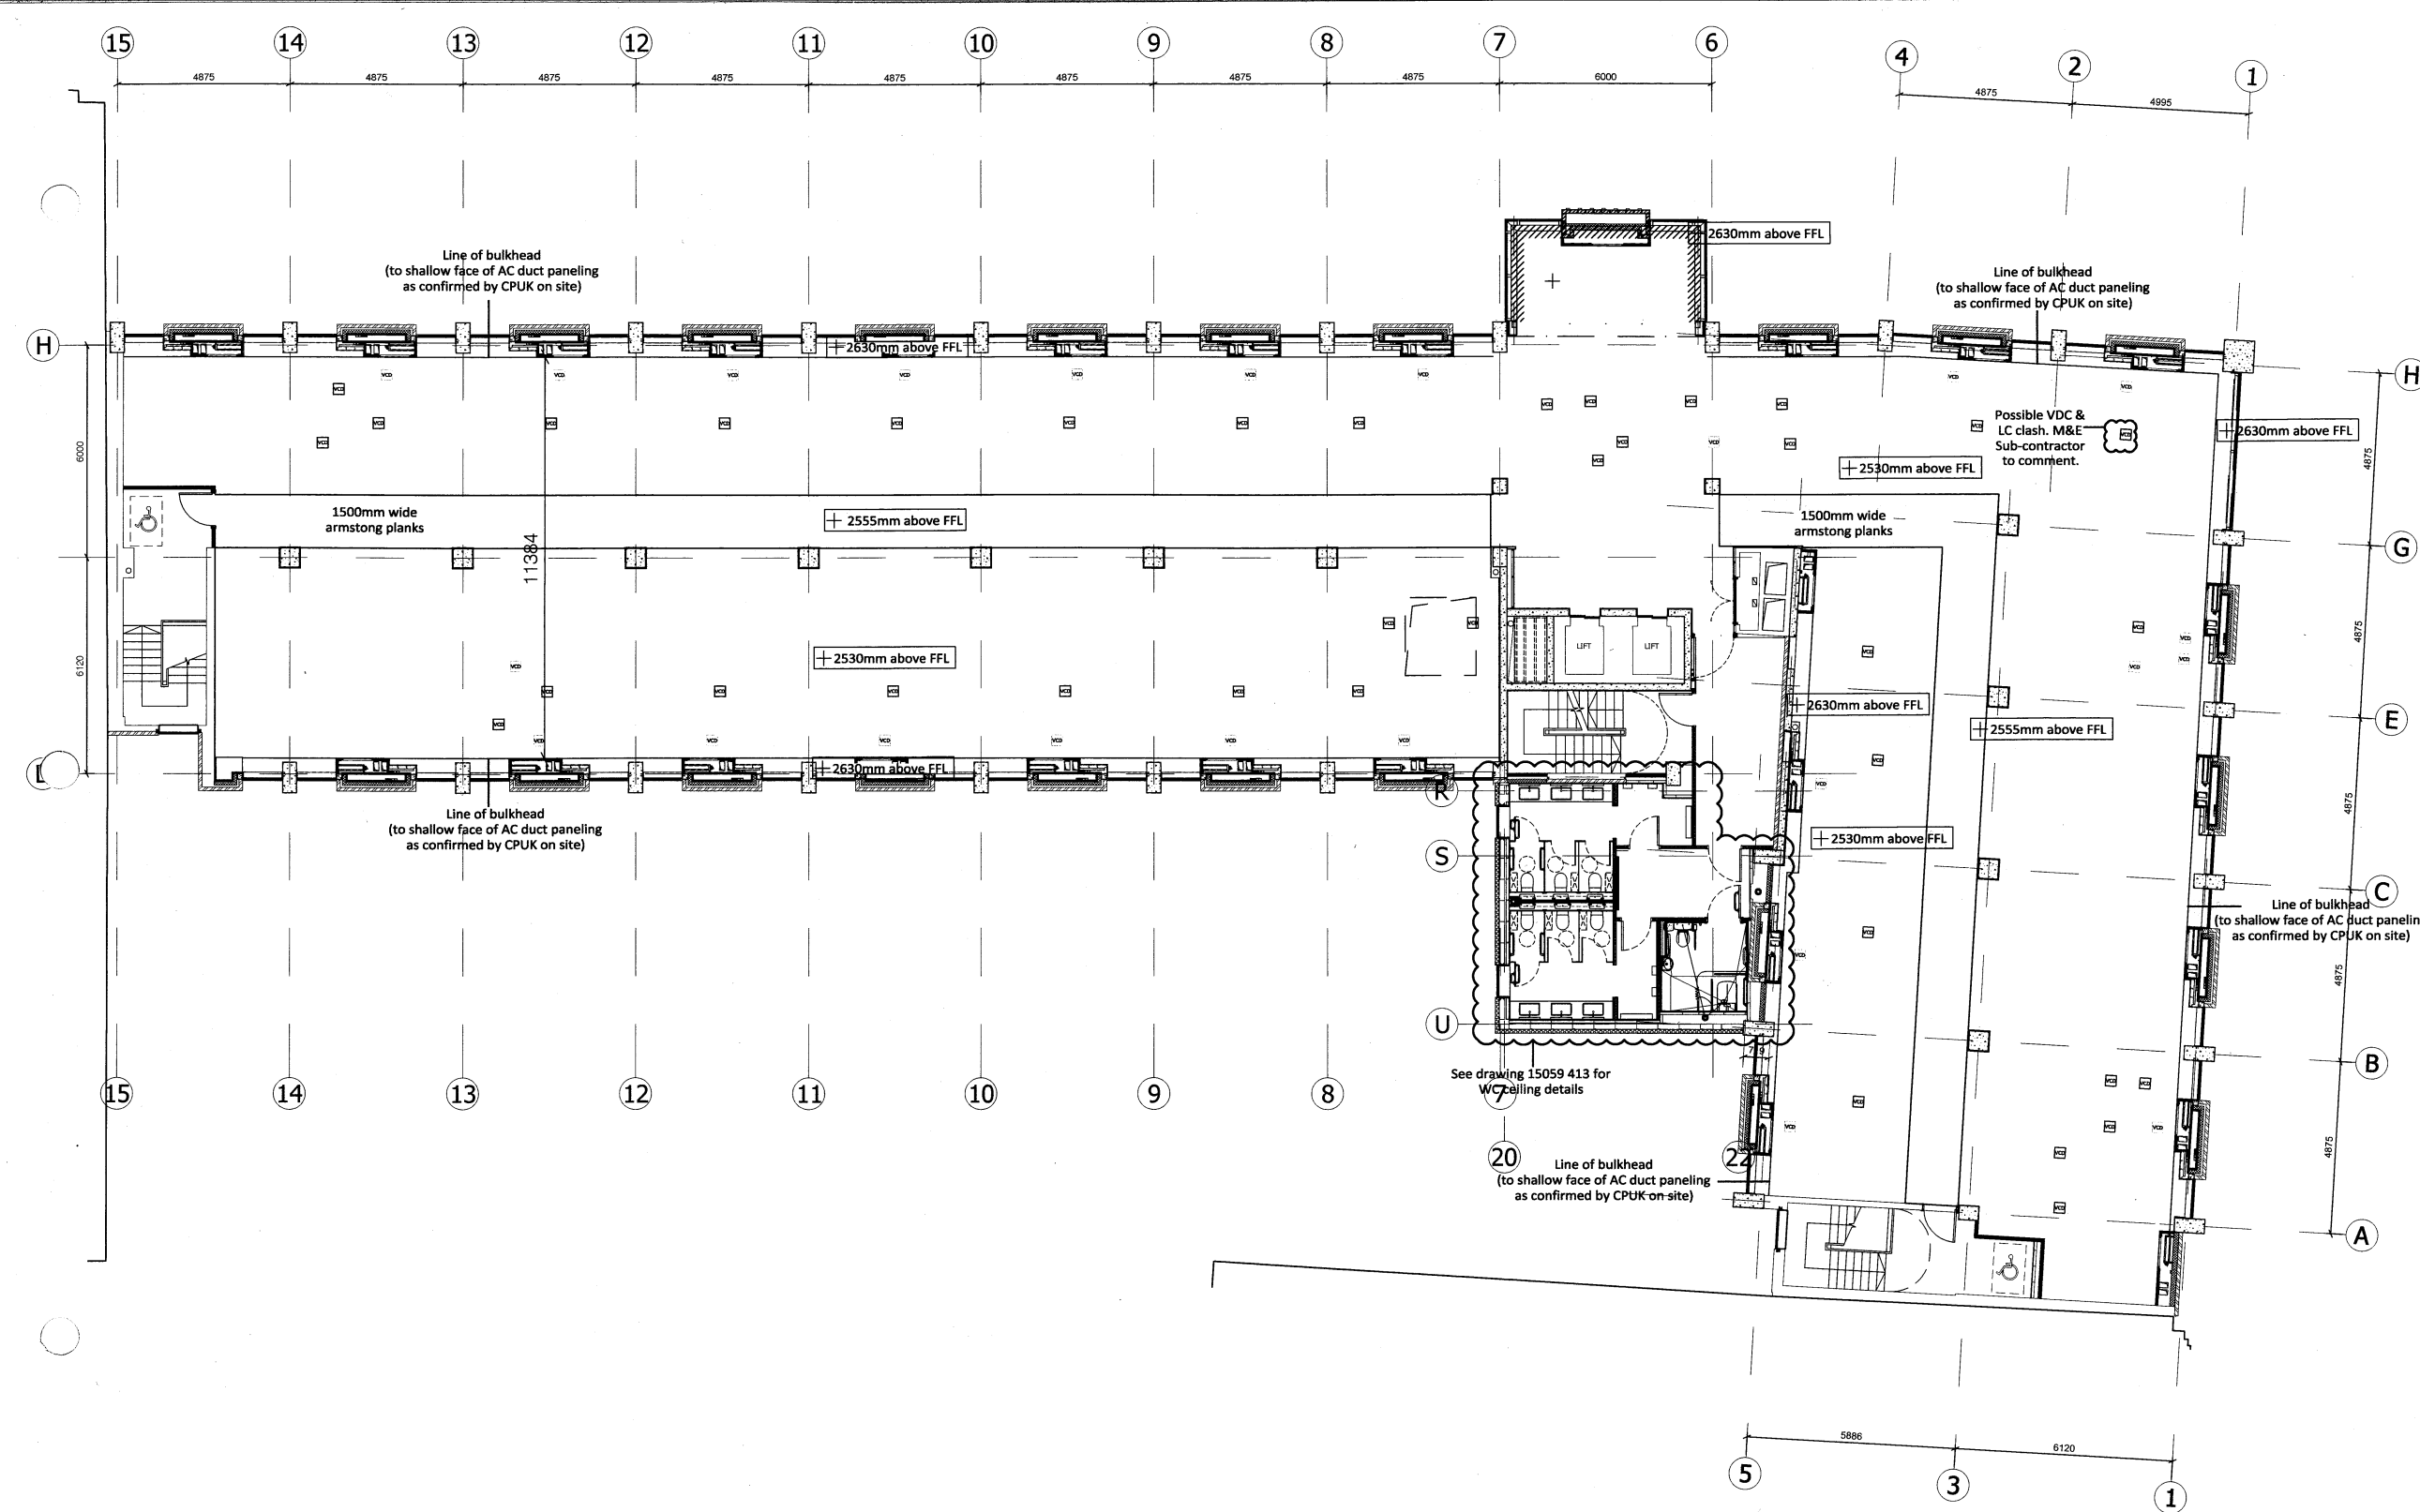

Reflected Ceiling Plan. Scale - 1:100

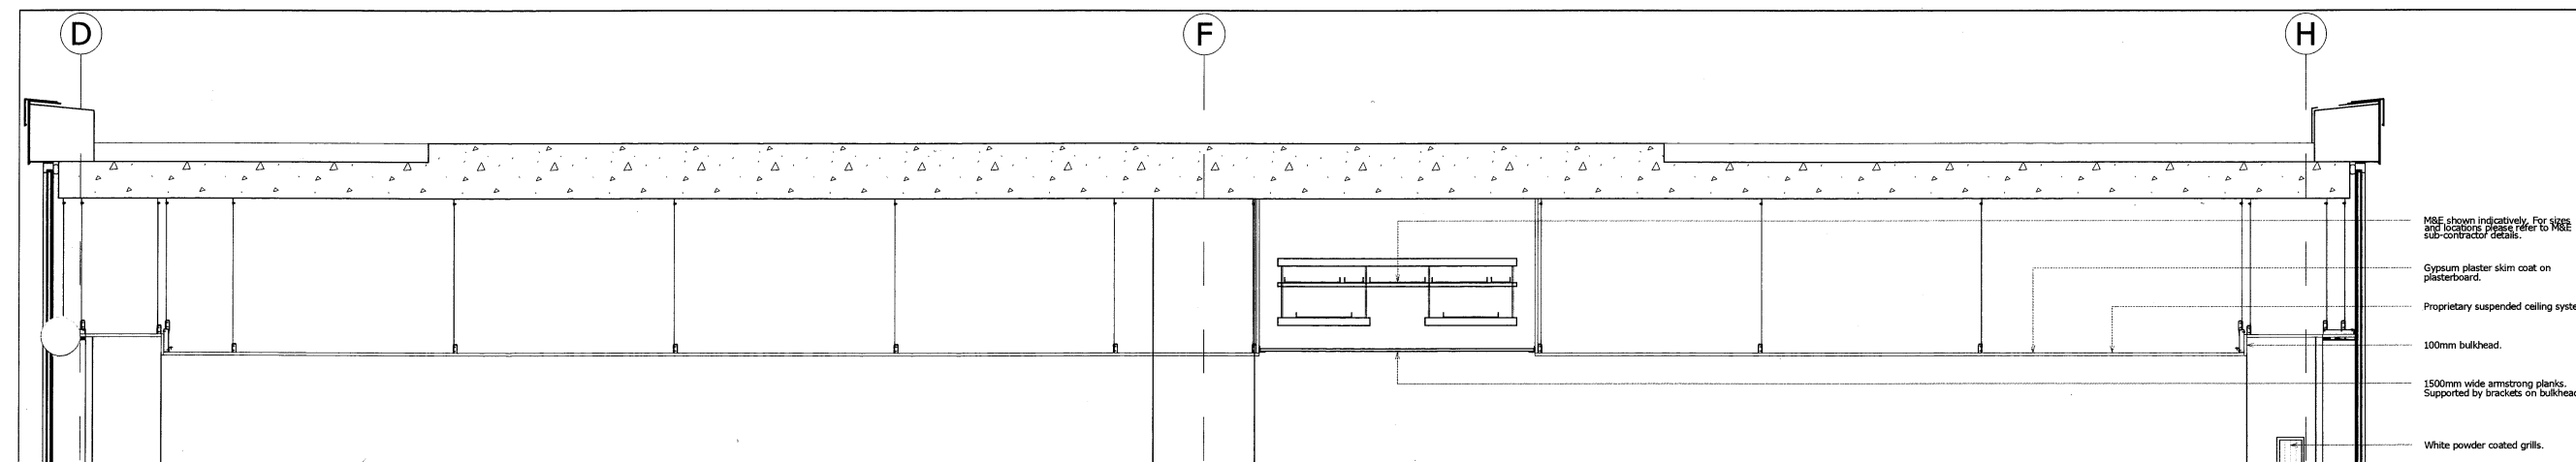

Ceiling Section. Scale - 1:20

General Notes

All site dimensions shall be verified by the Contractor on site prior to commencing any works.

Do not scale from this drawing.

Only work to written dimensions.

This drawing is the property of Fletcher-Rae (UK) Limited (t/a Fletcher-Rae) and copyright is reserved by them. The drawing is not to be copied or disclosed by or to any unauthorised persons without the prior written consent of Fletcher-Rae (UK) Limited.

NOTES:

THE DRAWING HAS BEEN BASED ON INFORMATION PROVIDED BY BRIDGE ARCHITECTS.

ALL EXPOSED SERVICES / LIGHTING / ACCESS HATCHES ETC SHOWN INDICATIVELY. PLEASE SEE M&E SUBCONTRACTOR DRAWINGS FOR ACTUAL LOCATIONS.

CEILING HEIGHTS SHOWN NOMINALLY. TO BE CONFIRMED ON SITE.

LEGEND:

- VCD ACCESS HATCH LOCATION.
- VCD ACCESS HATCH RELOCATED TO AVOID CLASHES WITH LIGHTINGS / BULKHEADS. REVISED LOCATION TO BE CONFIRMED BY M&E SUBCONTRACTOR.

Revision

Scale 1:100 / 20@A1
Status RECORD
Drawn by SH
Date March 2017
Client

Cushman and Wakefield

Project
Cornerblock, Deansgate Manchester

Drawing Description
Proposed Sixth Floor Reflected Ceiling Plan

Drawing No. 15059 R411

Rev. /

fletcher|rae

Architects Master Planners Designers

Hill Quays, 5 Jordan Street, Manchester, M15 4PY

t +44 (0)161 242 1140
f +44 (0)161 242 1141
w www.fletcher-rae.com
e info@fletcher-rae.com