


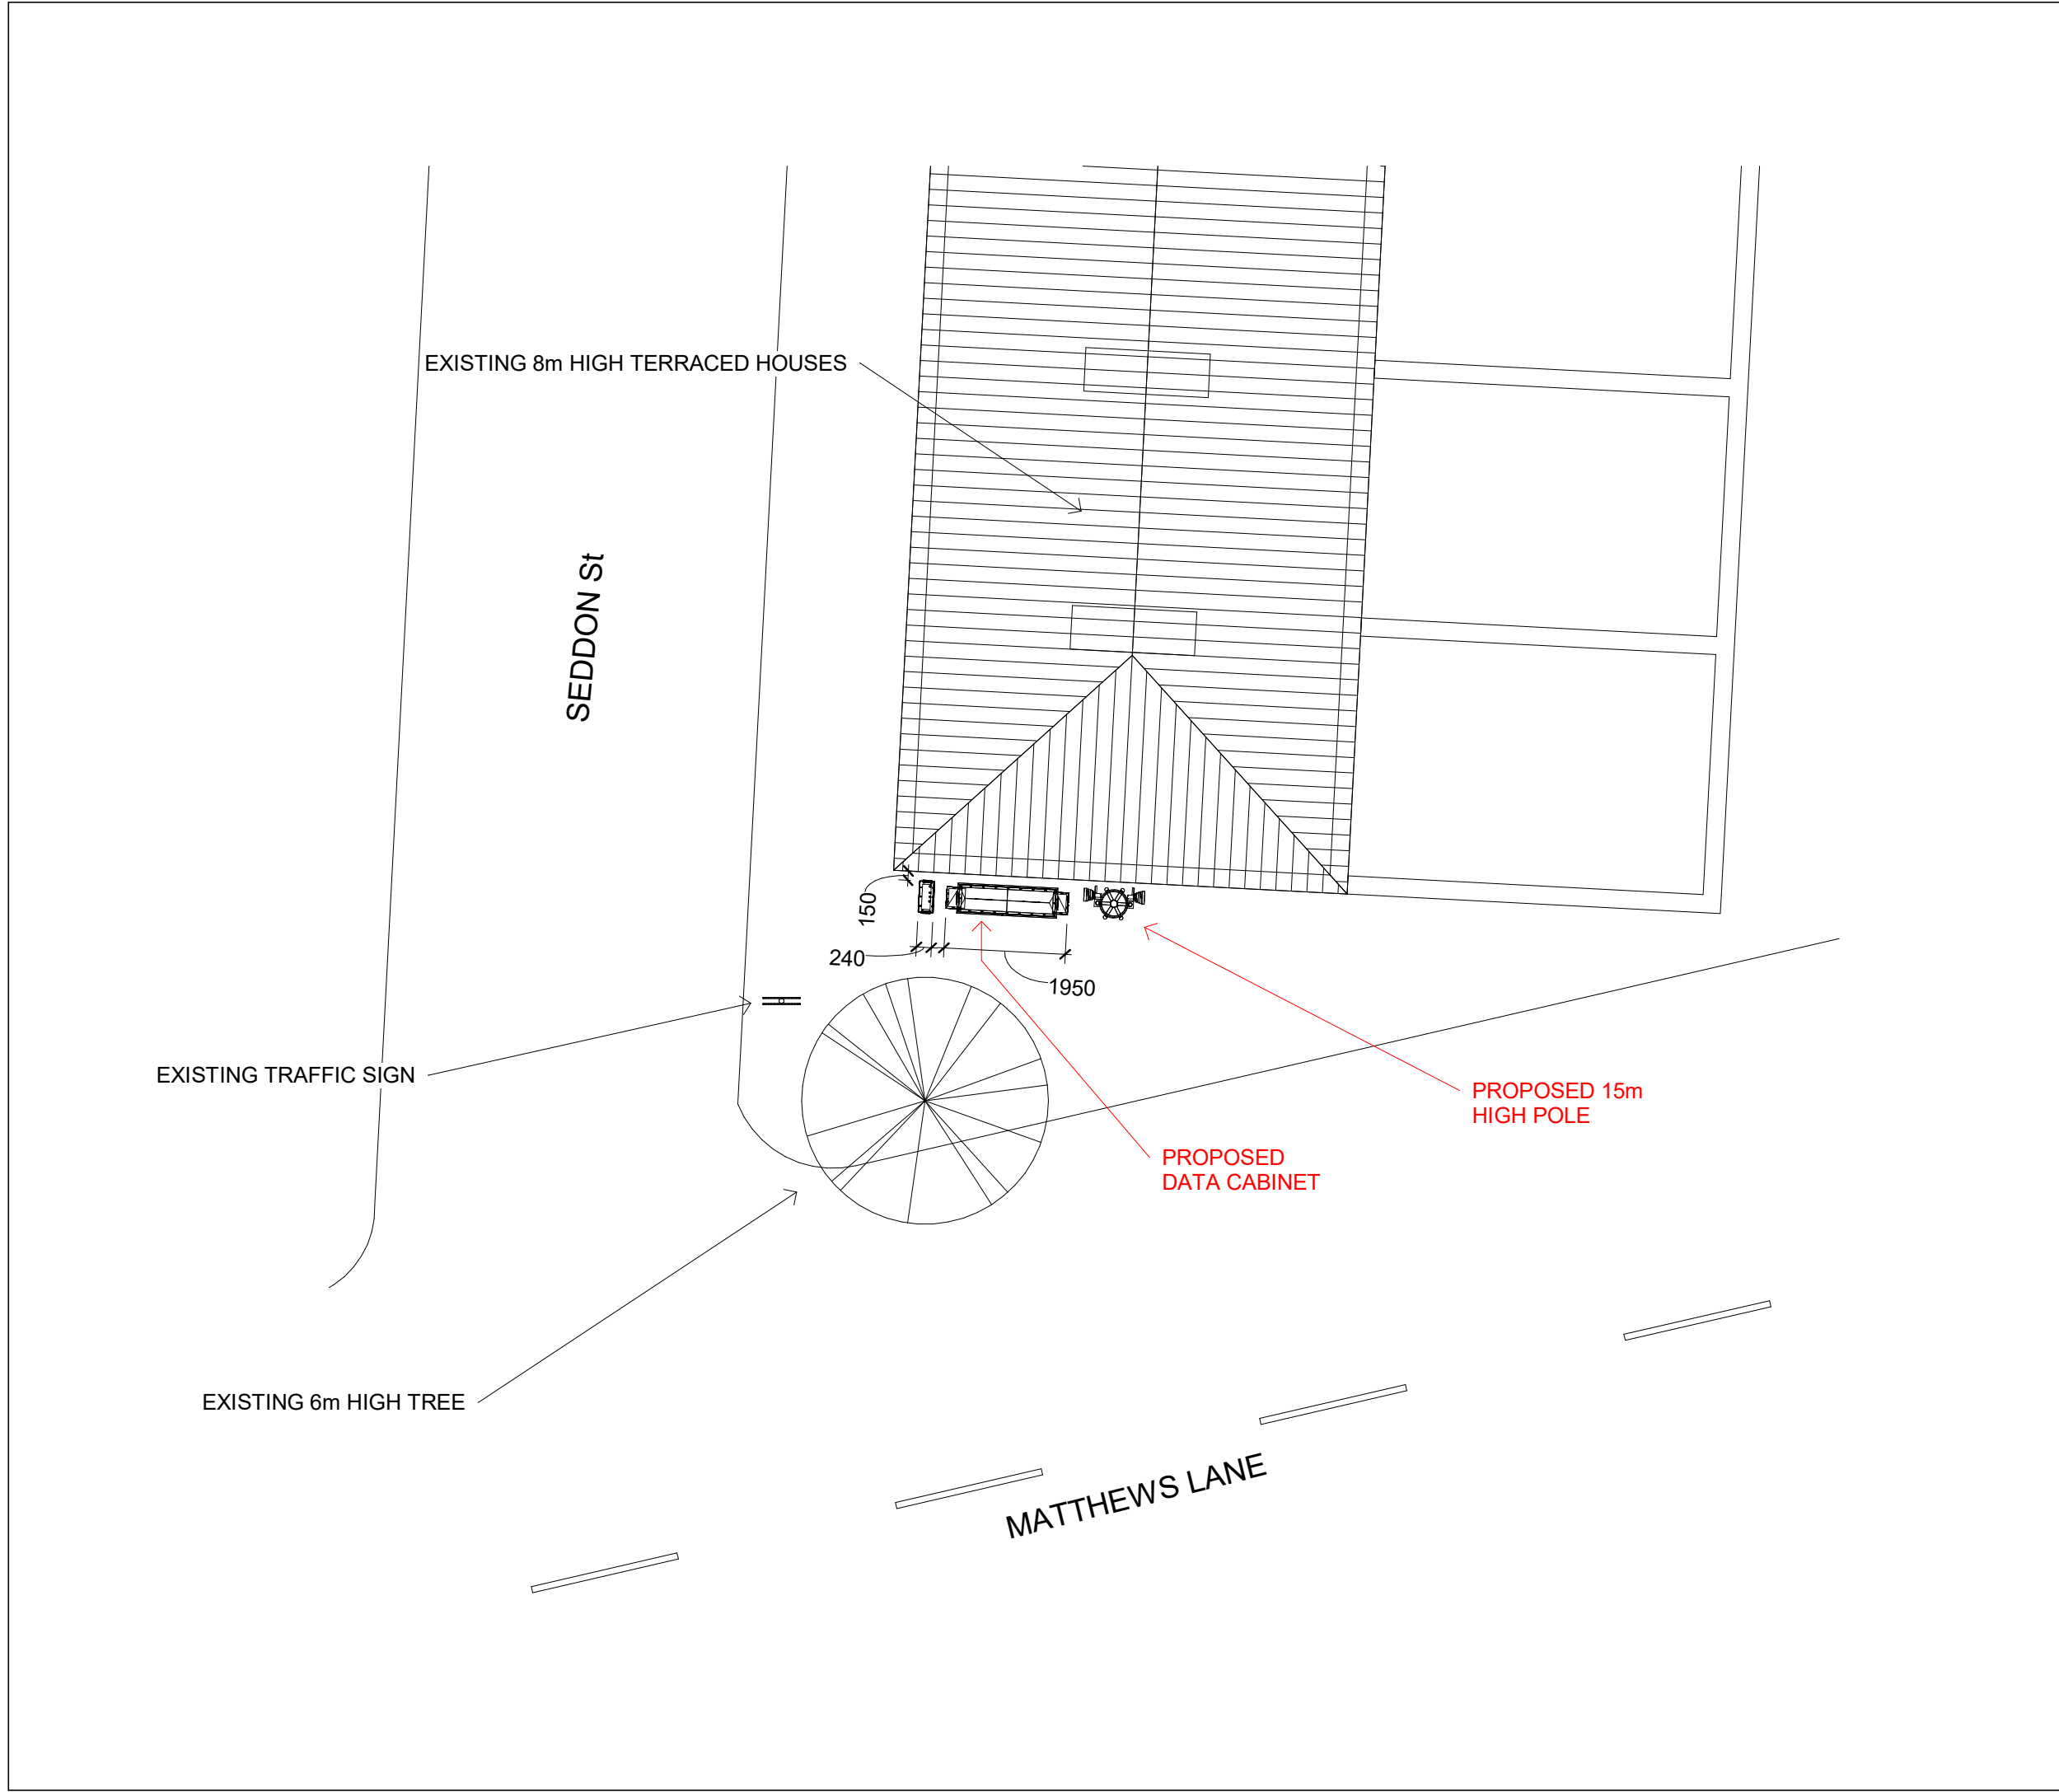

ALL DIMENSIONS ARE IN mm UNLESS OTHERWISE STATED

APPROVAL	PURPOSE OF ISSUE	
----------	------------------	--

No.	Description	Date

IX WIRELESS LTD

PROJECT
Manchester Sch3 SP1

SHEET
Site Plan

CLIENT
IX Wireless LTD

Drawn by BU	Checked by Checker	Date 07/10/21
----------------	-----------------------	------------------

Scale (@ A3) 1 : 100	DRAWING NUMBER IXW-PP-MAN-SCH3SP1-001
REV	