


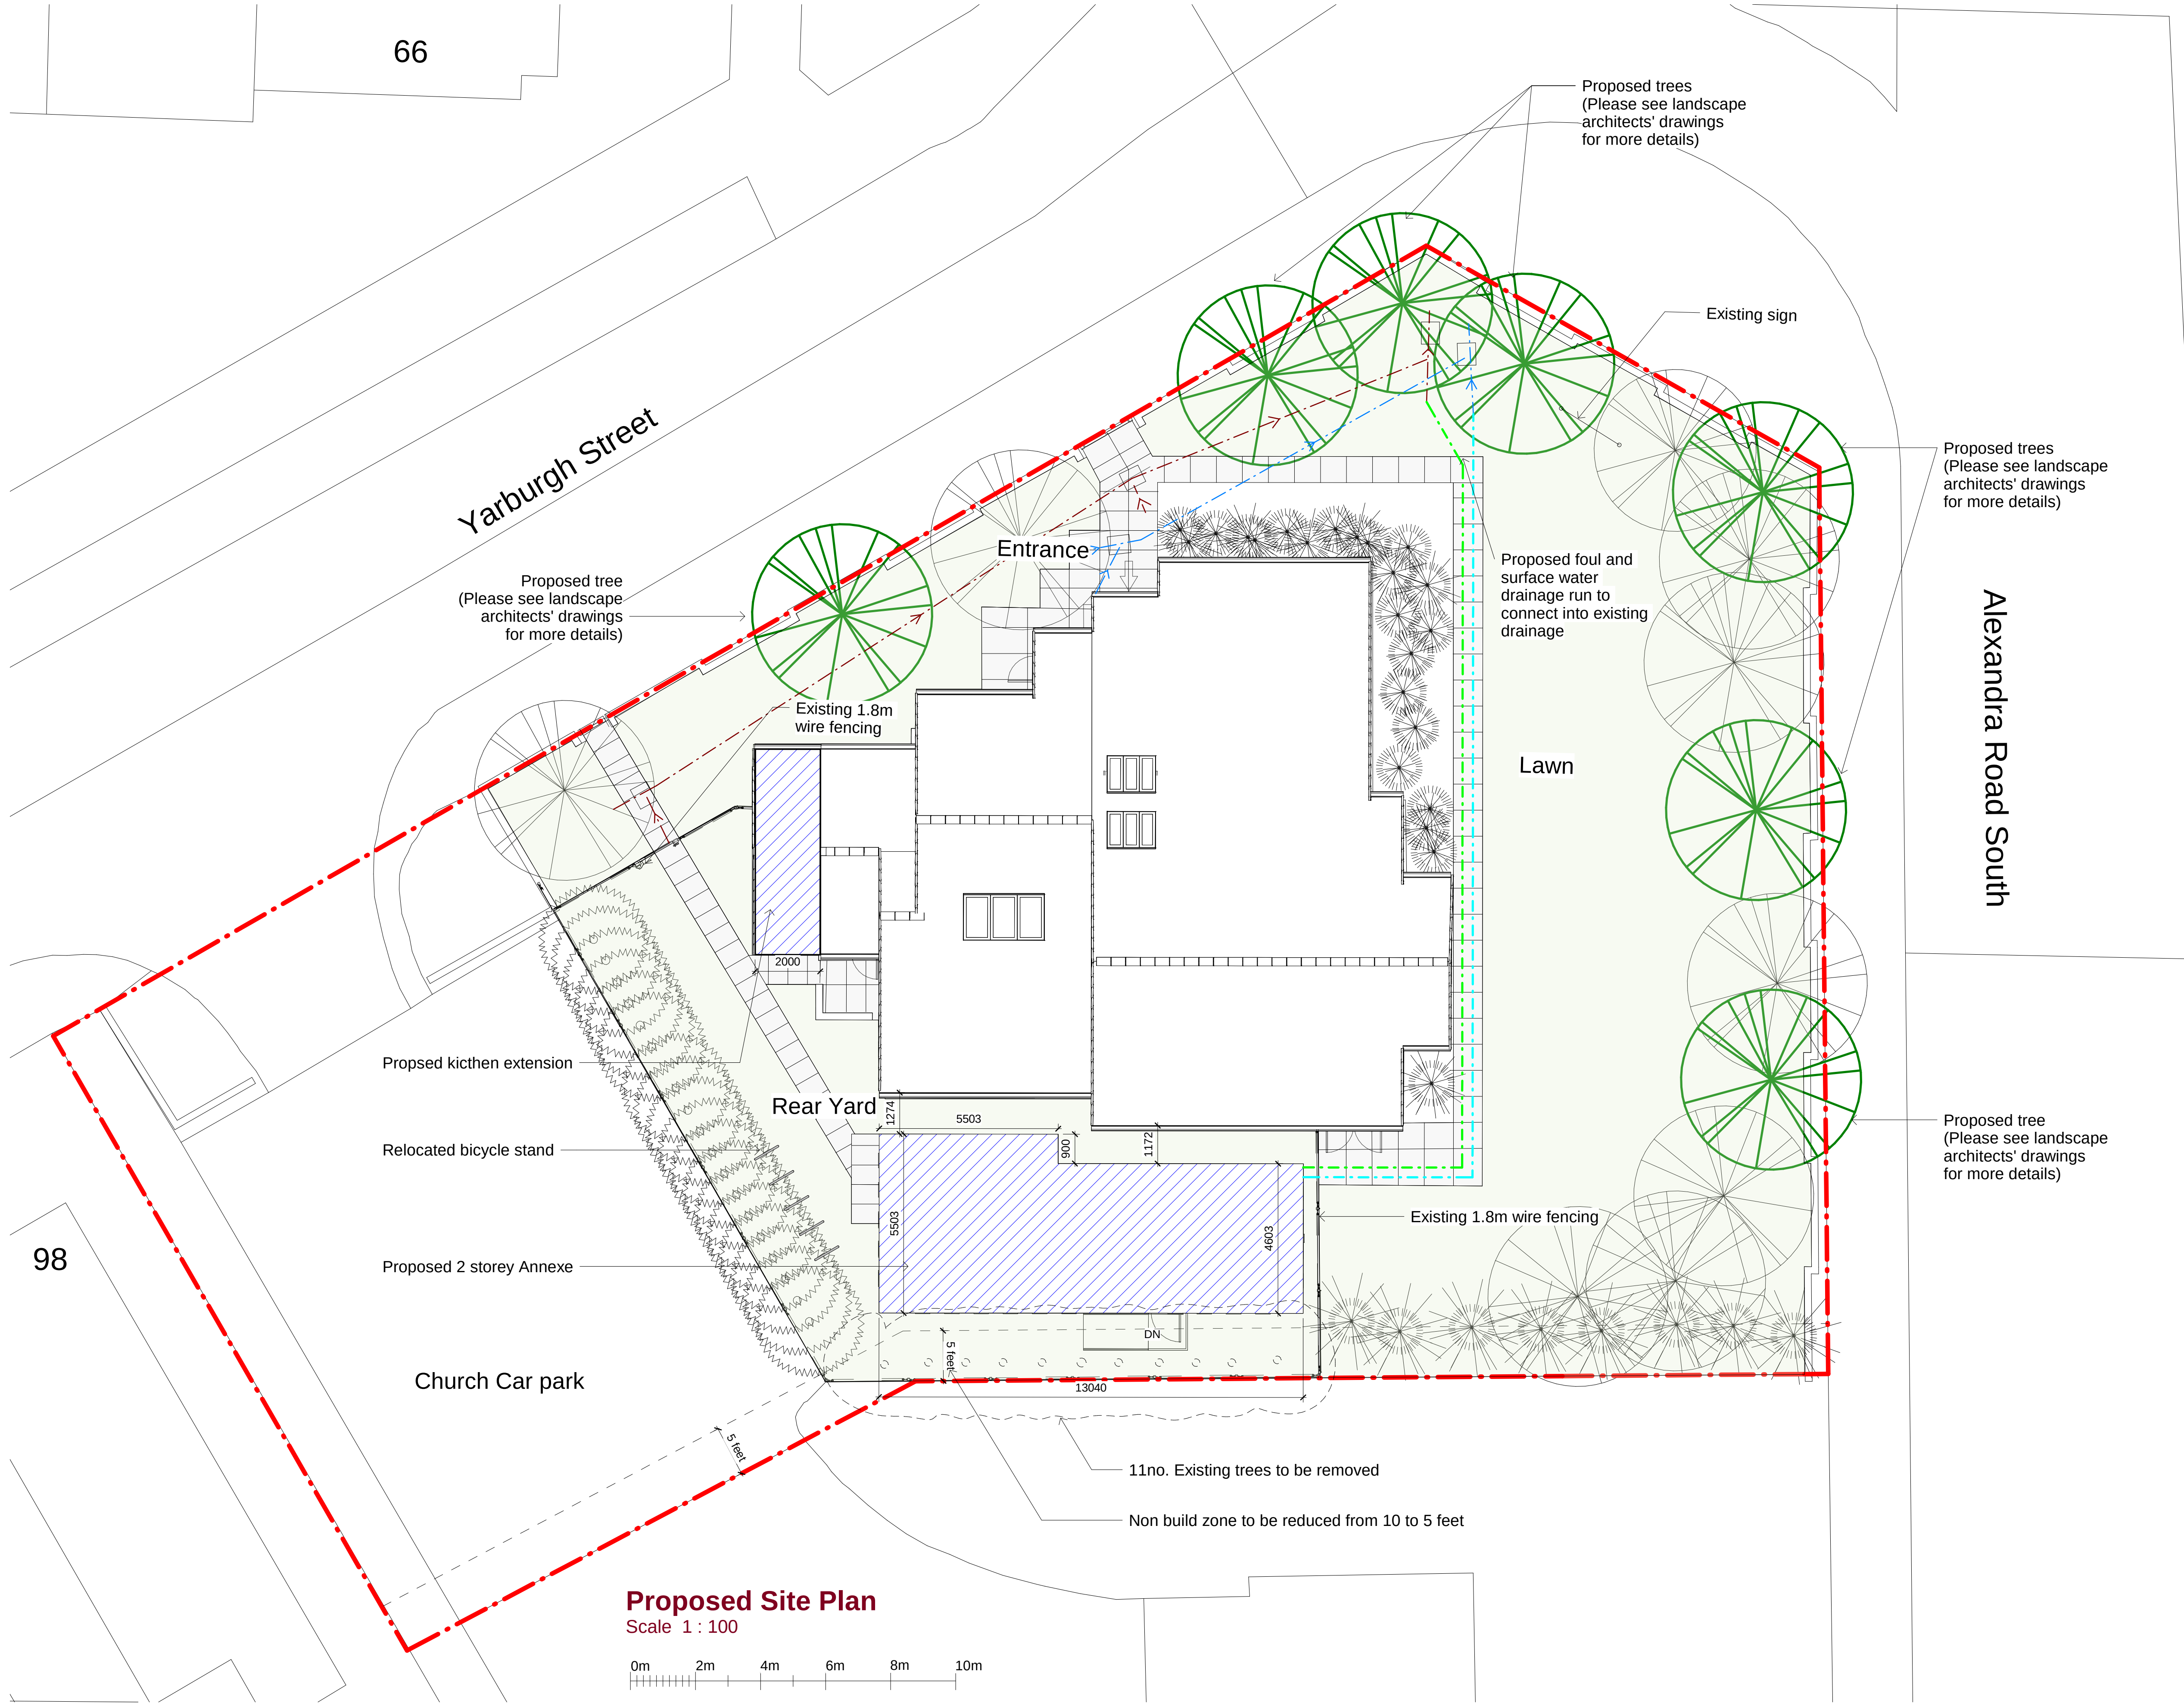

© This Drawing & Design is the copyright of Jenkins Design Services Ltd and should not be reproduced without written consent.

Contractors are to check all levels & dimensions on site prior to site works commencing & report discrepancies to the Designers.

DO NOT SCALE FROM THIS DRAWING

PLANNING

KEY

- Proposed Extension and Annexe Building
- Existing Tree Type 1
- Existing Tree Type 2
- Existing Tree Type 3
- Existing Shrub planting
- Existing Foul Drainage Run
- Existing Surface Water Drainage Run
- Proposed Trees (7no. in total)
- Proposed Foul Drainage Run
- Proposed Surface Water Drainage Run

Rev	Description	By	Chk	Date
Project:	Manchester Chinese Christian Church 100 Yarburgh Street, Manchester, M16 7EH			
Title:	Proposed Site Plan			
Client:	MCCC			
Drawn By:	AL	Checked By:	BJ	on 13/11/20
Original Size:	A1	Project Number:	22042	
Drawing Number:	B1-00-DR-A-2001			REV

