


SITE LOCATION

 


Reproduced by permission of Ordnance Survey on behalf of the Controller of Her Majesty's Stationery Office
All rights reserved. © Crown Copyright licence no. 100022432

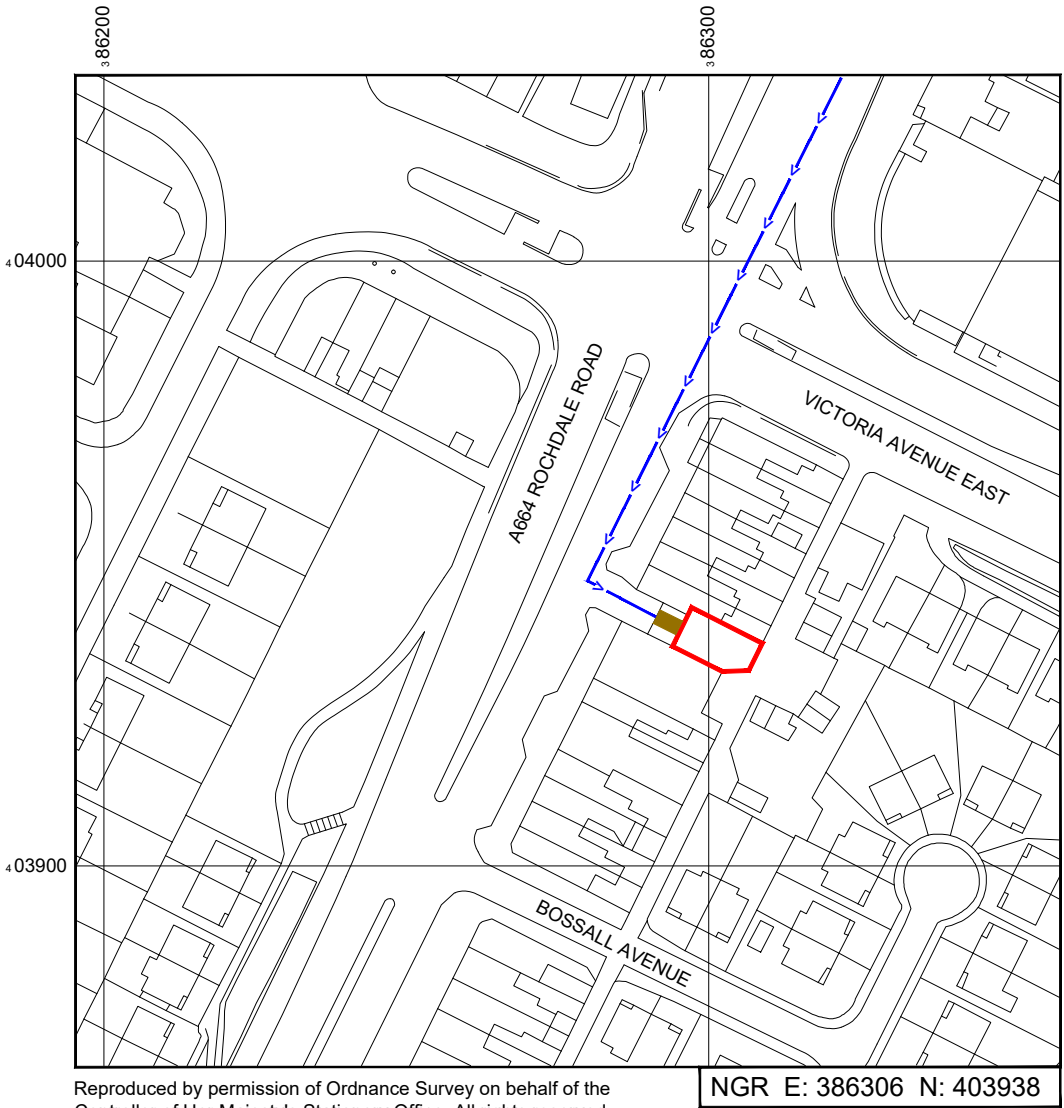


Reproduced by permission of Ordnance Survey on behalf of the
Controller of Her Majesty's Stationery Office. All rights reserved.
© Crown Copyright licence no. 100022432

SITE AREA PLAN



SITE LOCATION PLAN

 

GOOGLE MAPS QR CODE

GOOGLE MAPS - <https://goo.gl/maps/VJsPWwoGcBEP85C47>

GOOGLE STREETVIEW - <https://goo.gl/maps/xYwfWbmTFip>



SITE PHOTOGRAPH

NOTES:

1. ALL DIMENSIONS IN MM UNLESS OTHERWISE NOTED.

DIRECTIONS TO SITE:

FROM M60 JUNCTION 20 HEAD TOWARDS MANCHESTER ON THE
A664 ROCHDALE ROAD. THE SITE ENTRANCE IS ON THE RIGHT
HAND SIDE AFTER APPROX 240m.

Site Provider's
Property Boundary:



Access Route To Site:



Access Route:



Master:	MBNL / EE / H3G:	Project:	Purpose of Issue:	Issue:
M002	H3G	3UK UNILATERAL	Planning	B
Date:	05/09/2021	Revision / Upgrade Description:		
Drawn:	B.Devlin	Revised to PACS Comments		
Checked:	S.Taylor			
Approved:	S.Taylor			
Master:	MBNL / EE / H3G:	Project:	Purpose of Issue:	Issue:
M001	H3G	3UK UNILATERAL	Planning	A
Date:	09/07/2021	Revision / Upgrade Description:		
Drawn:	J.Boote	First Issue		
Checked:	J.Stockdale			
Approved:	J.Stockdale			



Hutchison 3G UK Limited
Star House, 20 Grenfell Road
Maidenhead, SL6 1EH
Tel: 01628 765 000
Fax: 01628 765 001

H3G Base Station Information line:
0845 6043000
Available 8am-8pm Monday to Friday

Design Consultant & Principal Contractor:



Great British Communications
Lapwing House, Block 3 Forward Point,
Tan House Lane, Widnes, Cheshire, WAB 0SL
t. 44 (0)151 420 4128
www.gbcservices.co.uk

Site Name:	AUBREY LEE & CO		
Site ID:	975438		
Address:	1170 ROCHDALE ROAD, BLACKLEY, MANCHESTER, GREATER MANCHESTER, M9 6ER		
Title:	002 SITE LOCATION PLAN		
Project:	3UK UNILATERAL		
Purpose of Issue:	GENERAL ARRANGEMENT		
EE Cell ID:	MBNL Cell ID:	3UK Cell ID:	
99409	MAN114	M0372	
Master Drawing No:		Issue:	
975438_MAN114_99409_M0372_M002		B	




Asset Reference	Asset Description:	Asset Status:	Antenna / Dish / MHA / RRU / Equipment Access Description:	Asset Reference	Asset Description:	Asset Status:	Antenna / Dish / MHA / RRU / Equipment Access Description:	Asset Reference	Asset Description:	Asset Status:	Antenna / Dish / MHA / RRU / Equipment Access Description:
EA1	Antenna	To be removed	Cherry picker Access Only	CAB1-2	Cabinets	To be removed	Unrestricted Access	RRU1-3	RRU	Proposed	Unrestricted Access
EB1	Antenna	To be removed	Cherry picker Access Only	CAB3-5	Cabinets	Existing	Unrestricted Access	RRU4-9	RRU	Proposed	Unrestricted Access
EC1	Antenna	To be removed	Cherry picker Access Only	CAB6-8	Cabinet	Proposed	Unrestricted Access	RRU10-12	RRU	Proposed	Unrestricted Access
A1-A2	Antenna	Proposed	Cherry picker Access Only					BB1	BOB Bottom	Proposed	Unrestricted Access
B1-B2	Antenna	Proposed	Cherry picker Access Only					PR1-6	Pass. Router	Proposed	Unrestricted Access
C1-C2	Antenna	Proposed	Cherry picker Access Only								

NOTES:

1. ALL DIMENSIONS IN MM UNLESS OTHERWISE NOTED.

DEFINED ACCESS ROUTE DESCRIPTION FROM SITE ENTRANCE TO THE EQUIPMENT:

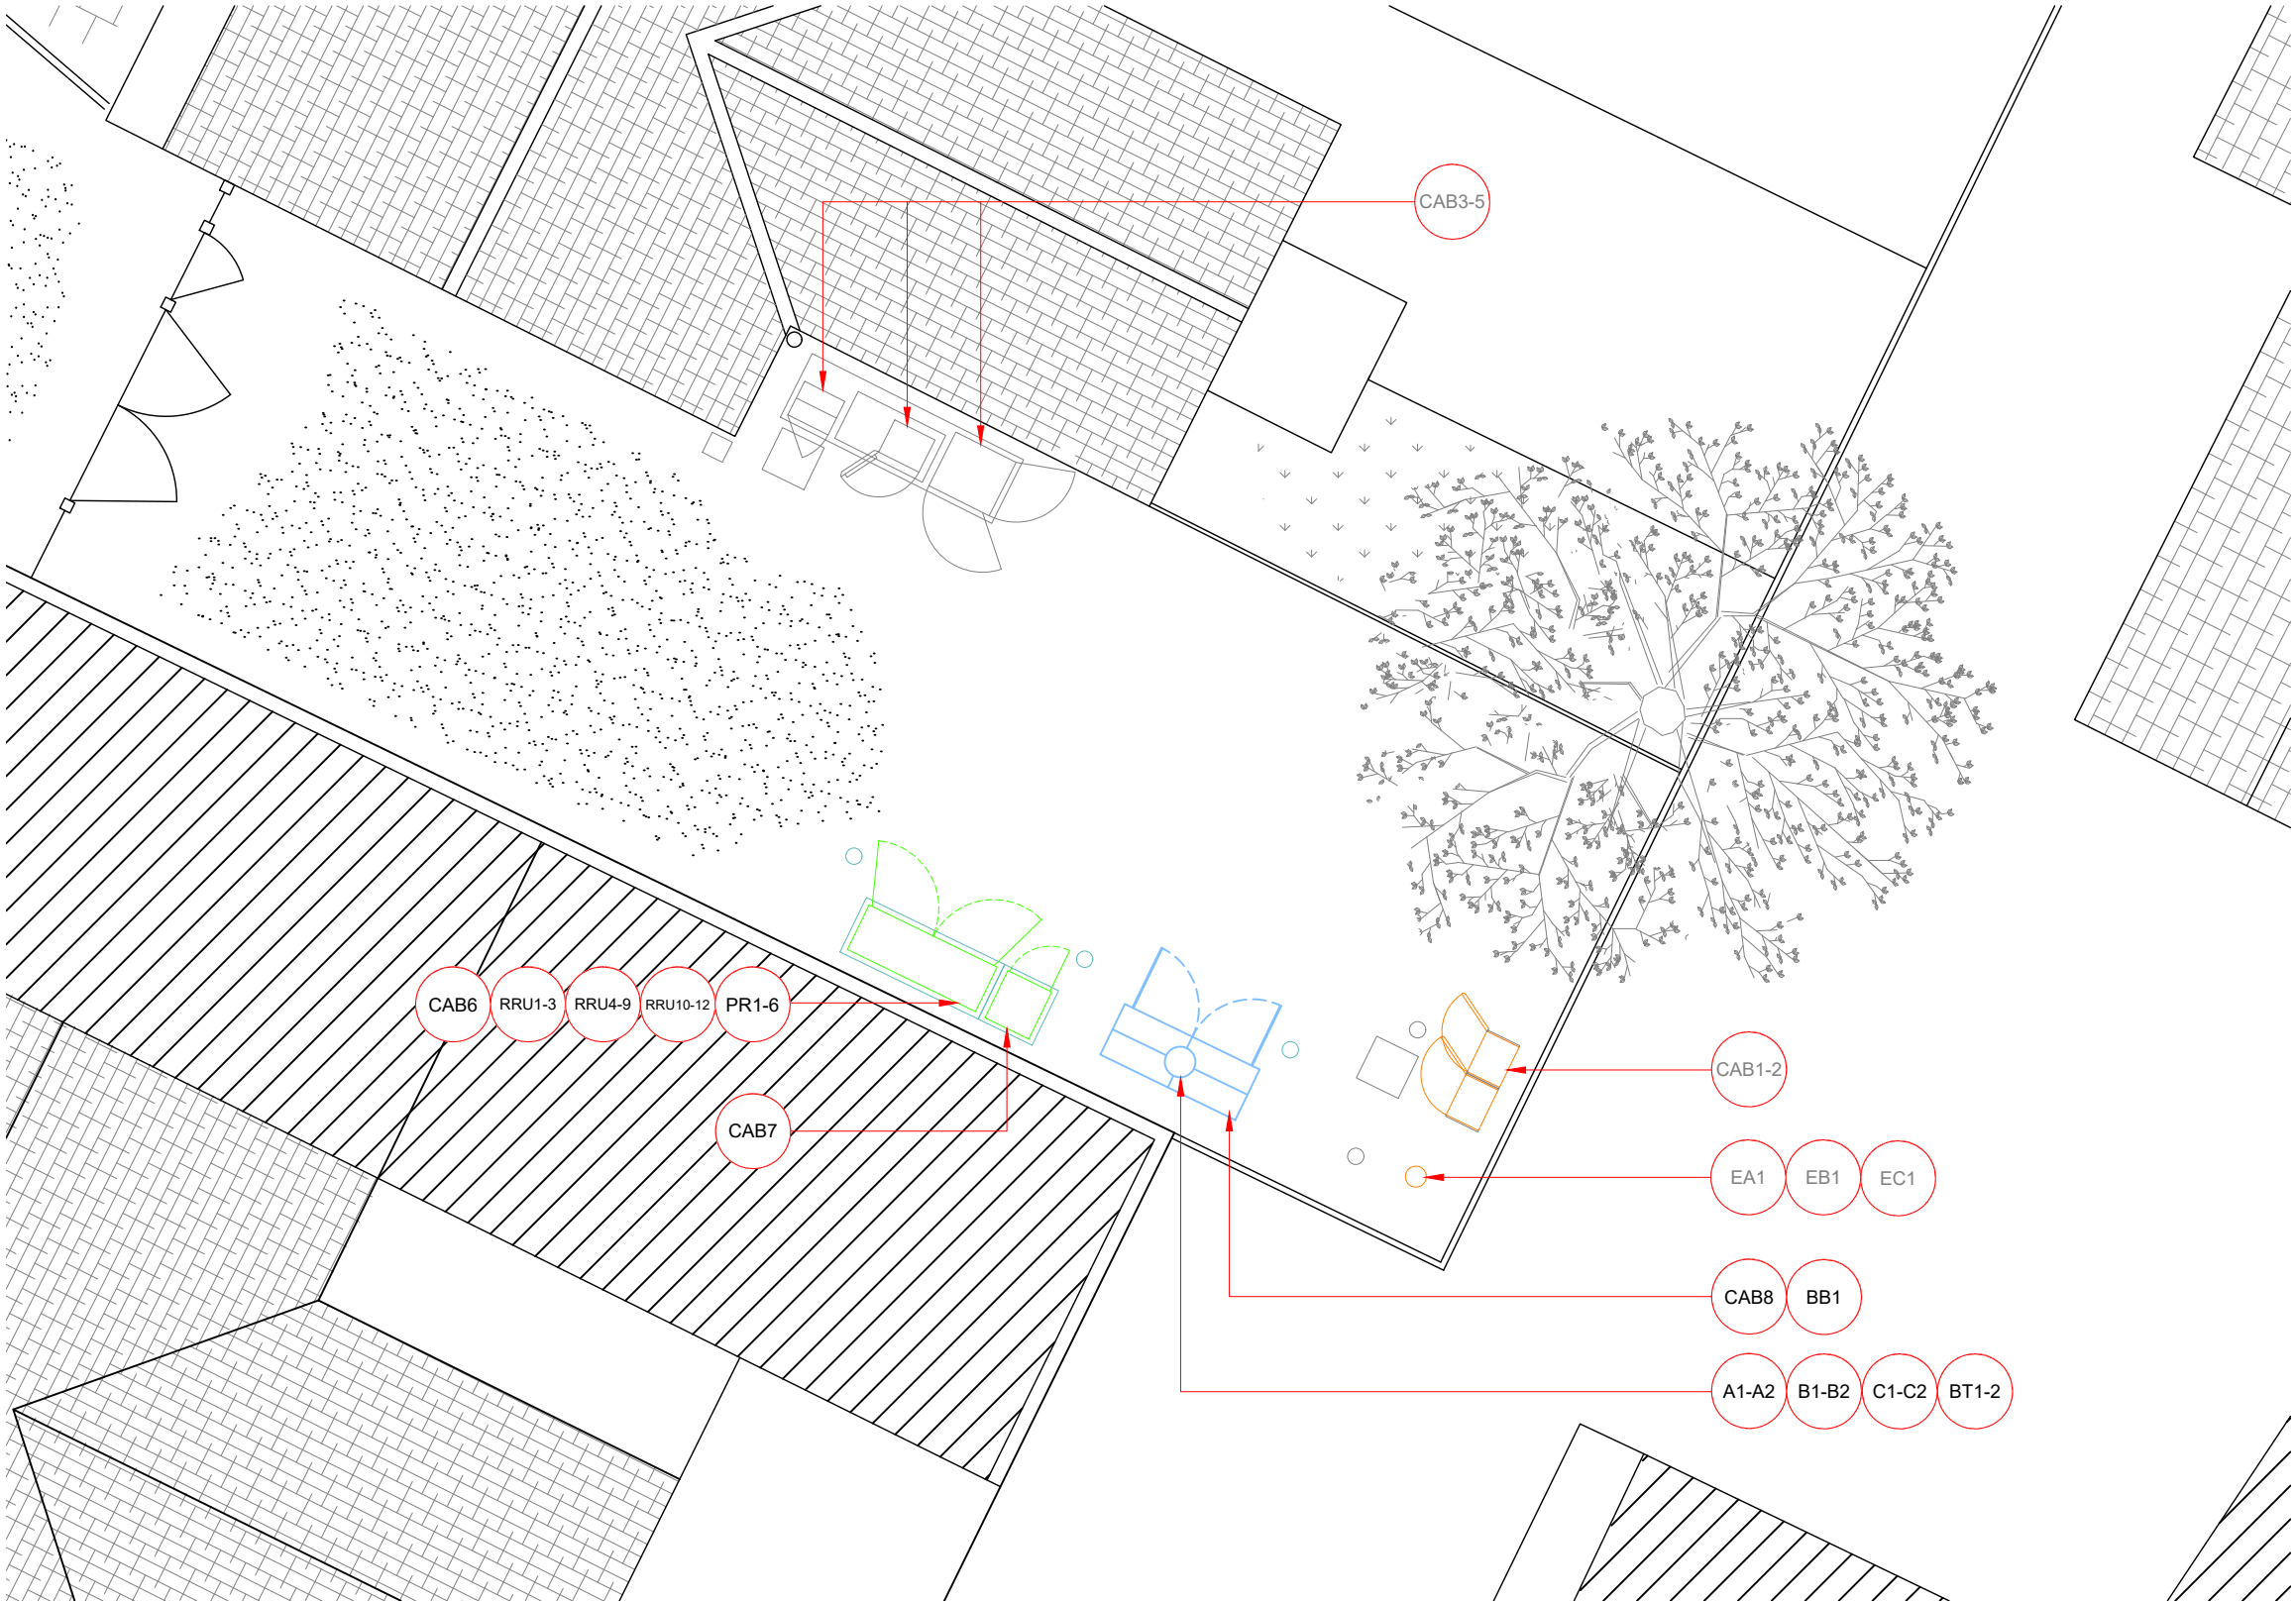

ACCESS PLAN

0 1:200 5m 8

Master:	MBNL / EE / H3G:	Project:	Purpose of Issue:	Issue:
M002	H3G	3UK UNILATERAL	Planning	B
Date:	05/09/2021	Revision / Upgrade Description:		
Drawn:	B.Devlin	Revised to PACS Comments		
Checked:	S.Taylor			
Approved:	S.Taylor			
Master:	MBNL / EE / H3G:	Project:	Purpose of Issue:	Issue:
M001	H3G	3UK UNILATERAL	Planning	A
Date:	09/07/2021	Revision / Upgrade Description:		
Drawn:	J.Boote	First Issue		
Checked:	J.Stockdale			
Approved:	J.Stockdale			



Hutchison 3G UK Limited
Star House, 20 Grenfell Road
Maidenhead, SL6 1EH
Tel: 01628 765 000
Fax: 01628 765 001


H3G Base Station Information line:
0845 6043000
Available 8am-8pm Monday to Friday

Design Consultant & Principal Contractor:


GBC

Great British Communications
Lapwing House, Block 3 Forward Point,
Tan House Lane, Widnes, Cheshire, WAB 0SL
t. 44 (0)151 420 4128
www.gbcservices.co.uk

Site Name:	AUBREY LEE & CO		
Site ID:	975438		
Address:	1170 ROCHDALE ROAD, BLACKLEY, MANCHESTER, GREATER MANCHESTER, M9 6ER		
Title:	003 ACCESS PLAN		
Project:	3UK UNILATERAL		
Purpose of Issue:	GENERAL ARRANGEMENT		
EE Cell ID:	MBNL Cell ID:	3UK Cell ID:	
99409	MAN114	M0372	
Master Drawing No:			Issue:
975438_MAN114_99409_M0372_M002			B

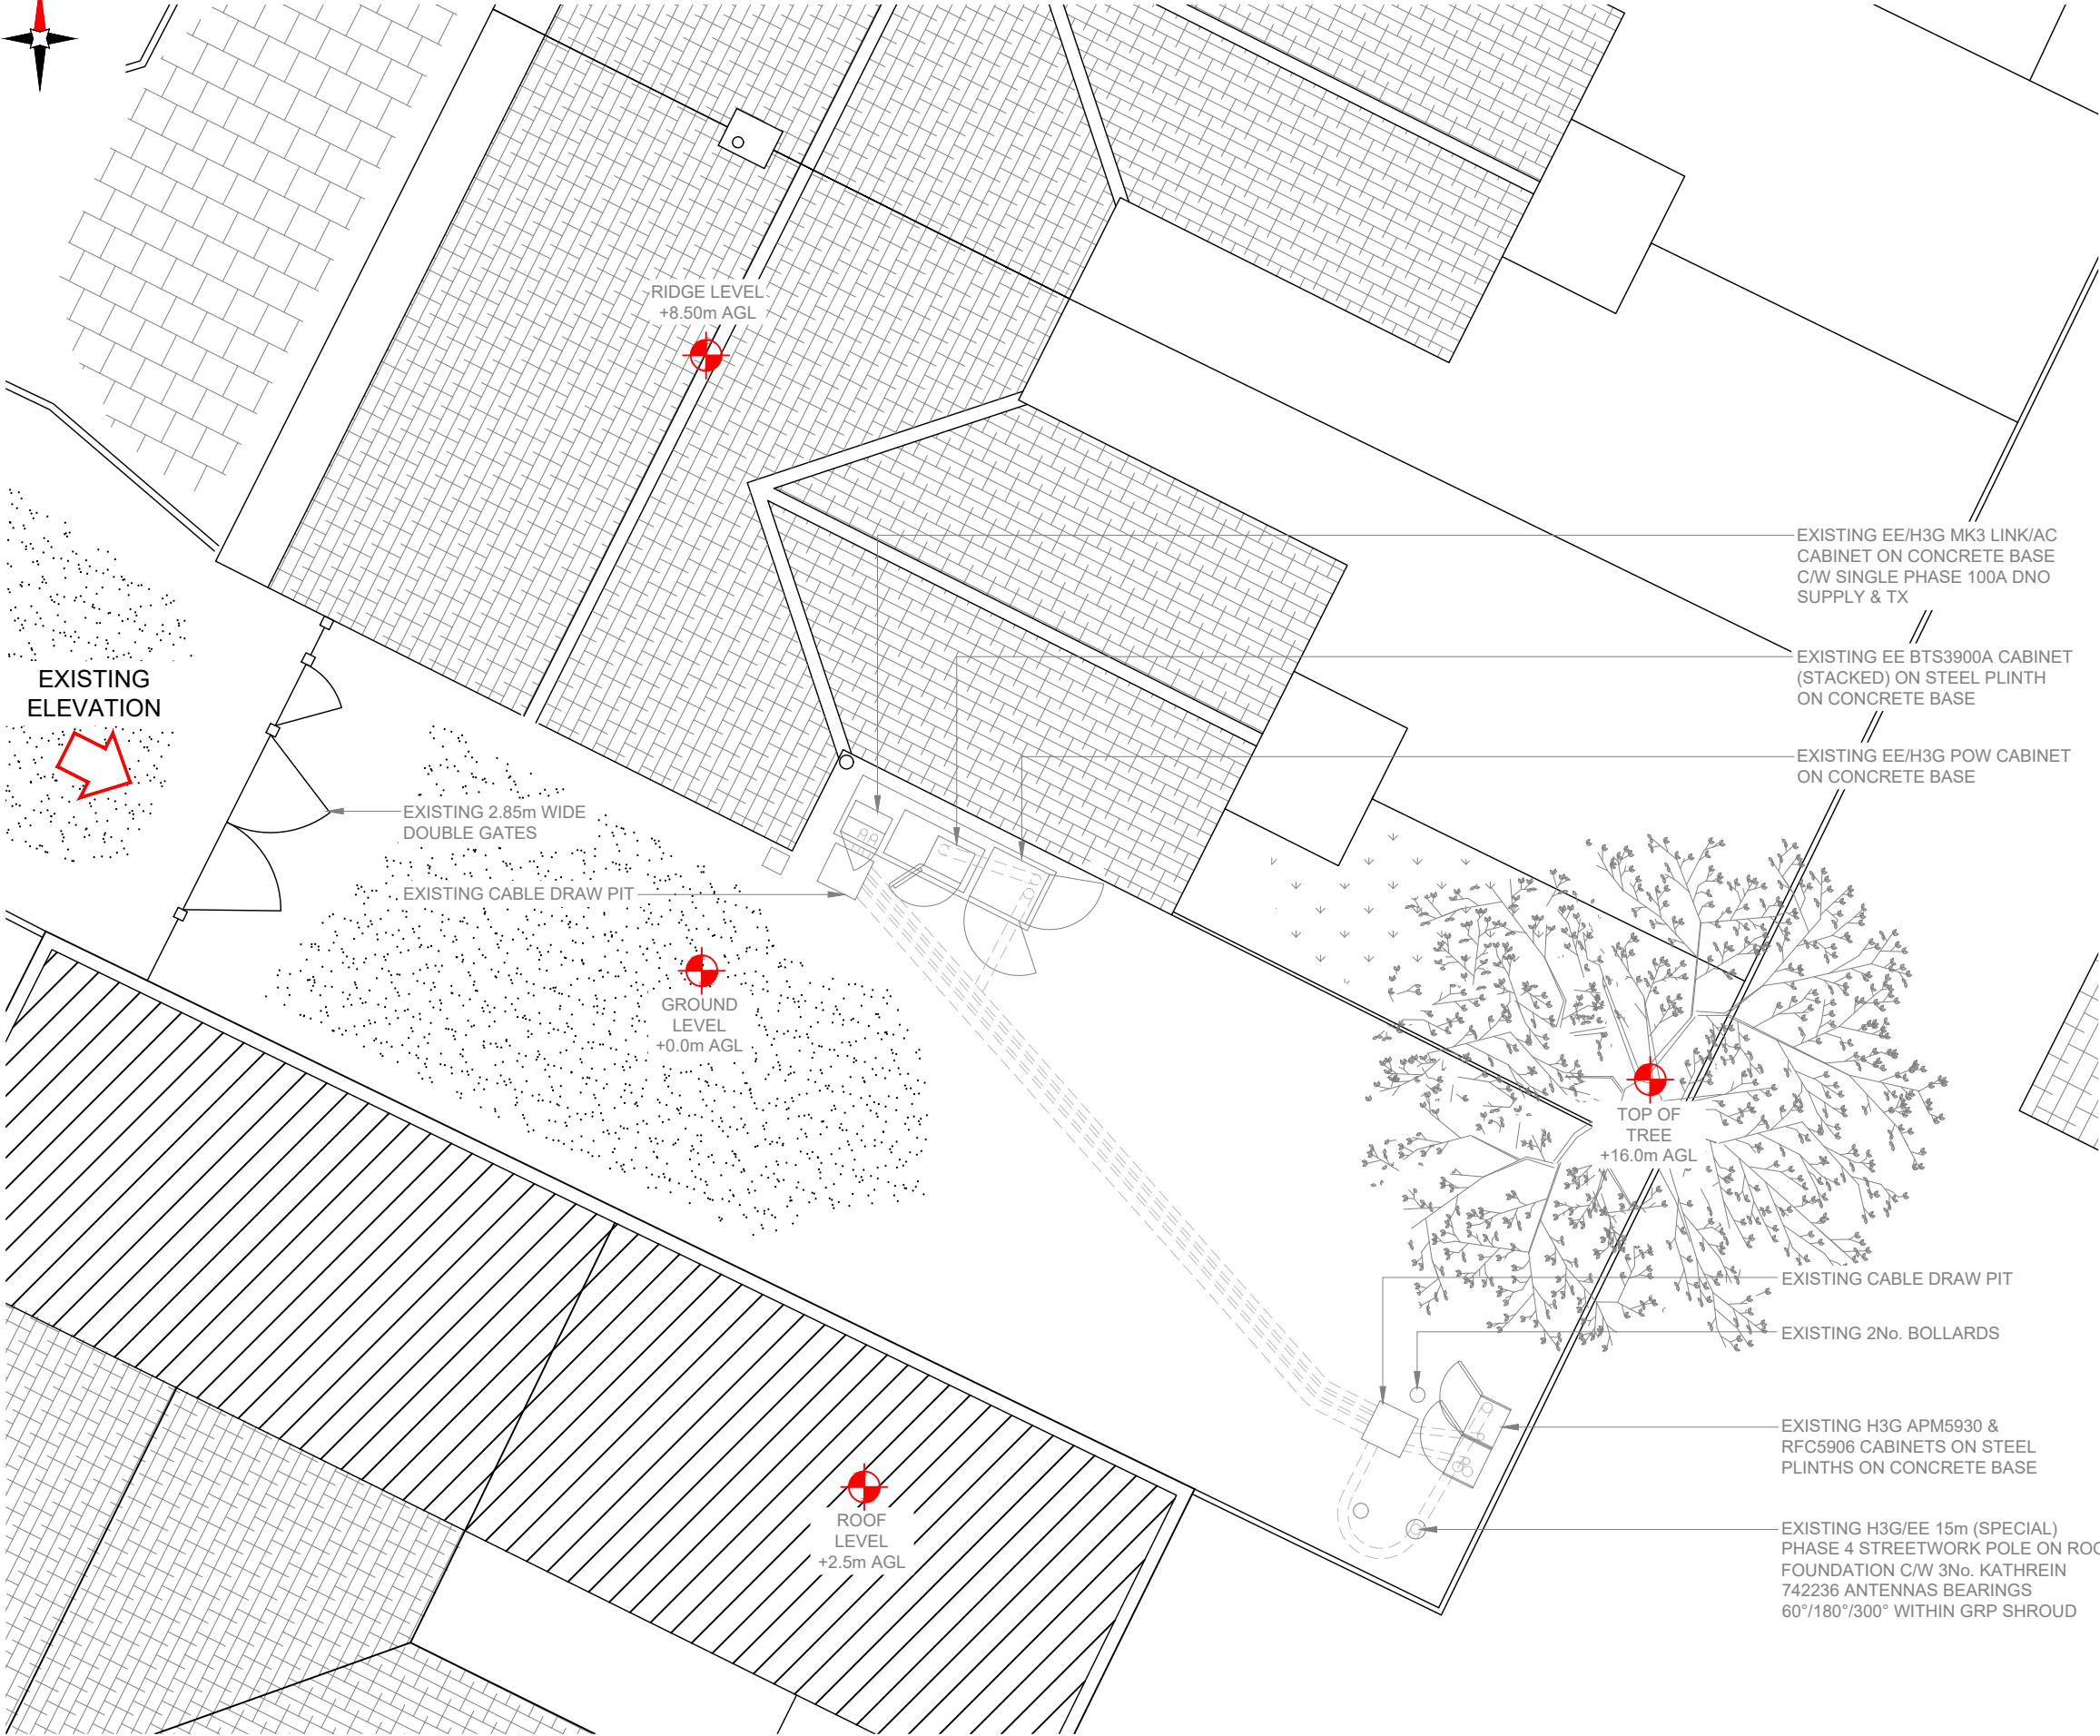

EXISTING SITE PLAN

 

- NOTES:
- ALL DIMENSIONS IN MM UNLESS OTHERWISE NOTED.

Master:	MBNL / EE / H3G:	Project:		Purpose of Issue:		Issue:	
M002	H3G	3UK UNILATERAL		Planning		B	
Date:	05/09/2021	Revision / Upgrade Description:					
Drawn:	B.Devlin	Revised to PACS Comments					
Checked:	S.Taylor						
Approved:	S.Taylor						
Master:	MBNL / EE / H3G:	Project:		Purpose of Issue:		Issue:	
M001	H3G	3UK UNILATERAL		Planning		A	
Date:	09/07/2021	Revision / Upgrade Description:					
Drawn:	J.Boote	First Issue					
Checked:	J.Stockdale						
Approved:	J.Stockdale						



Hutchison 3G UK Limited
Star House, 20 Grenfell Road
Maidenhead, SL6 1EH
Tel: 01628 765 000
Fax: 01628 765 001

H3G Base Station Information line:
0845 6043000
Available 8am-8pm Monday to Friday

Design Consultant & Principal Contractor:



Great British Communications
Lapwing House, Block 3 Forward Point,
Tan House Lane, Widnes, Cheshire, W48 0SL
t. 44 (0)151 420 4128
www.gbcservices.co.uk

Site Name:
AUBREY LEE & CO

Site ID:
975438

Address:
**1170 ROCHDALE ROAD,
BLACKLEY,
MANCHESTER,
GREATER MANCHESTER,
M9 6ER**

Title:
100 EXISTING SITE PLAN

Project:
3UK UNILATERAL

Purpose of Issue:
GENERAL ARRANGEMENT


EE Cell ID:	MBNL Cell ID:	3UK Cell ID:
99409	MAN114	M0372

Master Drawing No:	Issue:
975438_MAN114_99409_M0372_M002	B

100mm

50mm

10mm

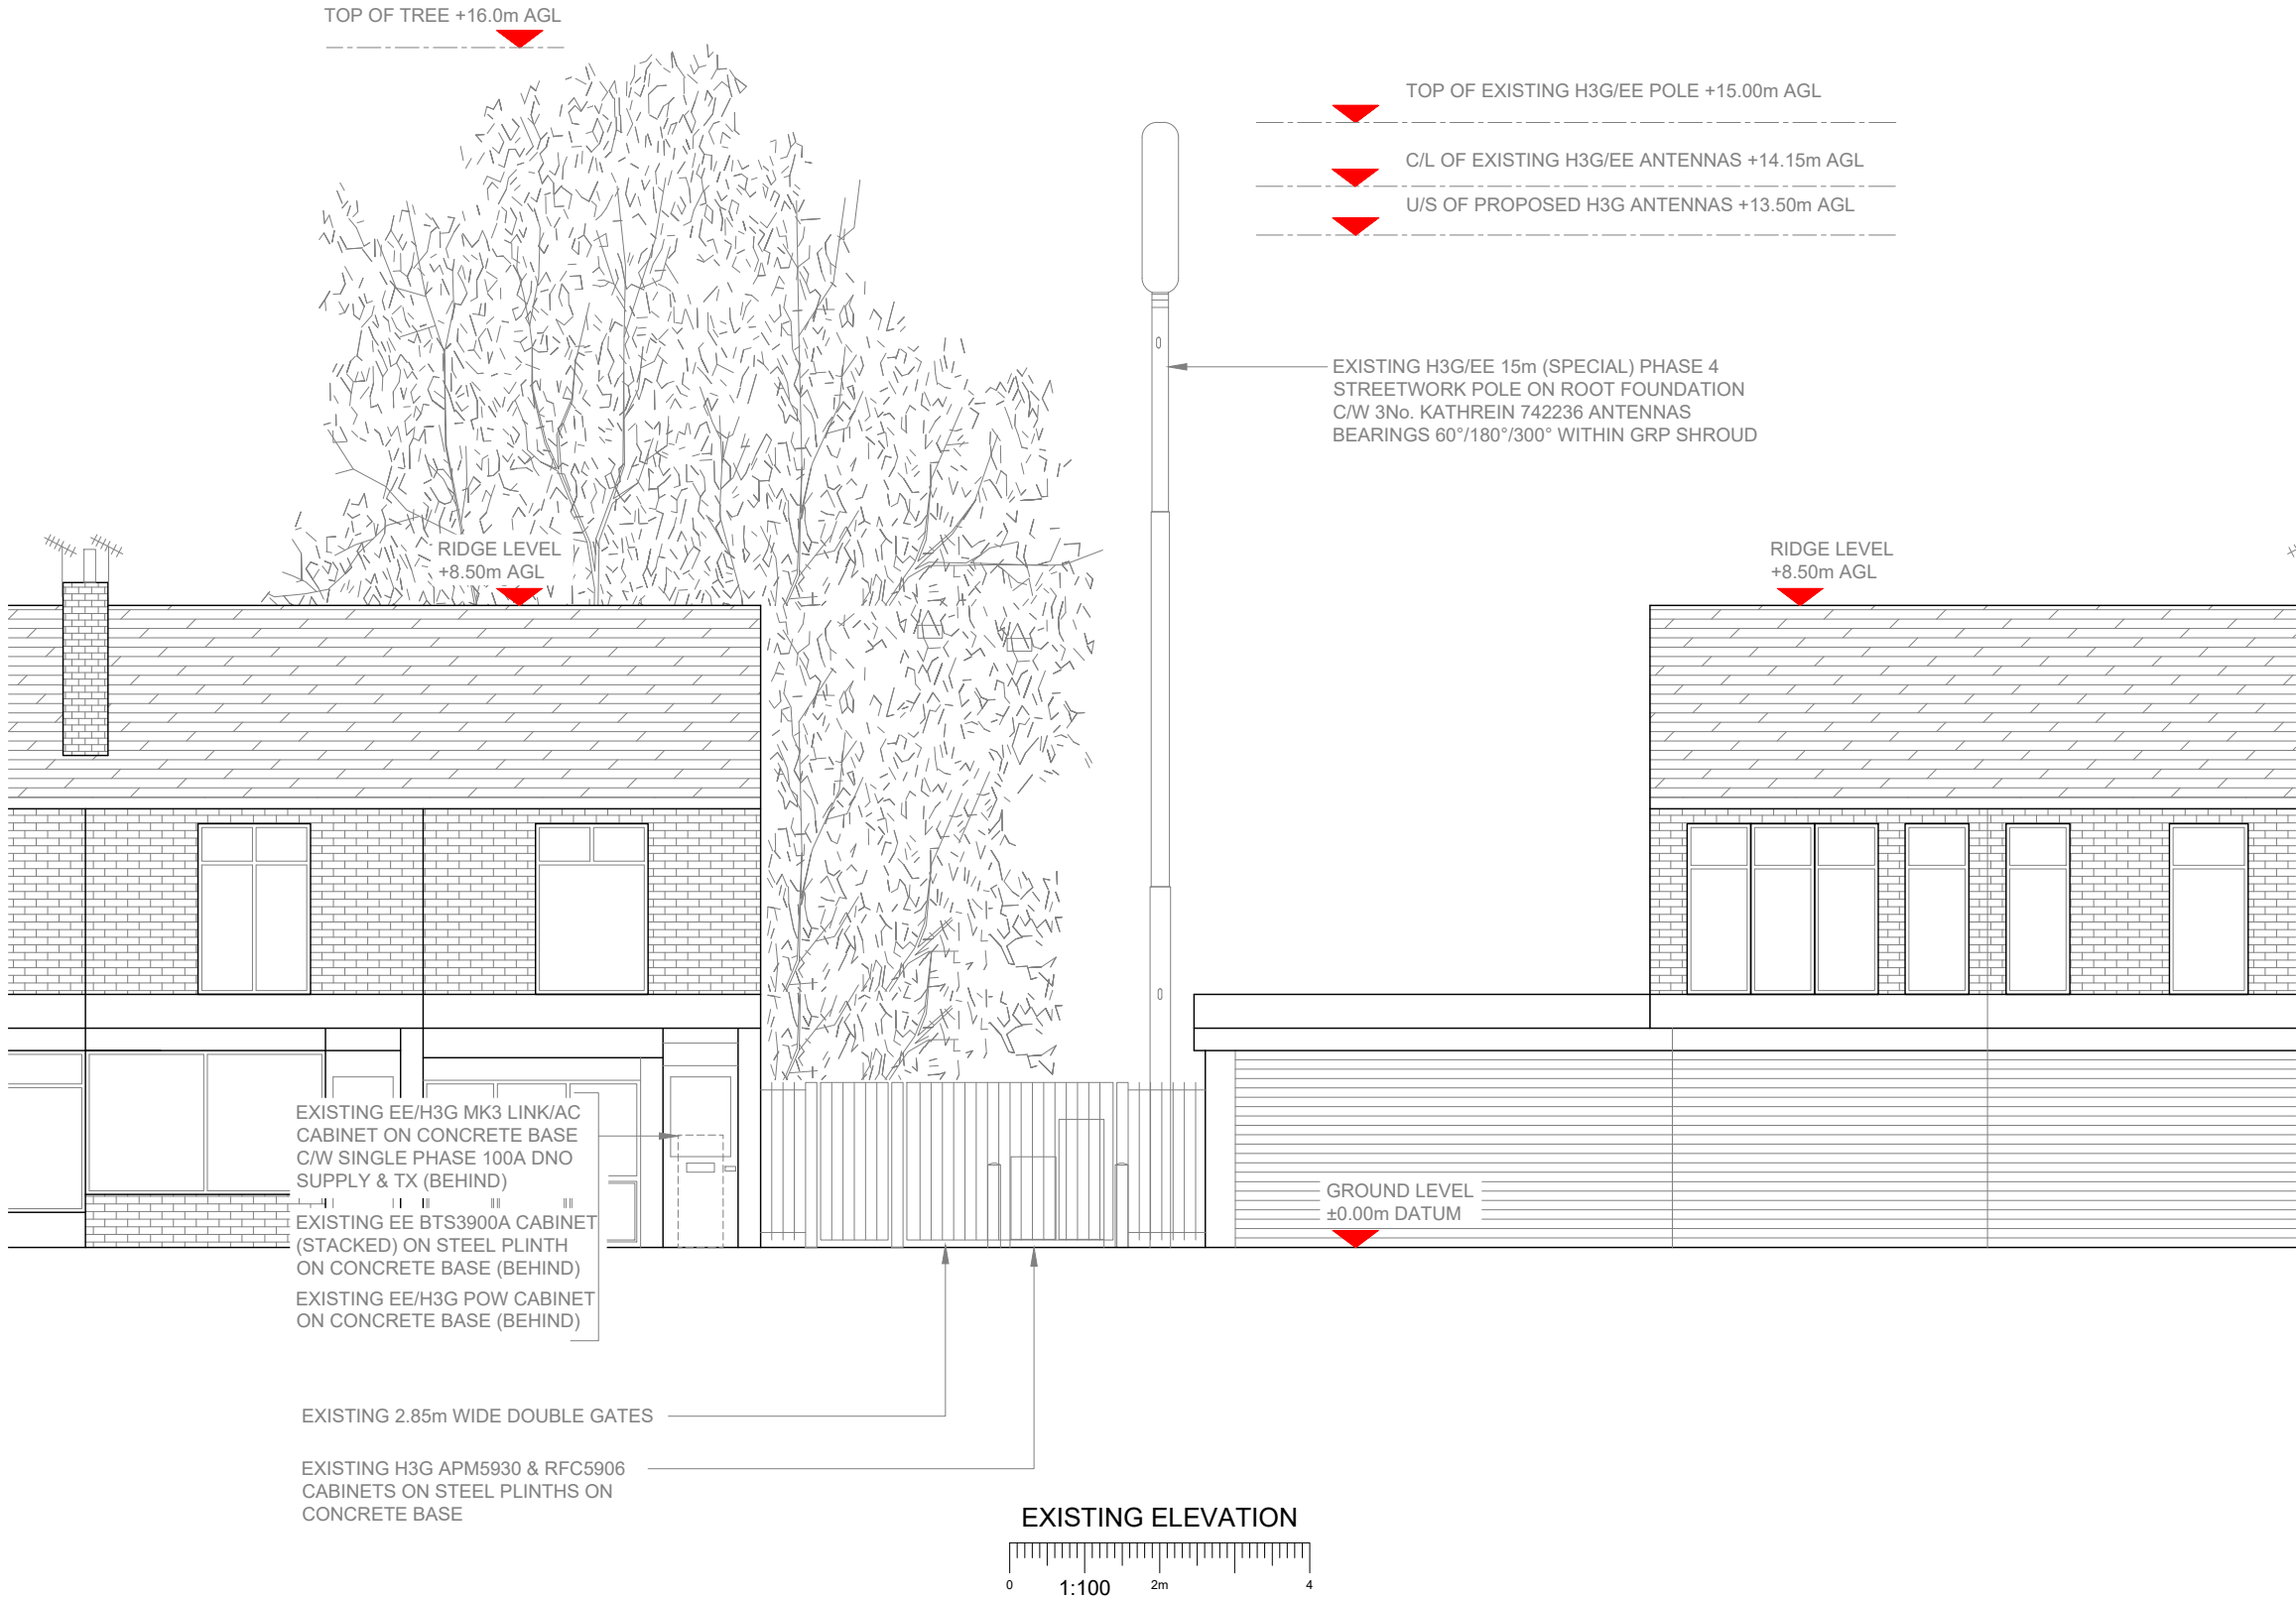

- NOTES:
- ALL DIMENSIONS IN MM UNLESS OTHERWISE NOTED.

Master:	MBNL / EE / H3G:	Project:	Purpose of Issue:	Issue:
M002	H3G	3UK UNILATERAL	Planning	B
Date:	05/09/2021	Revision / Upgrade Description:		
Drawn:	B.Devlin	Revised to PACS Comments		
Checked:	S.Taylor			
Approved:	S.Taylor			
Master:	MBNL / EE / H3G:	Project:	Purpose of Issue:	Issue:
M001	H3G	3UK UNILATERAL	Planning	A
Date:	09/07/2021	Revision / Upgrade Description:		
Drawn:	J.Boote	First Issue		
Checked:	J.Stockdale			
Approved:	J.Stockdale			



Hutchison 3G UK Limited
Star House, 20 Grenfell Road
Maidenhead, SL6 1EH
Tel: 01628 765 000
Fax: 01628 765 001


H3G Base Station Information line:
0845 6043000
Available 8am-8pm Monday to Friday

Design Consultant & Principal Contractor:

GBC

Great British Communications
Lapwing House, Block 3 Forward Point,
Tan House Lane, Widnes, Cheshire, W48 0SL
t. 44 (0)151 420 4128
www.gbcservices.co.uk

Site Name:				AUBREY LEE & CO			
Site ID:				975438			
Address:				1170 ROCHDALE ROAD, BLACKLEY, MANCHESTER, GREATER MANCHESTER, M9 6ER			
Title:				150 EXISTING ELEVATION			
Project:				3UK UNILATERAL			
Purpose of Issue:				GENERAL ARRANGEMENT			
EE Cell ID:		MBNL Cell ID:		3UK Cell ID:			
99409		MAN114		M0372			
Master Drawing No:						Issue:	
975438_MAN114_99409_M0372_M002						B	

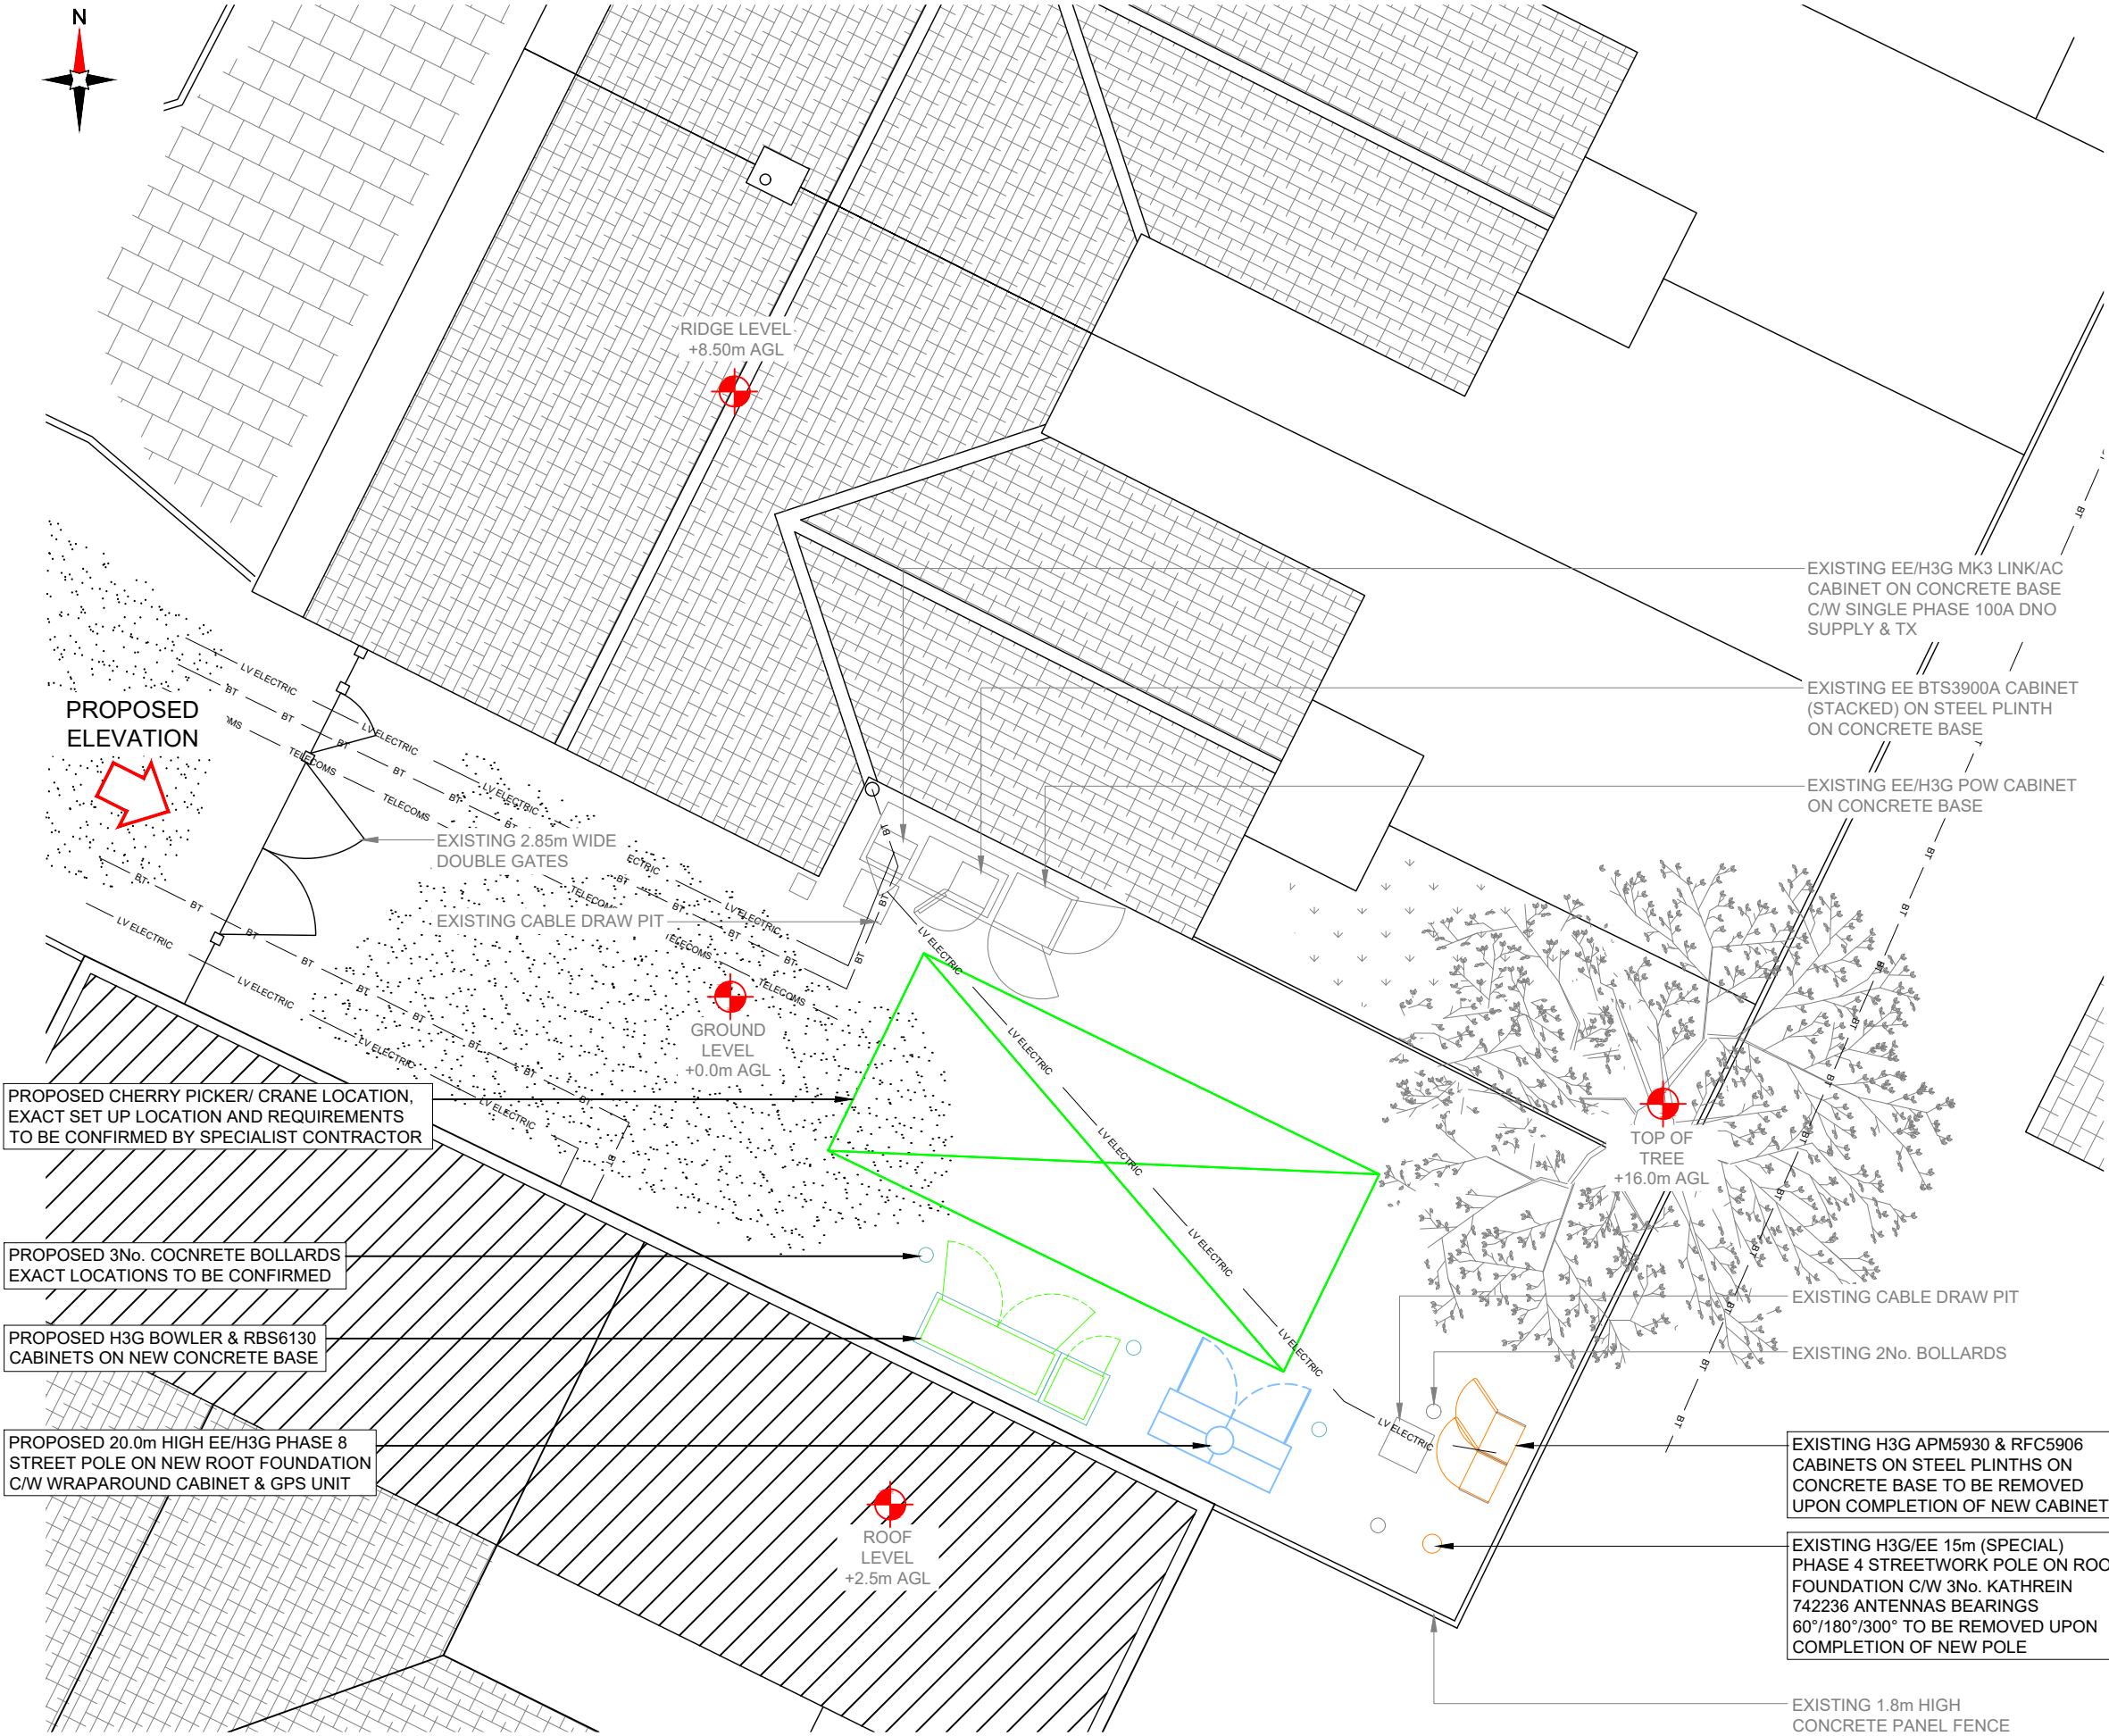

PROPOSED
ELEVATION

PROPOSED CHERRY PICKER/ CRANE LOCATION,
EXACT SET UP LOCATION AND REQUIREMENTS
TO BE CONFIRMED BY SPECIALIST CONTRACTOR

PROPOSED 3No. COCNRETE BOLLARDS
EXACT LOCATIONS TO BE CONFIRMED

PROPOSED H3G BOWLER & RBS6130
CABINETS ON NEW CONCRETE BASE

PROPOSED 20.0m HIGH EE/H3G PHASE 8
STREET POLE ON NEW ROOT FOUNDATION
C/W WRAPAROUND CABINET & GPS UNIT

✓ RIDGE LEVEL
+8.50m AGL

GROUND
LEVEL
+0.0m AGL

ROOF
LEVEL
+2.5m AGL

TOP OF
TREE
+16.0m AGL

EXISTING EE/H3G MK3 LINK/AC
CABINET ON CONCRETE BASE
C/W SINGLE PHASE 100A DNO
SUPPLY & TX

EXISTING EE BTS3900A CABINET
(STACKED) ON STEEL PLINTH
ON CONCRETE BASE

EXISTING EE/H3G POW CABINET
ON CONCRETE BASE

EXISTING CABLE DRAW PIT

EXISTING 2No. BOLLARDS

EXISTING H3G APM5930 & RFC5906
CABINETS ON STEEL PLINTHS ON
CONCRETE BASE TO BE REMOVED
UPON COMPLETION OF NEW CABINETS

EXISTING H3G/EE 15m (SPECIAL)
PHASE 4 STREETWORK POLE ON ROOT
FOUNDATION C/W 3No. KATHREIN
742236 ANTENNAS BEARINGS
60°/180°/300° TO BE REMOVED UPON
COMPLETION OF NEW POLE

EXISTING 1.8m HIGH
CONCRETE PANEL FENCE


PROPOSED H3G SITE PLAN



NOTES:

1. ALL DIMENSIONS IN MM UNLESS OTHERWISE NOTED.

PROPOSED CHERRY PICKER / SET DOWN LOCATION:

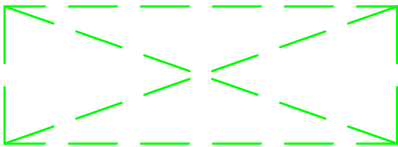

NOTE* SERVICE PLANS ARE
APPROXIMATE, SAFE DIGGING PRACTICES
TO BE USE AT ALL TIMES, CAT SCAN AREA
PRIOR TO BREAKING GROUND.

Master:	MBNL / EE / H3G:	Project:	Purpose of Issue:		Issue:
M002	H3G	3UK UNILATERAL	Planning	B	
Date:	05/09/2021	Revision / Upgrade Description:			
Drawn:	B.Devlin	Revised to PACS Comments			
Checked:	S.Taylor				
Approved:	S.Taylor				
Master:	MBNL / EE / H3G:	Project:	Purpose of Issue:		Issue:
M001	H3G	3UK UNILATERAL	Planning	A	
Date:	09/07/2021	Revision / Upgrade Description:			
Drawn:	J.Boote	First Issue			
Checked:	J.Stockdale				
Approved:	J.Stockdale				



Hutchison 3G UK Limited
Star House, 20 Grenfell Road
Maidenhead, SL6 1EH
Tel: 01628 765 000
Fax: 01628 765 001

H3G Base Station Information line:
0845 6043000
Available 8am-8pm Monday to Friday

Design Consultant & Principal Contractor:



Great British Communications
Lapwing House, Block 3 Forward Point,
Tan House Lane, Widnes, Cheshire, WAB 0SL
t. 44 (0)151 420 4128
www.gbcservices.co.uk

Site Name: AUBREY LEE & CO

Site ID: 975438

Address: 1170 ROCHDALE ROAD,
BLACKLEY,
MANCHESTER,
GREATER MANCHESTER,
M9 6ER

Title: 210 PROPOSED H3G SITE PLAN

Project: 3UK UNILATERAL

Purpose of Issue: GENERAL ARRANGEMENT


EE Cell ID:	MBNL Cell ID:	3UK Cell ID:
99409	MAN114	M0372

Master Drawing No:	Issue:
975438_MAN114_99409_M0372_M002	B

100mm

50mm

10mm

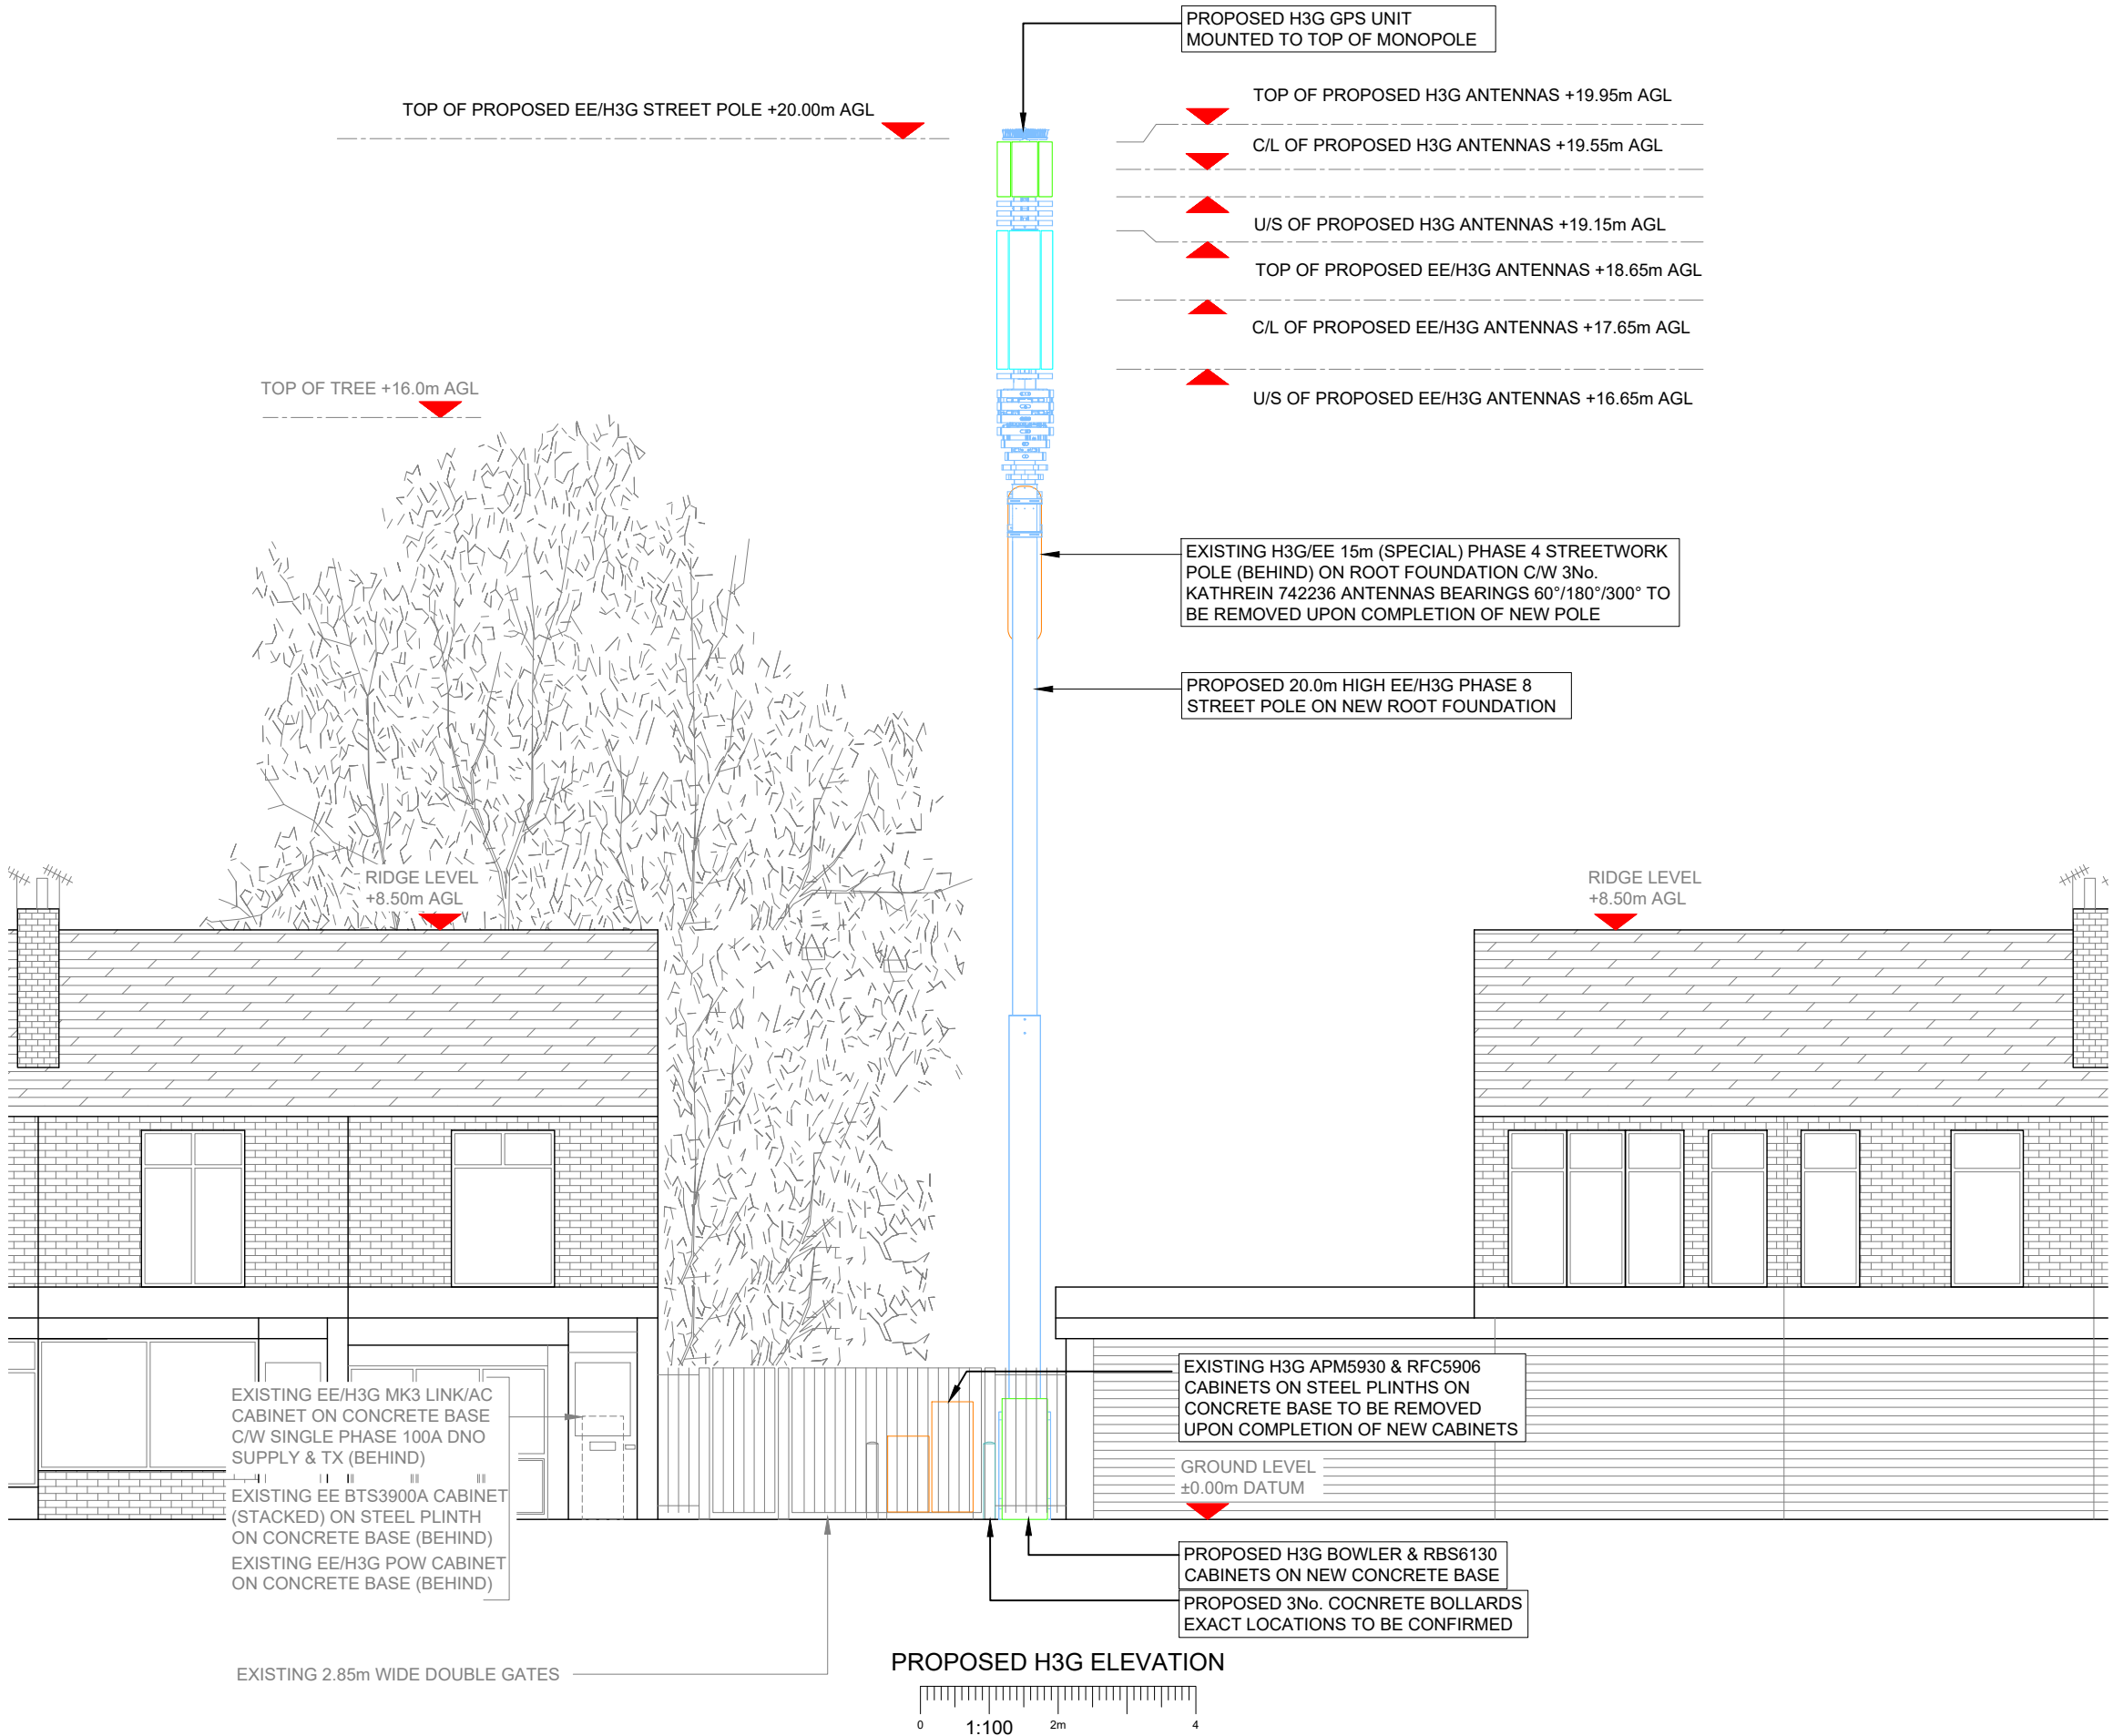

NOTES:

1. ALL DIMENSIONS IN MM UNLESS OTHERWISE NOTED.

Master:	MBNL / EE / H3G:	Project:	Purpose of Issue:	Issue:
M002	H3G	3UK UNILATERAL	Planning	B
Date:	05/09/2021	Revision / Upgrade Description:		
Drawn:	B.Devlin	Revised to PACS Comments		
Checked:	S.Taylor			
Approved:	S.Taylor			
Master:	MBNL / EE / H3G:	Project:	Purpose of Issue:	Issue:
M001	H3G	3UK UNILATERAL	Planning	A
Date:	09/07/2021	Revision / Upgrade Description:		
Drawn:	J.Boote	First Issue		
Checked:	J.Stockdale			
Approved:	J.Stockdale			



Hutchison 3G UK Limited
Star House, 20 Grenfell Road
Maidenhead, SL6 1EH
Tel: 01628 765 000
Fax: 01628 765 001

H3G Base Station Information line:
0845 6043000
Available 8am-8pm Monday to Friday

Design Consultant & Principal Contractor:



Great British Communications
Lapwing House, Block 3 Forward Point,
Tan House Lane, Widnes, Cheshire, WAB 0SL
t. 44 (0)151 420 4128
www.gbcservices.co.uk

Site Name:
AUBREY LEE & CO

Site ID:
975438

Address:
**1170 ROCHDALE ROAD,
BLACKLEY,
MANCHESTER,
GREATER MANCHESTER,
M9 6ER**

Title:
260 PROPOSED H3G ELEVATION

Project:
3UK UNILATERAL

Purpose of Issue:
GENERAL ARRANGEMENT

EE Cell ID: 99409	MBNL Cell ID: MAN114	3UK Cell ID: M0372
-----------------------------	--------------------------------	------------------------------

Master Drawing No: 975438_MAN114_99409_M0372_M002	Issue: B
---	--------------------

PROPOSED H3G ANTENNA SCHEDULE																												
Antenna Type, Azimuth, Tilt and Ports										Feeders / MHA / RRU / Overall System Loss																		
Antenna ID	Antenna Type & length	Antenna C/L	Bearing	Mechanical Tilt (+ / -)	Electrical Tilt (+ / -)	Manufacturer's Port Frequency Range (MHz)	Operator & Frequencies	Labeling	RET	Antenna feeder Jumper	MHA / Diplexer / Active Router	MHA / Diplexer Jumper	Active Router	MHA/ Diplexer, Triplexer Jumper	Main Feeder Type & Length	Main Feeder jumper	Passive router / UCU / SBC	Passive router / UCU / SBC feeder jumper	RRU / RFU	RRU / AAU Jumper Type & Length	Remote BOB	Main Fibre Length	Local BOB	BTS Tail or Fibre Tail Type & Length	Estimated Total System Loss At Highest Working Frequency (dB)			
A1	KATHREIN 80048 2002	17.65m	60°	AS PER RDS	AS PER RDS	698-960 (r1)	800	H08eA1	H08P:60	-	-	-	-	-	LDF4-50 22m	-	-	-	1No. 2460 RRU	-	-	-	-	-	-	1.387		
					AS PER RDS	698-960 (r2)	800	H08eA1	H08P:60	-	-	-	-	-	LDF4-50 22m	-	-	-	-	-	-	-	-	-	-	-	1.387	
					AS PER RDS	1427-2690 (y1)	1400/1800/2100	H14eA1/ H18eA1/ H21eA1	H14S:H18S :H21P:60	-	-	-	-	-	LDF4-50 22m	-	1400-2100	-	2No. 2012 RRU	-	-	-	-	-	-	-	1.851	
					AS PER RDS	1427-2690 (y4)	1400/1800/2100			-	-	-	-	-	LDF4-50 22m	-	PASSIVE ROUTER	-	1No. 4480 RRU	-	-	-	-	-	-	-	-	2.15/2.344
					AS PER RDS	1695-2960 (y3)	SPARE	-	-	-	-	-	-	-	-	-	-	-	-	-	-	-	-	-	-	-	-	-
					AS PER RDS	1695-2960 (y2)	1800/2100	EC1A1/EuA1	E18S:E21P:60	-	-	-	-	-	18/21	LDF5-50 30m	4-50=2m	-	-	-	RFU	-	-	-	-	-	-	-
A2	ERICSSON AIR 6449	19.55m	60°	AS PER RDS	AS PER RDS	3300-3800	H3G 3600	H36eA1	H36P:60	-	-	-	-	-	-	-	-	-	AIR	20m 11758 DC & 20m 11759 FIBRE	COMBINED BOB 11832	10.0m	-	6m FIBRE & DC	-			
B1	KATHREIN 80048 2002	17.65m	180°	AS PER RDS	AS PER RDS	698-960 (r2)	800	H08eB1	H08P:180	-	-	-	-	-	LDF4-50 22m	-	-	-	1No. 2460 RRU	-	-	-	-	-	-	1.387		
					AS PER RDS	698-960 (r2)	800	H08eB1	H08P:180	-	-	-	-	-	LDF4-50 22m	-	-	-	-	-	-	-	-	-	-	-	-	1.387
					AS PER RDS	1427-2690 (y1)	1400/1800/2100	H14eB1/ H18eB1/ H21eB1	H14S:H18S :H21P:180	-	-	-	-	-	LDF4-50 22m	-	1400-2100	-	2No. 2012 RRU	-	-	-	-	-	-	-	1.851	
					AS PER RDS	1427-2690 (y4)	1400/1800/2100			-	-	-	-	-	LDF4-50 22m	-	PASSIVE ROUTER	-	1No. 4480 RRU	-	-	-	-	-	-	-	-	2.15/2.344
					AS PER RDS	1695-2960 (y3)	SPARE	-	-	-	-	-	-	-	-	-	-	-	-	-	-	-	-	-	-	-	-	-
					AS PER RDS	1695-2960 (y2)	1800/2100	EC2A1/EuB1	E18S:E21P:180	-	-	-	-	-	18/21	LDF5-50 30m	4-50=2m	-	-	-	RFU	-	-	-	-	-	-	-
B2	ERICSSON AIR 6449	19.55m	180°	AS PER RDS	AS PER RDS	3300-3800	H3G 3600	H36eC1	H36P:180	-	-	-	-	-	-	-	-	-	AIR	20m 11758 DC & 20m 11759 FIBRE	COMBINED BOB 11832	10.0m	-	6m FIBRE & DC	-			
C1	KATHREIN 80048 2002	17.65m	300°	AS PER RDS	AS PER RDS	698-960 (r2)	800	H08eC1	H08P:300	-	-	-	-	-	LDF4-50 22m	-	-	-	1No. 2460 RRU	-	-	-	-	-	-	1.387		
					AS PER RDS	698-960 (r2)	800	H08eC1	H08P:300	-	-	-	-	-	LDF4-50 22m	-	-	-	-	-	-	-	-	-	-	-	-	1.387
					AS PER RDS	1427-2690 (y1)	1400/1800/2100	H14eC1/ H18eC1/ H21eC1	H14S:H18S :H21P:300	-	-	-	-	-	LDF4-50 22m	-	1400-2100	-	2No. 2012 RRU	-	-	-	-	-	-	-	1.851	
					AS PER RDS	1427-2690 (y4)	1400/1800/2100			-	-	-	-	-	LDF4-50 22m	-	PASSIVE ROUTER	-	1No. 4480 RRU	-	-	-	-	-	-	-	-	2.15/2.344
					AS PER RDS	1695-2960 (y3)	SPARE	-	-	-	-	-	-	-	-	-	-	-	-	-	-	-	-	-	-	-	-	-
					AS PER RDS	1695-2960 (y2)	1800/2100	EC3A1/EuC1	E18S:E21P:300	-	-	-	-	-	18/21	LDF5-50 30m	4-50=2m	-	-	-	RFU	-	-	-	-	-	-	-
C2	ERICSSON AIR 6449	19.55m	300°	AS PER RDS	AS PER RDS	3300-3800	H3G 3600	H36eC1	H36P:300	-	-	-	-	-	-	-	-	-	AIR	20m 11758 DC & 20m 11759 FIBRE	COMBINED BOB 11832	10.0m	-	6m FIBRE & DC	-			

STATUS KEY:

Installed: Existing
Retain: Existing and to remain
Relocate: Existing and to be relocated
Remove: Existing to be removed from site
Proposed: New on site

Master:	MBNL / EE / H3G:	Project:	Purpose of Issue:	Issue:
M002	H3G	3UK UNILATERAL	Planning	B
Date:	05/09/2021	Revision / Upgrade Description:		
Drawn:	B.Devlin	Revised to PACS Comments		
Checked:	S.Taylor			
Approved:	S.Taylor			
Master:	MBNL / EE / H3G:	Project:	Purpose of Issue:	Issue:
M001	H3G	3UK UNILATERAL	Planning	A
Date:	09/07/2021	Revision / Upgrade Description:		
Drawn:	J.Boote	First Issue		
Checked:	J.Stockdale			
Approved:	J.Stockdale			



Hutchison 3G UK Limited
Star House, 20 Grenfell Road
Maidenhead, SL6 1EH
Tel: 01628 765 000
Fax: 01628 765 001

H3G Base Station Information line:
0845 6043000
Available 8am-8pm Monday to Friday

Design Consultant & Principal Contractor:



Great British Communications
Lapwing House, Block 3 Forward Point,
Tan House Lane, Widnes, Cheshire, WAB 0SL
t. 44 (0)151 420 4128
www.gbcservices.co.uk

Site Name: AUBREY LEE & CO

Site ID: 975438

Address: 1170 ROCHDALE ROAD,
BLACKLEY,
MANCHESTER,
GREATER MANCHESTER,
M9 6ER

Title: 302 PROPOSED H3G ANTENNA
SCHEDULE & GPS NODE

Project: 3UK UNILATERAL

Purpose of Issue: GENERAL ARRANGEMENT

EE Cell ID: 99409	MBNL Cell ID: MAN114	3UK Cell ID: M0372
----------------------	-------------------------	-----------------------

Master Drawing No: 975438_MAN114_99409_M0372_M002	Issue: B
--	-------------

POST-UPGRADE 3UK FIBRE KEY							
RRU SECTOR ID	RRU BAND	BOTTOM BOB TO RRU (m)	BOTTOM BOB LOCATION	MAIN DC/ FIBRE TRUNK LENGTH (m)	MAIN DC/ FIBRE TRUNK TYPE	TOP BOB LOCATION	TOP BOB TO AAU (m)
1	700/800	-	WRAPAROUND CABINET	-	-	-	-
	1400	-		-	-	-	-
	1800/2100	-		-	-	-	-
	3600	6m		10m	ICD 11759 (A)	-	20m
2	700/800	-		-	-	-	-
	1400	-		-	-	-	-
	1800/2100	-		-	-	-	-
	3600	6m		10m	ICD 11759 (A)	-	20m
3	700/800	-		-	-	-	-
	1400	-		-	-	-	-
	1800/2100	-		-	-	-	-
	3600	6m		10m	ICD 11759 (A)	-	20m

PROPOSED GPS LINE KEY		
SECTOR ID	ANTENNA C/L (m) AGL	GPS CABLE LENGTH (m)
SECTOR A	20.20m	27m

Support Structure Schedule														STATUS KEY:						
Structure ID	Status	Equipment Description / Type	Structure Manufacturer	Height AGL (m)	Colour (RAL Colour)	Headframe Details	Foundation / Support Grillage / Host Structure Details	Support Bolt Details	MBNL Ref:	Comments				Installed:	Existing					
ST1	Existing	Phase 4 Monopole	Alifabs	15.0m	Galvanised	Phase 4 Shroud	Root Foundaiton	-	-	To be removed				Retain:	Existing and to remain					
ST2	Proposed	Phase 8 Monopole	-	20.0m	GREY	N/A	Root Foundaiton	-	-	-				Relocate:	Existing and to be relocated					
														Remove:	Existing to be removed from site					
														Proposed:	New on site					
														LOCATION KEY:						
														Outdoor:	Located outside					
														Indoor:	Located within an equipment cabin or equipment room					
														Internal:	located inside a cabinet or item of equipment					
Supply Status		Type	Supplier	Supply Type	Location	Comments														
EXISTING		REC	TBC	100A Single PHASE	Link/AC cabinet	LOAD TEST REQUIRED														
Equipment Schedule																				
Equipment ID	Quantity	Status	Equipment Description / Type	Equipment Manufacturer	Dimensions (W x D x H)	Weight (kg)	Colour (RAL Colour)	Material	Location	Power	Power cable length (m)	MBNL Ref:	Comments	Master:	MBNL / EE / H3G:	Project:	Purpose of Issue:	Issue:		
CAB1	1	REMOVE	H3G - APM5930	HUAWEI	600x480x1100	-	GREY	STEEL	OUTDOOR	-	-	-	TO BE REMOVED	M002	H3G	3UK UNILATERAL	Planning	B		
CAB2	1	REMOVE	H3G - RFC5906	HUAWEI	600x480x1600	-	GREY	STEEL	OUTDOOR	-	-	-	TO BE REMOVED	Date:	05/09/2021	Revision / Upgrade Description: Revised to PACS Comments				
CAB3	1	EXISTING	EE - BTS3900A	HUAWEI	600x600x1900	-	GREY	STEEL	OUTDOOR	-	-	-		Drawn:	B.Devlin					
CAB4	1	EXISTING	H3G/EE - POW	PORTASTOR	900x800x1240	-	GREY	STEEL	OUTDOOR	-	-	-		Checked:	S.Taylor					
CAB5	1	EXISTING	H3G/EE - LINK AC	ALIFABS	600x500x1280	-	GREY	STEEL	OUTDOOR	-	-	-		Approved:	S.Taylor	Master:	MBNL / EE / H3G:	Project:	Purpose of Issue:	Issue:
CAB6	1	PROPOSED	H3G - BOWLER	COMMScope	1900x600x1752	-	GREY	STEEL	OUTDOOR	-	-	-		M001	H3G	3UK UNILATERAL	Planning	A		
CAB7	1	PROPOSED	H3G RBS 6130	ERICSSON	650x700x950	-	-	-	OUTDOOR	-	-	-	C/W PROPOSED BBU & PSU WITHIN	Date:	09/07/2021	Revision / Upgrade Description: First Issue				
CAB8	1	PROPOSED	H3G/EE - WRAPAROUND	COMMScope	1800x750x1600	-	GREY	STEEL	OUTDOOR	-	-	-		Drawn:	J.Boote					
														Checked:	J.Stockdale					
														Approved:	J.Stockdale	 Hutchison 3G UK Limited Star House, 20 Grenfell Road Maidenhead, SL6 1EH Tel: 01628 765 000 Fax: 01628 765 001 H3G Base Station Information line: 0845 6043000 Available 8am-8pm Monday to Friday				
RRU/BOB/Combiner Schedule														Design Consultant & Principal Contractor:						
Equipment ID	Quantity	Status	Equipment Description / Type	Equipment Manufacturer	Dimensions (W x D x H)	Weight (kg)	Colour (RAL Colour)	Material	Location	Power	Power cable length (m)	MBNL Ref:	Comments	 Great British Communications Lapwing House, Block 3 Forward Point, Tan House Lane, Widnes, Cheshire, WAB 0SL t. 44 (0)151 420 4128 www.gbcservices.co.uk						
RRU1-3	3	PROPOSED	2460 (700-800)	ERICSSON	190x400x553	37kg	GREY	STEEL	Ground Level	-	-	-	700/800							
RRU4-9	6	PROPOSED	2012 (1400)	ERICSSON	131x342x420	17kg	GREY	STEEL	Ground Level	-	-	-	1400							
RRU10-12	3	PROPOSED	4480 (1800/2100)	ERICSSON	151x400x553	32kg	GREY	STEEL	Ground Level	-	-	-	1800/2100							
PR1-6	6	PROPOSED	1400-2100 Passive Router 7821 1533	-	-	-	GREY	STEEL	Ground Level	-	-	-	1400/1800/2100 TECHNOLOGY	Site Name: AUBREY LEE & CO						
MHA1	3	PROPOSED	RD0448	RADIO DESIGN	-	-	GREY	STEEL	Antenna Level	-	-	-	1400/1800/2100 TECHNOLOGY	Site ID: 975438						
FILTER	3	PROPOSED	1400 Filter KRF102 452	-	-	-	GREY	STEEL	Ground Level	-	-	-	1400 TECHNOLOGY	Address: 1170 ROCHDALE ROAD, BLACKLEY, MANCHESTER, GREATER MANCHESTER, M9 6ER						
BOB1	1	PROPOSED	Local DC & FIBRE BOB	ICD - 11832	-	-	-	-	Ground Level	-	-	-	WITHIN WRAPAROUND							
														Title: 304 EQUIPMENT SCHEDULE & SUPPORT STRUCTURE DETAILS						
														Project: 3UK UNILATERAL						
														Purpose of Issue: GENERAL ARRANGEMENT						
					EE Cell ID:		MBNL Cell ID:		3UK Cell ID:											
					99409		MAN114		M0372											
														Master Drawing No: 975438_MAN114_99409_M0372_M002				Issue: B		

100mm

50mm

10mm