


Notes

1. This layout shall be read in conjunction with all other services, architectural and structural information, project specifications and contract documentation.

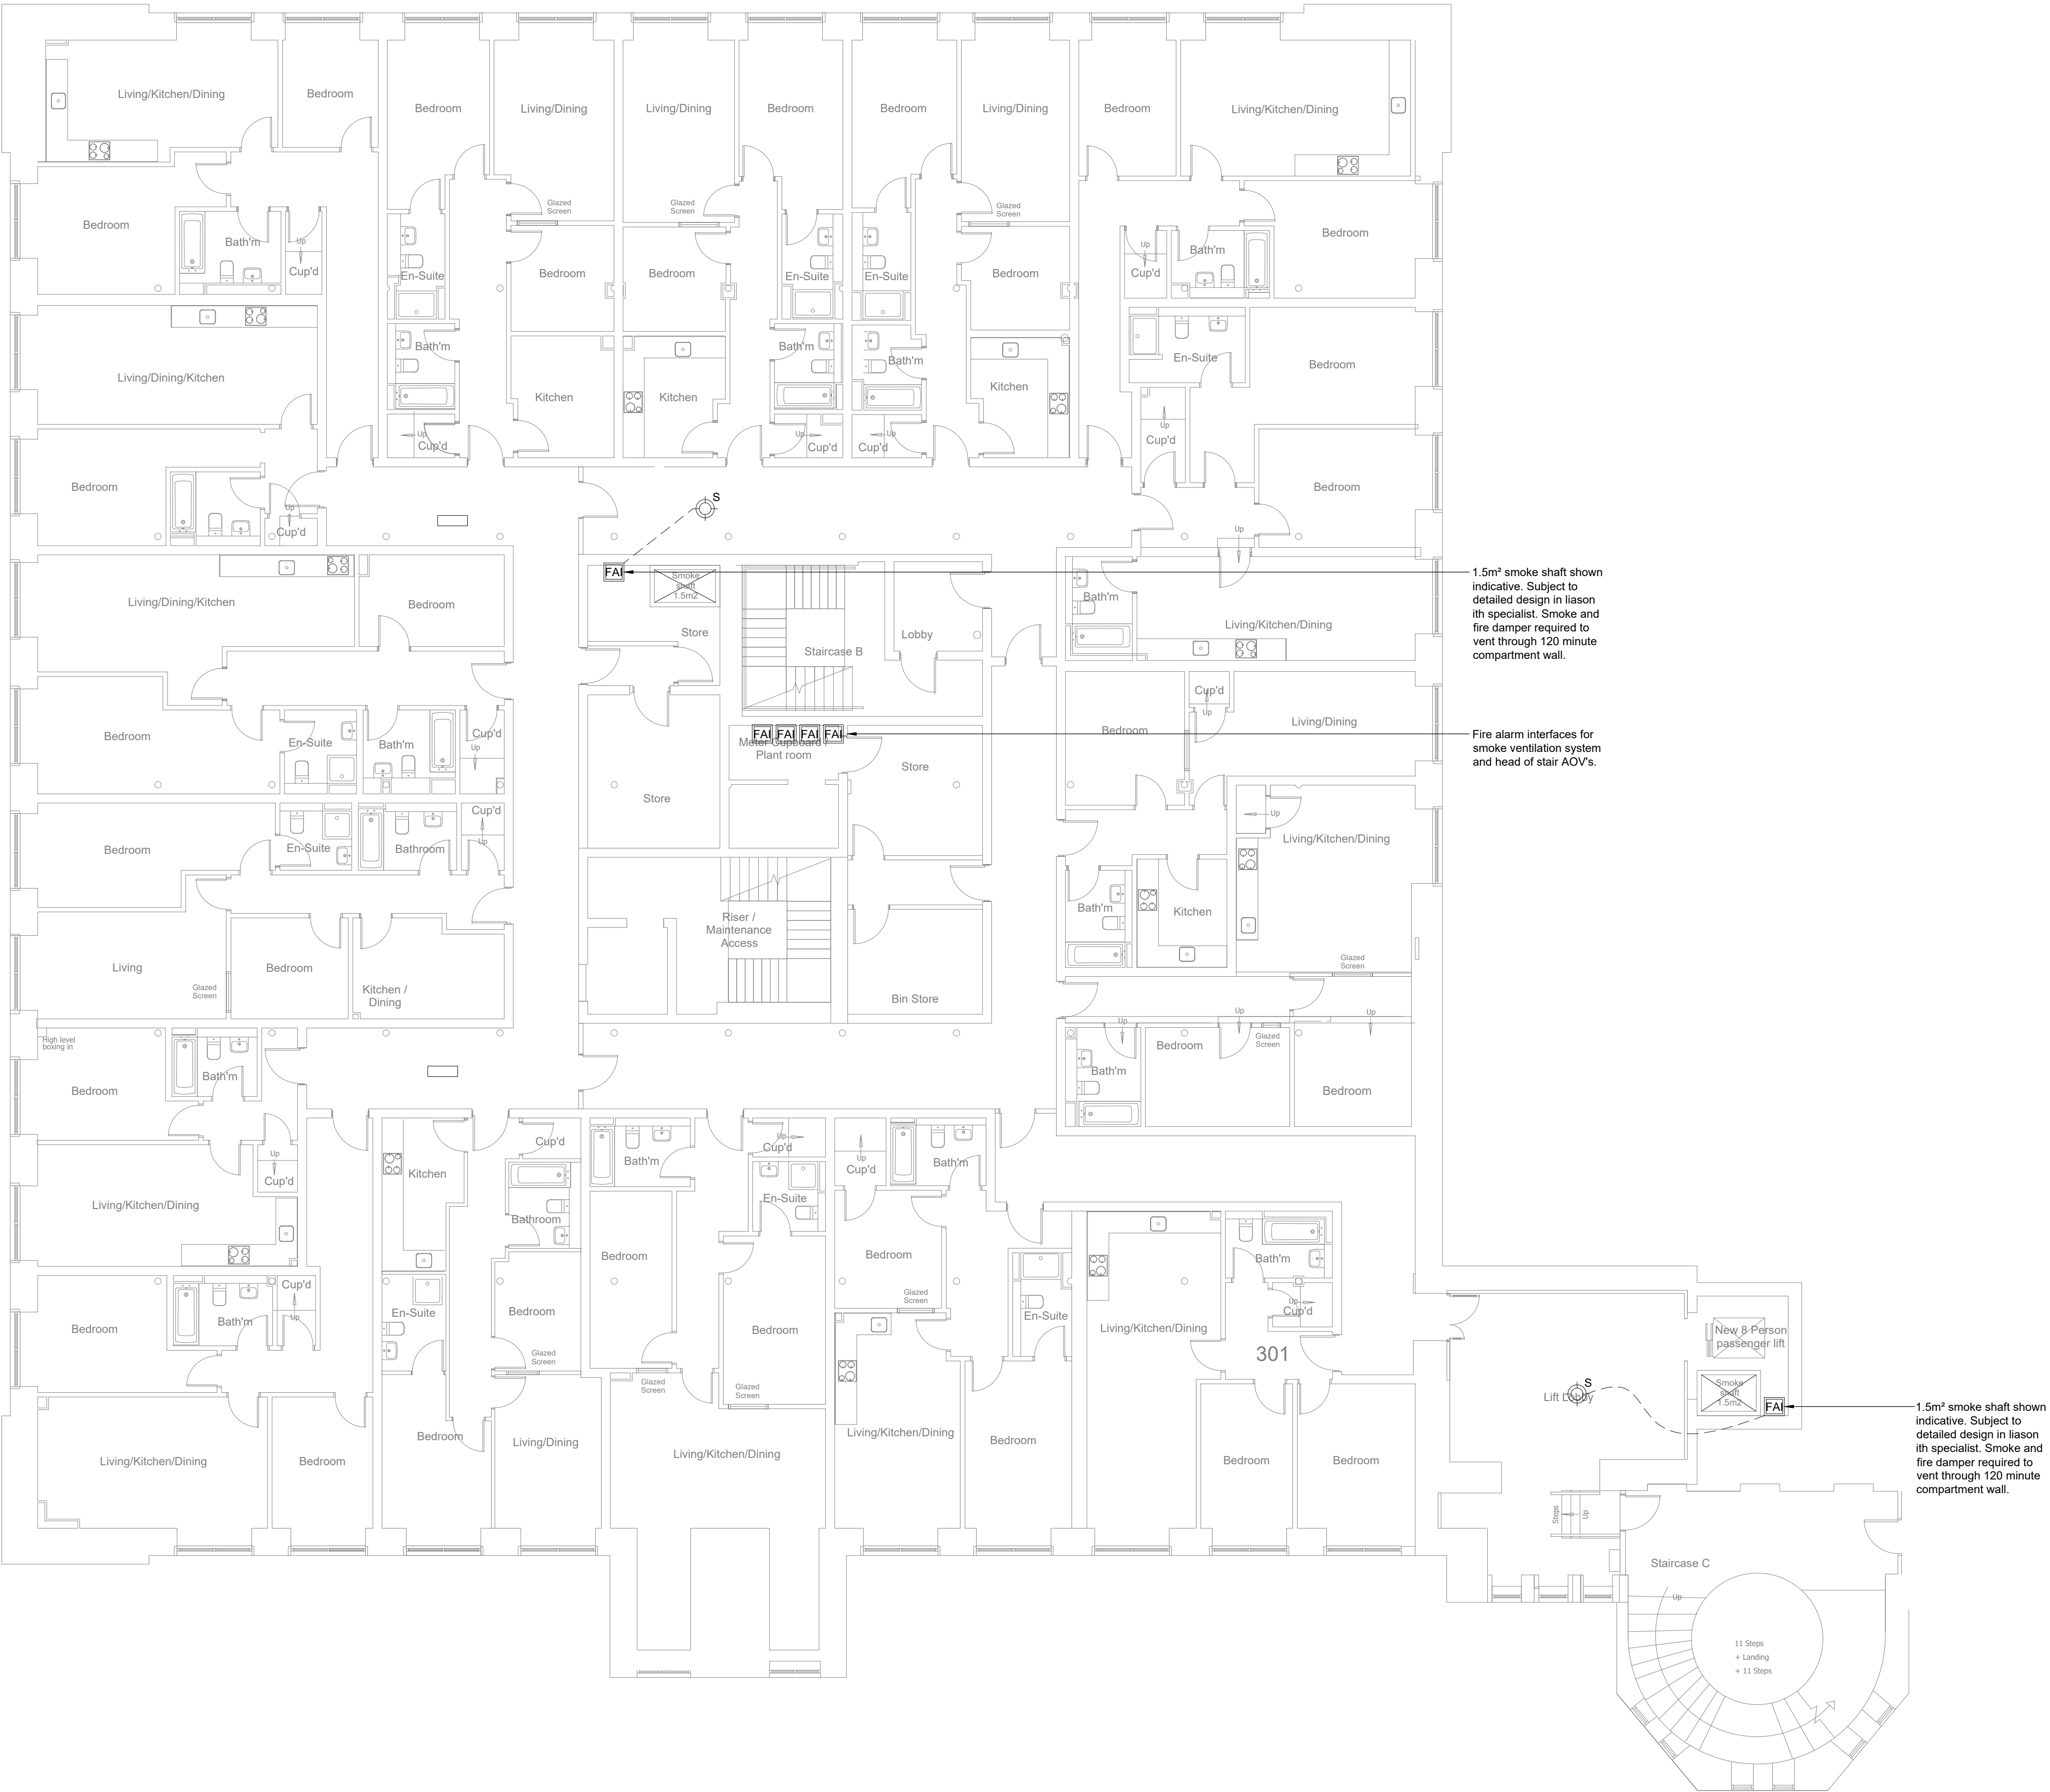

C1	NG	19.03.21	Contract Issue.
P1	NG	26.02.21	Preliminary Issue.
Rev	By	Date	Description



TACE

THE ASSOCIATES CONSULTING ENGINEERS
Portland House
Stanley Green Business Park
Oak Green
Cheshire M6
Salford S6 6LJ
T: 0161 486 5429
F: 0161 486 0488
E: info@tace.co.uk
W: www.tace.co.uk

Client			
RFP Advisory Group			
Project			
Victoria Mill, Manchester			
Drawing Title			
Proposed Smoke Ventilation Layout Level 03			
Drawn	ET	Date	26.02.21
Checked	NG	Date	26.02.21
Approved	NG	Date	26.02.21
Job No.	PA1484	Drawing No.	VMM-TCE-XX-03-DR-M-57002
Cad File		External Ref.	-
Scale		Issue Status	--
Rev		C1	