


- Notes
- This layout shall be read in conjunction with all other services, architectural and structural information, project specifications and contract documentation.

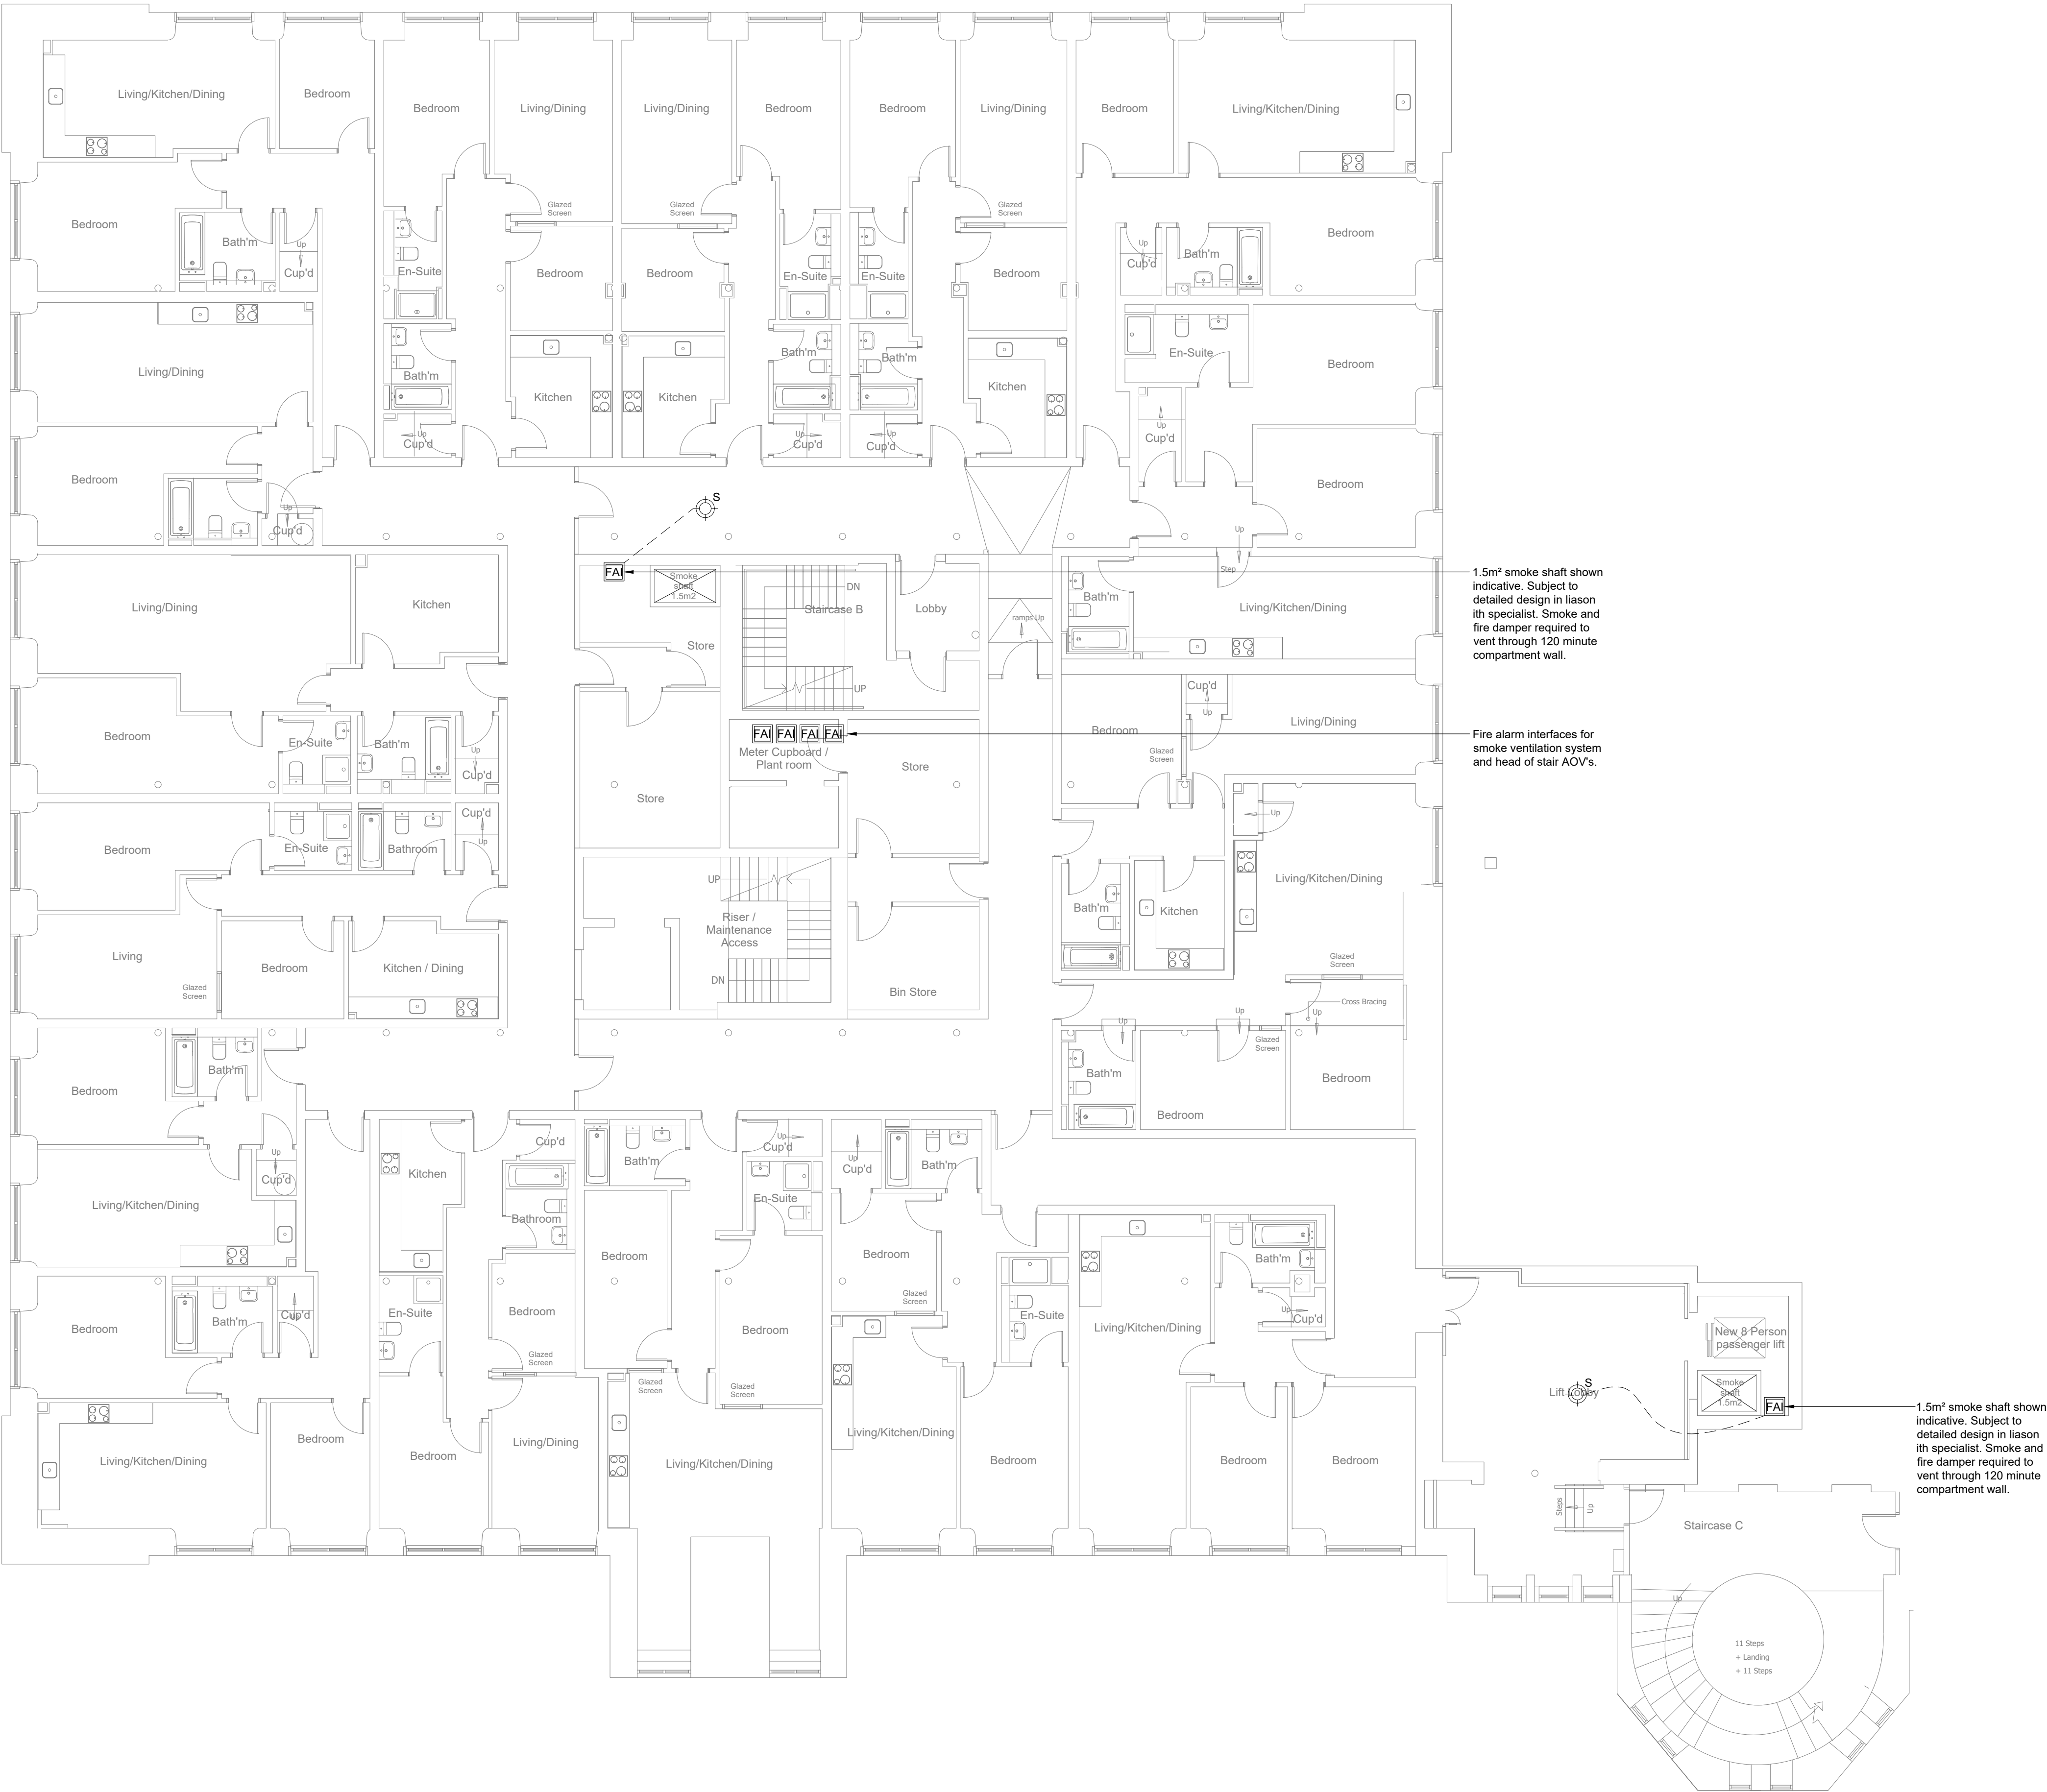

C1	NG	19.03.21	Contract Issue.
P1	NG	26.02.21	Preliminary Issue.
Rev	By	Date	Description



TACE

THE ASSOCIATES CONSULTING ENGINEERS
Portland House
Stanley Green Business Park
Oak Green
Cheshire M6
SK8 6QZ
T: 01457 486 5429
F: 01457 486 0488
E: info@tace.co.uk
W: www.tace.co.uk

Client			
RFP Advisory Group			
Project			
Victoria Mill, Manchester			
Drawing Title			
Proposed Smoke Ventilation Layout Level 02			
Drawn	ET	Date	26.02.21
Checked	NG	Date	26.02.21
Approved	NG	Date	26.02.21
Job No.	PA1484	Drawing No.	VMM-TCE-XX-02-DR-M-57002
		Scale	1:100 at A1
		Issue Status	--
		Rev	C1