



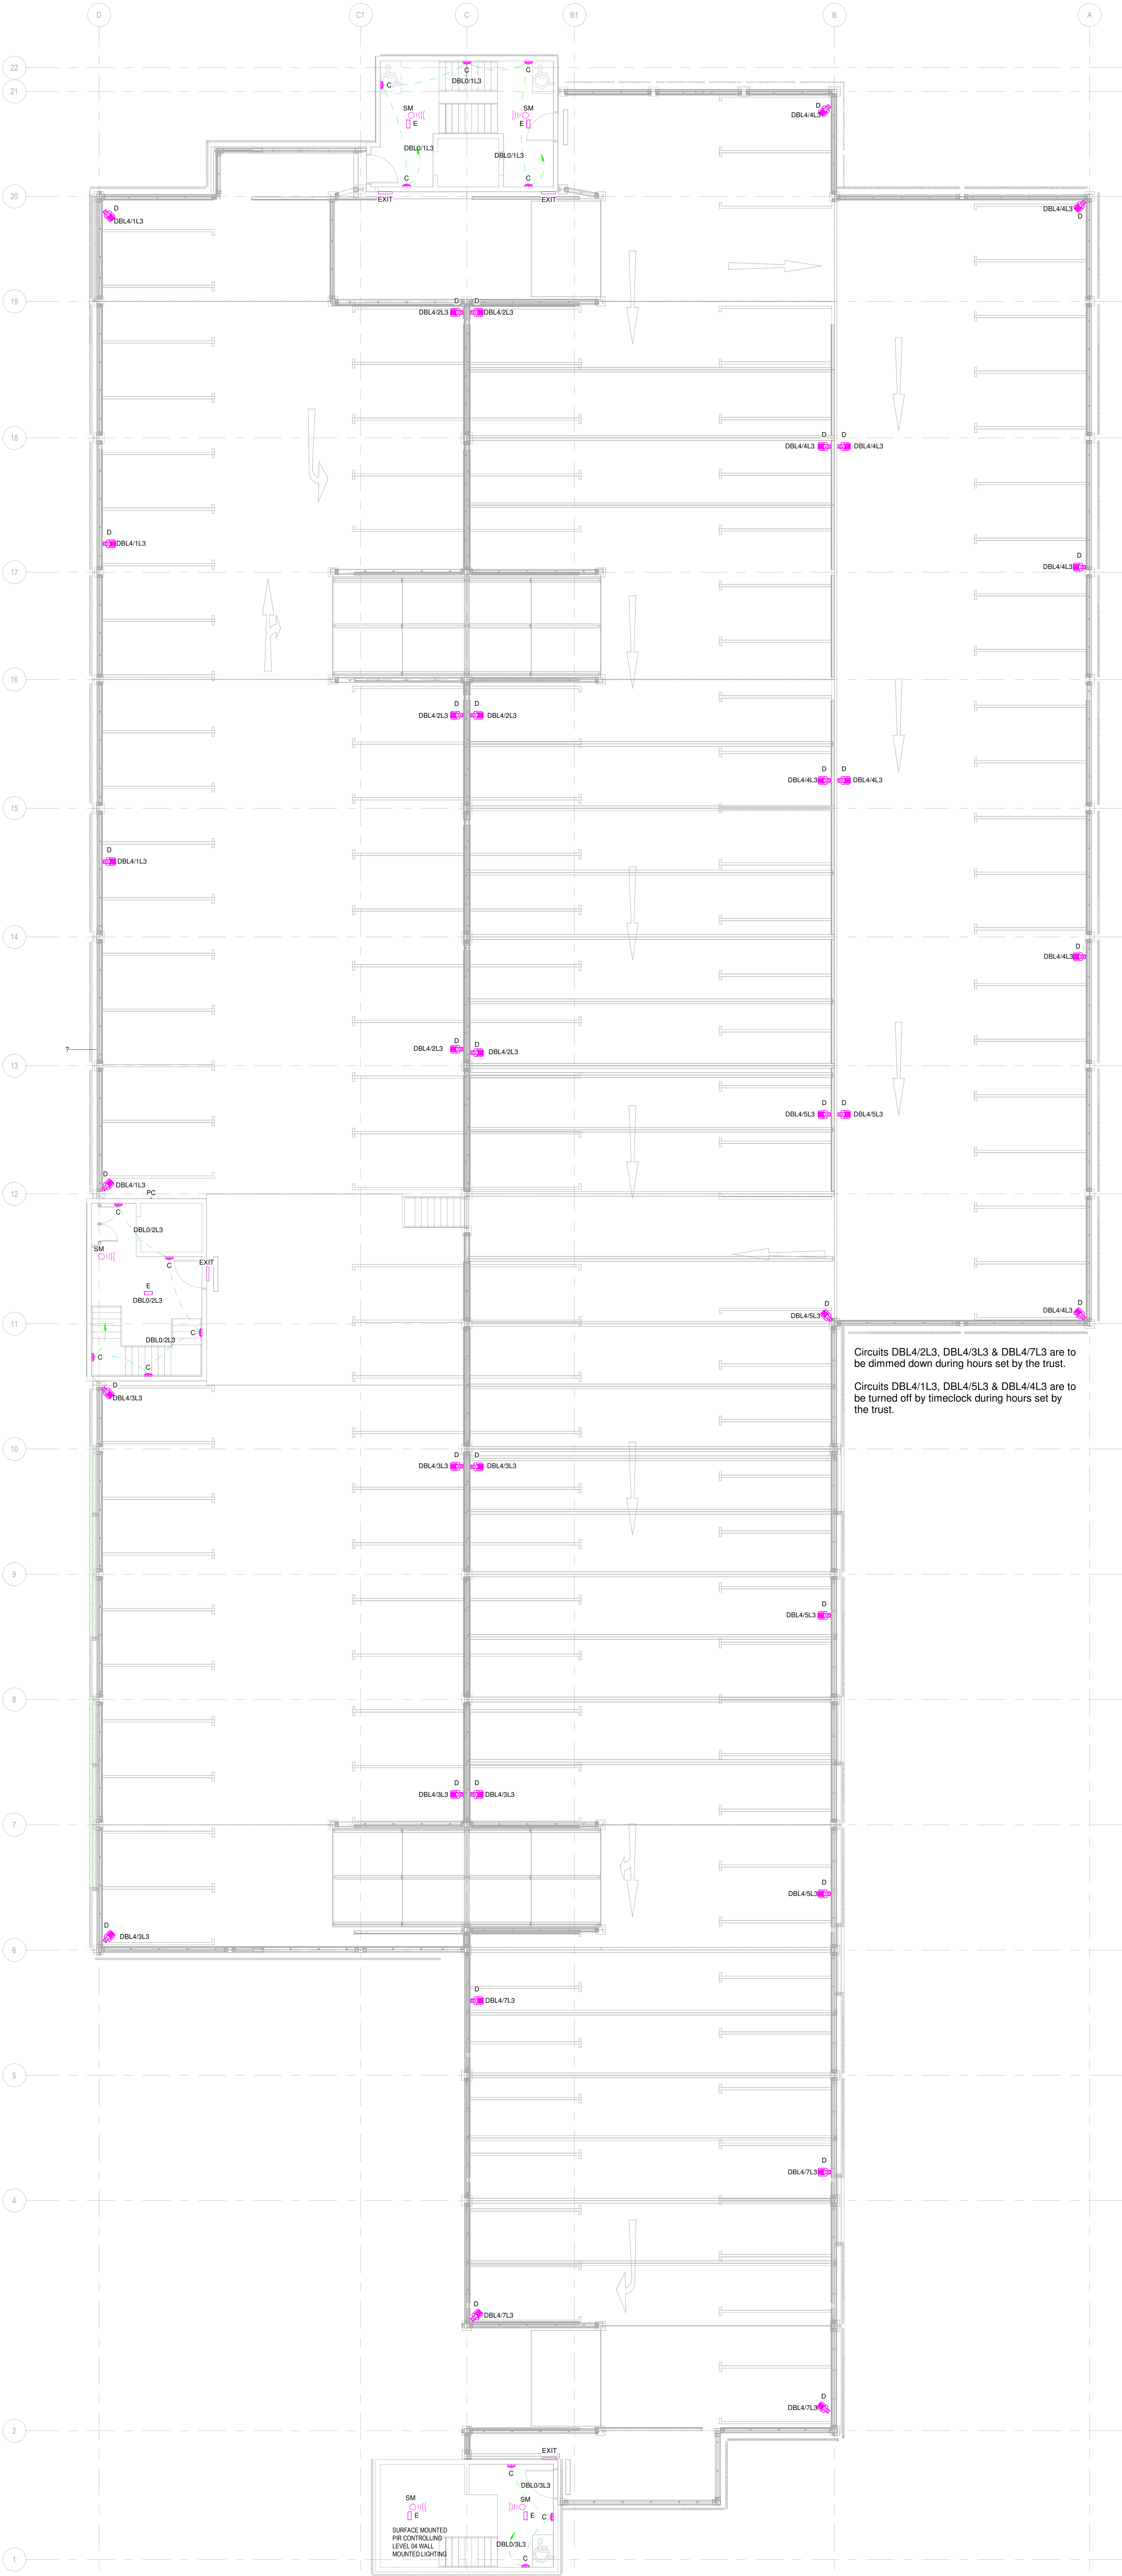

Circuits DBL4/2L3, DBL4/3L3 & DBL4/7L3 are to be dimmed down during hours set by the trust.

Circuits DBL4/1L3, DBL4/5L3 & DBL4/4L3 are to be turned off by timeclock during hours set by the trust.

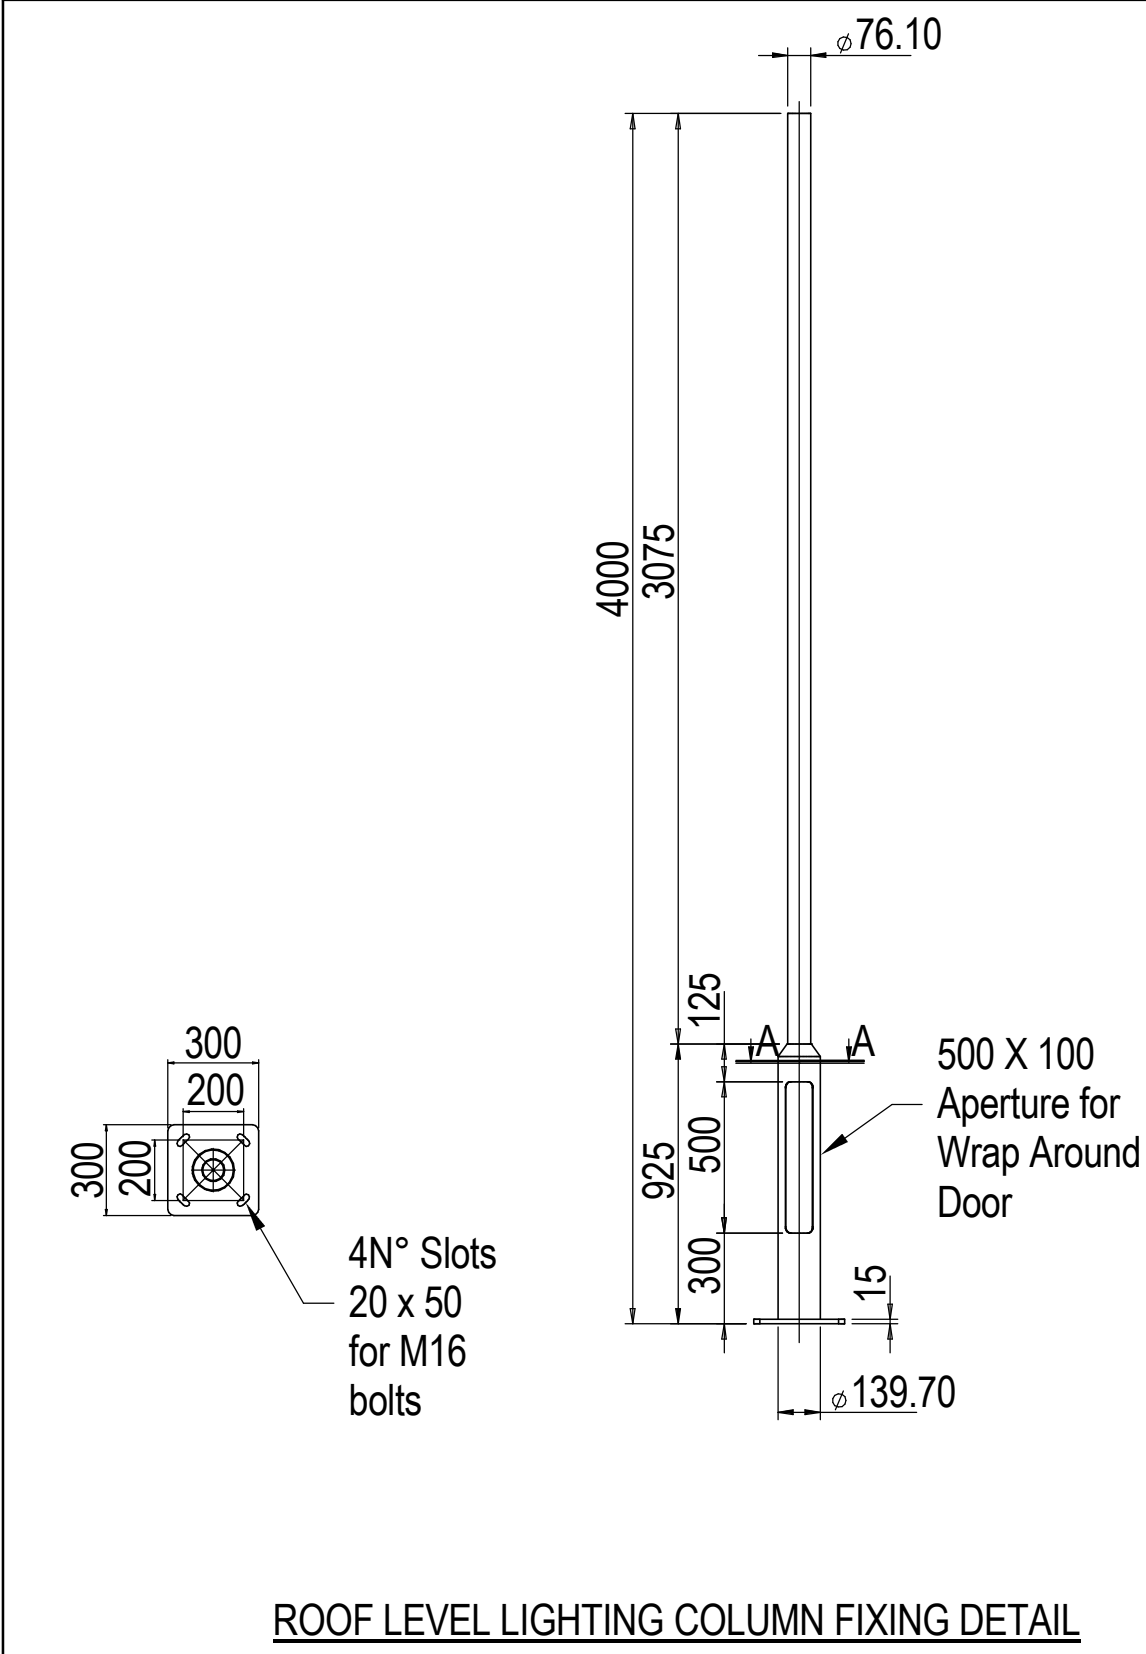

THIS DRAWING IS THE PROPERTY OF HE SIMM. IT IS NOT TO BE REPRODUCED OR TRANSMITTED IN ANY FORM OR BY ANY MEANS, WITHOUT PRIOR WRITTEN CONSENT FROM HE SIMM. THE DRAWING IS FOR INFORMATION ONLY. ALL DIMENSIONS ARE IN MILLIMETERS UNLESS STATED OTHERWISE. THE DRAWING IS NOT TO BE USED FOR CONSTRUCTION OF THE BUILDING WITHOUT THE WRITTEN CONSENT OF HE SIMM. THE DRAWING IS NOT TO BE USED FOR CONSTRUCTION OF THE BUILDING WITHOUT THE WRITTEN CONSENT OF HE SIMM.

NOTES: -63 LIGHTING NOTES

1. ALL SUPPORT SYSTEMS & BRACKETRY SHALL BE DESIGNED & CO-ORDINATED WITH THE BUILDING FABRIC & MECHANICAL SERVICES BY THE ELECTRICAL CONTRACTOR.
2. STEEL CUPS SHALL BE USED FOR ALL POWER CABLES WHERE CLIPPED TO LADDER OR TRAY.
3. THE ELECTRICAL CONTRACTOR SHALL BE RESPONSIBLE TO ENSURE THAT THE ELECTRICAL INSTALLATION FULLY COMPLIES WITH BS7671 - 18TH EDITION.
4. THE ELECTRICAL CONTRACTOR SHALL BE RESPONSIBLE TO ENSURE THAT THE EMERGENCY LIGHTING SYSTEM FULLY COMPLIES WITH BS5266.
5. ALL LIGHTING ON 24HR CIRCUITS IS TO BE CONTROLLED VIA LOCAL TIMECLOCK WITHIN CENTRAL RISER CUPBOARD.
6. LIGHTING ON LEVEL 06 & 05 ARE TO BE CONTROLLED VIA TIMECLOCK WITH A 50% SPLIT IN LUMINAIRES. 50% OF THE LUMINAIRES WILL BE TURNED OFF BETWEEN THE HOURS SET BY THE TRUST WITH 50% OF THE FITTINGS ON OWNED OR THE DURATION SET BY THE TRUST.
7. NON 24HR FITTINGS ARE TO BE CONTROLLED VIA LOCAL PIR MOUNTED ON TRUNKING SYSTEM.

LIGHTING LEGEND

- A THORLUX 23W THORPROOF 1500mm SURFACE MOUNTED LINEAR FITTING
- B THORLUX 30W THORPROOF 1500mm SURFACE MOUNTED LINEAR FITTING
- C THORLUX 15W COBALT WALL MOUNTED FITTING
- D THORLUX 31W STARBEST FLOORLIGHT FITTING ON 4M COLUMN WITH SHROUD CASING
- E HOSTNATIVE SWM FORULAS LED LIFE EMERGENCY SURFACE MOUNTED FITTING
- EXIT HOSTNATIVE KUBUS PIR EMERGENCY EXIT FITTING WITH DIRECTIONAL ARROWS
- LG LIGHTING GRIDSWITCH ASSEMBLY
- LA LONG RANGE SURFACE MOUNTED PIR PRESENCE DETECTOR
- SM SURFACE MOUNTED PIR PRESENCE DETECTOR LOCATED IN CORES
- TC TIME CLOCK
- LC LIGHTING CONTROLLER
- PC EXTERNAL WALL MOUNTED PHOTO CELL

CONSTRUCTION ISSUE	OK	RB
STAGE 4 - FOR STAKEHOLDER PRESENTATION	AC	RB
PRELIMINARY ISSUE	AC	RB
Revised	28/05/21	28/05/21
Approved	28/05/21	28/05/21

HE Simm
ENGINEERING EXCELLENCE

HEAD OFFICE
Suite 5 & 6, Spinnaker House
141 Sefton Street
Liverpool L8 5SH
Tel: 0151 707 3222
Email: info@hesimm.co.uk
hesimm.co.uk

Project Name:
THE CHRISTIE TIERED CAR PARK
Sheet Title:
LEVEL 06 & 05
PROPOSED LIGHTING LAYOUT
Scale (@ A0):
1:100
Drawn: RIBA Stage:
AC 5
Status:
A5
Revision:
C01