



FIRST FLOOR:

EXISTING & PROPOSED FLOOR PLAN

PLANNING DRAWINGS ONLY
NOT TO BE USED ON SITE

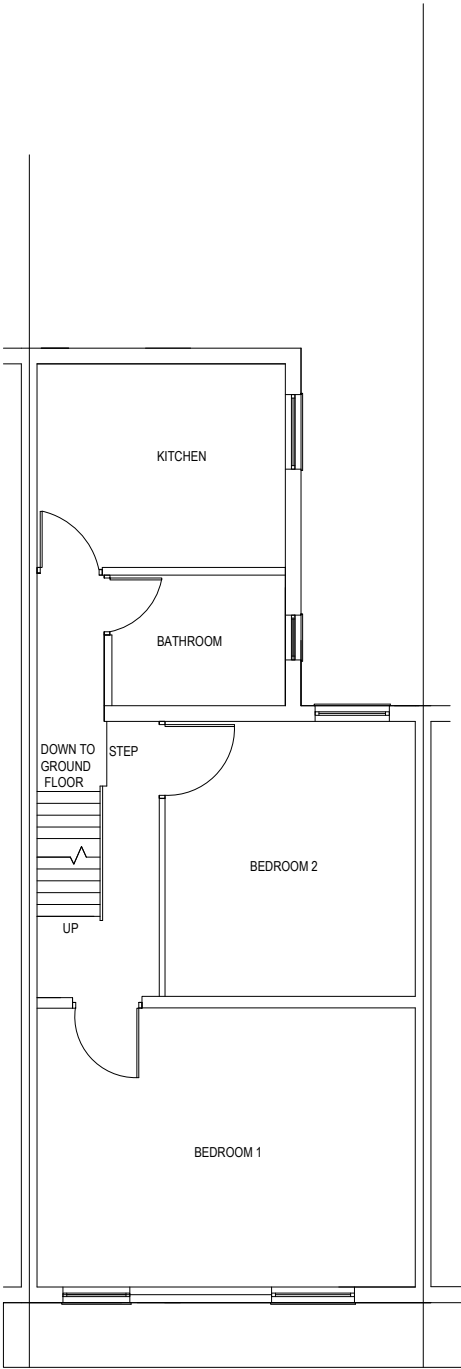

EXISTING FIRST FLOOR

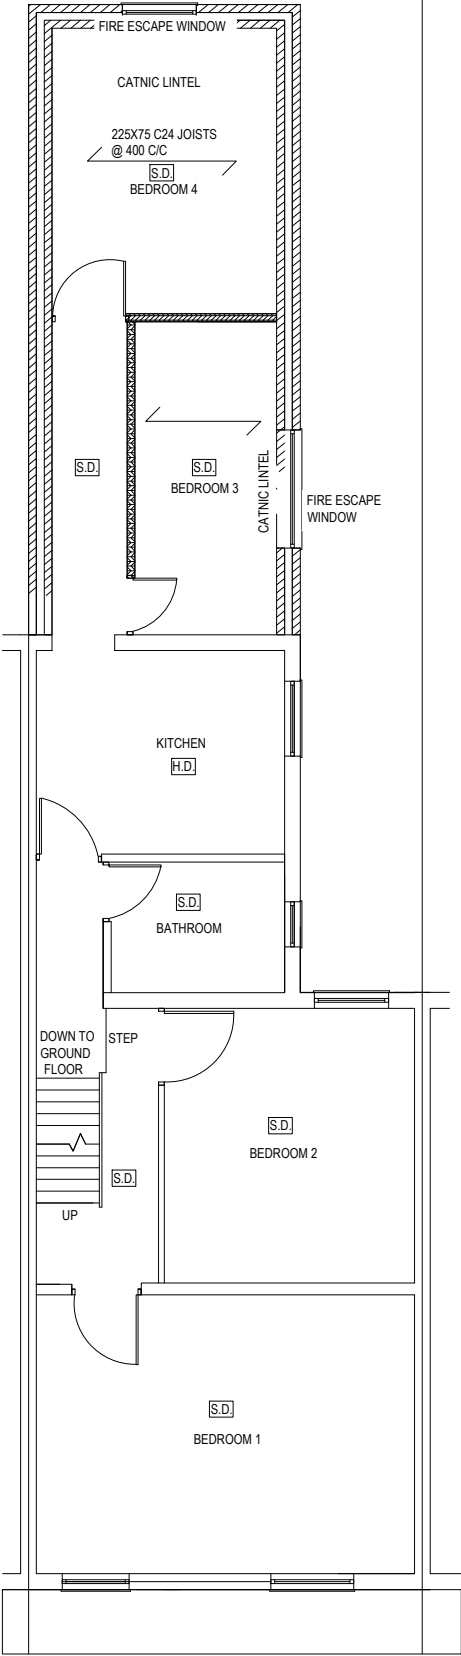

PROPOSED FIRST FLOOR

ALL ELEMENTS OF STRUCTURE ARE TO BE PROVIDED WITH 30 MINS
FIRE RESISTANCE

FIRE DETECTION

SEE FLOOR PLANS FOR POSITION OF SMOKE AND HEAT
DETECTORS.

SMOKE AND HEAT ALARMS TO BE INTERCONNECTED SO THAT
THEY ALL GIVE AN AUDIBLE ALARM WHEN ANY ONE OF THEM IS
ACTIVATED. THE MAXIMUM NUMBER OF SMOKE AND HEAT
ALARMS WHICH MAY BE INTERCONNECTED NOT TO EXCEED
THAT GIVEN IN THE MANUFACTURER'S INSTRUCTIONS.

SMOKE AND HEAT ALARMS TO BE BATTERY BACKED UP AND
PERMANENTLY WIRED TO A CIRCUIT WHICH IS SEPERATELY
FUSED AT THE DISTRIBUTION BOARD. SERVES ONLY SMOKE
ALARMS AND HEAT ALARMS AND WHERE A RESIDUAL
CURRENT DEVICE IS USED, THE CIRCUIT IS NOT CONNECTED
TO A RESIDUAL CURRENT DEVICE WHICH IS ALSO USED BY
ANY OTHER CIRCUIT.

SMOKE DETECTOR

PROVIDE SELF CONTAINED FIRE ALARM SYSTEM WITH DETECTION NOT
MORE THAN 3.0m FROM EVERY BEDROOM DOOR AND NOT MORE THAN
7.5m FROM KITCHEN / LIVING ROOM ETC TO COMPLY WITH BS 5446: PT
1 2000 ANY SMOKE DETECTION TO HABITABLE ROOMS TO BE OPTICAL
TYPE

S.D. - DENOTES POSITION OF SMOKE DETECTOR (SEE FLOOR PLANS)

HEAT DETECTOR
PROVIDE SELF CONTAINED HEAT DETECTOR SYSTEM TO BE
INSTALLED IN KITCHEN AND TO COMPLY WITH BS 5446: PT 2 2003
PROVIDE BACK UP TO HEAT DETECTORS

H.D. - DENOTES POSITION OF HEAT DETECTOR (SEE FLOOR PLANS)

ALL MEASUREMENTS TO BE RE CHECKED
ON SITE BEFORE CONSTRUCTION
COMMENCES

ALL FINISHES ARE TO MATCH THAT OF
EXISTING DWELLING

ALL DRAINAGE TO BE CONNECTED TO
EXISTING
FOUL/STORM SEWER RESPECTIVELY

PROJECT: 50 BARLOW ROAD, LEVENSHULME,
MANCHESTER, M19 3DA

SCALE: 1:50 DRAWN: VH DESIGNER: VH

TITLE: EXISTING & PROPOSED FIRST FLOOR PLAN

CLIENT: ISHFAQ HUSSAIN

DRAWING NUMBER: 19205

REV: B