


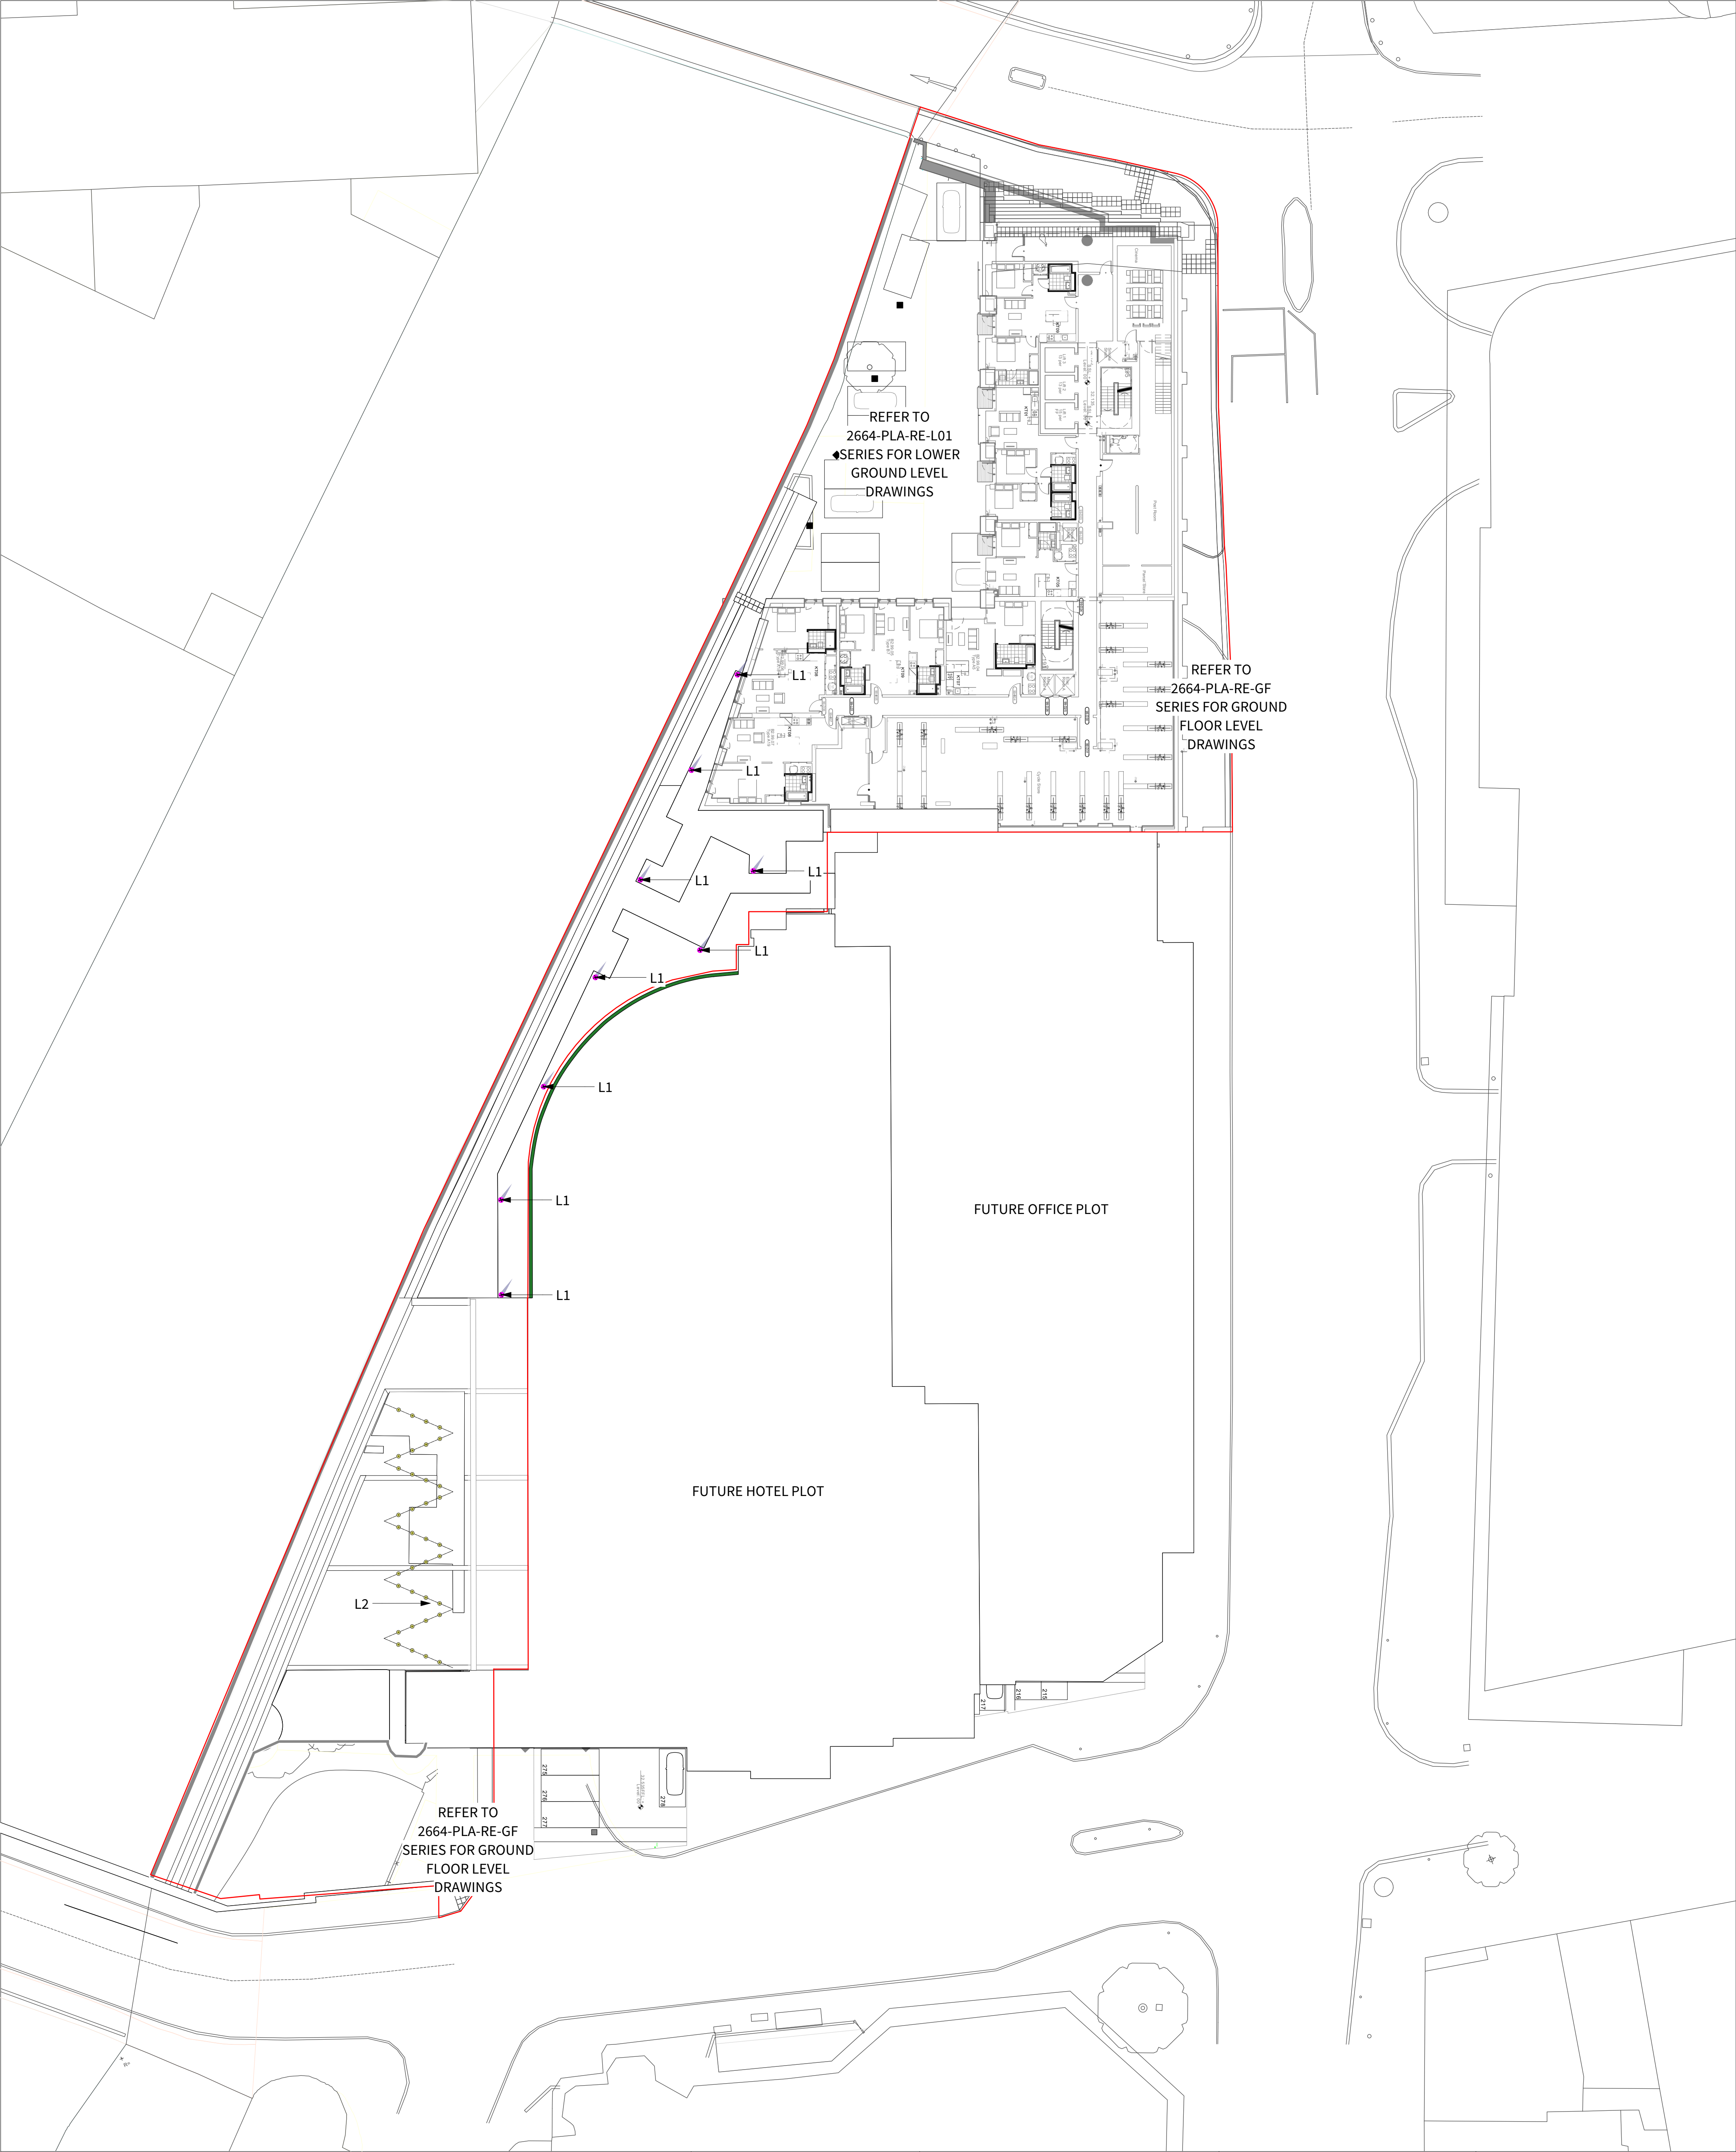

KEY

- L1 - Lighting Bollards**
Material: Corten Steel
Size: 30mm width, 100mm length, 300mm height
Product: Streetline Bright Bollards or similar
- L2 - Catenary Lighting**
Product: Original LED by Lumisphere Products Ltd
LED Colours: Cool White
Cable Colour: Black

S4-P02	22-10-21	Planning Issue	SR	FF
S3-P01	14-09-21	Stage 3 Issue	LB	FF
Revision	Date	Description	Drawn	Apprvd.

Client	Property Alliance Group & Starwood Capital Group		
Project	Renaissance Site Manchester		
Drg Title	Lighting Plan Riverside Terrace Level		
Created on	21/05/21	Created by	LB
		Approved by	FF
Scale	1:250	Size	A1
		Workstage	Stage 3
Drg No.	2664-PLA-RE-L02-DR-L-4002	Suitability	S4
		Revision	P02



Planit I.E. Limited
E: info@planit-ie.com W: planit-ie.com
MANCHESTER
2 Back Grafton St., Altrincham, WA14 1DY
T: 0161 928 9281
LONDON
Unit 6 Waterside, 44-48 Wharf Road, London, N1 7UX
T: 0207 253 5678
LIVERPOOL
Tempest 5.3, 12 Tithebarn Street, Liverpool, L2 2DT
T: 0151 363 1230



THIS DRAWING IS COPYRIGHT PROTECTED AND MAY NOT BE REPRODUCED IN WHOLE OR PART WITHOUT WRITTEN AUTHORITY FROM THE OWNER.

NOTES:

1. Do not scale from this drawing.
2. Always work to noted dimensions.
3. All dimensions are in millimetres unless otherwise stated.
4. All setting out, levels and dimensions to be agreed on site.
5. The dimensions of all materials must be checked on site before being laid out.
6. This drawing must be read with the relevant specification clauses and detail drawings.
7. Order of construction and setting out to be agreed on site.