



GENERAL NOTES

1. DRAWINGS ARE TO BE READ IN CONJUNCTION WITH ALL RELEVANT SPECIFICATIONS, ENGINEERS, ARCHITECTS & SERVICES DRAWINGS, INCLUDING APPROVED BUILDERS WORK DRAWINGS. CONTRACTOR TO NOTIFY ENGINEER OF DISCREPANCIES BETWEEN STRUCTURAL DRAWINGS AND SPECIFICATIONS OR OTHER DRAWINGS.
2. ALL DIMENSIONS ARE IN MILLIMETRES UNLESS NOTED OTHERWISE.
3. DO NOT SCALE FROM THIS DRAWING, WORK TO DIMENSIONS OR CO-ORDINATES PROVIDED. ALL LEVELS ARE IN METRES AND ALL DIMENSIONS ARE IN MILLIMETRES, UNLESS OTHERWISE NOTED. ANY AMBIGUITIES, OMISSIONS AND ERRORS ON DRAWINGS, SHALL BE BROUGHT TO THE ENGINEERS ATTENTION IMMEDIATELY.
4. INFORMATION CONTAINED ON THIS DRAWING IS SCHEME DESIGN ONLY AND REQUIRES FURTHER DETAILED DESIGN AND CO-ORDINATION WITH THE CONTRACTOR, DESIGN TEAM AND APPROPRIATE SUB-CONTRACTORS.

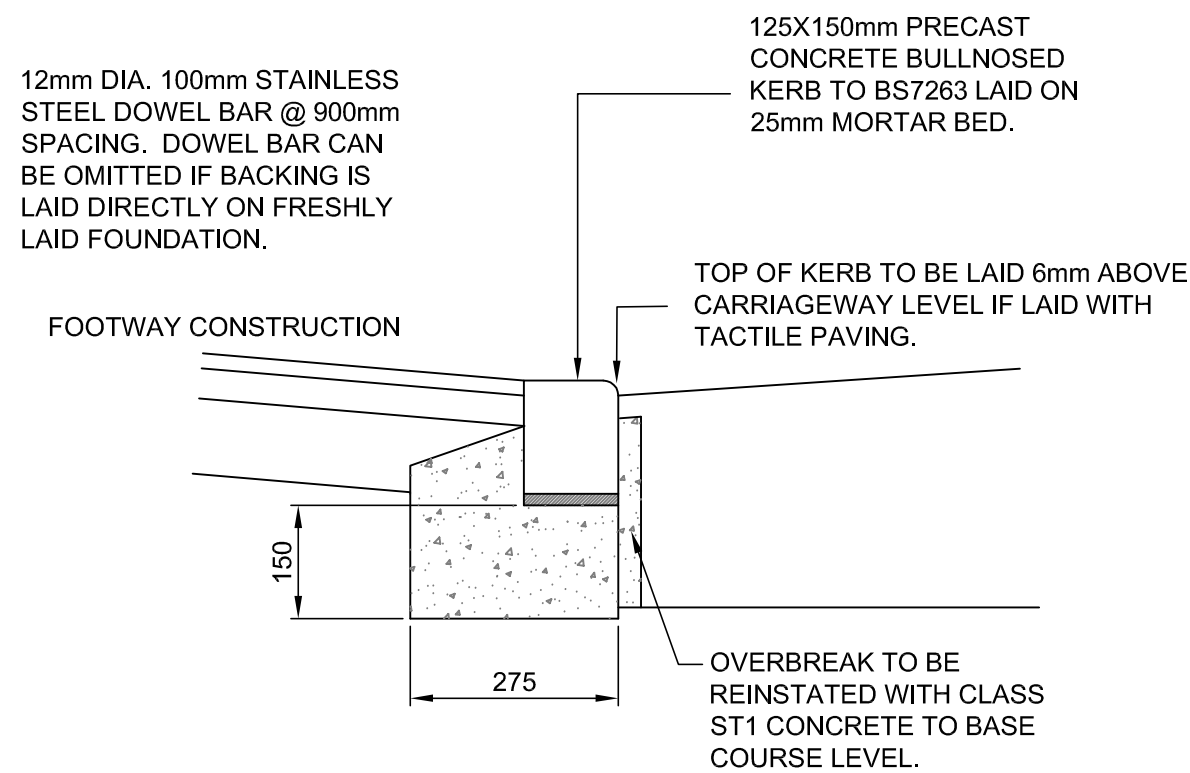


BULL NOSED DROP KERB (BN)

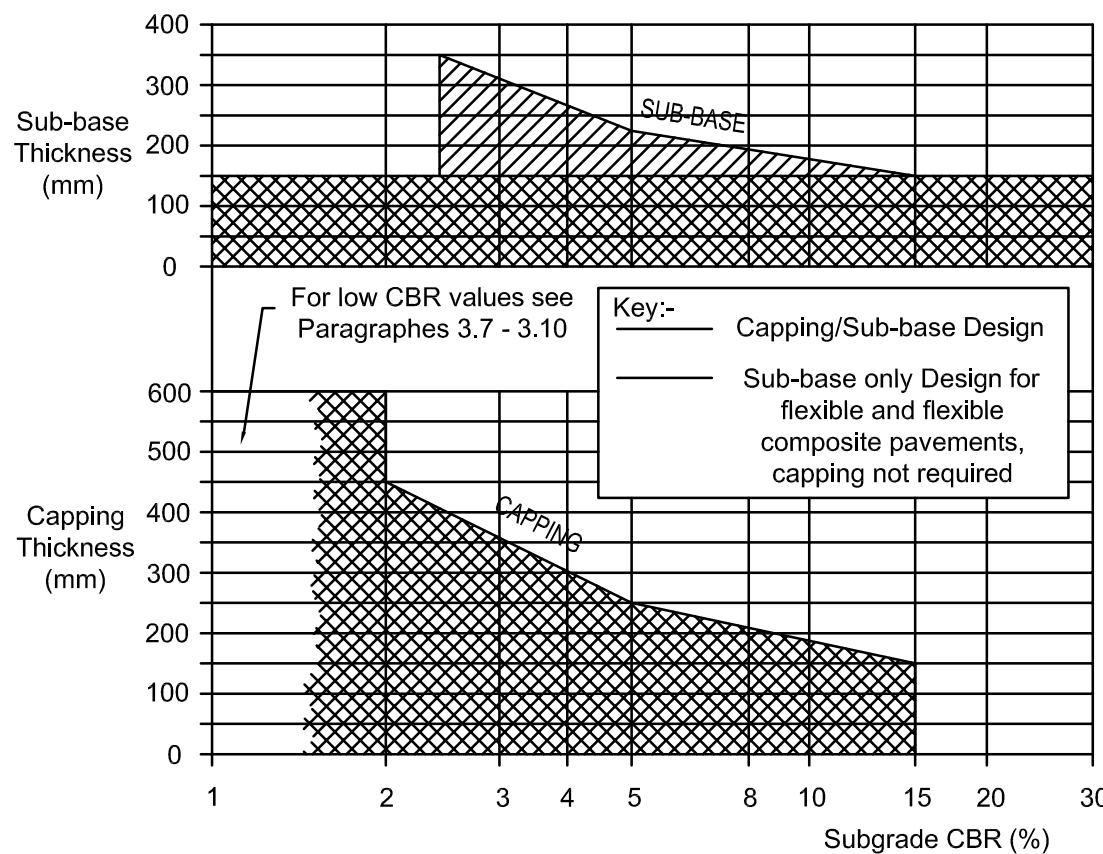


CAPPING & SUB-BASE THICKNESS DESIGN TABLE


(Figure 3.1 of Design Manual for Roads and Bridges Volume 7 Section 2 Part 2 Chapter 3).

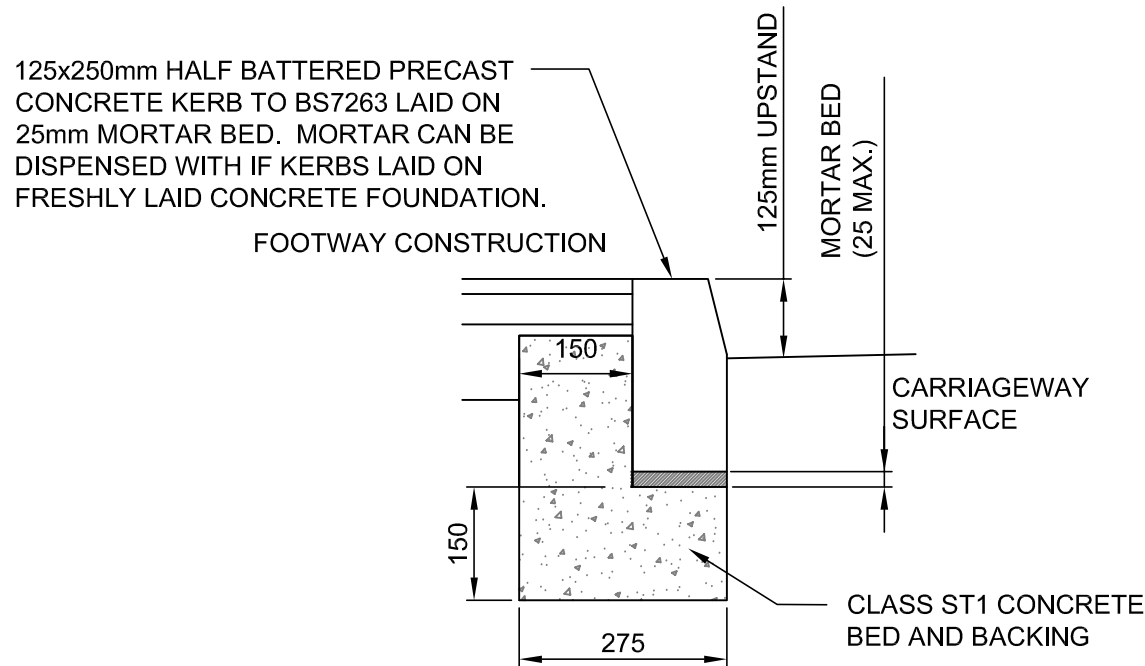


HALF BATTERED KERB (HB2)

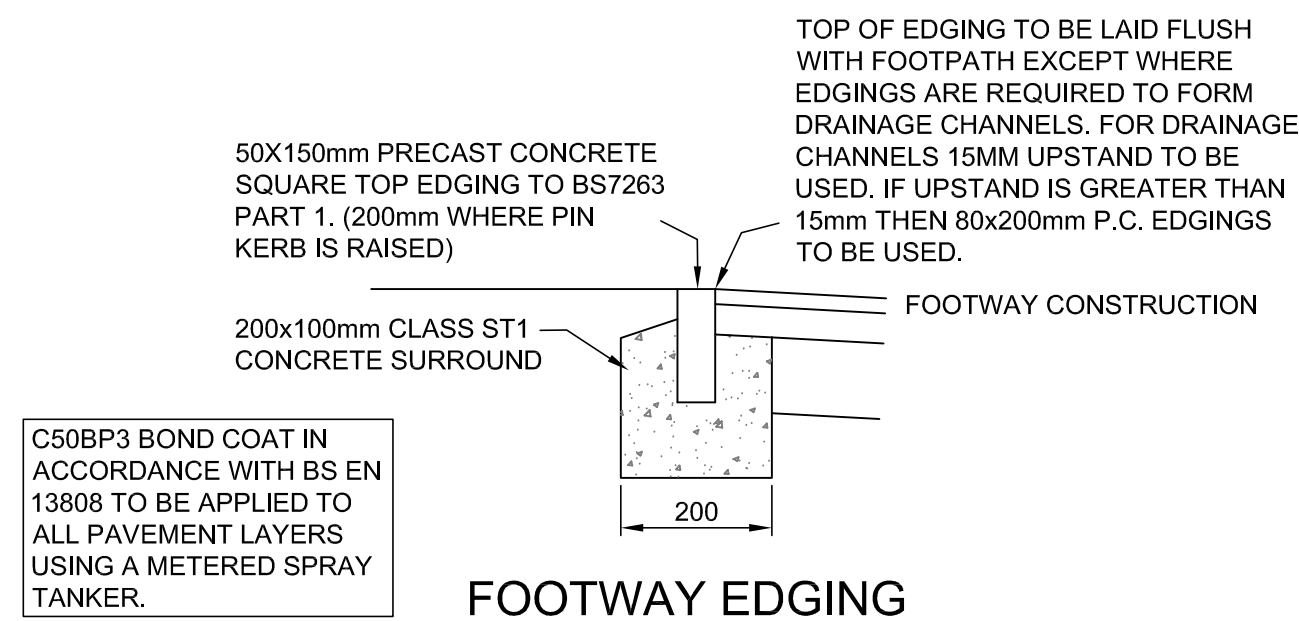


FOOTWAY EDGING

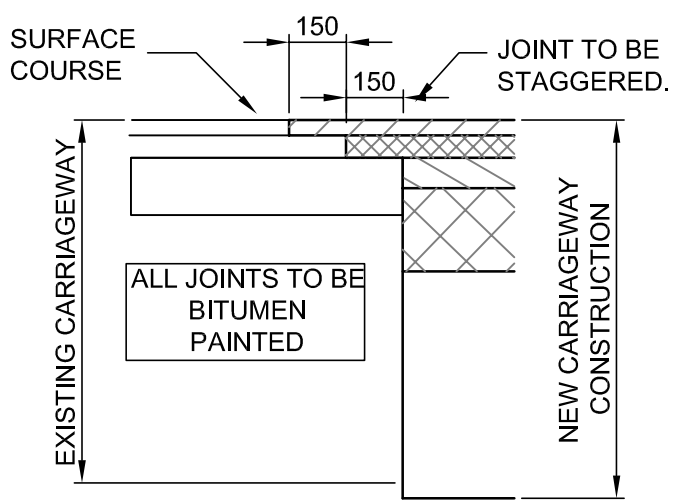


TYPICAL TIE INTO EXISTING CARRIAGEWAY

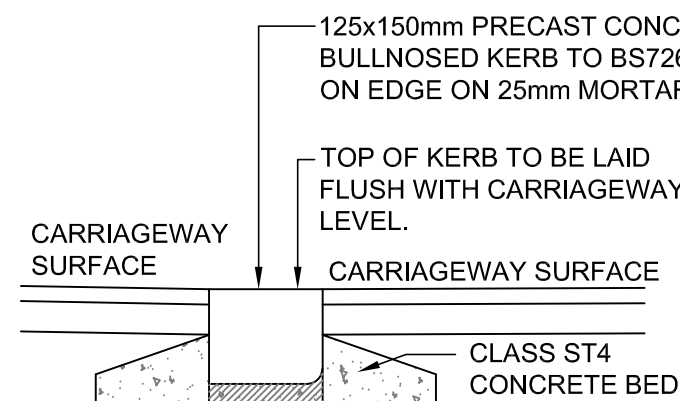


FLUSH KERB

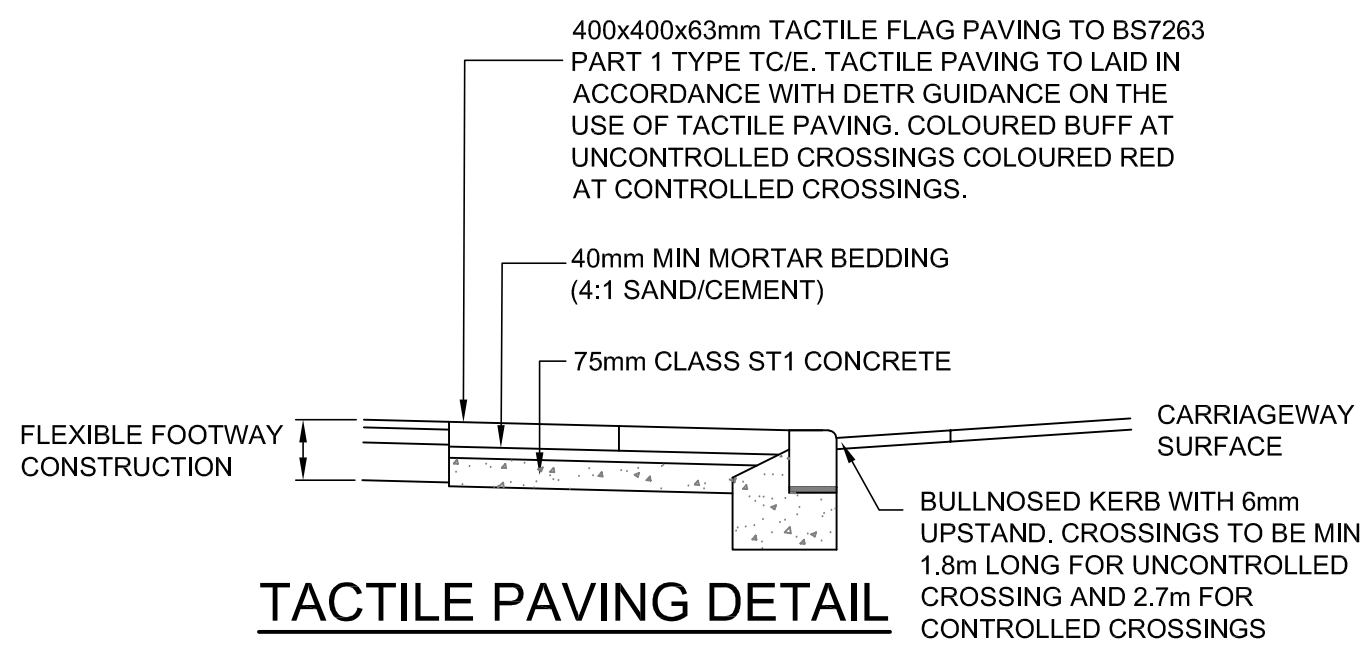

TACTILE PAVING DETAIL

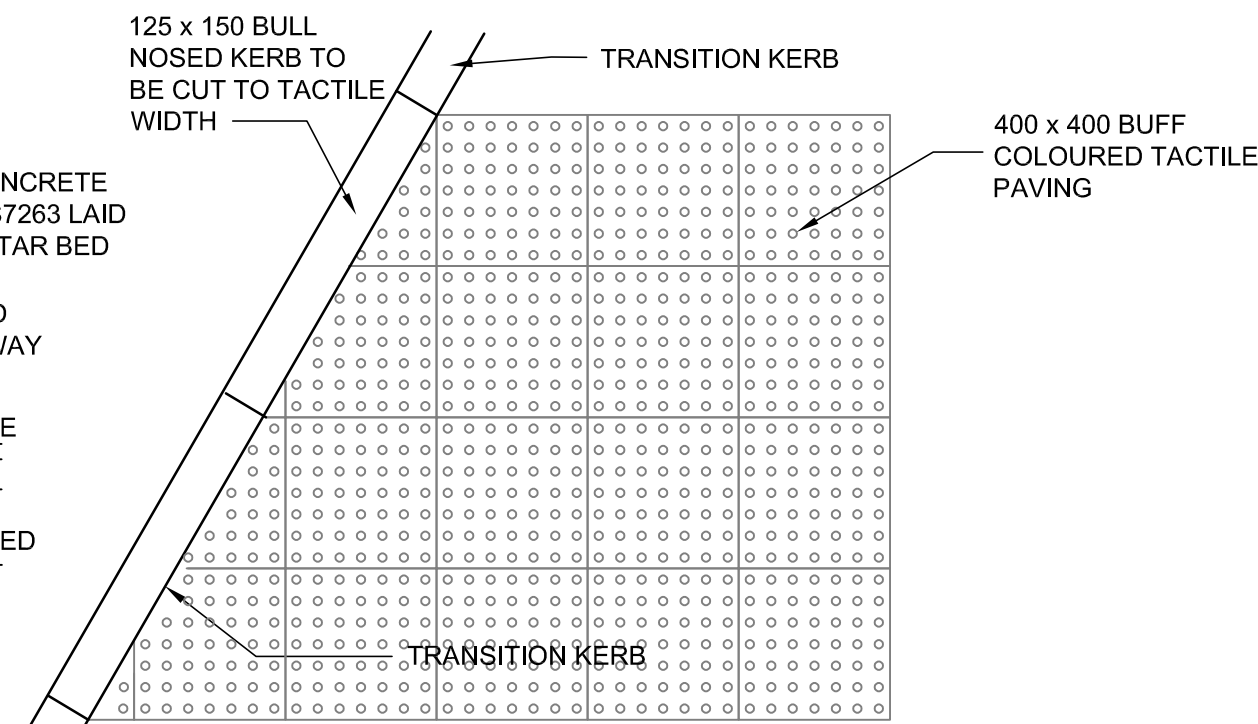

TACTILE PAVING PLAN

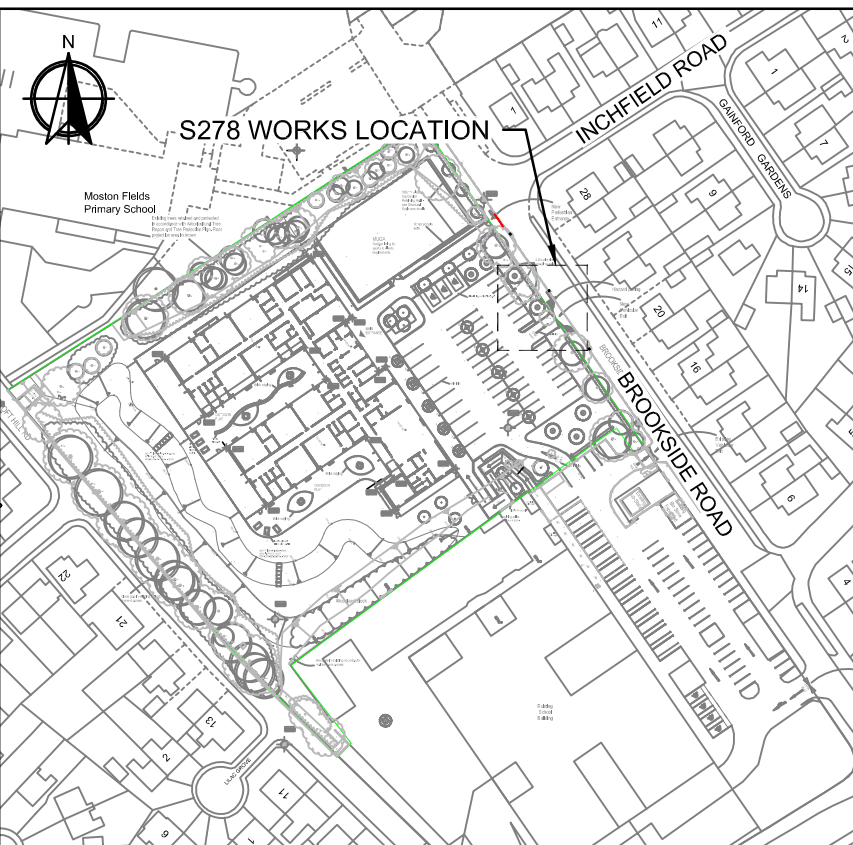

LOCATION PLAN

SCALE 1:2000

No	DATE	DRAWN	REV'D ENG.	AMENDMENT
P1	18.06.21	AS	PG	MCC COMMENTS INCORPORATED

STATUS	PURPOSE OF ISSUE
S2	FOR INFORMATION

COPYRIGHT:
The concepts and the information contained in this document are the copyright of Scott Hughes Design Ltd. Use or copying of the document in whole or in part without written permission of Scott Hughes Design Ltd. constitutes an infringement of copyright.



Scott Hughes Design Ltd.
The Flint Glass Works,
64 Jersey Street,
Manchester M4 6JW
t. 0161 605 0831
f. 0161 605 0832
e.mail@scotthughesdesign.co.uk
Reg No. 4899745

CLIENT	MANCHESTER CITY COUNCIL		
PROJECT	SEN SCHOOLS CAMBERWELL PARK		
DRAFTER	AS	ENGINEER	PG
TITLE	BELLMOUTH S278 MINOR WORKS DETAILS		
SCALE	SHEET	DRAWING No	REV
AS NOTED	A1	CPK-SHD-02-XX-DR-C-90201	P1