





- NOTES
1. LIGHTING TO BE CONTROLLED VIA TIMECLOCK & PHOTOCELL.
 2. SPARE DUTY TO BE TERMINATED IN DRAW PIT OUTSIDE OF BUILDING FOR FUTURE.
 3. ALL CONTAINMENT TO BE CONCEALED.

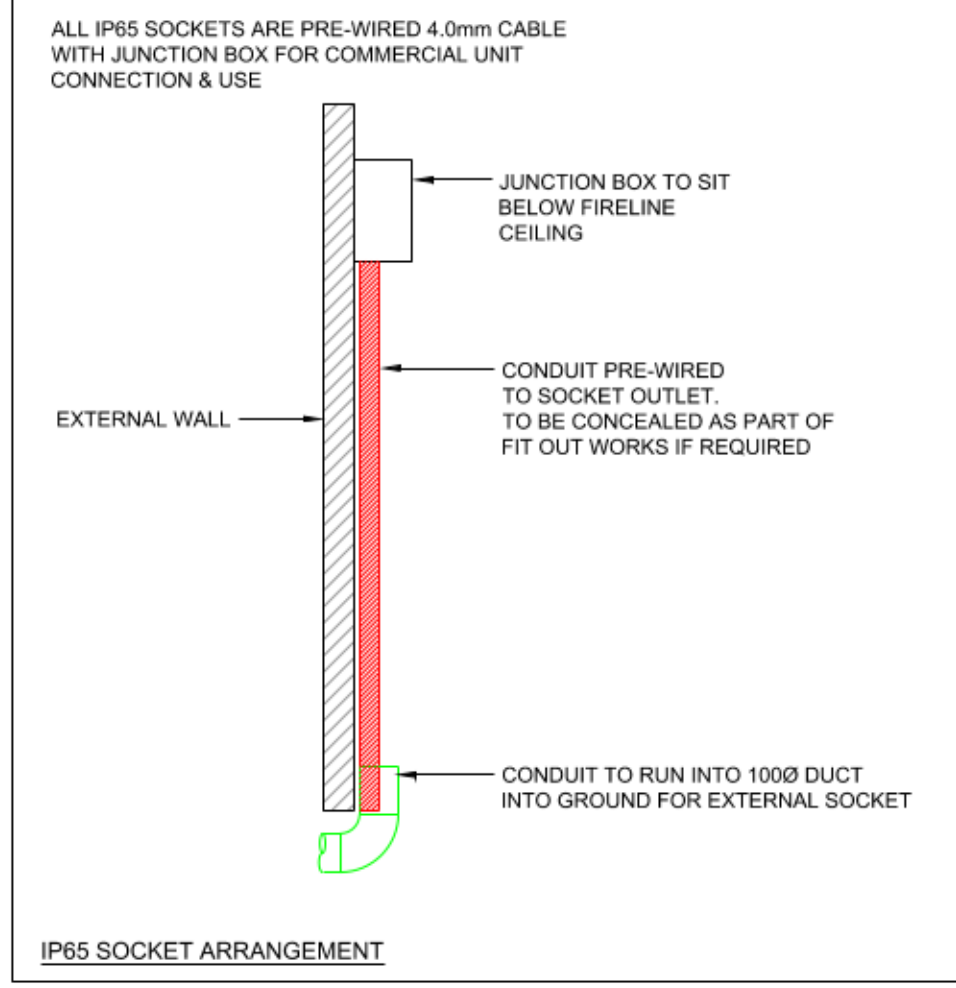

- LEGEND
- UNDERGROUND PVC DUCT - SIZE AS SHOWN
 - 50x50mm L&P TRUNKING
 - TRAY FOR EXTERNAL LIGHTING
 - DRAW PIT 600x600
 - POP UP POWER POINTS - 63A LANDLORD SUPPLIED MULTI OUTLET COMMANDO, 2x16A 230V & 2x32A 230V
 - WEATHER PROOF IP65 TWIN SOCKET
 - DENOTES 3 HR INTEGRAL EMERGENCY
 - LISTED BUILDINGS WORKS BOUNDARY - SEPARATE PACKAGE TO MAIN BUILD. BLOCKS C, E & F

LUMINAIRE PARTS LIST				
INDEX	MANUFACTURER	LUMINAIRE TYPE	CONNECTED LOAD	COMMENTS
A	SPURLITE LTD	WALL MOUNTED LED LUMINAIRE	3W	WALL MOUNTED
A1	SPURLITE LTD	RECESSED LED SQUARE LUMINAIRE	3W	SQUARE RECESSED
A2	SPURLITE LTD	RECESSED LED CIRCULAR LUMINAIRE	3W	CIRCULAR RECESSED
C	SPURLITE LTD	SURFACE LOW PROFILE LED SURFACE MOUNTED	1100/16	WITH EXTERNAL CHIMNEY
D	SPURLITE LTD	HARM GUARD 2000 BODIA	5 W	GROUND RECESSED
F	SPURLITE LTD	JURY & FLOOD 207 240LM 2W 3000K	5 W	GROUND MOUNTED ON A SPINE
G	SPURLITE LTD	JURY & FLOOD 1027 1000LM 2W 3000K	5 W	GROUND MOUNTED ON A SPINE
H1	SPURLITE LTD	SURFACE LOW PROFILE LED SURFACE MOUNTED	1100/16	FULL FORMER TOP OF BRUSH
H2	SPURLITE LTD	SURFACE LOW PROFILE LED SURFACE MOUNTED	1100/16	SHOULDER SIDE OF BRUSH
I	SPURLITE LTD	SURFACE LOW PROFILE LED SURFACE MOUNTED	1100/16	SHOULDER SIDE OF BRUSH
J	SPURLITE LTD	FESTOON LIGHTING	200 PER 10M	SUPPLEMENTED FESTOON
K	SPURLITE LTD	FAIRY LIGHTS	2.20 PER STRING	SUPPLEMENTED FAIRY LIGHTS
L	SPURLITE LTD	HARM GUARD 200 BODIA	5 W	GROUND RECESSED
M	SPURLITE LTD	PHOTOCELL		

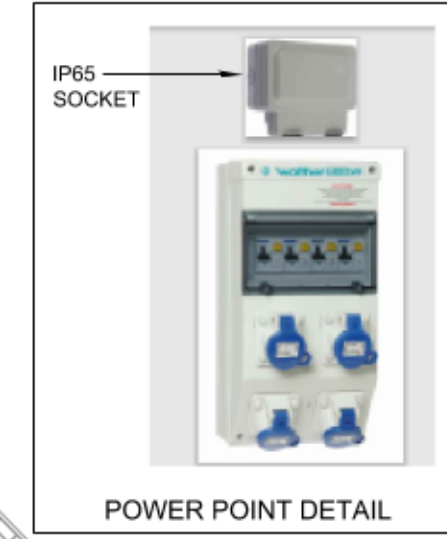

Rev	Description	Drawn	Date
C06	CONSTRUCTION ISSUE	GP	02.03.21
C05	CONSTRUCTION ISSUE	SB	15.04.20
C04	CONSTRUCTION ISSUE	SB	11.02.20
C03	CONSTRUCTION ISSUE	GP	07.11.19
C02	CONSTRUCTION ISSUE	SB	17.10.19
C01	CONSTRUCTION ISSUE	SB	20.09.19
P01	PRELIMINARY ISSUE	DS	26.03.19

Briggs & Forrester Living Ltd
Bembridge House
Bembridge Drive
Kingsthorpe
Northampton
NN2 6LZ
www.briggsandforrester.co.uk
Registered in England No. 1087941

Tel: (01604) 720072

Client:
Mount Anvil

Project:
Kampus Manchester

Drawing Title:
EXTERNAL LIGHTING LAYOUT LEVEL 00

Scale: 1:200 @ A1
Checked: *DS*
Drawing Number: **4006-BAF-ZZ-00-DR-E-(63)-012**
Sustainability: **S4**
Drawing Status: **CONSTRUCTION**

This drawing is copyright and may not be reproduced either in part or full without written permission from Briggs & Forrester Group Ltd.
DO NOT SCALE OFF THIS DRAWING

bsi
BIM Verified
Design & Construction
Capital/Delivery
PAS 1192:2
VC 658367