




FLOOR PLAN

ELECTRICAL LEGEND:	
NOTE SEE TO REVIEW AND CONFIRM LOCATIONS OF ANY MECHANICAL AND ELECTRICAL FIXTURES AND FITTINGS APPLICABLE TO THIS ROOM.	
	LINE INDICATES DADO TRUNKING IN PLAN
	DOUBLE SWITCHED SOCKET
	SINGLE SWITCHED SOCKET
	SINGLE LOCKABLE CLEANERS SOCKET
	1 GANG 1 WAY LIGHT SWITCH
	DOUBLE POLE SWITCH
	UNSWITCHED FUSE SPUR
	SWITCHED FUSE SPUR
	ROTARY ISOLATOR
	DATA POINT
	COAX POINT
	PANIC ALARM
	DDA TOILET FLASHING BEACON
	FAIL SAFE OPEN DEVICE WALL MOUNTED GREEN BREAK GLASS TYPE
	PUSH BUTTON TO OPEN MANUAL EGRESS DOOR RELEASE SWITCH
	MANUAL CALL POINT
	DISTRIBUTION BOARD
	INTERFACE UNIT
	OVERDOOR INDICATOR

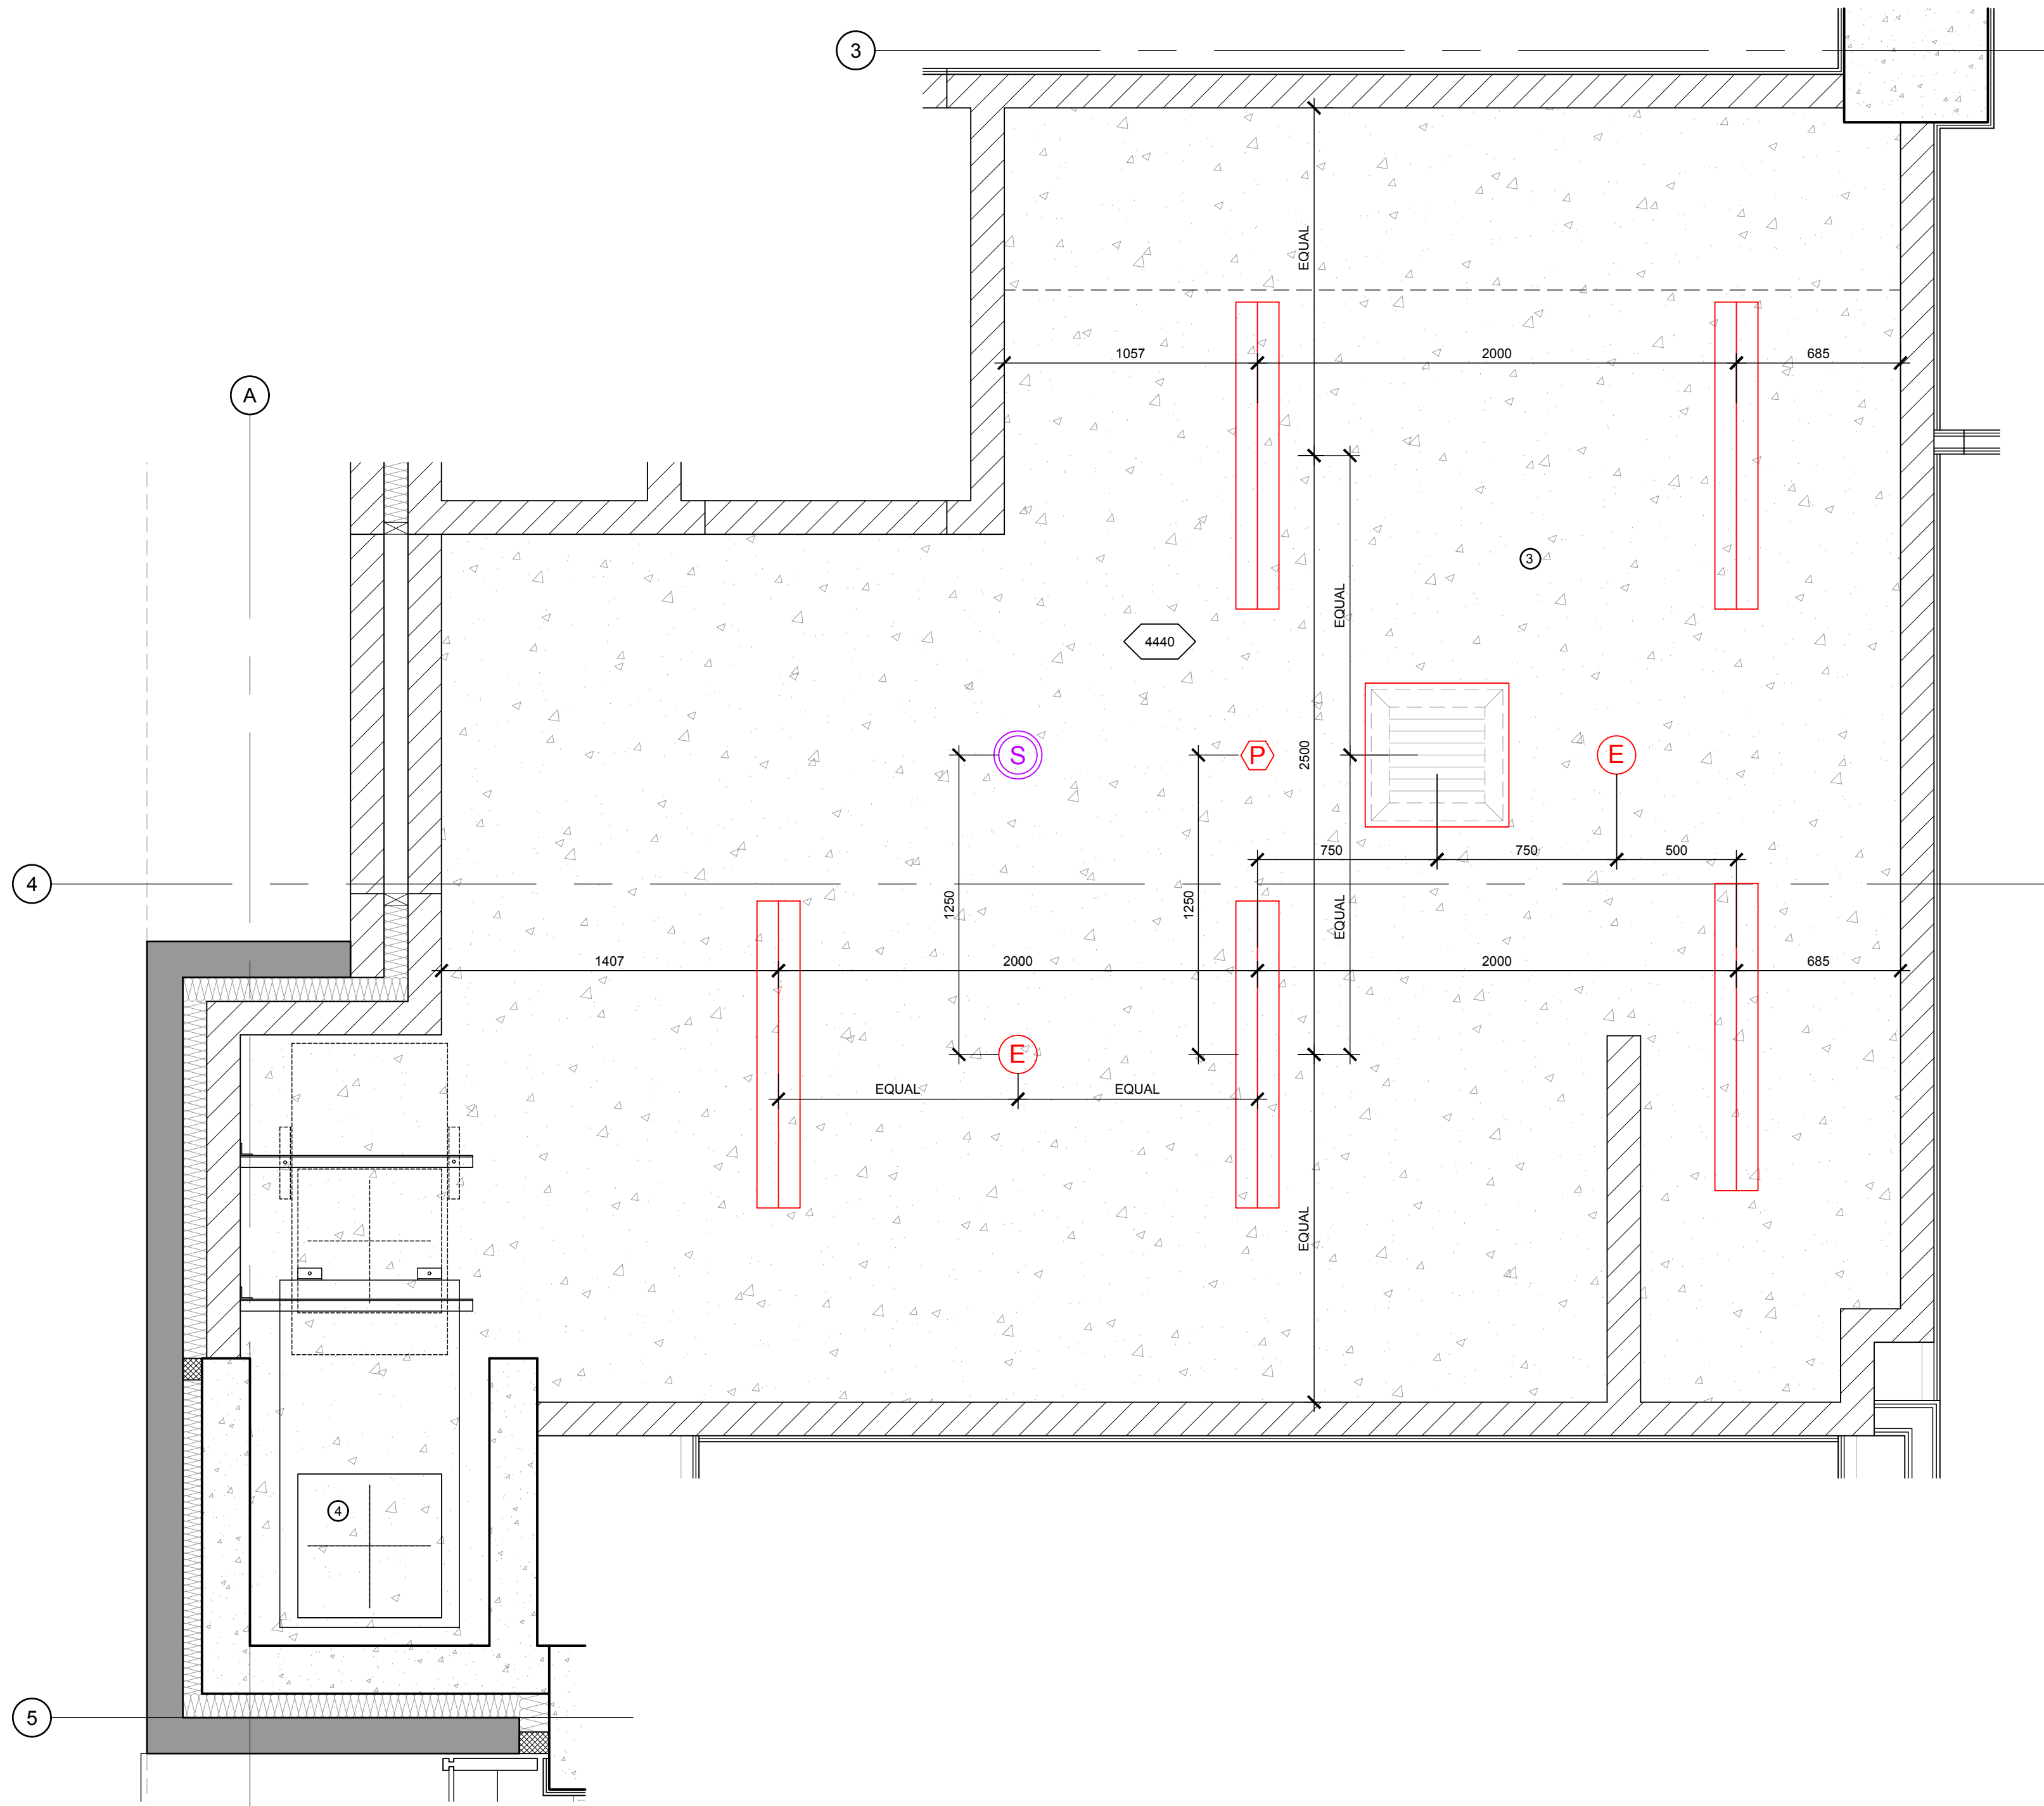

CEILING PLAN

CEILING LEGEND:	
	600x600mm RECESSED FLAT PANEL LED LUMINAIRE
	SURFACE MOUNTED STEEL BONDED LED LUMINAIRE WITH POLYCARBONATE DIFFUSER
	LED RECESSED DOWNLIGHT
	RECESSED EMERGENCY DOWNLIGHT
	MOTION SENSOR
	VRF INDOOR UNIT
	SMOKE DETECTOR
	SMOKE DETECTOR/SOUNDER
	HEAT SENSOR/SOUNDER
	MULTI SENSOR/SOUNDER
	ACCESS HATCH

NOTES:	
THIS DRAWING SHOULD BE READ IN CONJUNCTION WITH THE LATEST LRW L(20) SERIES GENERAL ARRANGEMENT DRAWINGS. DRAWING AND SPECIFICATIONS TO BE READ IN CONJUNCTION WITH DALATA GENERAL WORKS REQUIREMENTS DOCUMENT.	
FOR FLOOR, SKIRTING, WALL AND CEILING FINISHES REFER TO L(43) DRAWING SERIES FOR SPECIFICATIONS.	
ALL DRAWINGS AND SPECIFICATIONS ARE SUBJECT TO DALATA APPROVAL.	
	RED LINE INDICATES PLYWOOD PATTERNS

SPECIFICATION KEY - REFUSE STORE	
ITEM	SPECIFICATION
FINISHES	
	FLOOR - FLOOR SEALER 2
	WALL - MASONRY WALL SEALER
	CEILING - EXPOSED SOFFIT
FURNITURE	
	REFUSE CHUTE

GENERAL NOTES:

ALL DIMENSIONS ARE TO BE CHECKED ON SITE WITH ANY DISCREPANCIES REPORTED TO THE ARCHITECT PRIOR TO THE WORKS BEING CARRIED OUT.

ALL WORKS ARE TO BE IN ACCORDANCE WITH THE PLANNING APPROVAL AND ANY SUBSEQUENT APPROVED LOCAL AUTHORITY PLANNING CORRESPONDENCE INCLUDING DRAWINGS, DOCUMENTS AND REPORTS.

ALL WORKS ARE TO COMPLY WITH THE BUILDING REGULATIONS, BRITISH STANDARDS, CODE OF PRACTICE, AND ANY LOCAL STATUTORY REQUIREMENTS.

ALL WORKS ARE TO COMPLY WITH CURRENT HEALTH AND SAFETY LEGISLATION, H.S.E. RECOMMENDATIONS/GUIDANCE AND THE CURRENT C.D.M. REGULATIONS.

THIS DRAWING IS TO BE READ IN CONJUNCTION WITH LEACH RHODES WALKER ARCHITECTS GENERAL ARRANGEMENT (L CODE) DRAWINGS, TOGETHER WITH RELEVANT DETAILED (A CODE) DRAWINGS AND SPECIFICATIONS.

FOR ALL STRUCTURAL WORKS REFER TO THE STRUCTURAL ENGINEERS INFORMATION.

FOR ALL MECHANICAL AND ELECTRICAL WORKS REFER TO THE MECHANICAL AND ELECTRICAL ENGINEERS INFORMATION.

FOR ALL ABOVE GROUND DRAINAGE WORKS REFER TO THE PUBLIC HEALTH ENGINEERS INFORMATION.

ALL PRODUCTS SPECIFIED ARE TO BE INSTALLED STRICTLY IN ACCORDANCE WITH THE MANUFACTURERS RECOMMENDATIONS, SPECIFICATION AND DETAILS.

C	REFUSE BINN ADDED	RB	RW	11.02.21
B	VENTILATION ADDED	RB	RW	22.12.21
A	ELECTRICAL FITTINGS ADDED AND LEGEND ADDED	RB	RW	15.12.20
REV	REVISIONS	DATE	BY	CHK

DO NOT SCALE OFF THIS DRAWING

© LEACH RHODES WALKER 2021

LeachRhodesWalker
Architects

info@lrw.co.uk | www.lrw.co.uk
50 Deansgate Place Manchester M2 5LH

Manchester London Buchanan
+44 (0)161 833 0211 +44 (0)207 201 2160 +40 (0)1950 4006

Manchester +44 (0)161 835 0211		London +44 (0)207 201 2160		Buckham +40 (2) 6550 4026	
client					
PROPERTY ALLIANCE GROUP					
project					
55 PORTLAND STREET MANCHESTER					
project no		drawing no		rev	
7684		L(70)07		C	
description					
REFUSE STORE LAYOUTS					
scale		date drawn		drawn by	
1:20 @ A0		26.11.20		RB	
authorised by		checked by			
RW		RB			
no. of sheets					
purpose of issue					
drawing					
drawing type					
order					
approval					
correction					