


© This Drawing & Design is the copyright of Jenkins Design Services Ltd and should not be reproduced without written consent.

Contractors are to check all levels & dimensions on site prior to site works commencing & report discrepancies to the Designers.


DO NOT SCALE FROM THIS DRAWING

PLANNING


Recessed LED CAT 2 light fitting

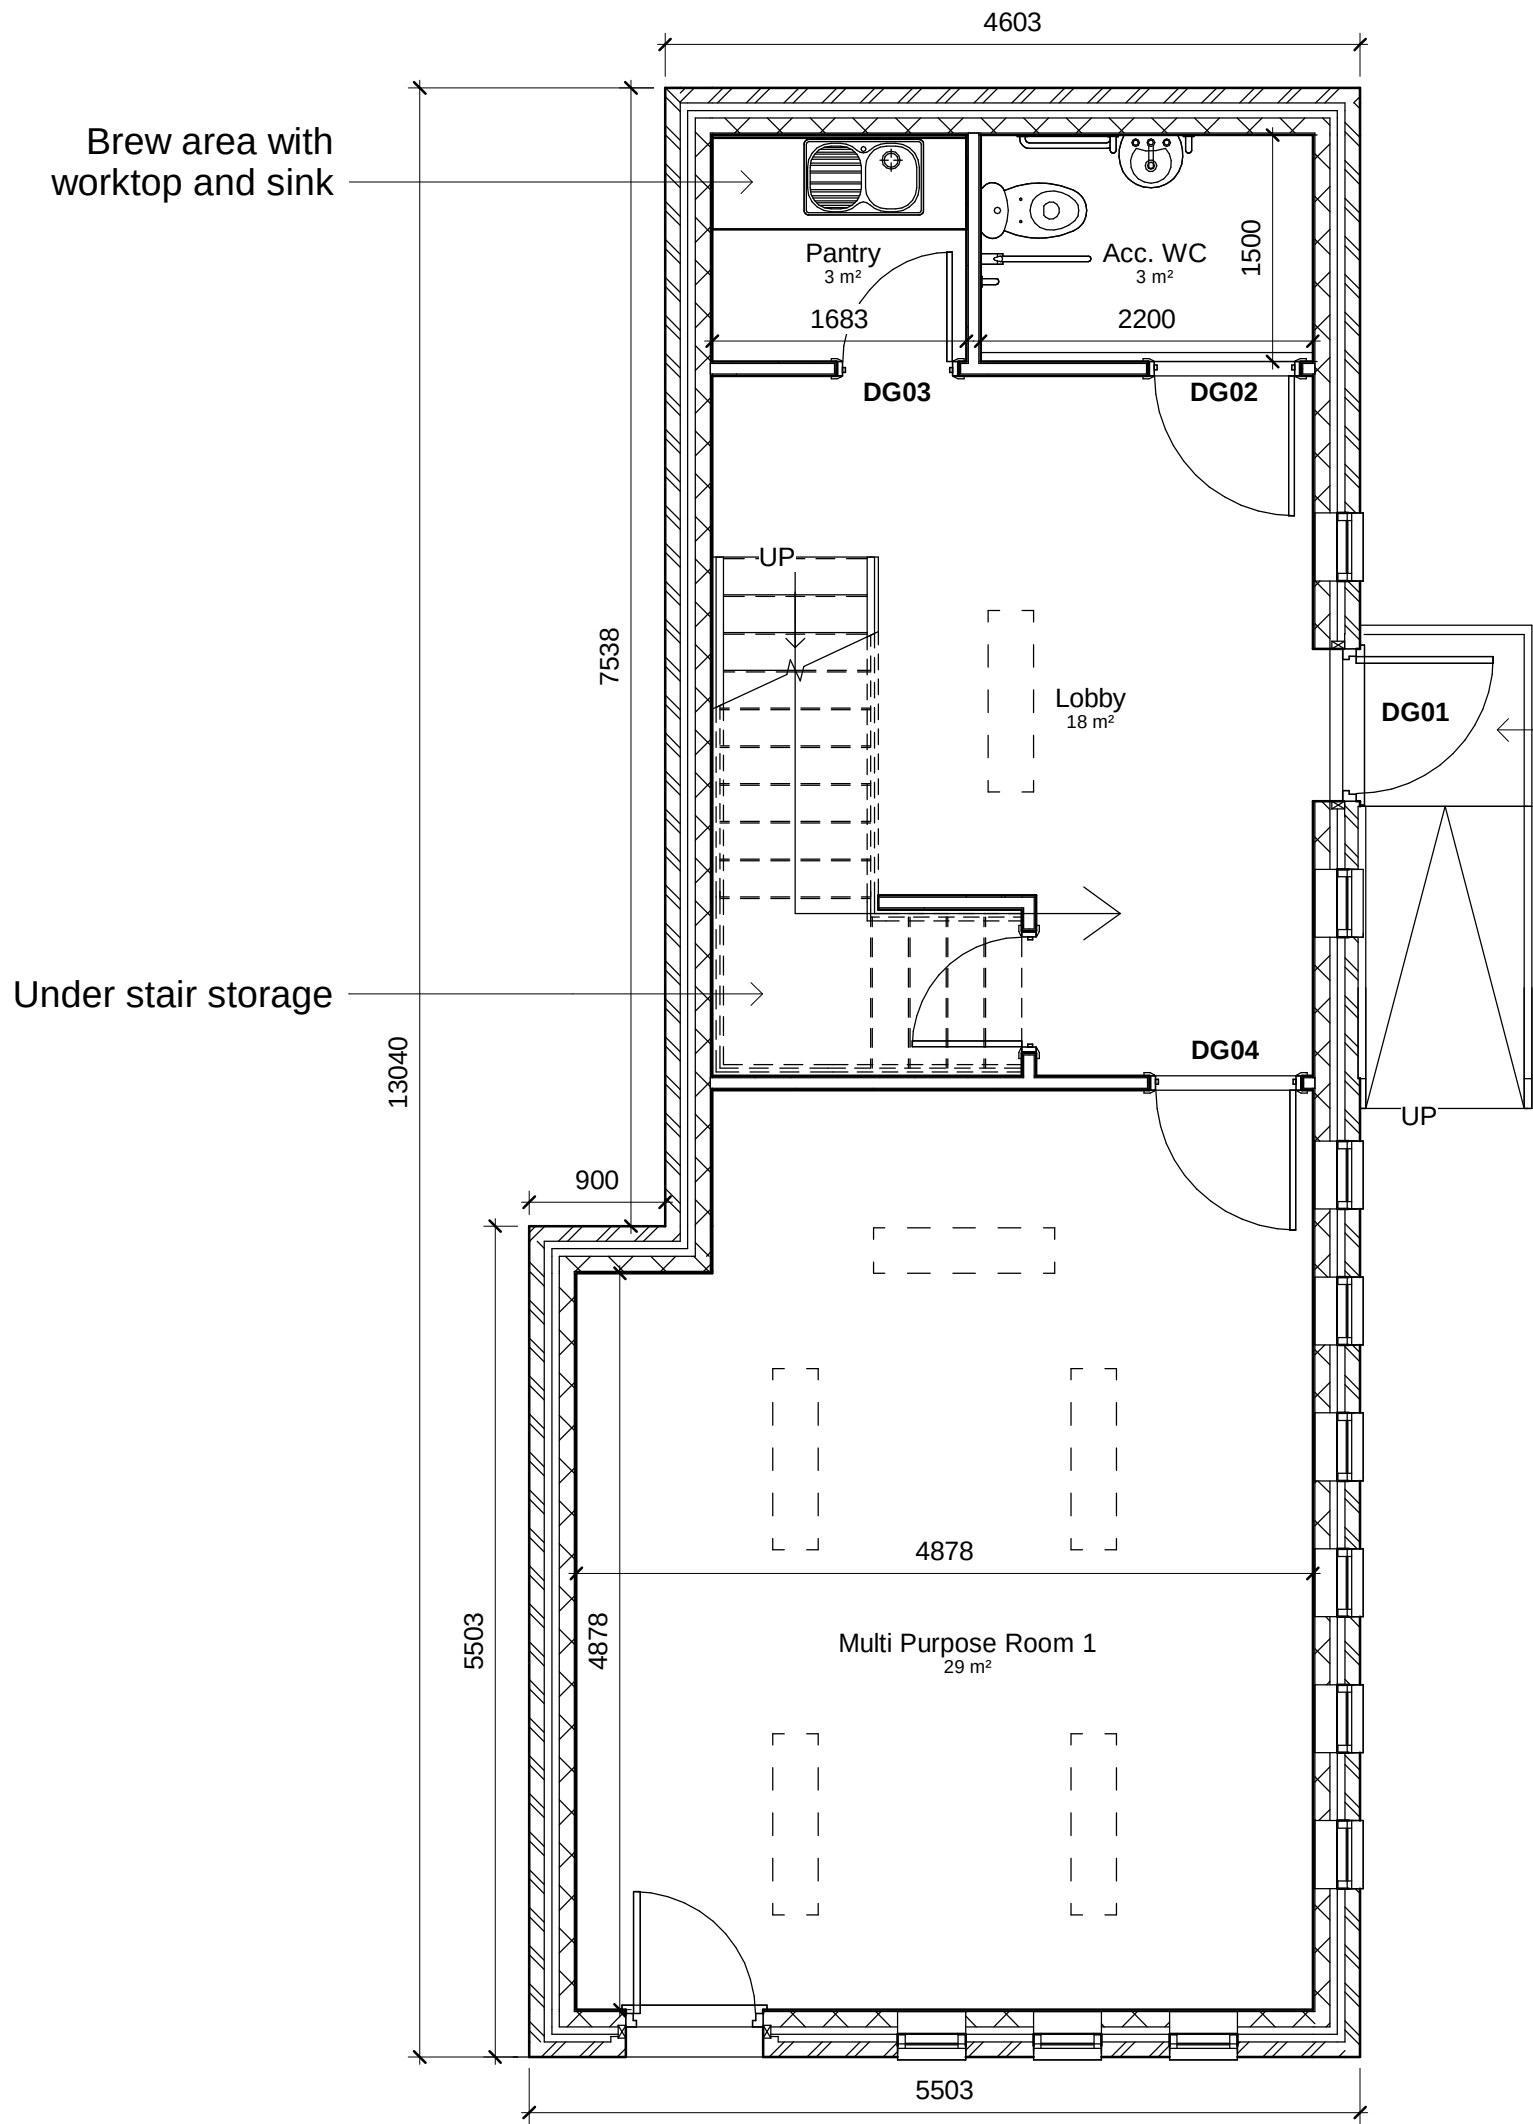

Proposed Annexe Ground Floor Plan
Scale 1 : 50

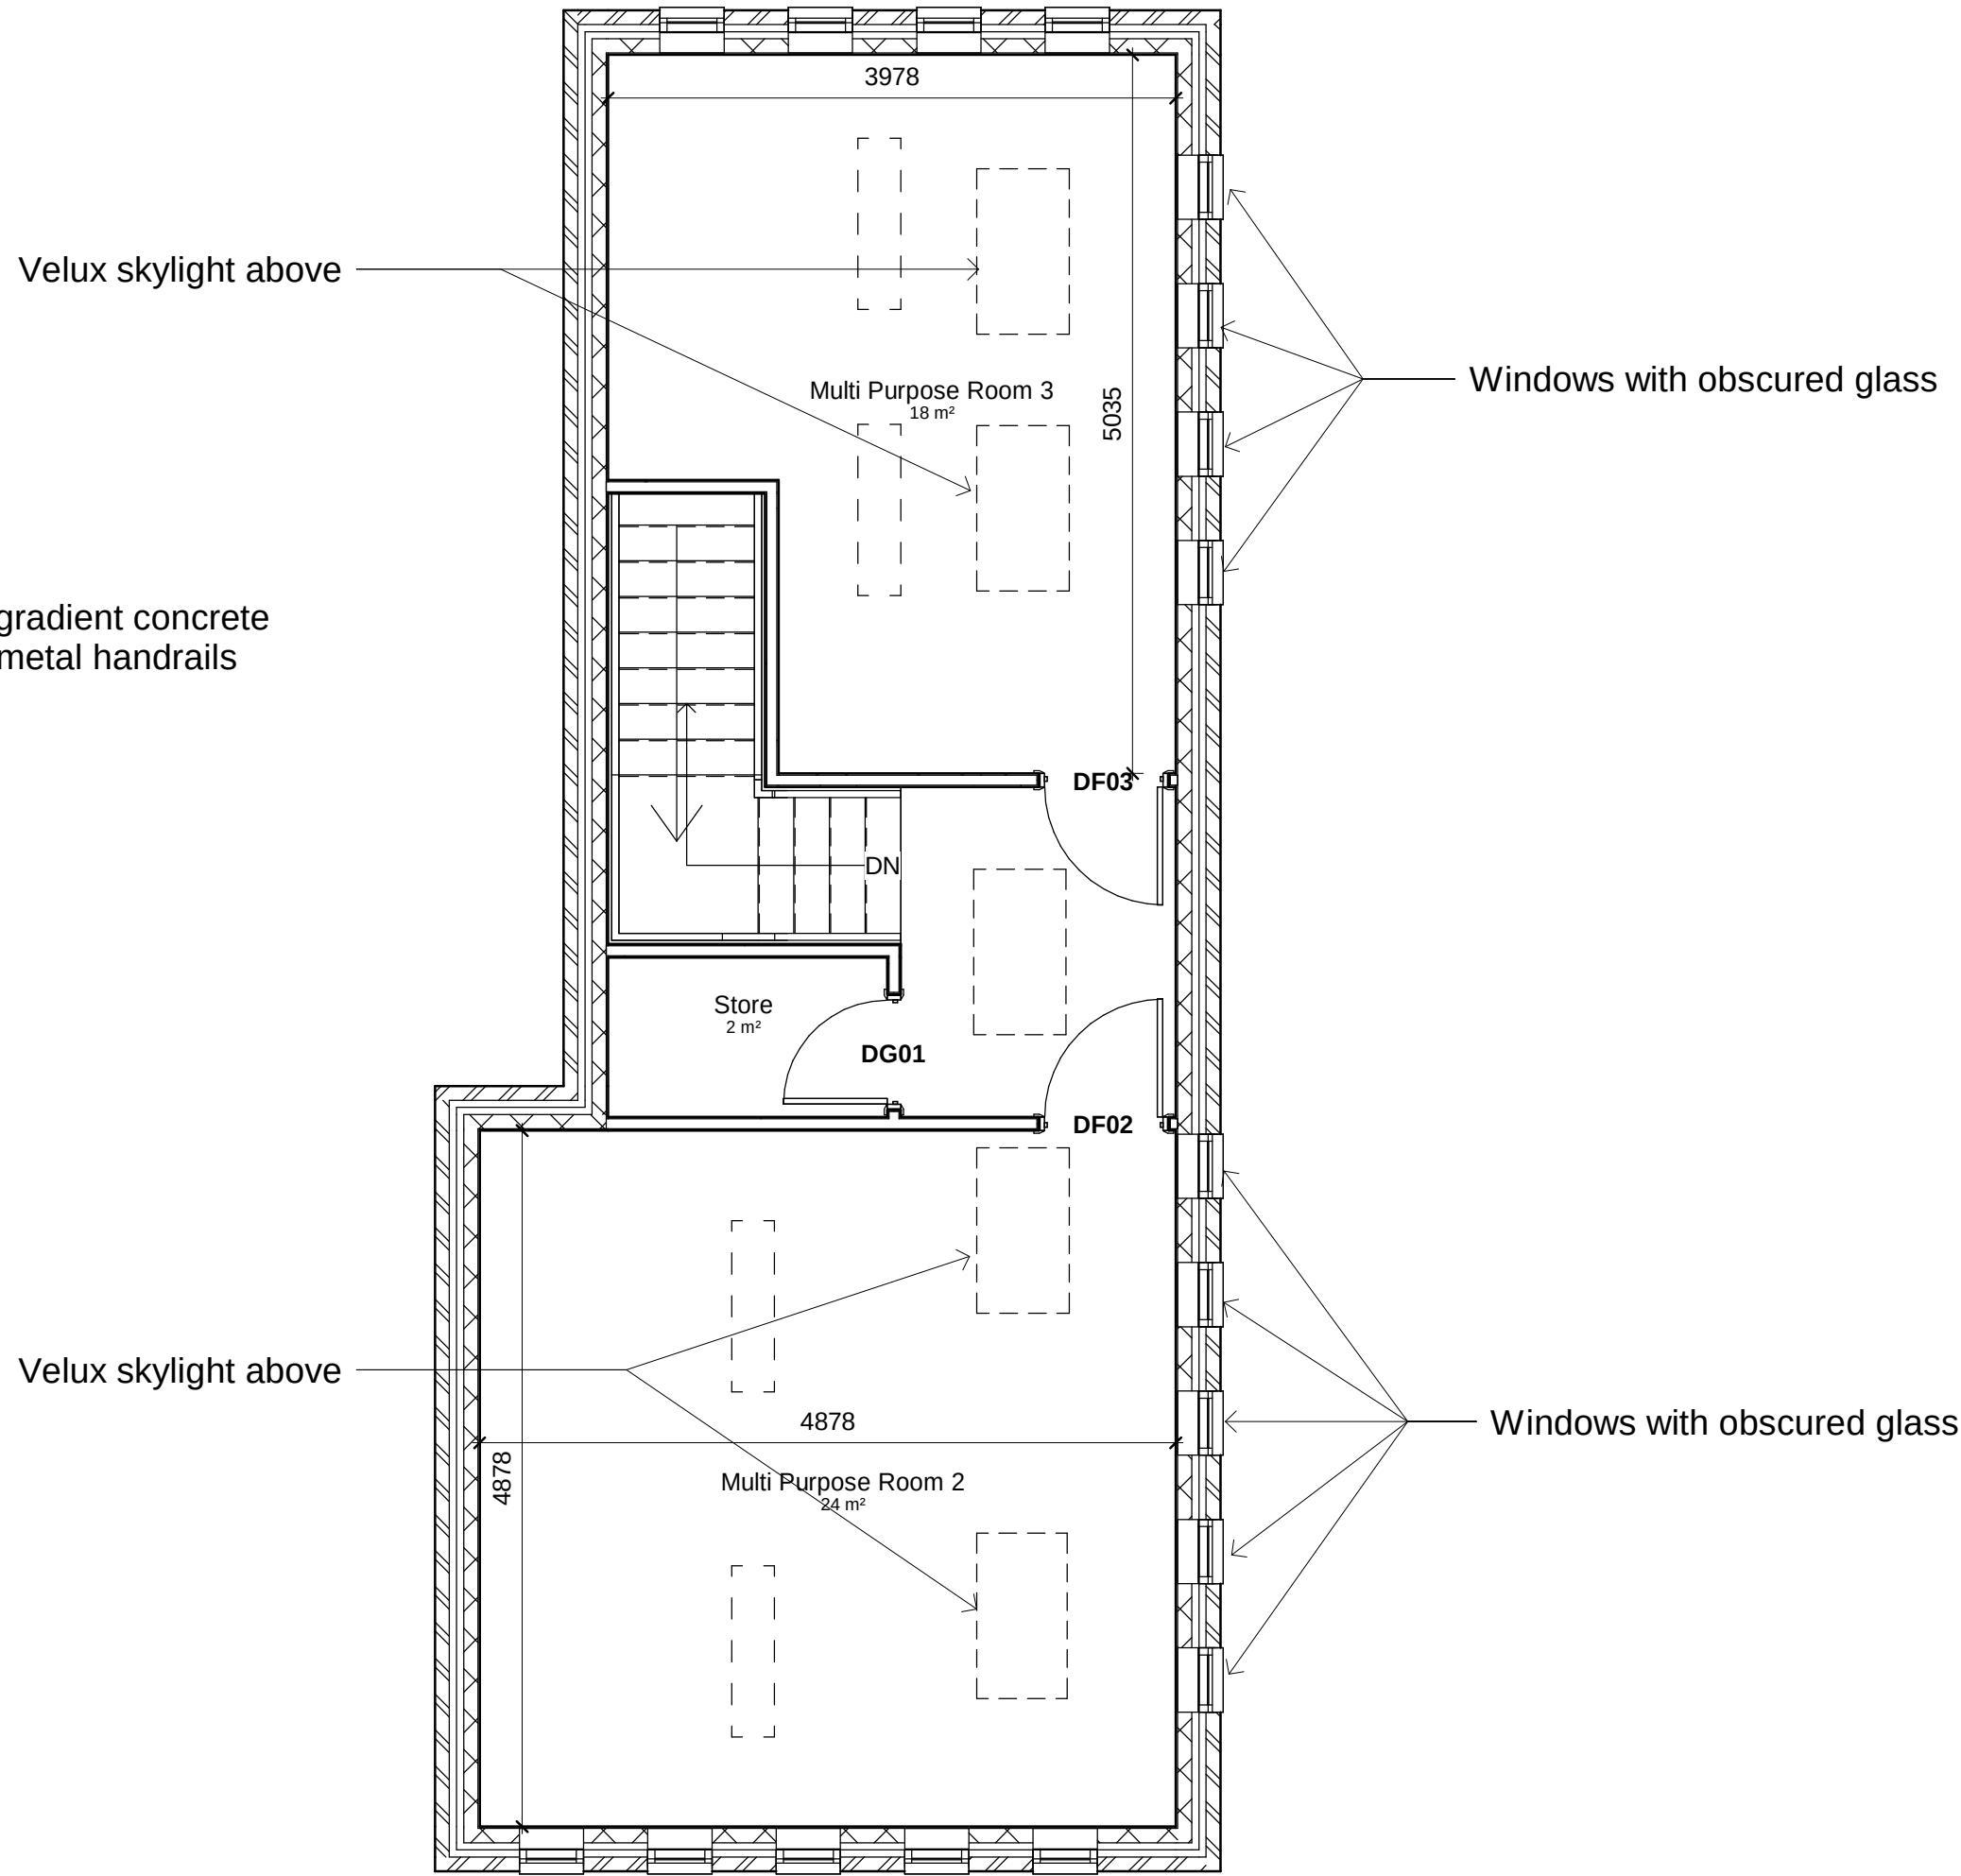

Proposed Annexe First Floor Plan
Scale 1 : 50

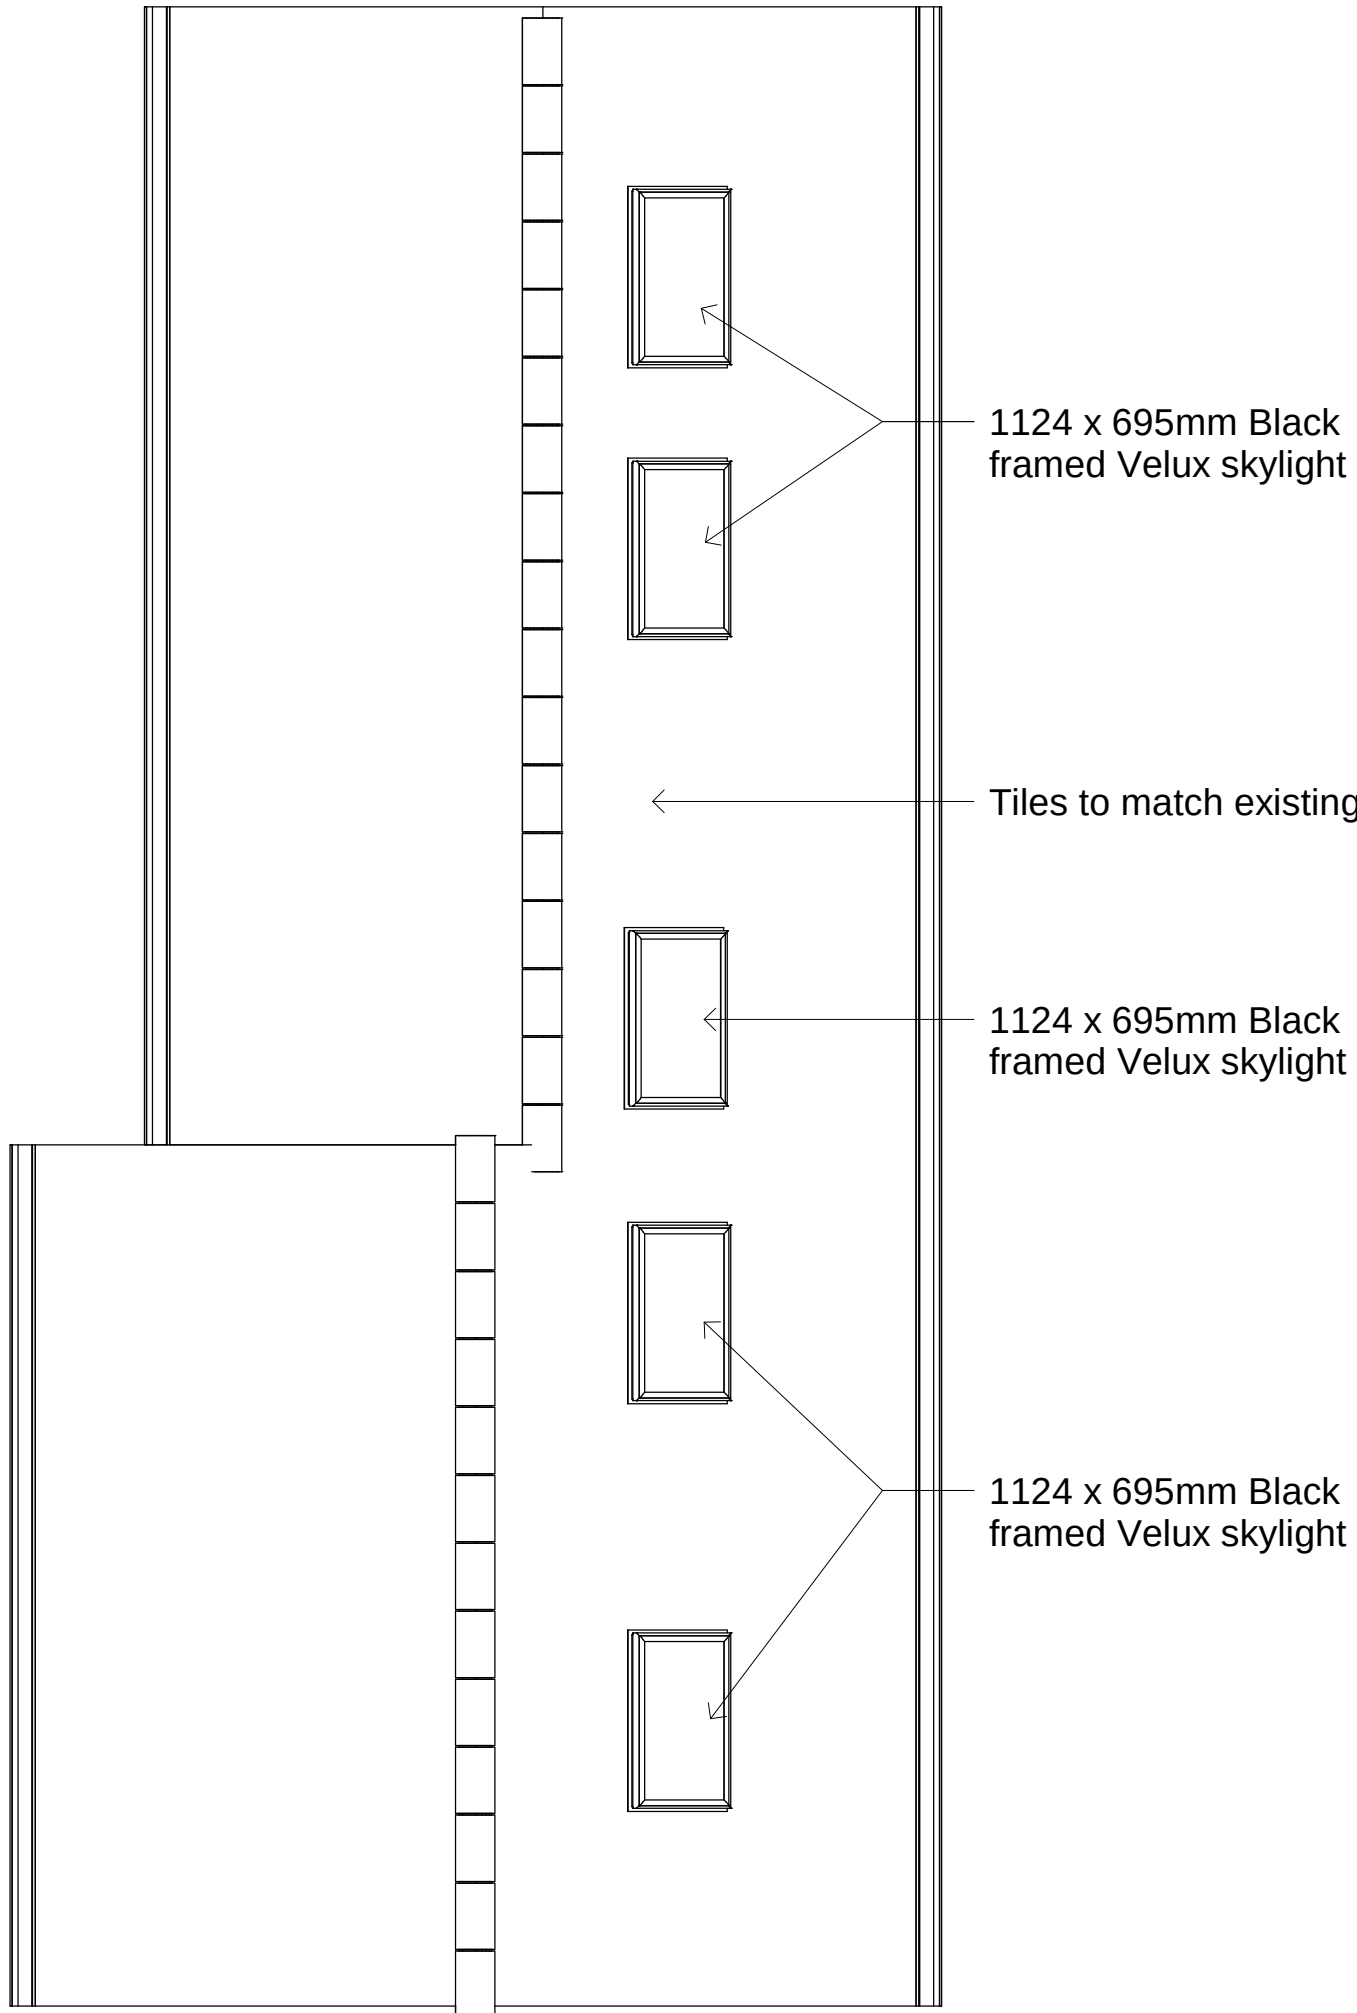

Proposed Annexe Roof Plan
Scale 1 : 50

Rev	Description	By	Chk	Date
Project:	Manchester Chinese Christian Church 100 Yarburgh Street, Manchester, M16 7EH			
Title:	Proposed Annexe Floor Plans			
Client:	MCCC			
Drawn By:	AL	Checked By:	BJ	on 13/11/20
Original Size:	A1	Project Number:	22042	
Drawing Number:	B1-XX-DR-A-2020			REV

