


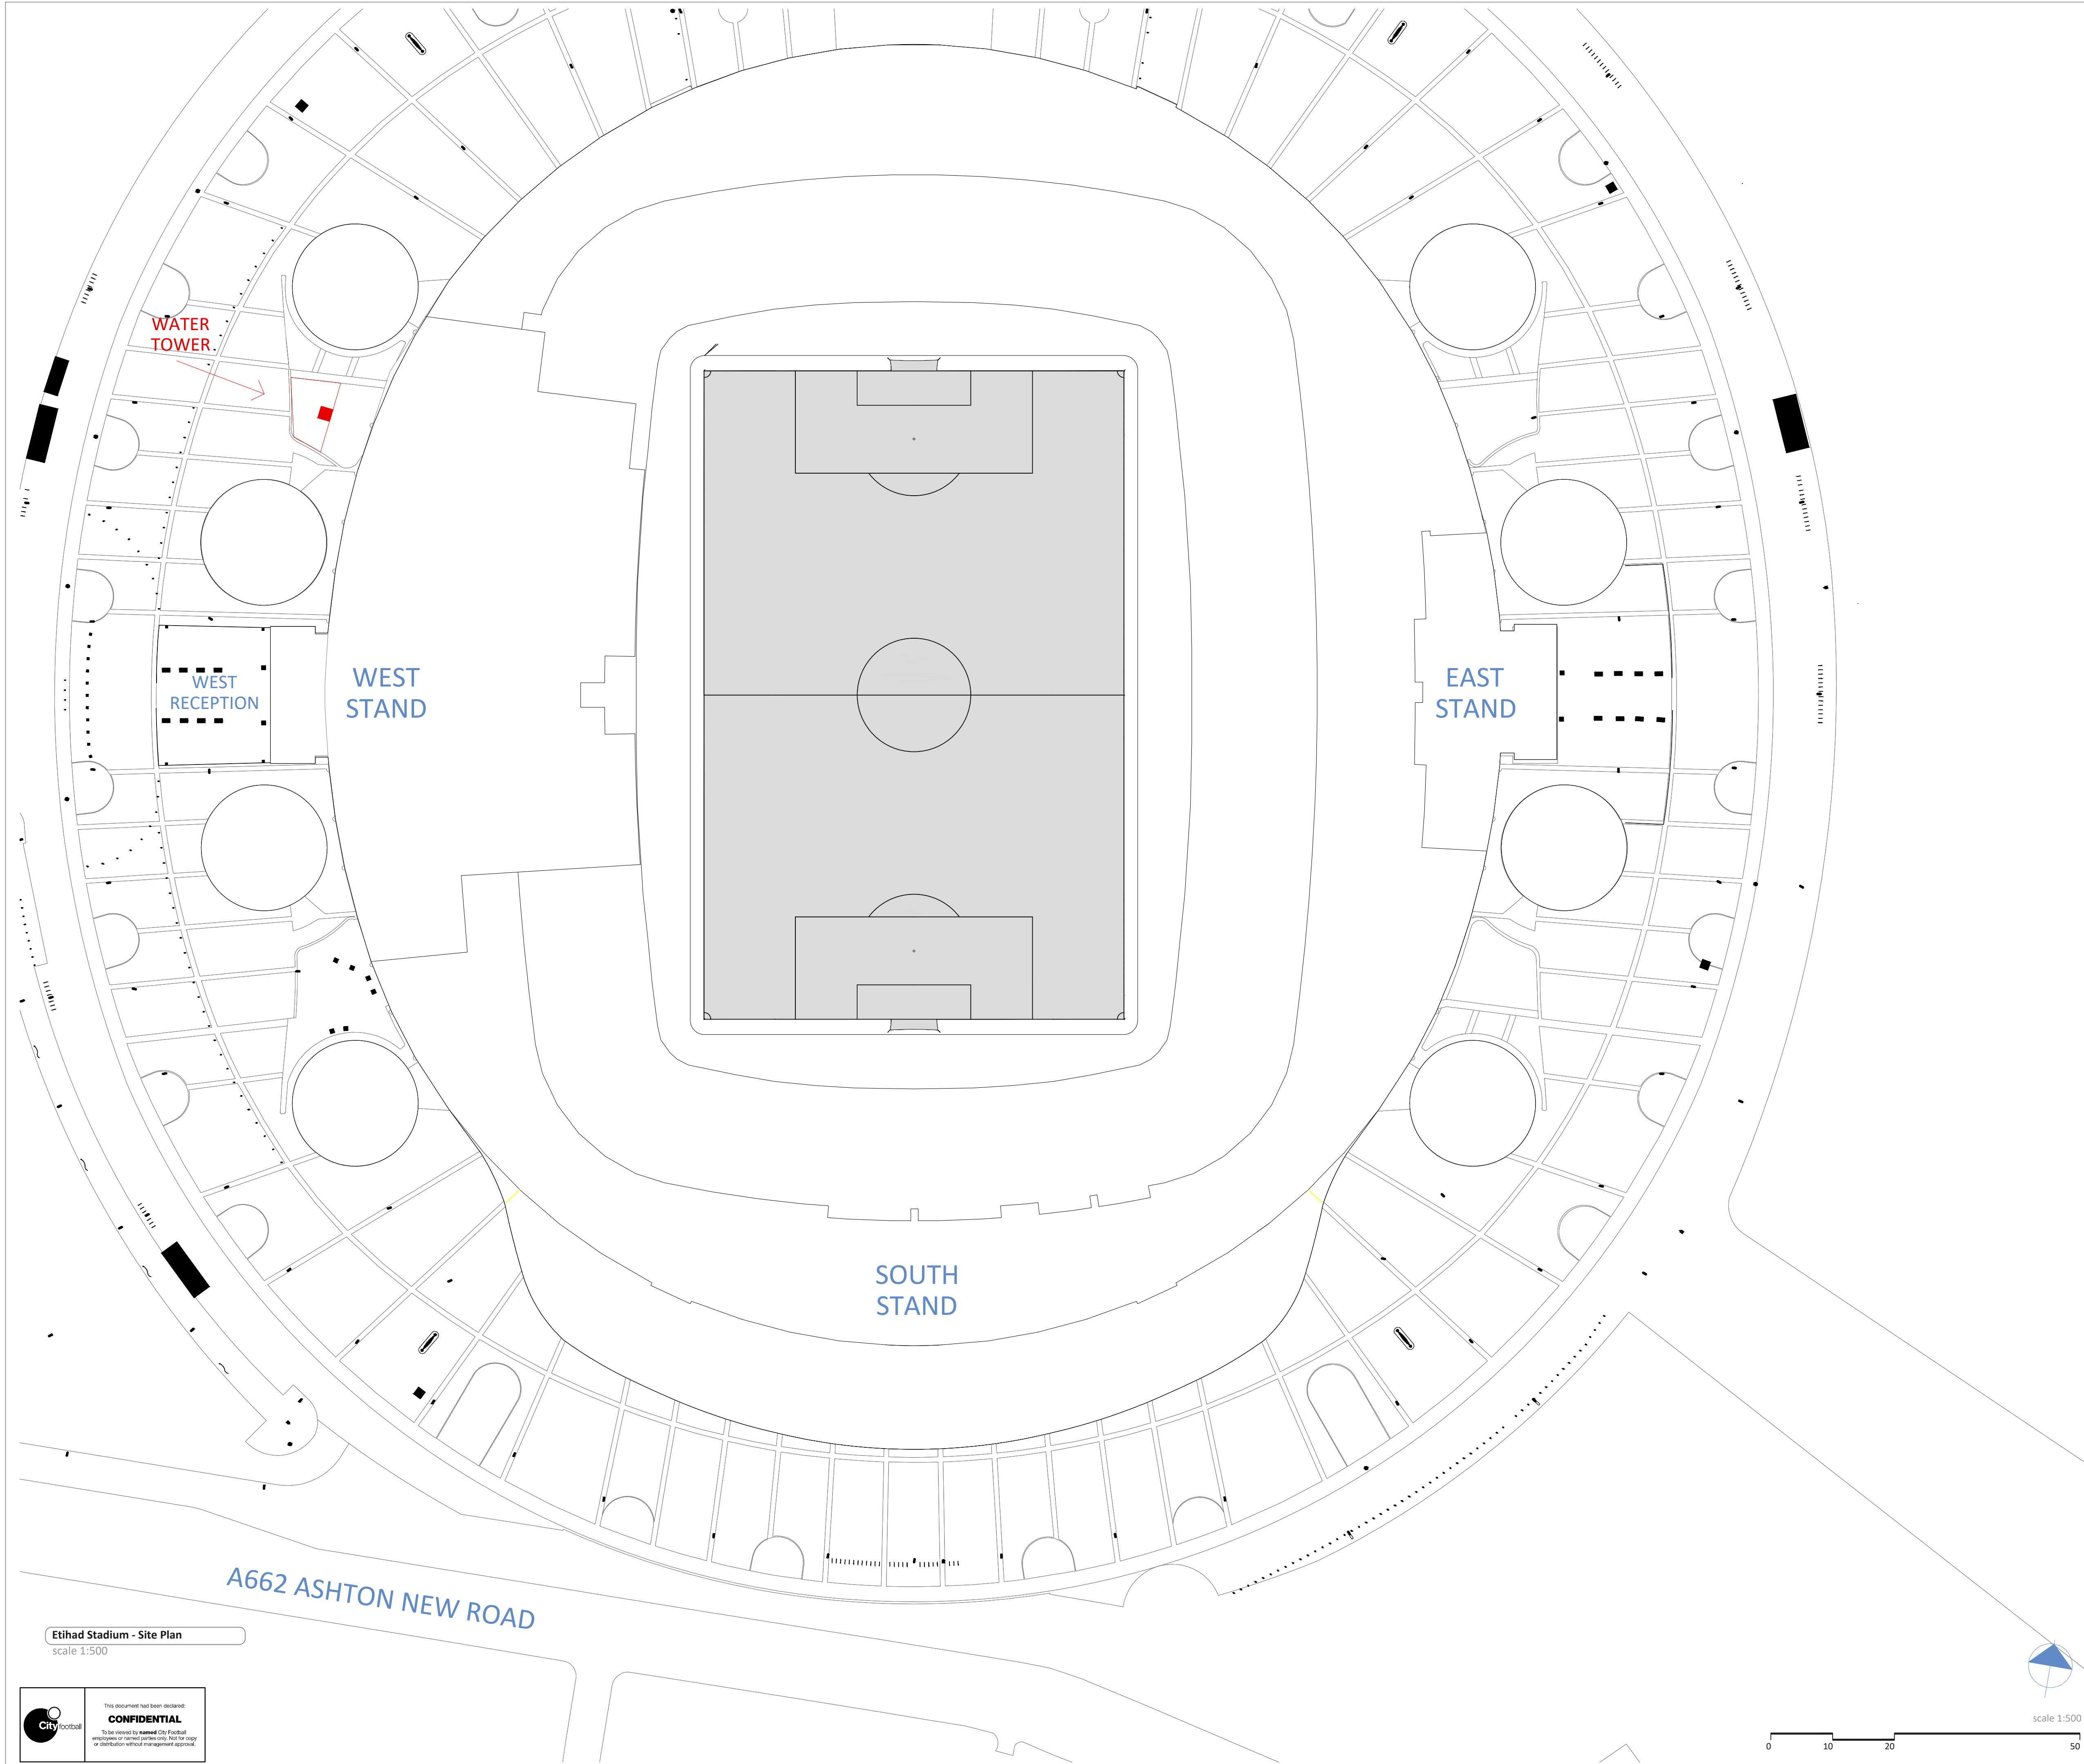

Etihad Stadium - Site Plan

scale 1:500



This document has been declared

CONFIDENTIAL

To be viewed by named City Football employees or named parties only. Not for copy or distribution without management approval.



Project Title

**WATER TOWER
AT THE ETIHAD**

Drawing Title

SITE PLAN
Water tower Location

Drawn by:	Initials ID	Date 26/10/2021
Approved by:		

Scale 1:1000 @ A1	Revision 00
----------------------	----------------

Drawing code WT	Drawing number 02
---------------------------	-----------------------------