

○ BOWKER SADLER PARTNERSHIP LIMITED
■ THIS DRAWING IS THE SUBJECT OF COPYRIGHT WHICH VESTS IN BOWKER SADLER PARTNERSHIP LIMITED. IT IS AN INFRINGEMENT OF COPYRIGHT TO REPRODUCE THIS DRAWING, BY WHATEVER MEANS, INCLUDING ELECTRONIC, WITHOUT THE EXPRESS WRITTEN CONSENT OF BOWKER SADLER PARTNERSHIP LIMITED WHICH RESERVES ALL ITS RIGHTS
BOWKER SADLER PARTNERSHIP LIMITED ASSERTS ITS RIGHTS TO BE IDENTIFIED AS THE AUTHOR OF THIS DESIGN
■ DRAWING NOT TO BE SCALED.
■ REPORT ERRORS & OMISSIONS TO ARCHITECT.
■ CHECK ALL DIMENSIONS ON SITE
■ DRAWING TO BE READ IN CONJUNCTION WITH THE HEALTH AND SAFETY PLAN AND ALL RELEVANT RISK ASSESSMENTS

Gyproc Thermaline PIR insulation board with 100mm Isover roof insulation to rafters of existing roof plaster skim and paint finish white BS00E55 refer to Architects drawing 18-094-6501 for details

Suspended Plasterboard ceiling on British Gypsum MF sytem with plaster and paint finish white BS00E55

Existing soffits cleaned and any damage made good before painted matt white emulsion BS00E55


L1
Thorlux Hi-Bar suspended continuous strip LED fitting with uplight option. Aluminium body finished black RAL 9005

L3
Thorlux G3 PRO recessed downlighter die cast ring finished white with black anti glare outer reflector.

L4
Thorlux Oviv surface mounted indirect LED fitting

L5
Whitecroft lighting Mirage LED surface height 200mm. Aluminium body finished black RAL 9005

L6
Thorlux Hi-Bar surface continuous strip LED fitting. Aluminium body finished black RAL 9005

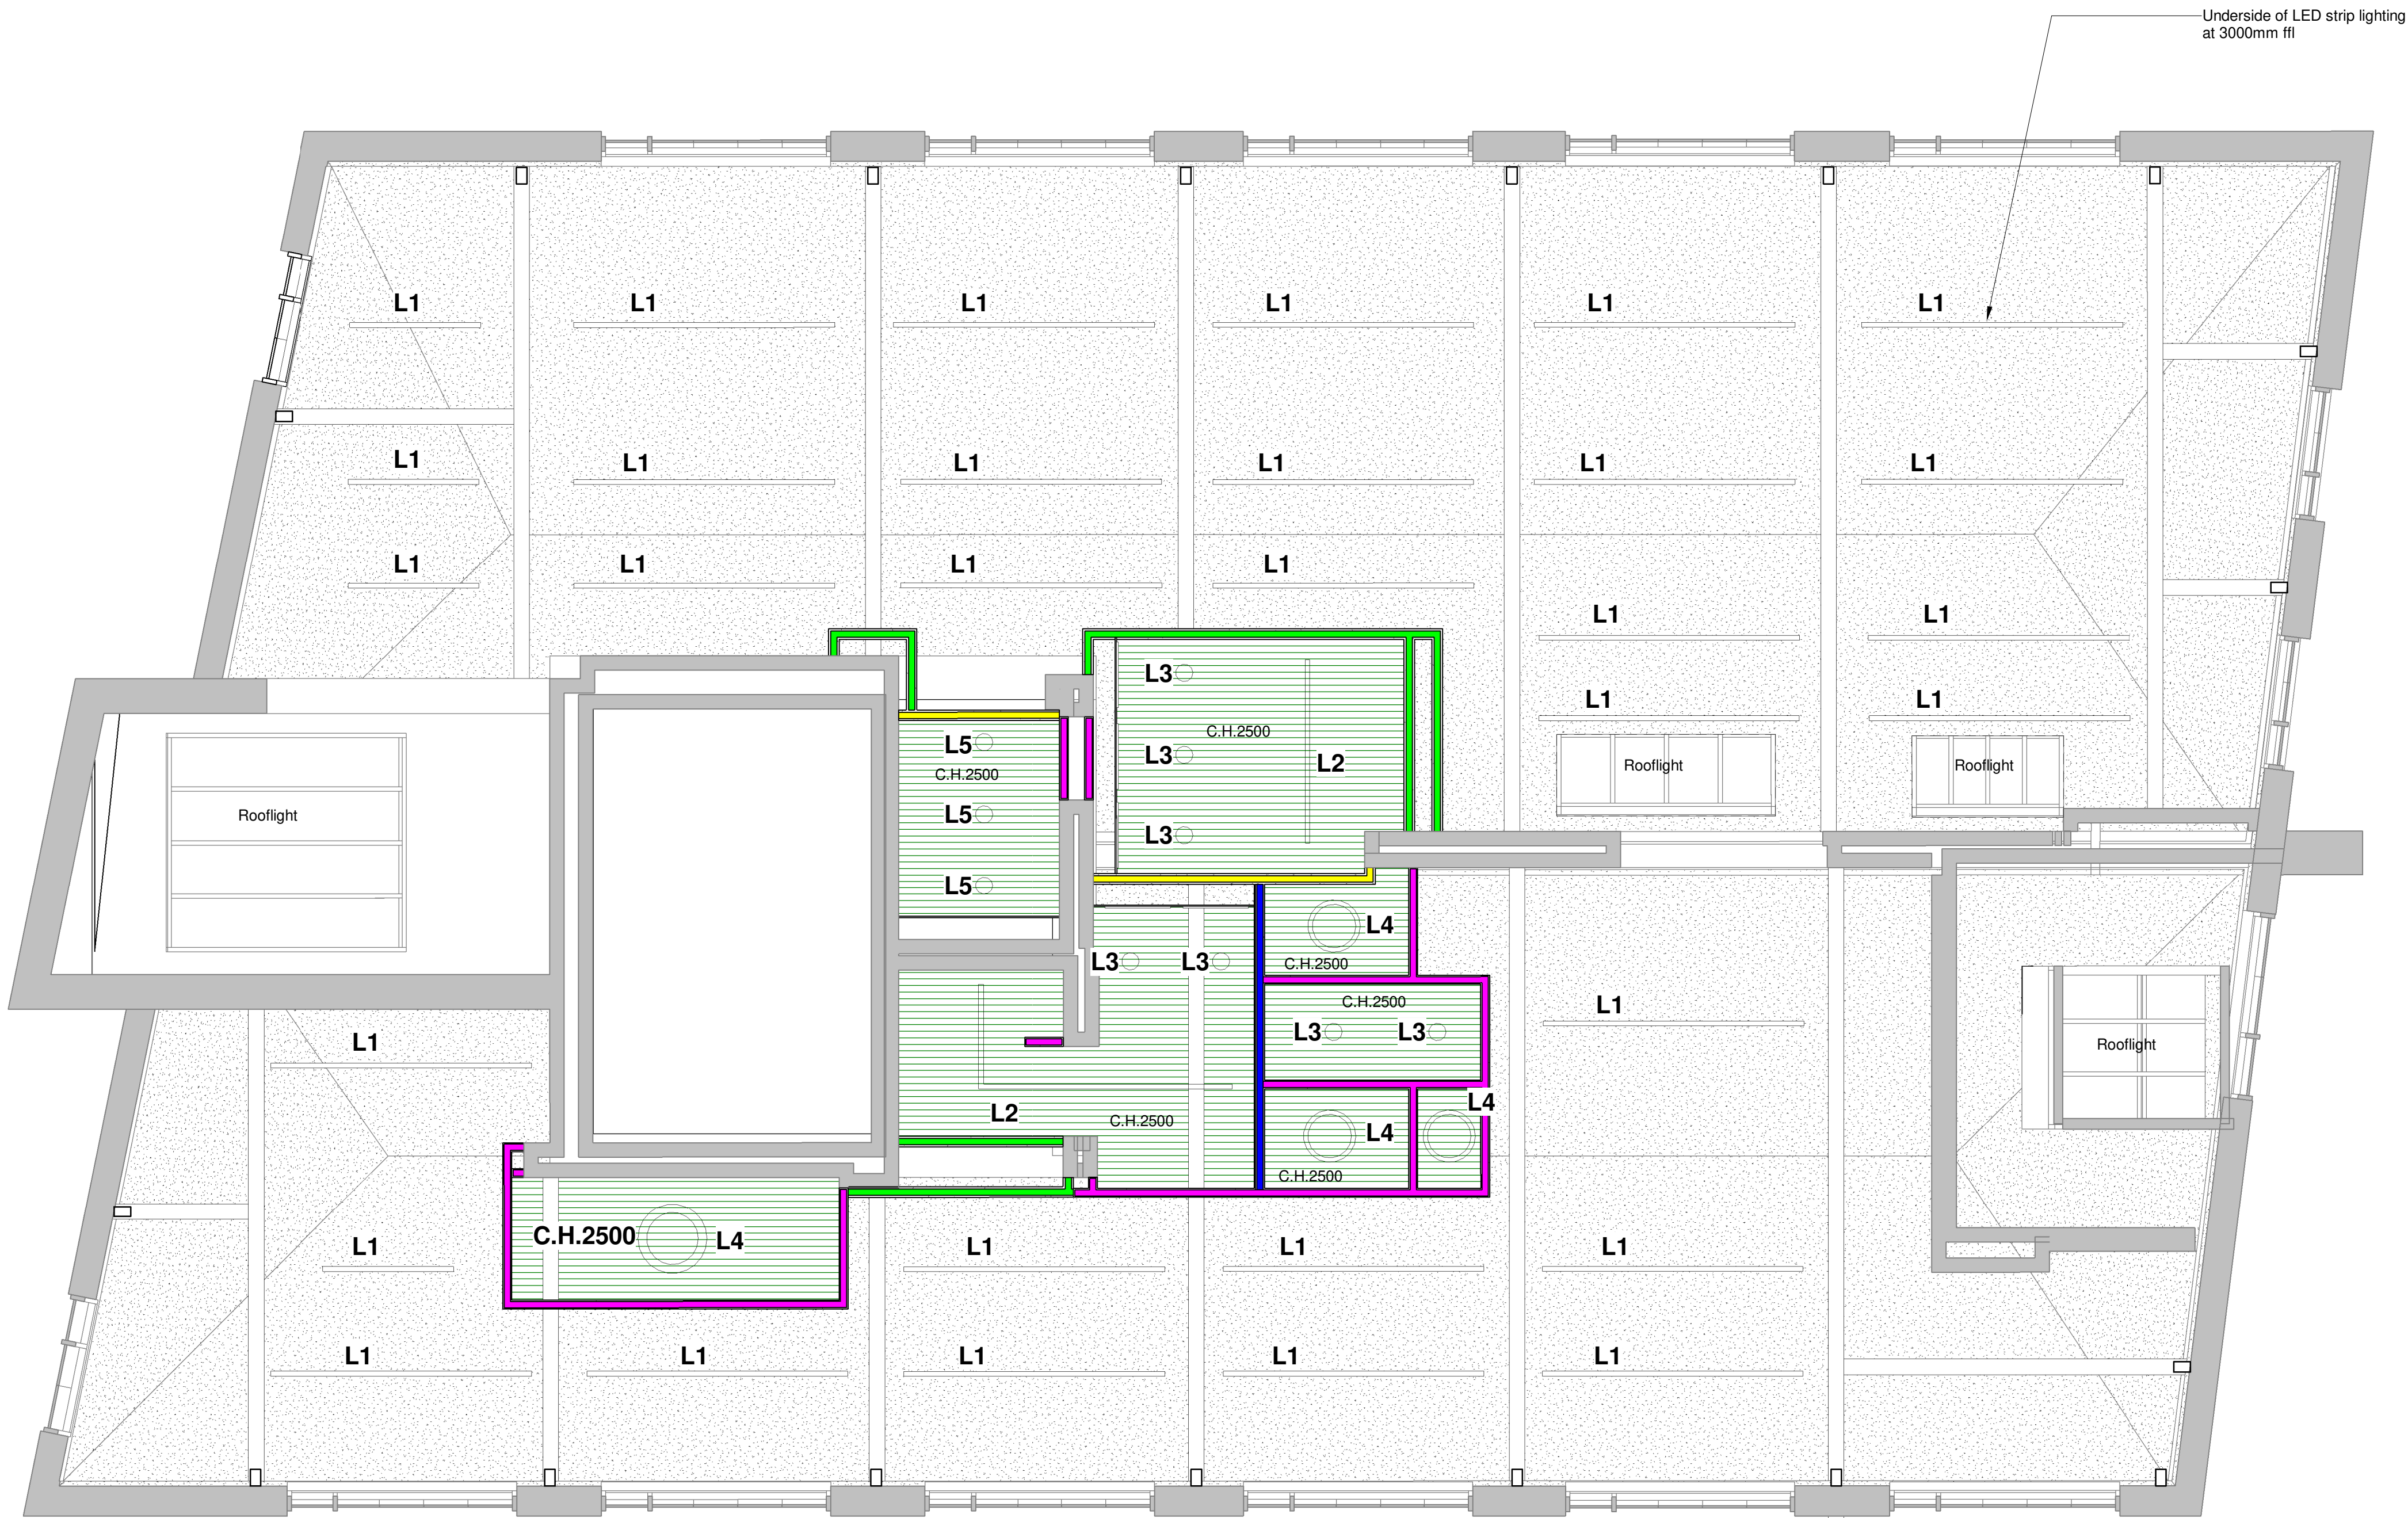

A 01.09.21 AW Ceiling and lighting layout updated to suit new core layout. DL

REV.	DATE	DRN.	CHKD.
------	------	------	-------

PROJECT
Princess House, 105-107
Princess Street Manchester

CLIENT
Lapwine Ltd

DRAWING
Fourth Floor
Reflected Ceiling Layout

SCALE	SHEET SIZE	DRAWN	CHECKED	DATE
1 : 50	@ A1	KB	DAL	24/07/19

BOWKER SADLER ARCHITECTURE
A: Hatherlow House, Hatherlow, Romiley, Stockport SK6 3DY
T: 0161 406 7333
E: office@bowker-sadler.co.uk
W: www.bowker-sadler.co.uk

JOB No	DRAWING No	REVISION
18-094	2075	A
STATUS	PLANNING	

Fourth Floor - Reflected Ceiling Layout
1 : 50

