


Exposed concrete soffits to bin store, bike store and plant areas to have concrete sealer ref: Watco water based concrete sealer


Dashed line indicating Delta light anodised edge profile and LEDflex light between plasterboard ceiling and wall ref: Rendez-vous

Existing ground and lower ground floor night club area not included as part of this application


Upper Ground Floor - Reflected Ceiling Layout
1 : 50

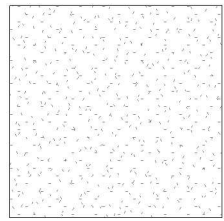


Plasterboard fireline boards to underside of existing floor joists plaster and paint finish white BS00E55 refer to Architects drawing 18-094-6002 for details

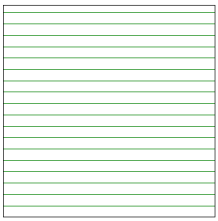

 Suspended Plasterboard ceiling on British Gypsum MF sytem with plaster and paint finish white BS00E55



Existing soffits cleaned and any damage made good finished painted matt white emulsion BS00E55

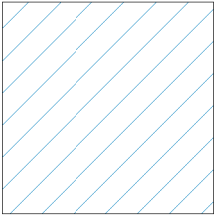

Suspended moisture resistant plasterboard ceiling on British Gypsum MF sytem with plaster and paint finish white BS00E55 hardwearing acrylic eggshell



L1 Thorlux Hi-Bar slimline suspended continuous strip LED fitting with uplight option. Aluminium body finished black RAL 9005




L2 Thorlux Hi-Bar recessed continuous strip LED fitting. Aluminium body finished White RAL9016



L3 Thorlux G3 PRO recessed downlighter die cast ring finished white with black anti glare outer reflector.



L4 Thorlux Ovox surface mounted indirect LED fitting

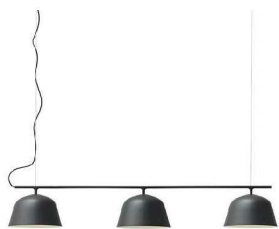

L6 Muuto ambit rail lamp feature pendant lamp finished black and suspended over the reception desk



L7 Thorlux 50mm dia. LED downlighter IP65 suitable for shower rooms finished white



 
 
L8 LED linear anti corrosive Thoroproof IP65 light fitting



L10 Buzzispace Buzzijet medium pendant light fitting upholstered in Kvadrat memory 2 range colour tbc

L9 Ceiling mounted LED light strip in aluminium profile to wash existing brickwork walls

L11 LED light strip recessed in aluminium channel so flush with bronze cladding, to walls and soffit



○ BOWKER SADLER PARTNERSHIP LIMITED
■ THIS DRAWING IS THE SUBJECT OF COPYRIGHT WHICH VESTS IN BOWKER SADLER PARTNERSHIP LIMITED. IT IS AN INFRINGEMENT OF COPYRIGHT TO REPRODUCE THIS DRAWING, BY WHATEVER MEANS, INCLUDING ELECTRONIC, WITHOUT THE EXPRESS WRITTEN CONSENT OF BOWKER SADLER PARTNERSHIP LIMITED WHICH RESERVES ALL ITS RIGHTS
BOWKER SADLER PARTNERSHIP LIMITED ASSERTS ITS RIGHTS TO BE IDENTIFIED AS THE AUTHOR OF THIS DESIGN
■ DRAWING NOT TO BE SCALED.
■ REPORT ERRORS & OMISSIONS TO ARCHITECT.
■ CHECK ALL DIMENSIONS ON SITE
■ DRAWING TO BE READ IN CONJUNCTION WITH THE HEALTH AND SAFETY PLAN AND ALL RELEVANT RISK ASSESSMENTS

B 31.08.21 AW Layout revised, DL
A 14.08.19 KB Revised lighting layout to reception area DL

REV. DATE DRN. CHKD.

PROJECT
Princess House, 105-107
Princess Street Manchester

CLIENT
Lapwine Ltd

DRAWING
Upper Ground Floor
Reflected Ceiling Layout

SCALE 1 : 50 SHEET SIZE @ A1 DRAWN KB CHECKED DAL DATE 24/7/19

BOWKER SADLER ARCHITECTURE
A: Hatherlow House, Hatherlow, Romiley, Stockport SK6 3DY
T: 0161 406 7333
E: office@bowker-sadler.co.uk
W: www.bowker-sadler.co.uk

JOB No 18-094 DRAWING No 2071 REVISION B
STATUS PLANNING