




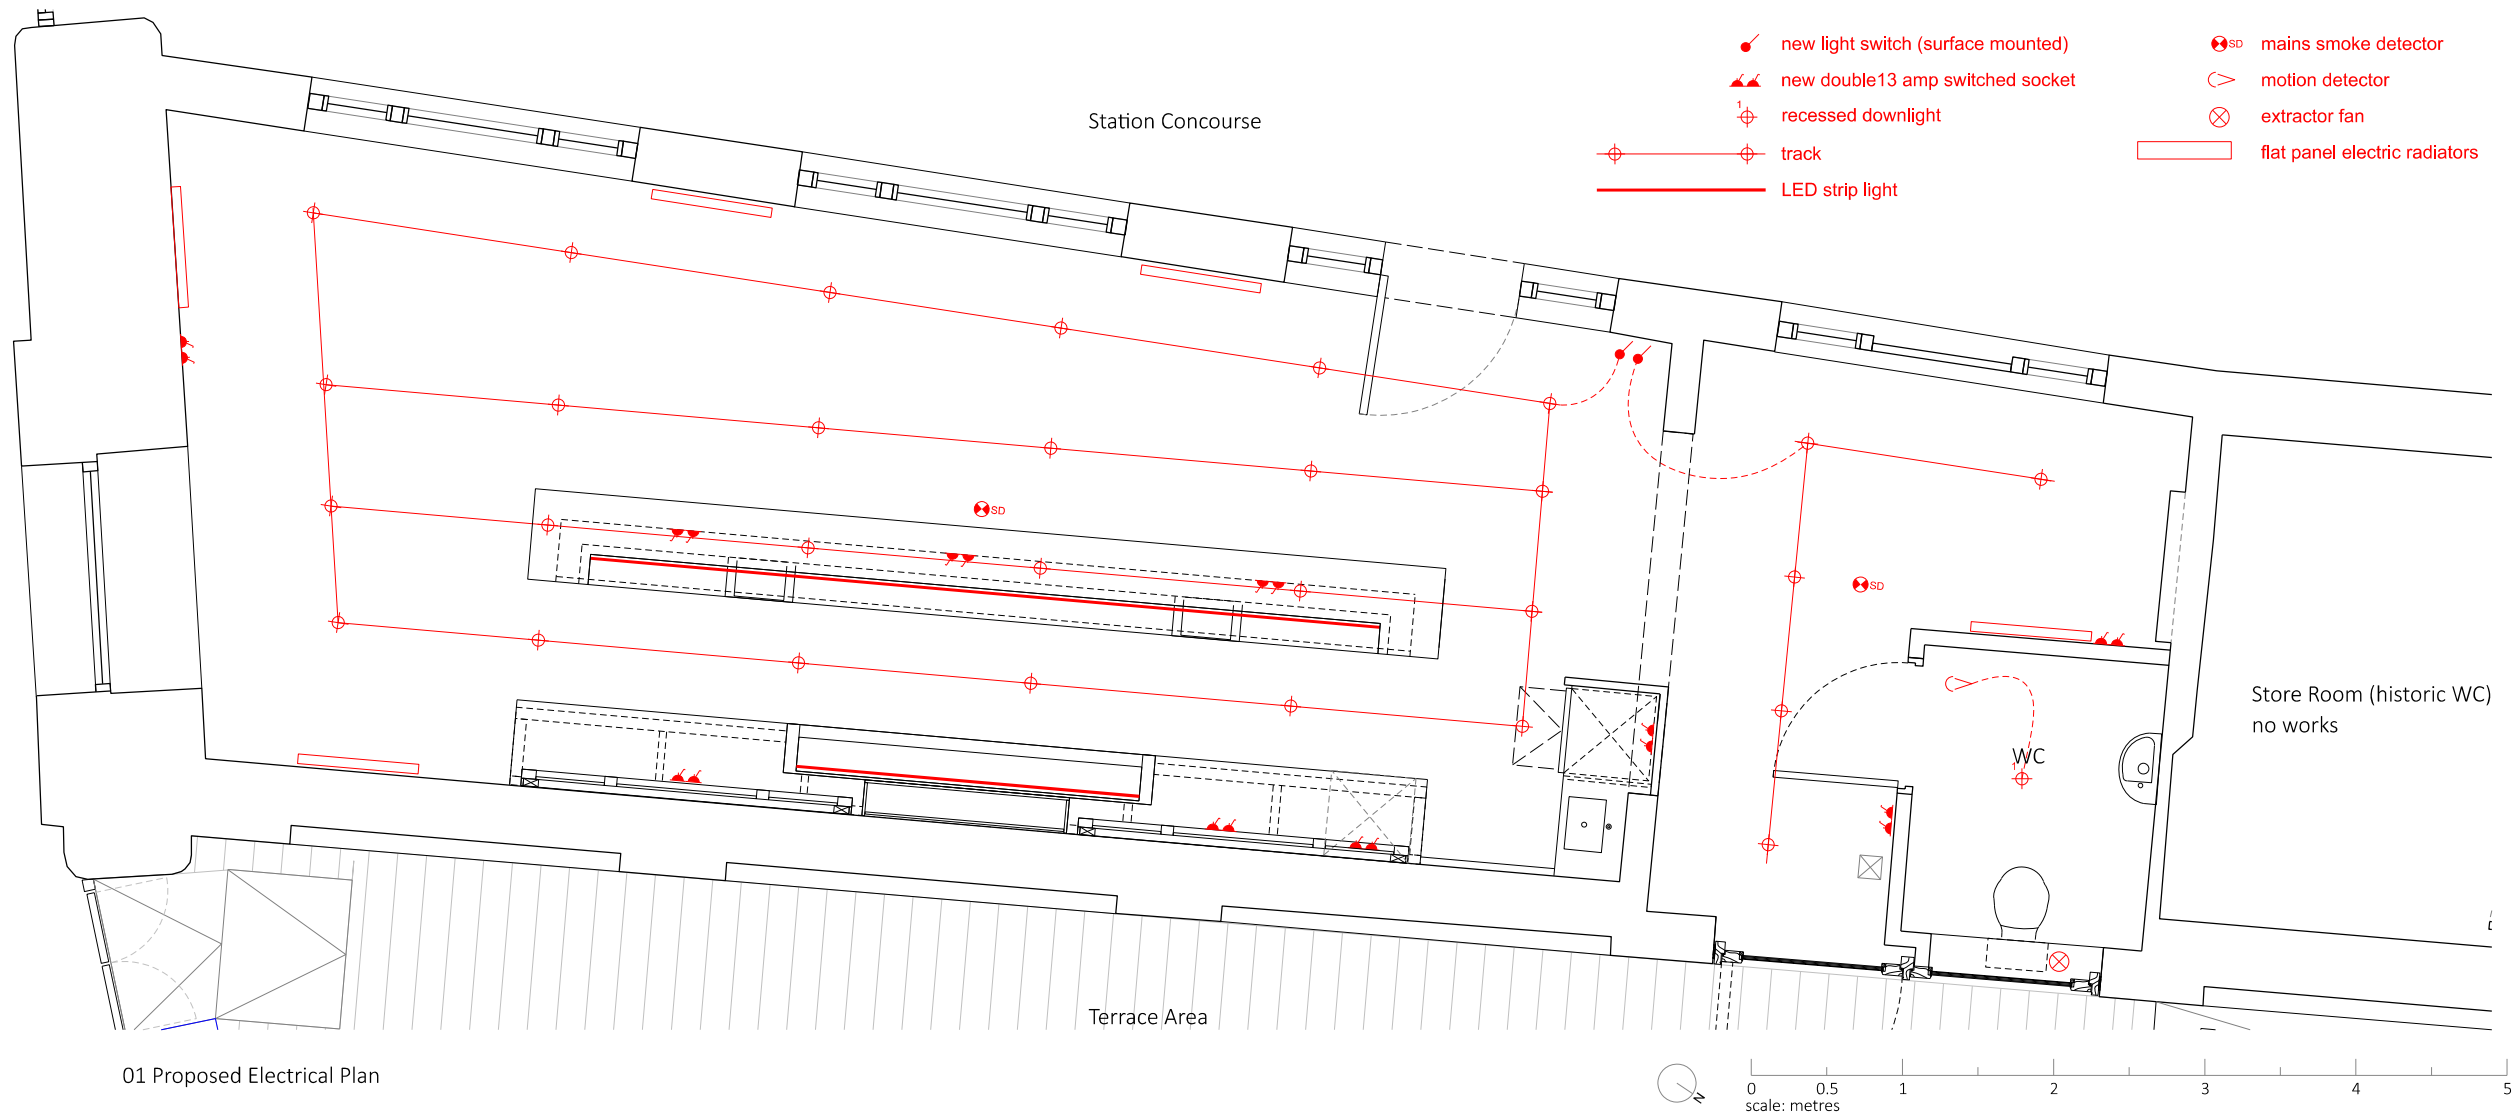


01 Proposed Electrical Plan

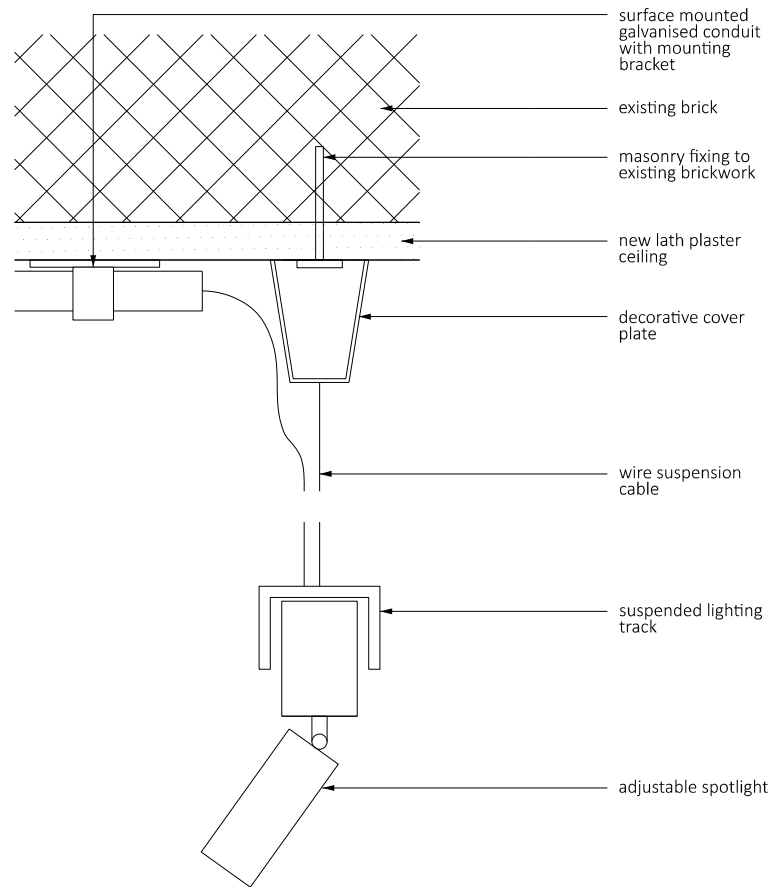

01 Proposed Lighting Track Detail - 1:5

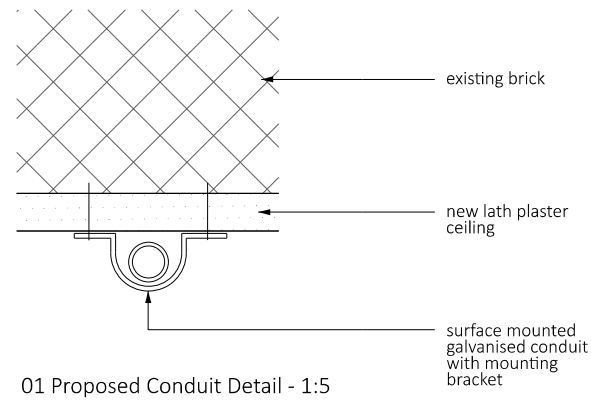

01 Proposed Conduit Detail - 1:5

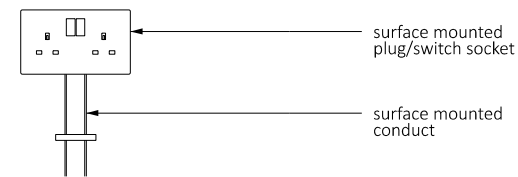

01 Proposed Socket Detail - 1:5

SAFETY, HEALTH AND ENVIRONMENTAL INFORMATION:	
IN ADDITION TO THE HAZARDS / RISKS NORMALLY ASSOCIATED WITH THE TYPES OF WORK DETAILED ON THIS DRAWING, NOTE THE FOLLOWING:	
Significant Residual Risks:	
Action to be Taken:	
Refer to Health and Safety Plan	

NOTES:

REV	DATE	DETAIL	DRN	CHK
-----	------	--------	-----	-----

PROJECT TITLE
Victoria Tap

DRAWING TITLE
Proposed Ground Floor Plan -
Electrical and Lighting

DATE 310821	SCALE 1:100	@A3
STATUS PLANNING	DRAWN AP	CHECKED DD

DRAWING NUMBER 071_PL41	REVISION -
----------------------------	---------------

BEASLEY DICKSON ARCHITECTS

Address
PROJECT EMAIL:
Info@beasleydickson.com

© BEASLEY DICKSON ARCHITECTS LTD 2014