


RED LION - SIGNS OVERVIEW




915 x 1220mm
Pictorial post made
from Green GRP with
gold vinyl letters
and graphic
Sign, 1 off

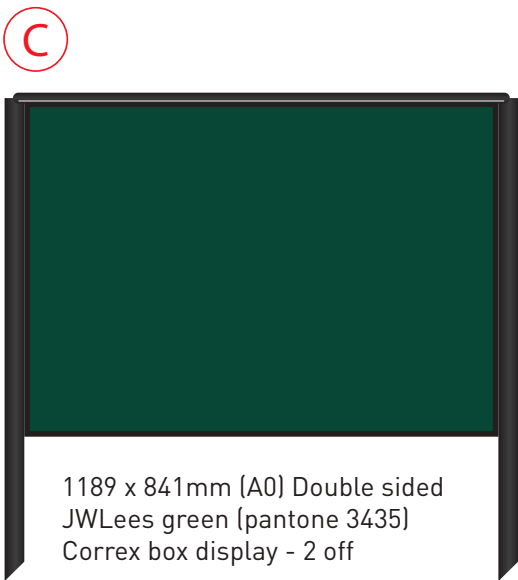


1189 x 841mm (A0) Double sided
JWLees green (pantone 3435)
Correx box display - 2 off



1500 x 750 mm Welcome Sign, Dbl sided
directional sign made from Green GRP with
gold vinyl letters, trough light (see nano light info page), 1 off

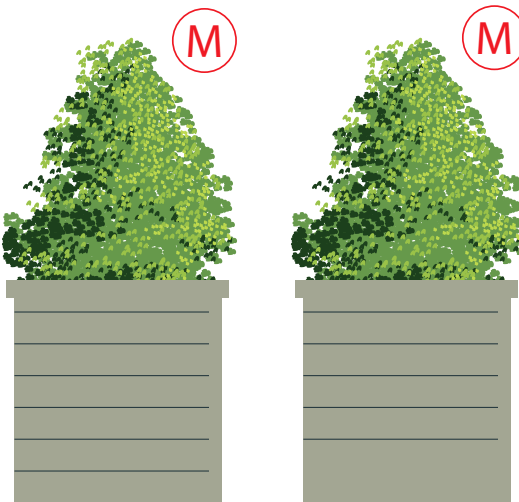

600 x 600 x 600 mm Wooden planter boxes
with painted in Dulux 10GY with green
vinyl applied to front to each side of
main entrance, 2 Off.

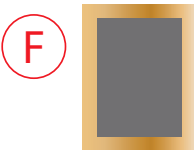

A3 Brass
menu box
with 50mm
depth and
frame
1 off



620 x 450mm
Disclaimer, 2 off



20 w LED Floods,
5 off



30 w LED Floods,
1 off



Brass lantern,
1 off



9 No. Lights
at lower level



180 x 124mm
Brass Plaque
1 off



Refurb Feature lantern
above main entrance, 1 off



JOB NAME
RED LION

JOB NO.
20200110

DATE
14th October 2021

DRAWN BY
Andrew Norse

SITE ADDRESS
Address

Tel: 01254 580166 or email: info@parkinsonsigns.com - 12 Chapel Street, Blackburn, Lancashire BB2 2EH

RED LION - SIGNS OVERVIEW



JOB NAME
RED LION

JOB NO.
20200110

DATE
14th October 2021

DRAWN BY
Andrew Norse

SITE ADDRESS
Address

Tel: 01254 580166 or email: info@parkinsonsigns.com - 12 Chapel Street, Blackburn, Lancashire BB2 2EH

Scale 1:20 at A3

SIDE PROJECTION



JOB NAME
RED LION

JOB NO.
20200110

DATE
14th October 2021

DRAWN BY
Andrew Norse

SITE ADDRESS
Address

Tel: 01254 580166 or email: info@parkinsonsigns.com - 12 Chapel Street, Blackburn, Lancashire BB2 2EH

RED LION - SIGNS OVERVIEW

N EAST ELEVATION - Ground to base of sign: 2565mm



JOB NAME
RED LION

JOB NO.
20200110

DATE
14th October 2021


DRAWN BY
Andrew Norse

SITE ADDRESS
Address

Tel: 01254 580166 or email: info@parkinsonsigns.com - 12 Chapel Street, Blackburn, Lancashire BB2 2EH

Scale 1:20 at A3

SIDE PROJECTION

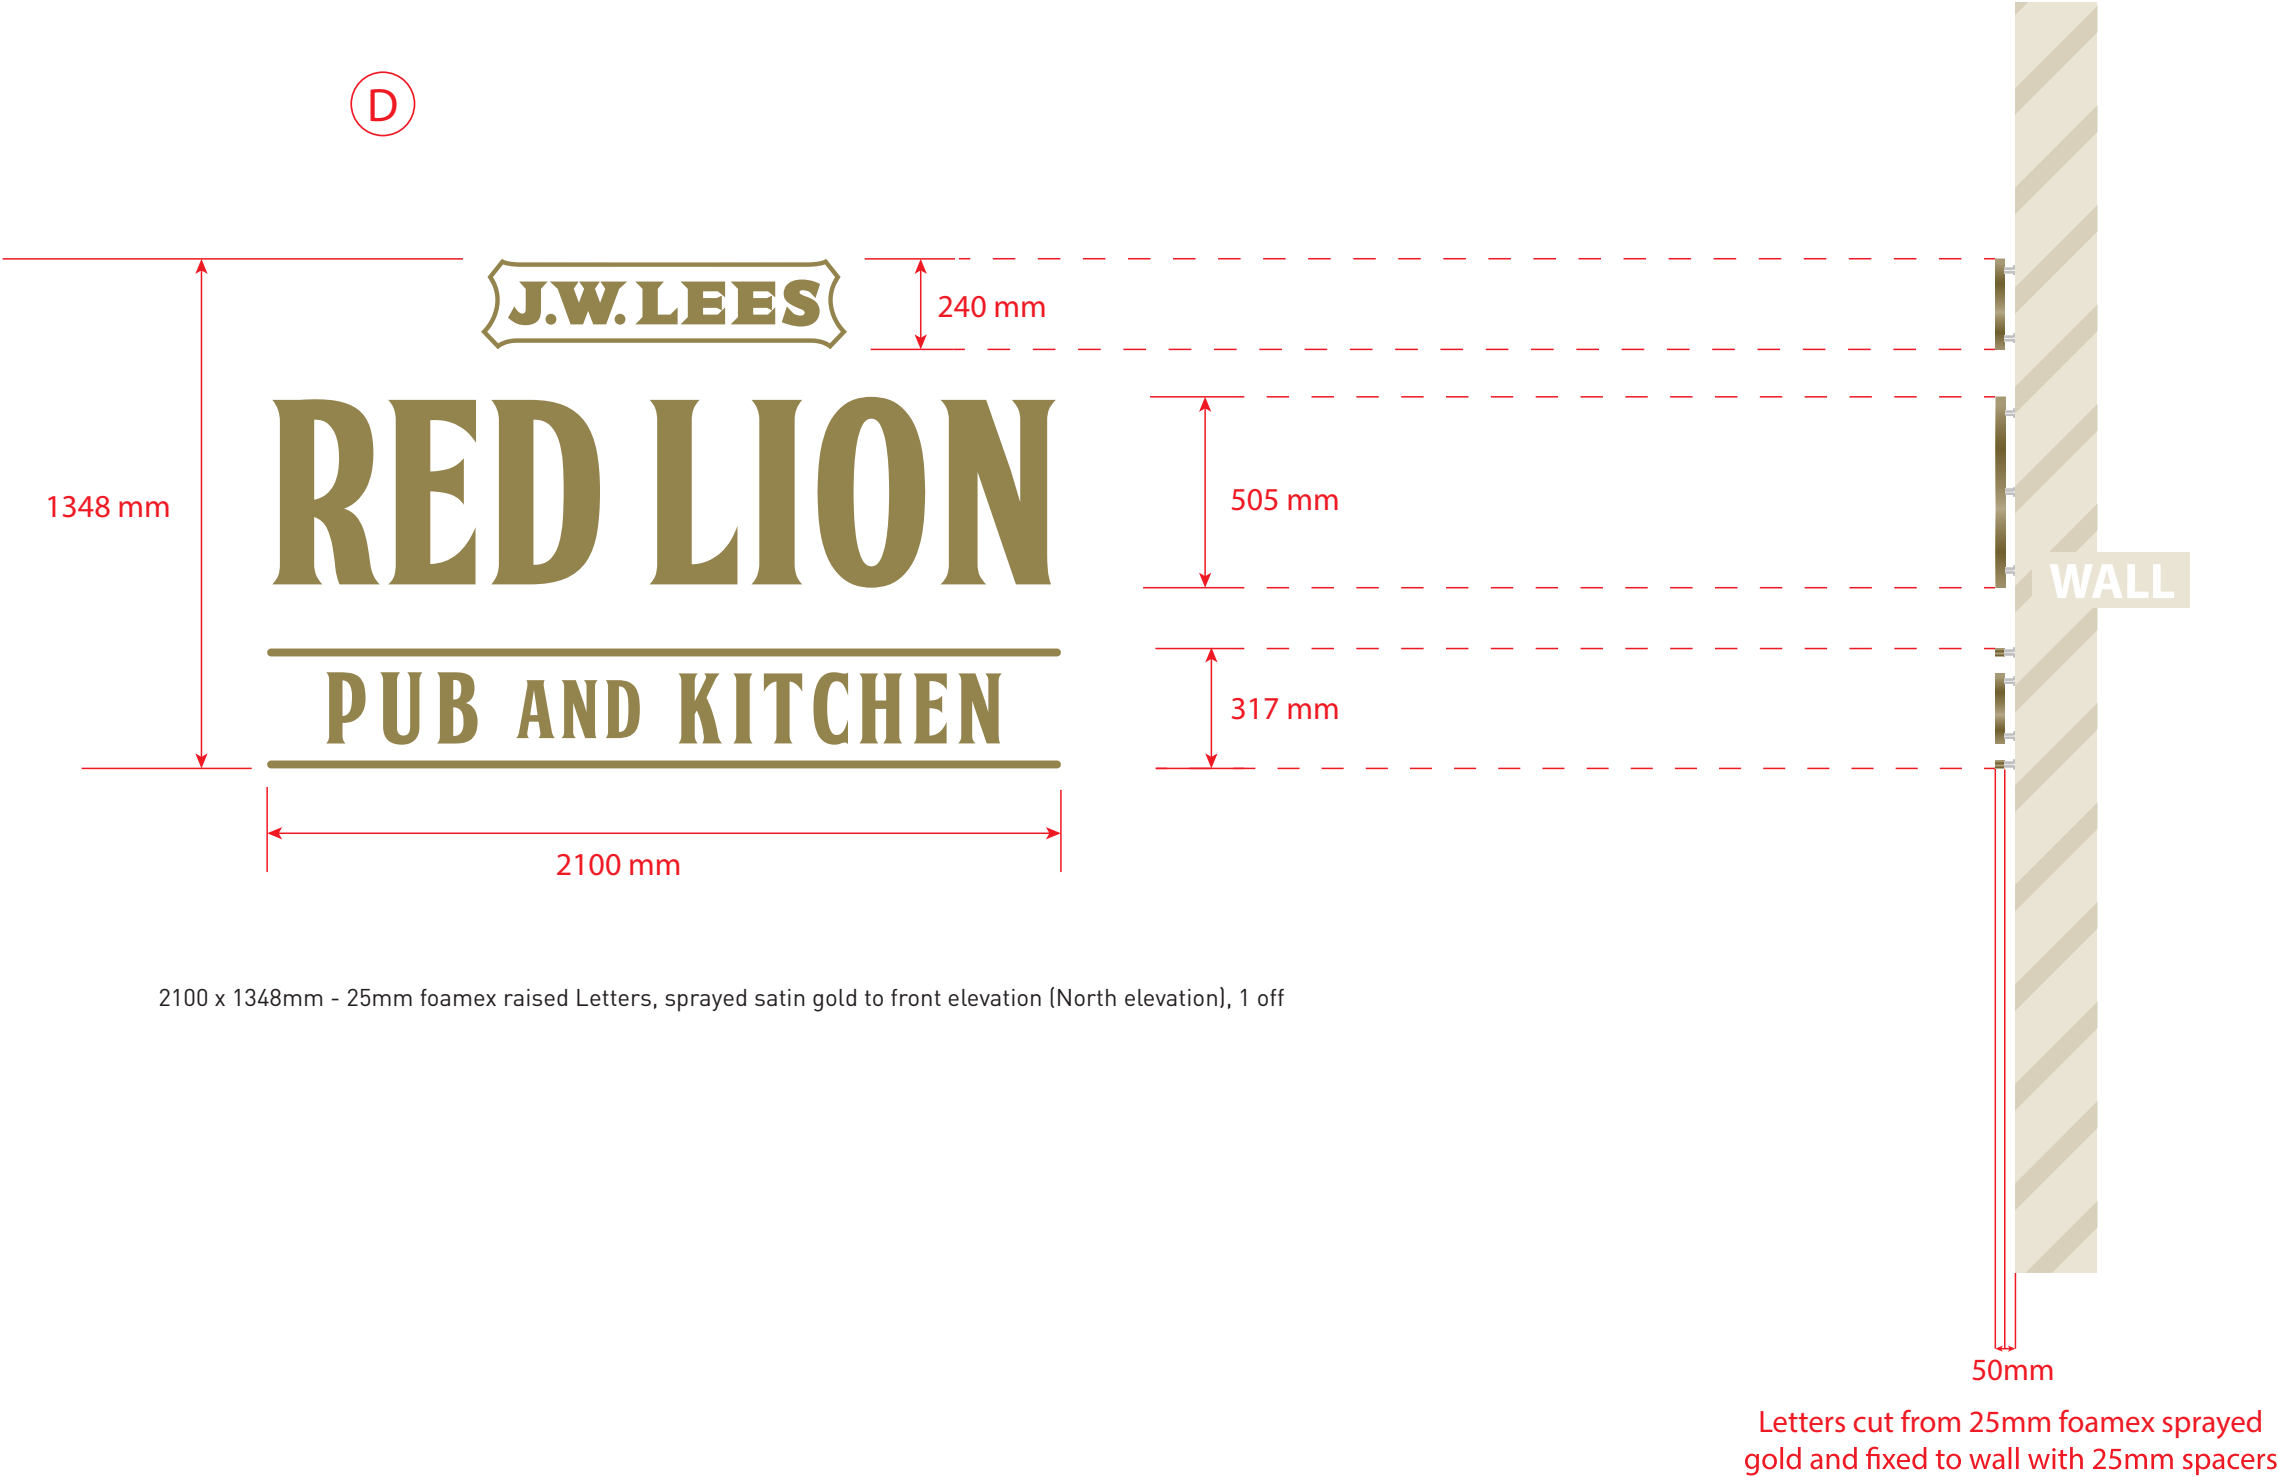

JOB NAME
RED LION

JOB NO.
20200110

DATE
14th October 2021

DRAWN BY
Andrew Norse

SITE ADDRESS
Address

Tel: 01254 580166 or email: info@parkinsonsigns.com - 12 Chapel Street, Blackburn, Lancashire BB2 2EH

RED LION - SIGNS OVERVIEW

D

NORTH ELEVATION
Ground to base of sign:
3565mm



JOB NAME
RED LION

JOB NO.
20200110

DATE
14th October 2021


DRAWN BY
Andrew Norse

SITE ADDRESS
Address

Tel: 01254 580166 or email: info@parkinsonsigns.com - 12 Chapel Street, Blackburn, Lancashire BB2 2EH

Scale 1:20 at A3

SIDE PROJECTION

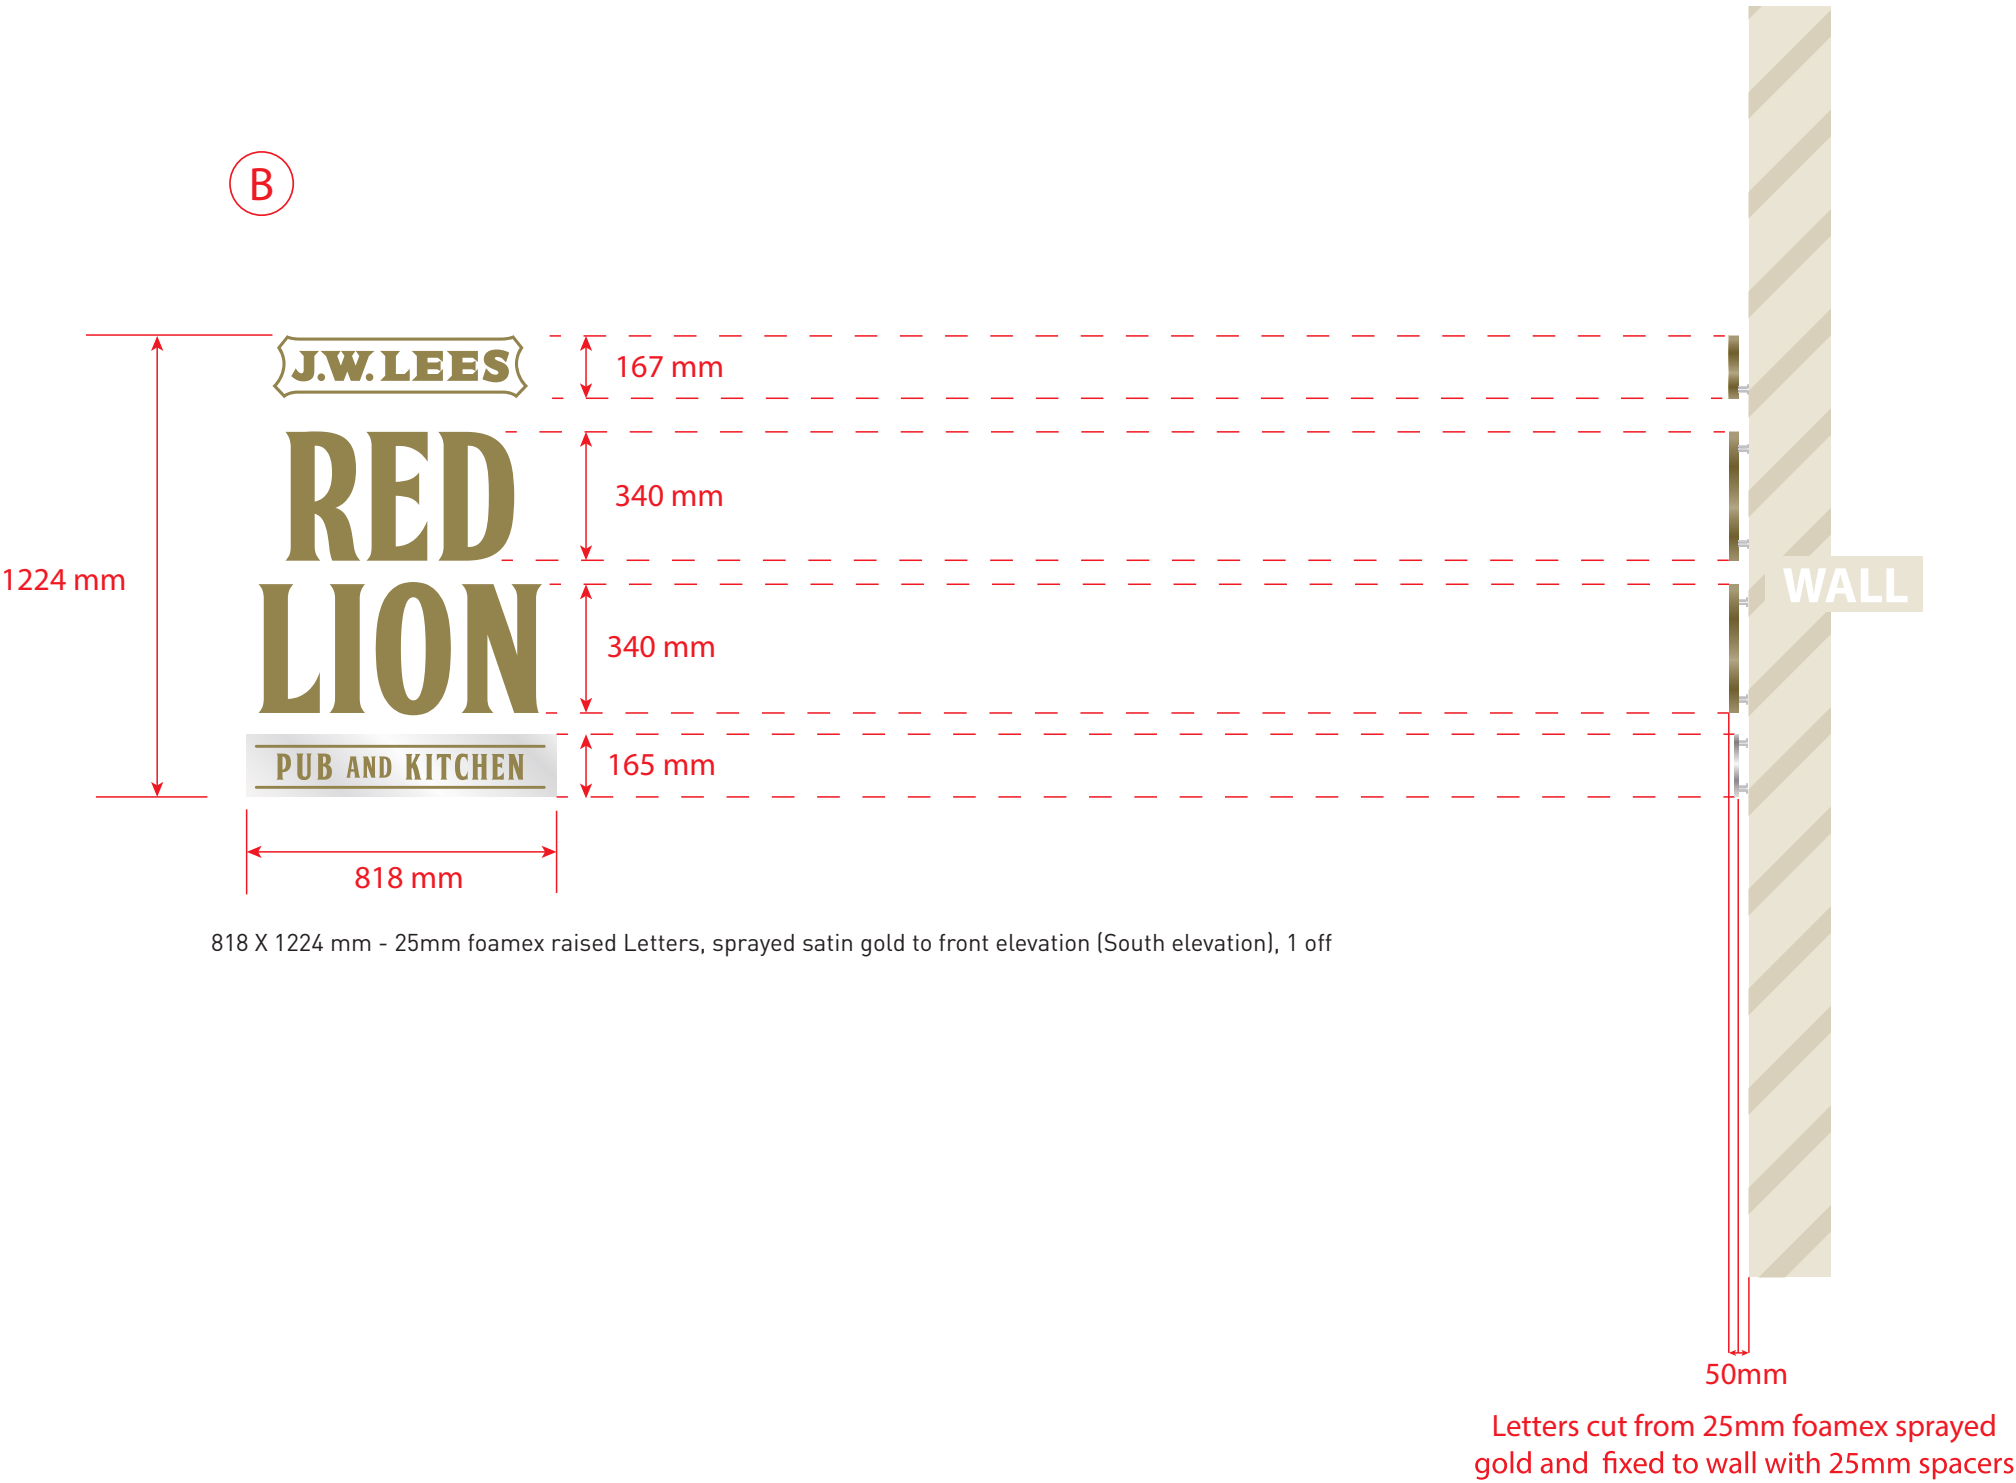

JOB NAME
RED LION

JOB NO.
20200110

DATE
14th October 2021

DRAWN BY
Andrew Norse

SITE ADDRESS
Address

Tel: 01254 580166 or email: info@parkinsonsigns.com - 12 Chapel Street, Blackburn, Lancashire BB2 2EH

RED LION - SIGNS OVERVIEW

B

SOUTH ELEVATION
Ground to base of sign:
3100mm



JOB NAME
RED LION

JOB NO.
20200110

DATE
14th October 2021


DRAWN BY
Andrew Norse

SITE ADDRESS
Address

Tel: 01254 580166 or email: info@parkinsonsigns.com - 12 Chapel Street, Blackburn, Lancashire BB2 2EH

LANCASHIRE SIGN MAKERS
PARKINSON SIGNS
SINCE 1946

RED LION - SIGNS OVERVIEW

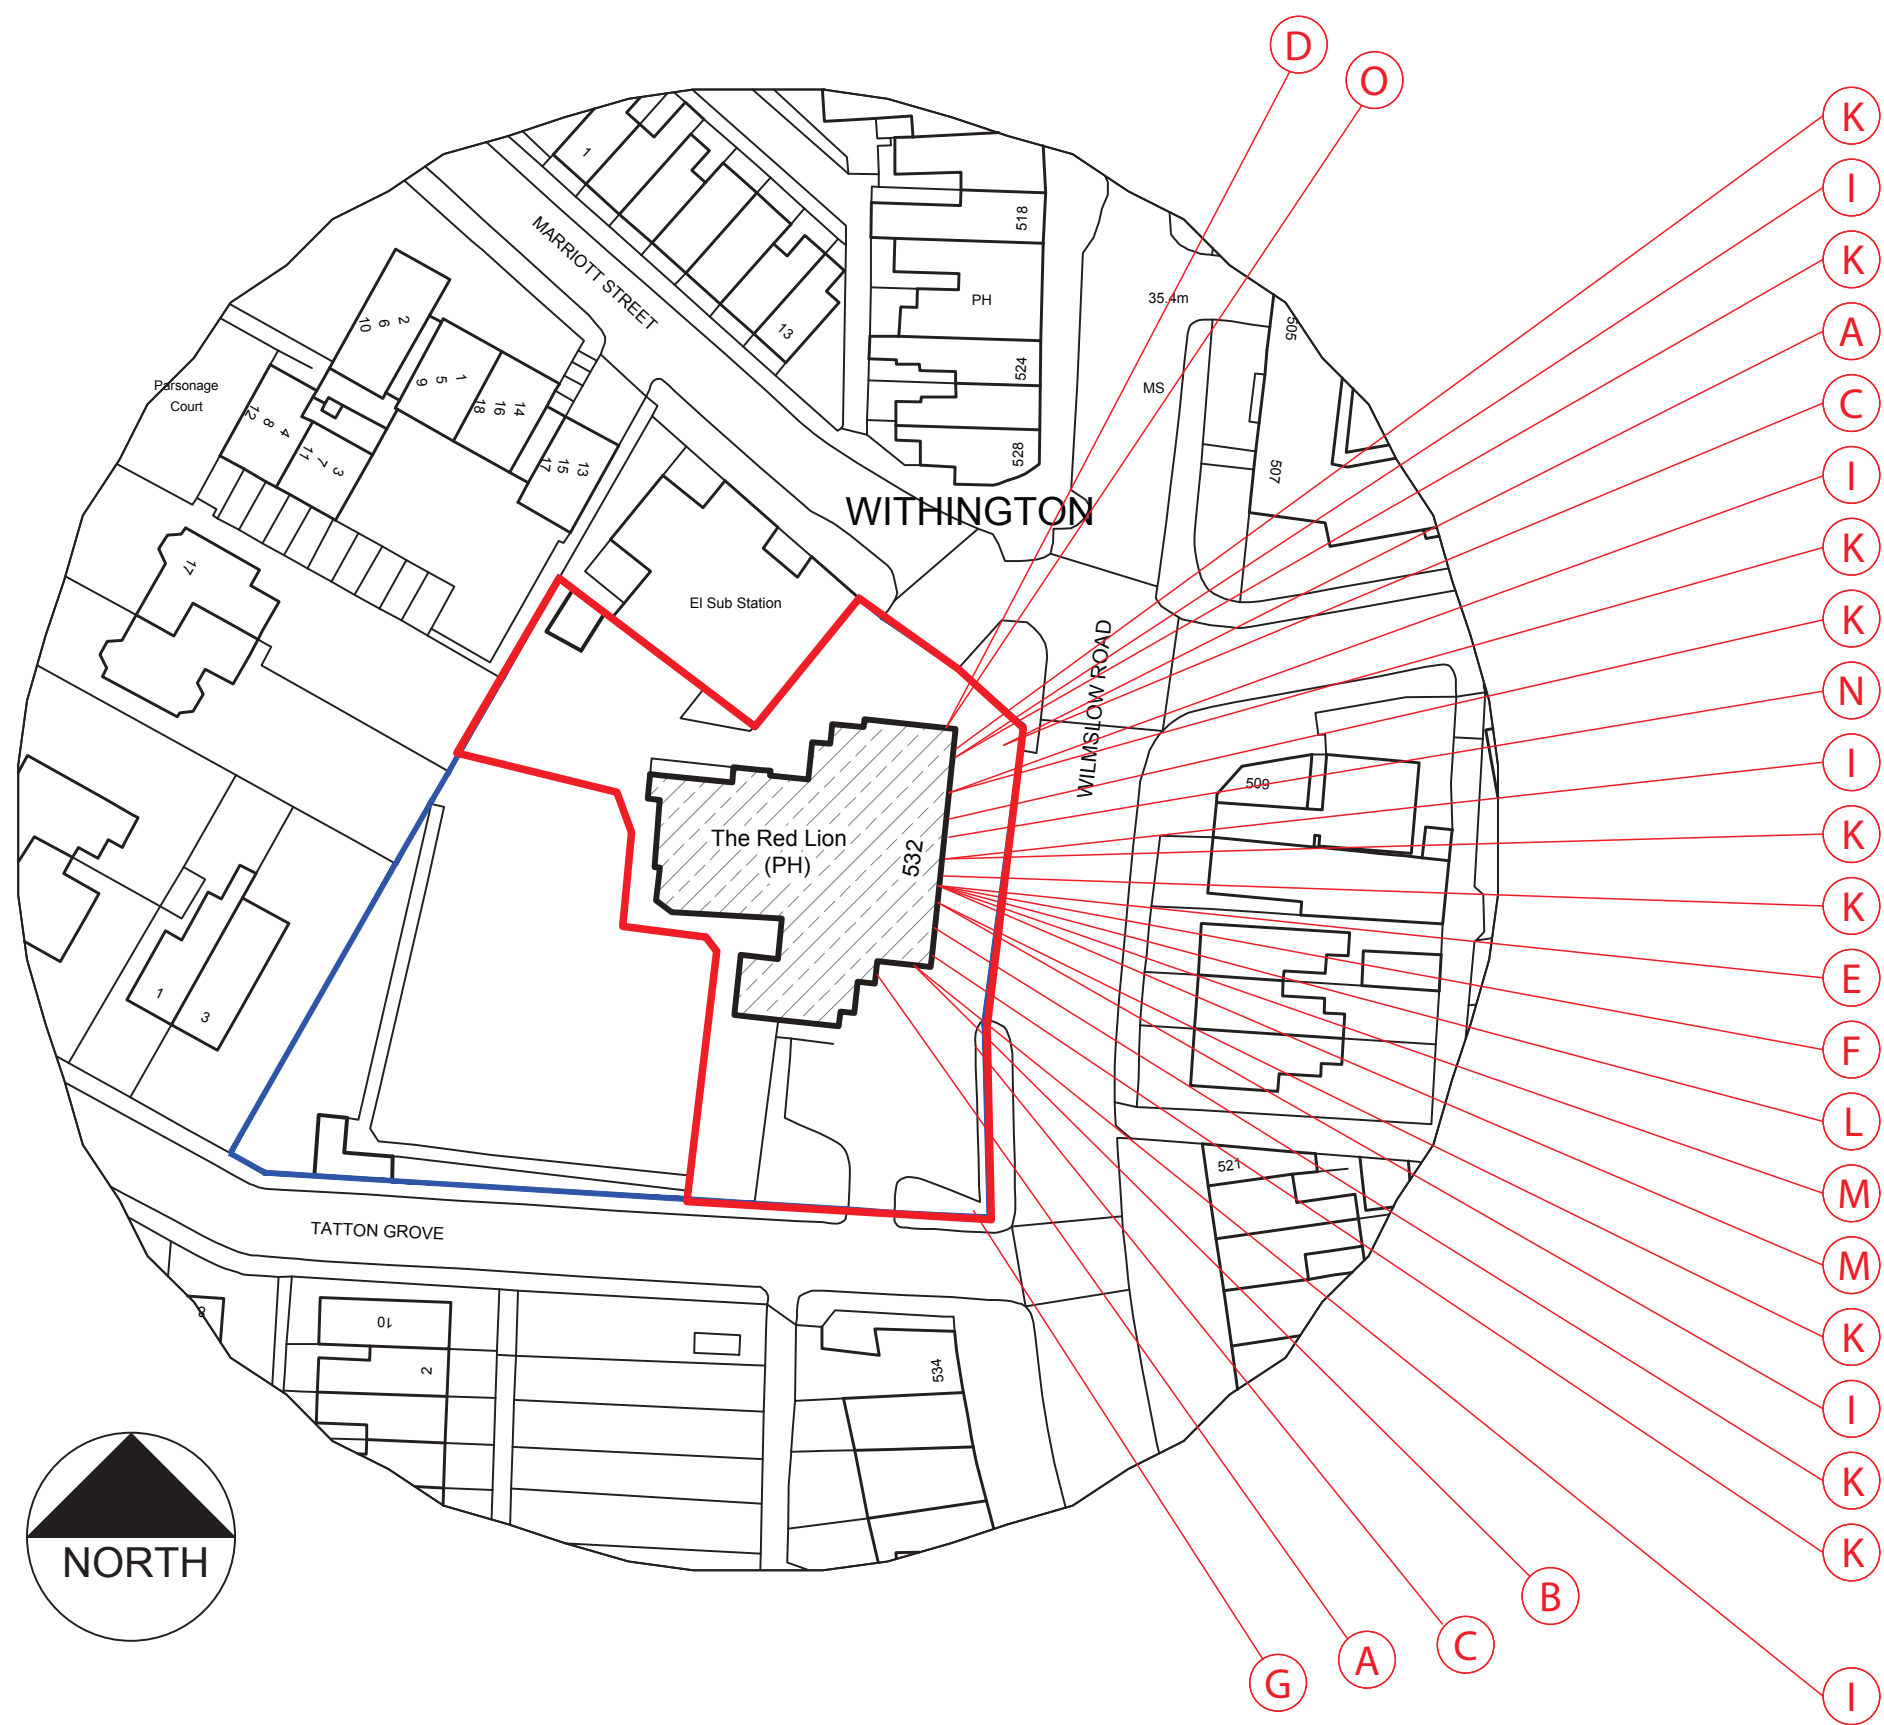

L 9 No. Lights
at lower level




Marine - Large wall lantern

Product Information

Fitting Height: 445mm
Width: 241mm
Projection: 254mm
Finish: Western Bronze
Class: Class 1
Wattage: 5 watt LED
Socket: E27
Voltage: 220-240v 50hz
Energy rating: A - E
Build material: Metal
Product type: Wall light
Weight: 5kg

Product Dimensions

CAT NO.	LENGTH (mm)	DEPTH (mm)	HEIGHT (mm)
LFS6B1**	125	70	85
LFS12B1**	135	80	105
LFS18B1**	135	80	105
LFS30B1**	260	110	185
LFSP6B1**	125	130	135
LFSP12B1**	155	140	155
LFSP18B1**	155	140	155
LFSP30B1**	260	160	230

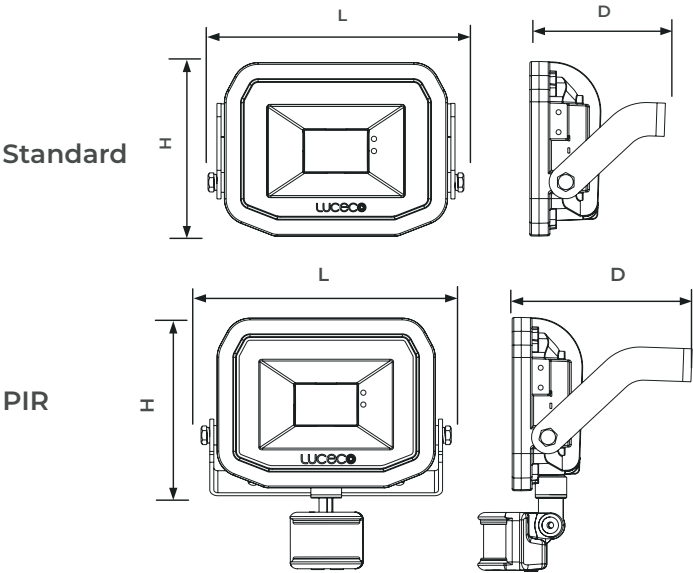

CAT NO.	WEIGHT (kg)	CRI	FREQUENCY (Hz)	IK RATING	TEMP RANGE (°C)	AMBIENT TEMP RATED LIFE (°C)	L/B RATED LIFE
LFS6B1**	0.45	>80	50-60	IK04	-20 to +25	25	L70 / B50
LFS12B1**	0.635	>80	50-60	IK04	-20 to +25	25	L70 / B50
LFS18B1**	0.585	>80	50-60	IK04	-20 to +25	25	L70 / B50
LFS30B1**	2.0	>80	50-60	IK04	-20 to +25	25	L70 / B50
LFSP6B1**	0.5	>80	50-60	IK04	-20 to +25	25	L70 / B50
LFSP12B1**	0.75	>80	50-60	IK04	-20 to +25	25	L70 / B50
LFSP18B1**	0.635	>80	50-60	IK04	-20 to +25	25	L70 / B50
LFSP30B1**	2.06	>80	50-60	IK04	-20 to +25	25	L70 / B50

STANDARD	DESCRIPTION
60598-1	Luminaires - General requirements
60598-2-5	Luminaires - Floodlights
61000-3-2	Electromagnetic compatibility (EMC) - Part 3-2: Limits - for harmonic current emissions
61000-3-3	Lamp controlgear - Part 1: General and safety requirements
61547	Equipment for general lighting purposes - EMC immunity requirements
55015	Limits and methods of measurement of radio disturbance characteristics of electrical lighting and similar equipment

LUCECO

This luminaire contains built-in LED lamps.

A++

A+

A

B

C

D

E

} LED

The lamps cannot be changed in the luminaire.

874/2012

SLIMLINE
GUARDIAN
FLOODLIGHT

Product Features


- Die-cast aluminium housing for maximum durability
- Easy installation with fit and tilt bracket
- Various colour temperatures available to suit all applications
- Supplied with 1 metre of cable, ideal where through-wall wiring is neccasary
- Option of PIR detection with adjustable settings and override functionality, operate in dusk till dawn mode only



Standard

Non-PIR

CAT NO.	LUMINAIRE LUMENS	WATTAGE	COLOUR TEMP	IP RATING
LFS6B130	600	8W	3000K	IP65
LFS6B150	600	8W	5000K	IP65
LFS12B130	1200	15W	3000K	IP65
LFS12B150	1200	15W	5000K	IP65
LFS18B130	1800	22W	3000K	IP65
LFS18B150	1800	22W	5000K	IP65
LFS30B130	3000	38W	3000K	IP65
LFS30B150	3000	38W	5000K	IP65

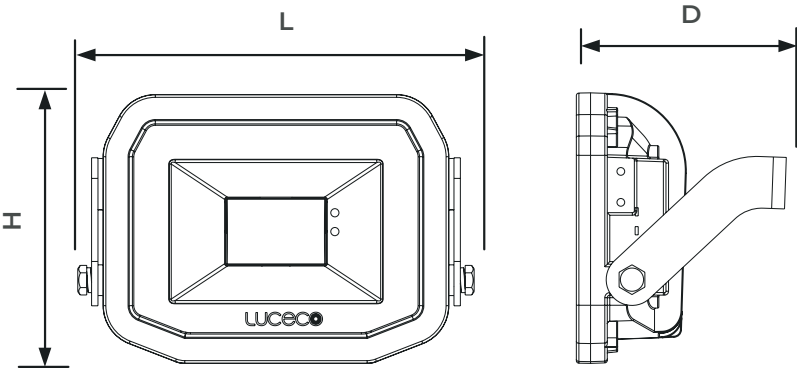

Product Dimensions

CAT NO.	LENGTH (mm)	DEPTH (mm)	HEIGHT (mm)
LFS6B1**	125	70	85
LFS12B1**	135	80	105
LFS18B1**	135	80	105
LFS30B1**	260	110	185
LFSP6B1**	125	130	135
LFSP12B1**	155	140	155
LFSP18B1**	155	140	155
LFSP30B1**	260	160	230

LUCECO

This luminaire contains built-in LED lamps.

A++

A+

A

B

C

D

E

} LED

The lamps cannot be changed in the luminaire.

874/2012




nanolight

Nanolight is the most waterproof LED sign light in the UK, sealed to IP66. The high-efficiency LED strip technology inside Nanolight consumes only 11.5 watts per metre and has an unrivalled 190 Lumens per Watt efficiency, that's an impressive 2185 lumens per metre. Premium Tridonic LED drivers are enclosed in a sleek 45mm aluminium profile. Installation is fast and easy thanks to the quick-fix brackets and our precision-engineered 'plug & play' middle connector system when linking two or more units. It is maintenance free, and with a 5 year parts warranty you can 'fit and forget'.

TECHNICAL SPECIFICATION

- Slim 45mm aluminium profile*
- Dust and water tight - sealed to IP66
- Length: Any size to nearest millimetre (300mm minimum – 6100mm maximum per section)
- Magnifying lens with built in gasket
- Internal Tridonic LED drivers**
- 2185 Lumens per metre light output
- 11.5 watts per metre
- Quick-fix brackets
- 2 part fully sealed middle connector system
- 5 year parts warranty
- Conforms to EN65958 electrical safety requirements and tested by Nemko Ltd

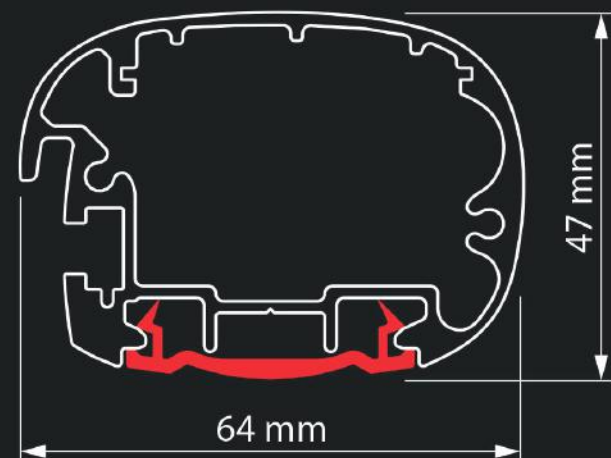

* 47mm profile including lens. **Mean Well drivers used in trough lights smaller than 1000mm.

 
200MM QUICK-FIX BRACKETS INCLUDED

- 4-way adjustability to reach the preferred angle
- Available in various sizes for ideal light projection*
- Powder coated and finished to match Nanolight
- Strong yet unobtrusive, perfectly coordinated with Nanolight
- T-shaped brackets to hang and hold Nanolight in place whilst fastening.



* Nanolight also fits on to our current range of brackets.

STOCK COLOURS



white
RAL 9003



black
RAL 9005



yellow
RAL 1023



red
RAL 3020



blue
RAL 5002



grey
RAL 7043



silver
RAL 9006

Nanolight is available in a variety of stock colours (black/white semi-gloss finish included at no extra cost). We can also powder coat to non-stock RAL colours in various finishes. Prices available on request.

OPTIONS

- Quick-fix brackets available with 100, 200, 300, 400 & 500mm projection
- Other styles of brackets available to suit various installations
- Choice of LEDs – 6000K Cool White as standard. Alternatively, 4000K Natural White and 3000K Warm White LEDs are available.