




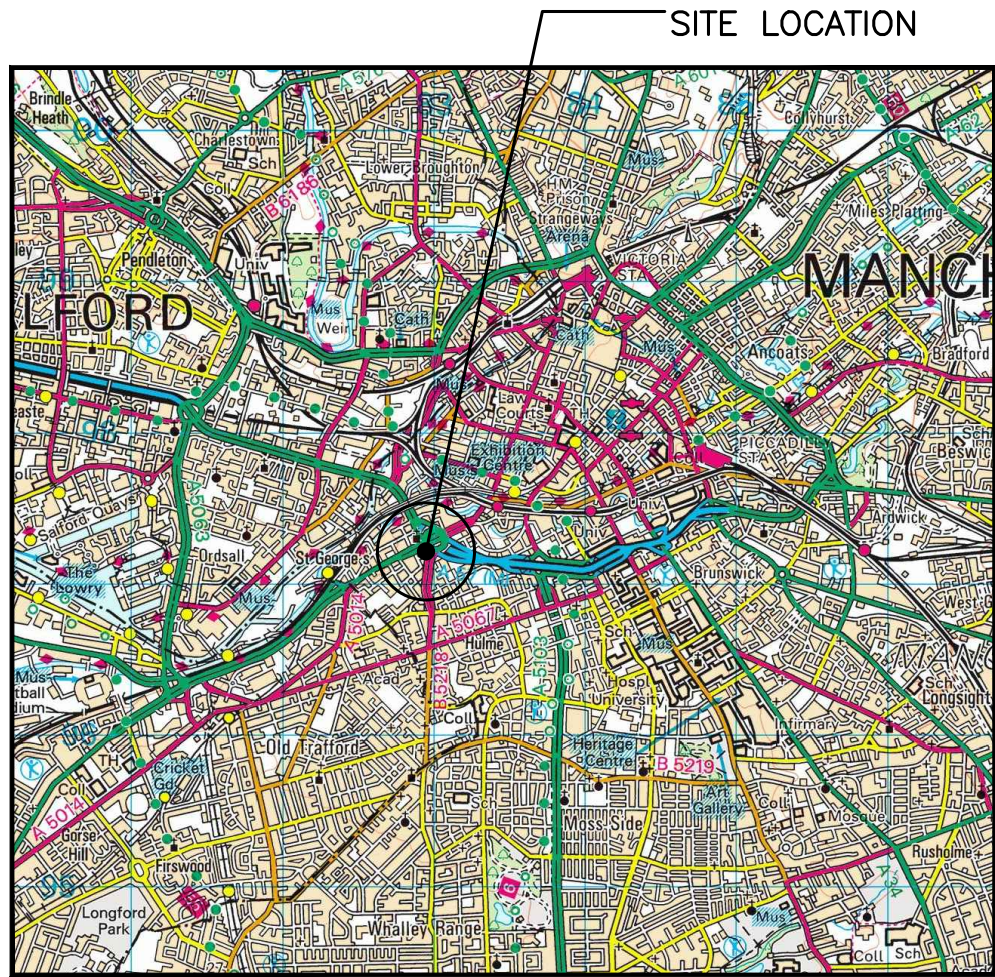


SITE LOCATION
(Scale 1:50000)
Ordnance Survey map extract
based upon Landranger map series
with the permission of the controller of
Her Majesty's Stationery Office
Licence No. 100022432
Crown copyright.

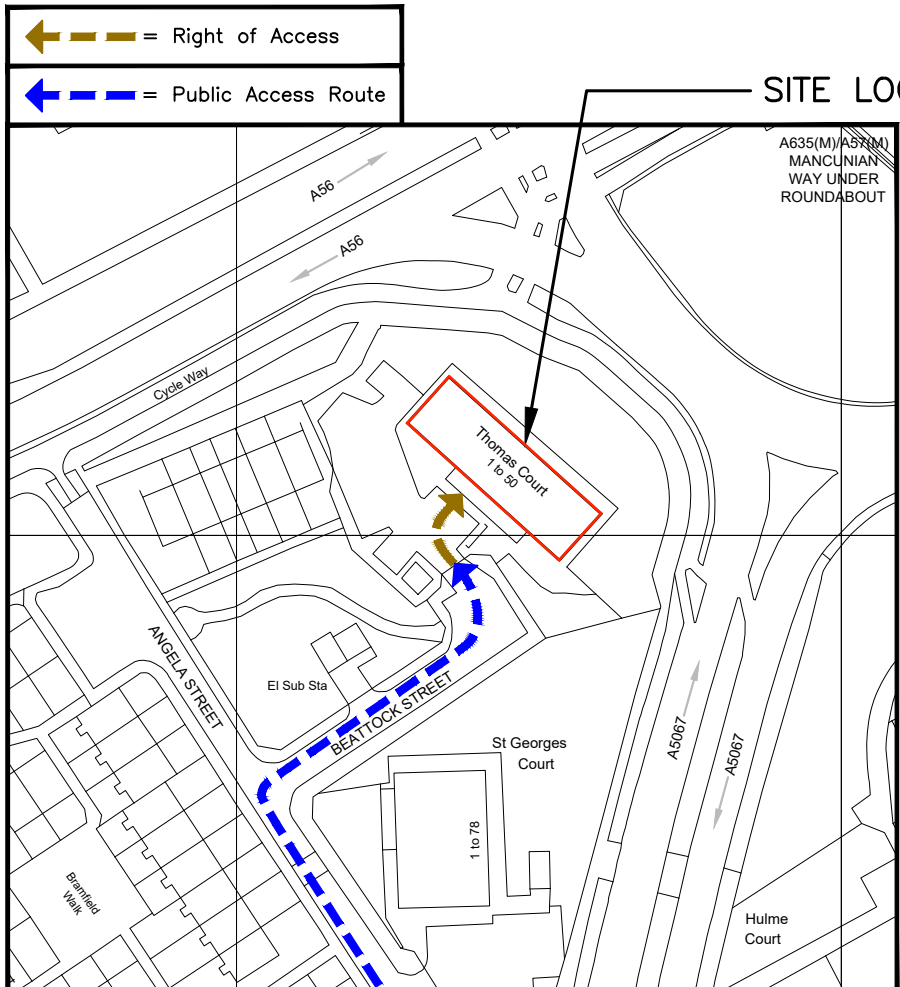

SITE PHOTOGRAPH

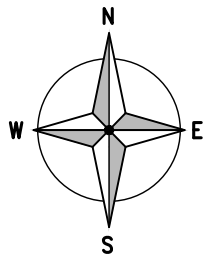

DETAILED SITE LOCATION
(Scale 1:1250)
Based upon Ordnance Survey map extract
with the permission of the Controller of
Her Majesty's Stationery Office.
Crown copyright.
Licence No. 100022432

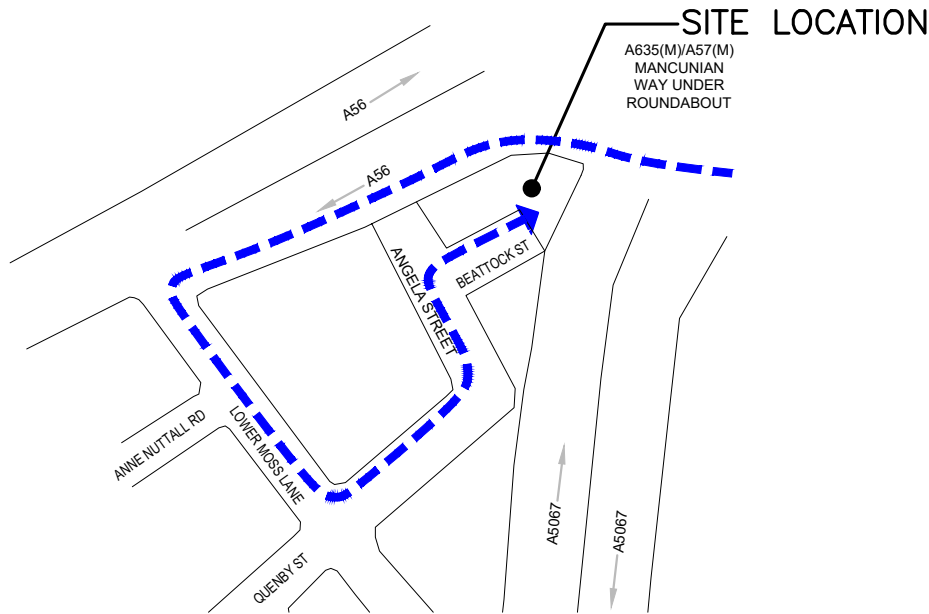

SITE ACCESS ROUTE
(N.T.S.)

ALL DIMENSIONS ARE IN mm UNLESS NOTED OTHERWISE

N.G.R | E: 382937 N: 397220

DIRECTIONS TO SITE:
HEADING WEST ALONG MANCUNIAN WAY, GOING
UNDER FOOT BRIDGE COME OFF AT JUNCTION
SIGN POSTED A56 ALTRINCHAM, TRAFFORD
PARK, WHALEY RANGE, DEANS GATE AND TURN
LEFT ONTO A56. THEN TURN AT 1st LEFT ON
TO LOWER MOSS LANE, THEN TURN LEFT ON
TO ANGELA STREET, FOLLOW ROUND THEN
TURN RIGHT IN TO BEATTOCK STREET.
ACCESS GATES TO BUILDING ARE TO LEFT AT
END OF STREET. SITE IS ON THOMAS COURT
BUILDING.

NOTES:

A	Issued for Approval	A.P	D.W	22.07.21
REV	MODIFICATION	BY	CH	DATE

CLARKE
telecom
Unit E, Madison Place, Northampton Road,
Manchester, M40 5AG
Tel: 0161 785 4500
Fax: 0161 785 4501
Web: www.clarke-telecom.com

O₂


CORNERSTONE - BEACON 3

Cell Name	Opt.
THOMAS COURT	-

Cell ID No		
CORNERSTONE	TEF	VF
304508_00 E337454	92408	00758

Site Address / Contact Details		
BEATTOCK STREET MANCHESTER GREATER MANCHESTER M15 4JA		

Drawing Title: SITE LOCATION MAPS				
Purpose of issue: PLANNING				Dwg Rev:
Drawing Number: 100				A
Surveyed By: D.W		Original Sheet Size: A3		Pack Issue:
Drawn: A.P	Date: 22.07.21	Checked: D.W	Date: 22.07.21	A

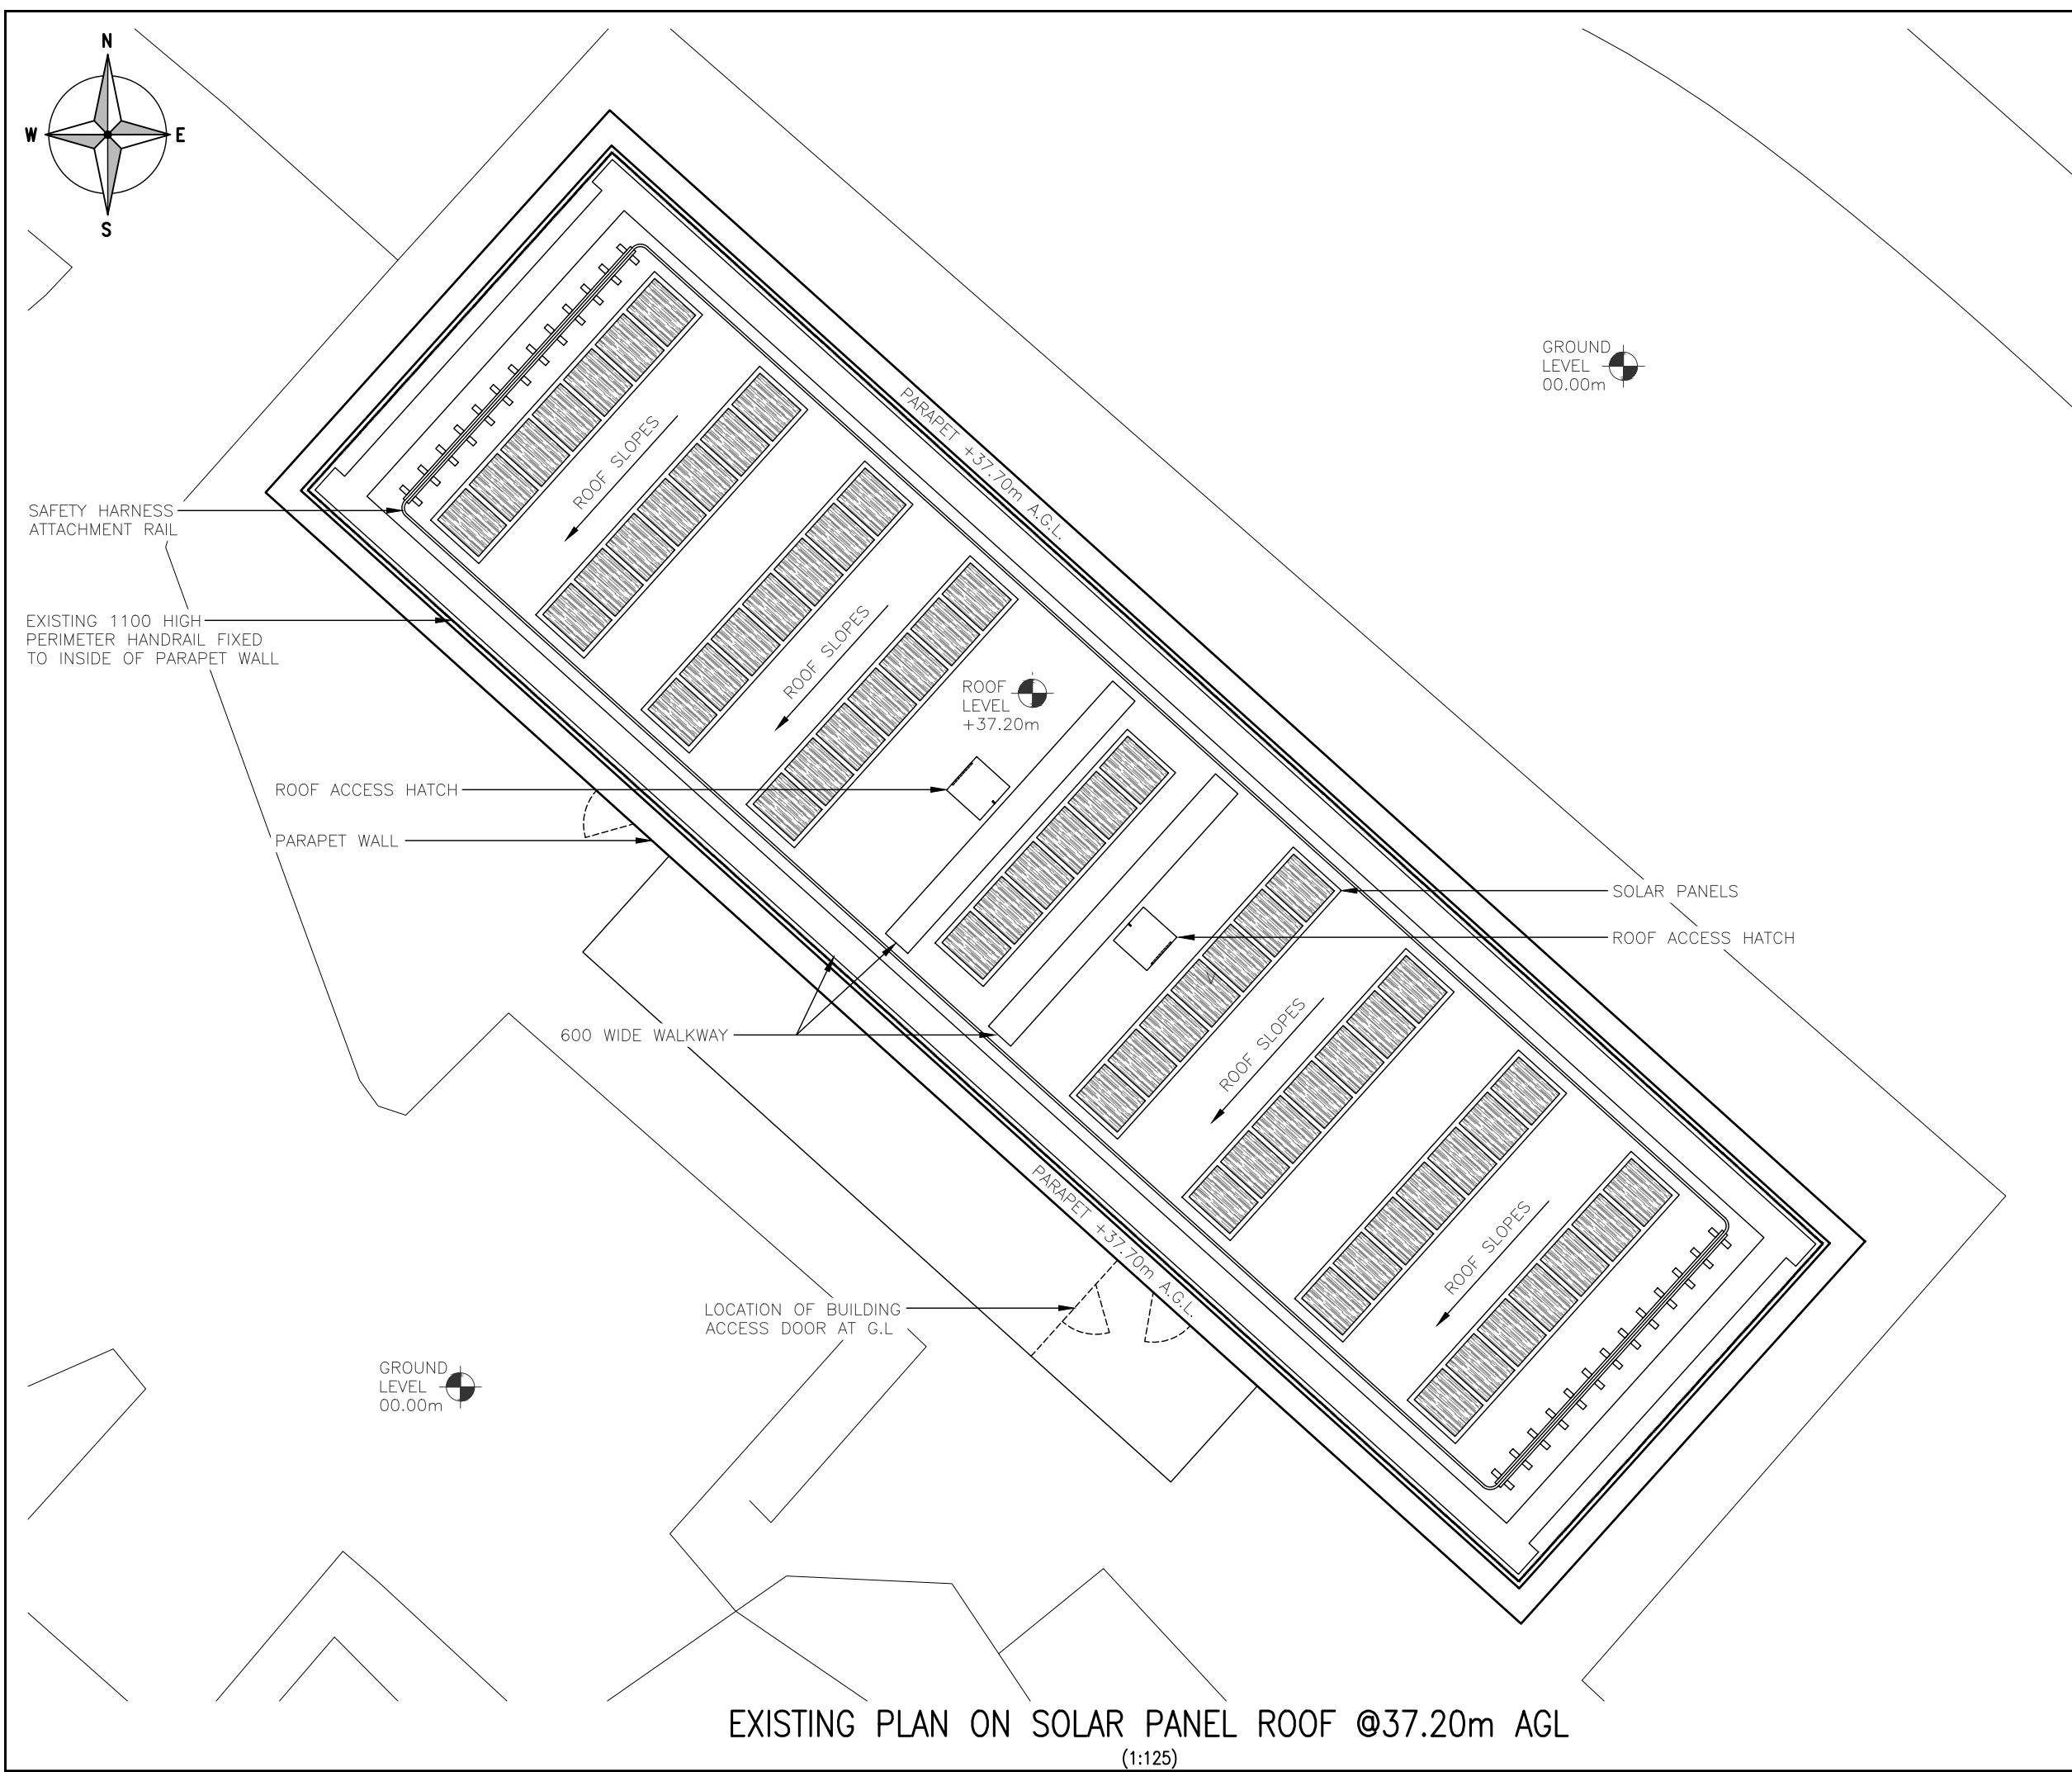

ALL DIMENSIONS ARE IN mm UNLESS NOTED OTHERWISE

N.G.R

E: 382937

N: 397220


NOTES:

A	Issued for Approval	A.P	D.W	22.07.21
REV	MODIFICATION	BY	CH	DATE

Unit E, Madison Place, Northampton Road,
Manchester, M40 5AG
Tel: 0161 785 4500
Fax: 0161 785 4501
Web: www.clarke-telecom.com

CORNERSTONE - BEACON 3

Cell Name			Opt.
THOMAS COURT			-
Cell ID No			
CORNERSTONE	TEF	VF	
304508_00 E337454	92408	00758	
Site Address / Contact Details			
BEATTOCK STREET MANCHESTER GREATER MANCHESTER M15 4JA			
Drawing Title: EXISTING SITE PLAN			
Purpose of issue: PLANNING			Dwg Rev:
Drawing Number: 200			A
Surveyed By: D.W		Original Sheet Size: A3	Pack Issue:
Drawn: A.P	Date: 22.07.21	Checked: D.W	Date: 22.07.21

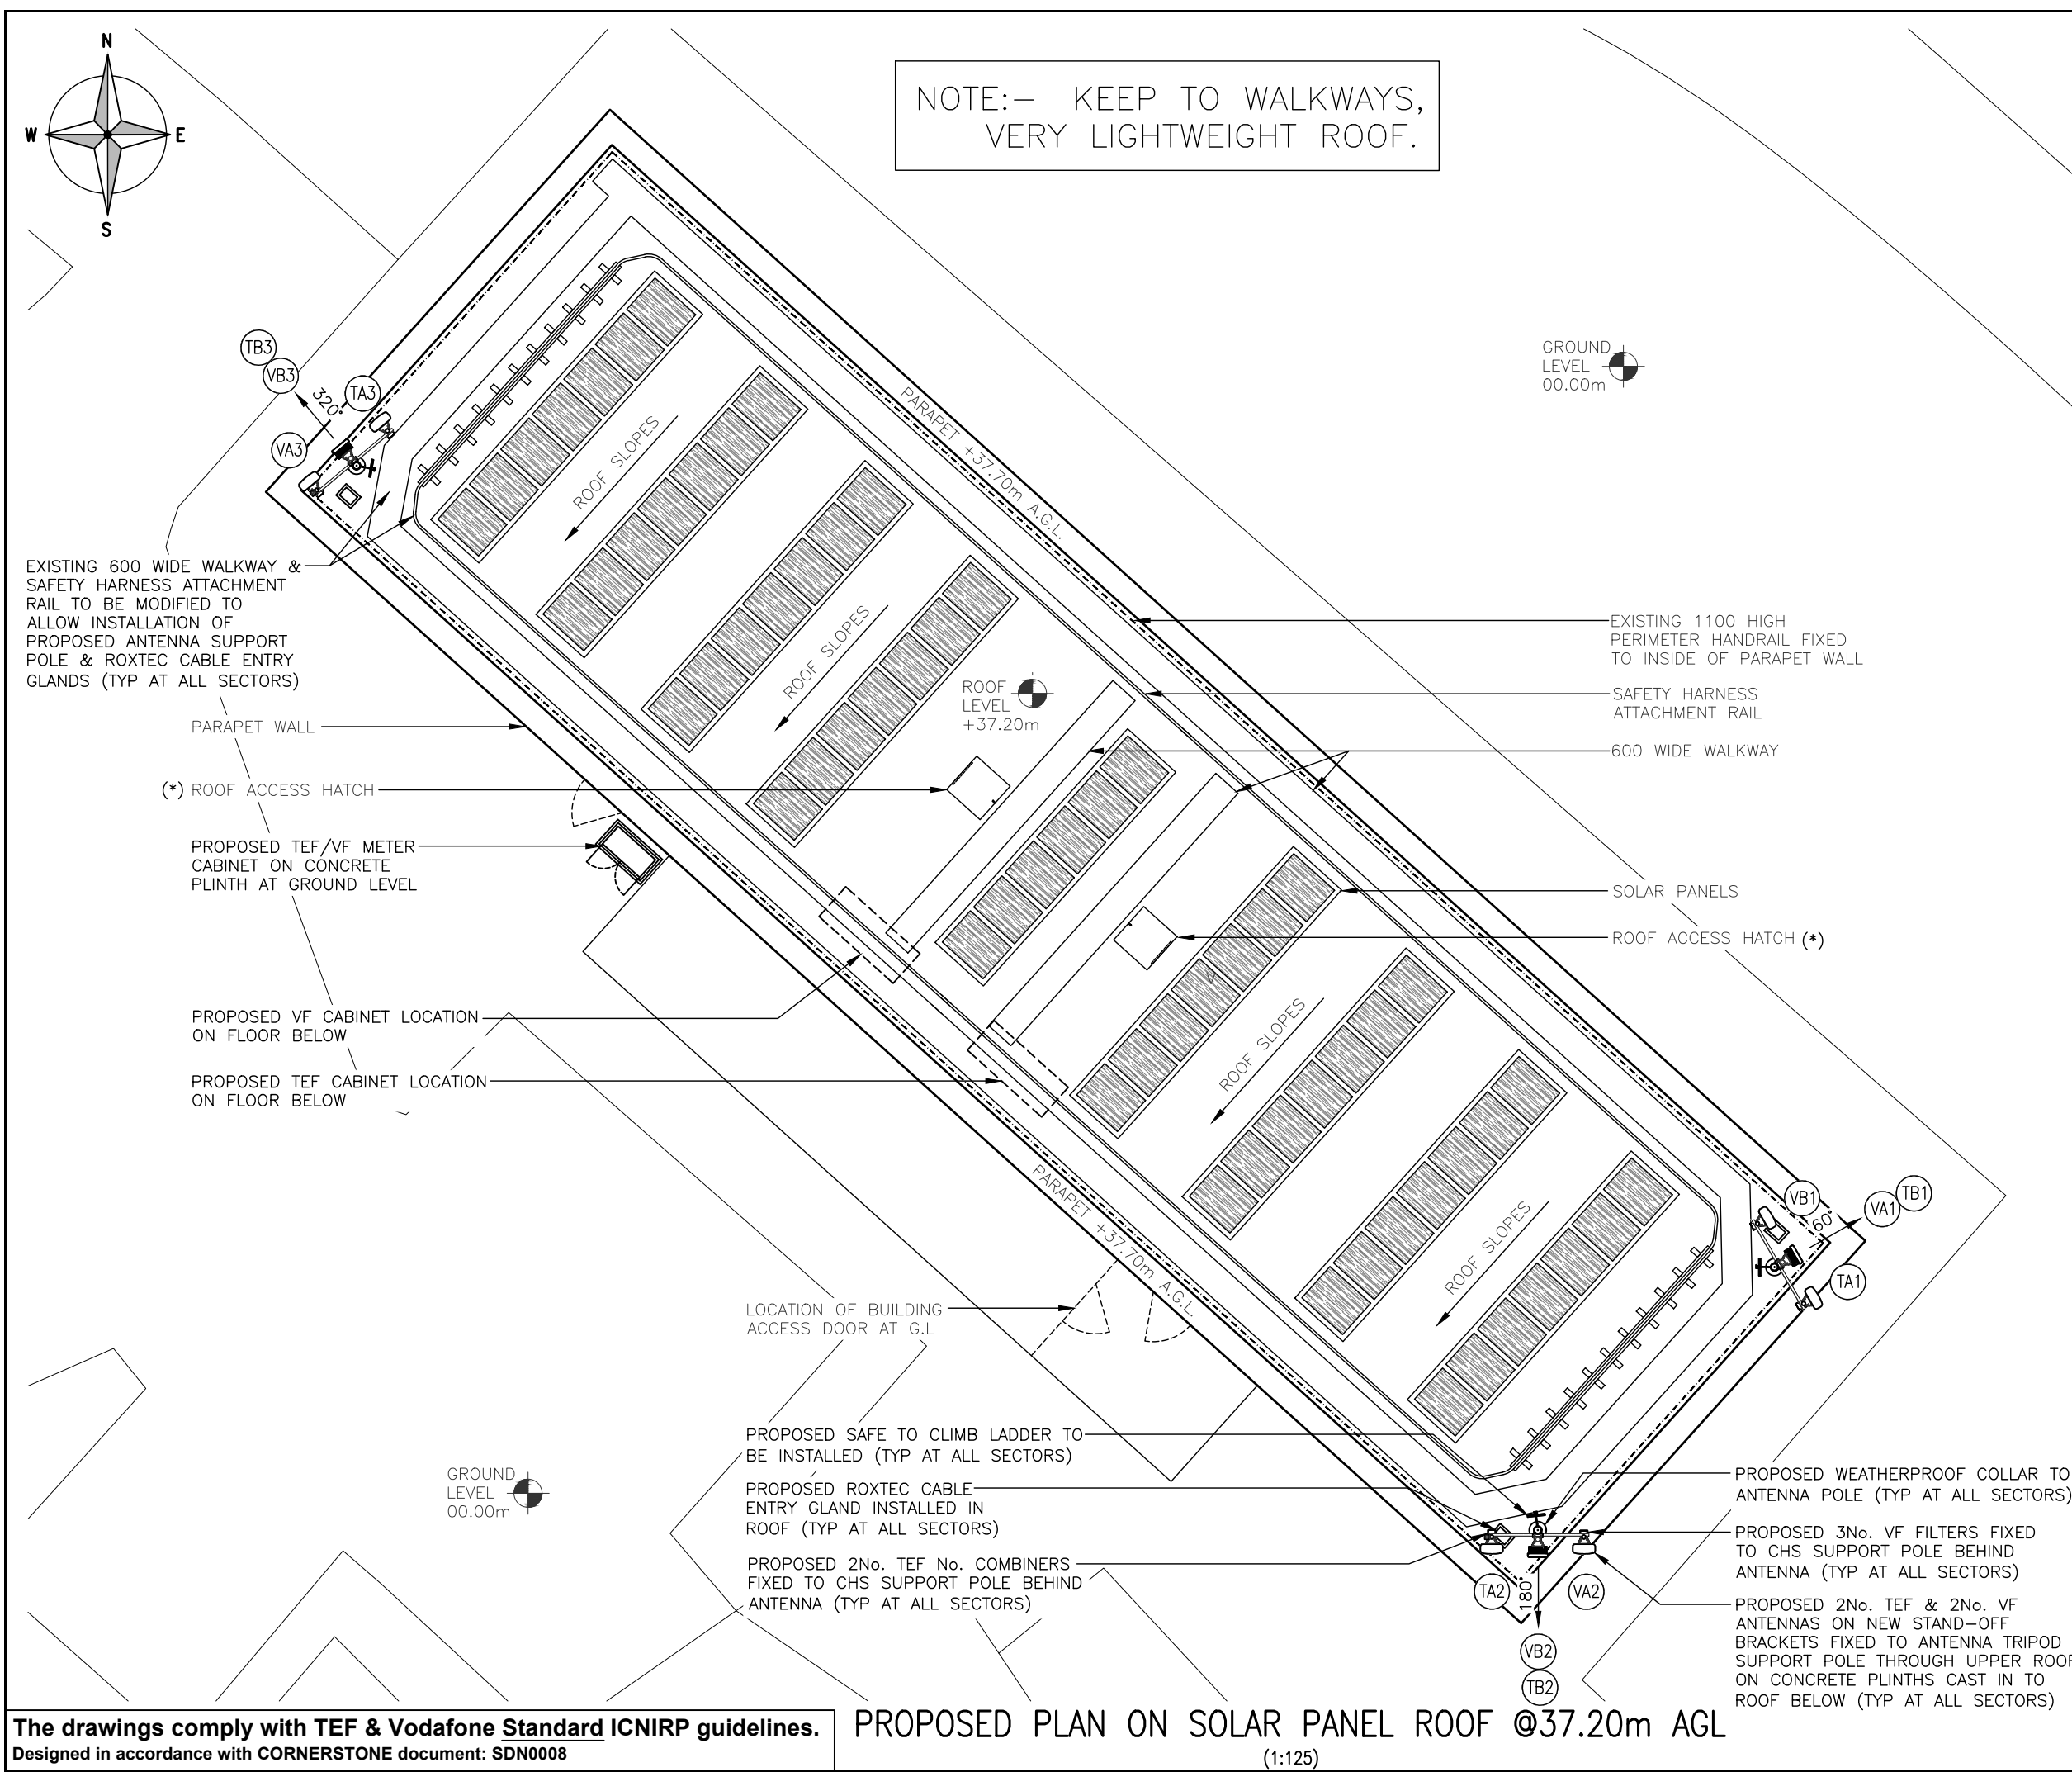

ALL DIMENSIONS ARE IN mm UNLESS NOTED OTHERWISE

N.G.R

E: 382937

N: 397220

NOTES:

NOTE:- ALL STEELWORK IS TO BE DESIGNED TO BE MAN HANDLED UP TO ROOF LEVELS AND EQUIPMENT TO BE FLAT PACK TYPE

(*) - EXISTING CLIMBING SYSTEMS & HATCHES EXIT ON TO SOLAR PANEL ROOF ARE TO BE MODIFIED/IMPROVED. EXACT DETAILS T.B.C

A	Issued for Approval	A.P	D.W	22.07.21	
REV	MODIFICATION	BY	CH	DATE	


Unit E, Madison Place, Northampton Road,
Manchester, M40 5AG
Tel: 0161 785 4500
Fax: 0161 785 4501
Web: www.clarke-telecom.com

CORNERSTONE - BEACON 3

Cell Name			Opt.
THOMAS COURT			-
Cell ID No			
CORNERSTONE	TEF	VF	
304508_00 E337454	92408	00758	
Site Address / Contact Details			
BEATTOCK STREET MANCHESTER GREATER MANCHESTER M15 4JA			
Drawing Title: PROPOSED SITE PLAN			
Purpose of issue:			Dwg Rev:
PLANNING			
Drawing Number:			A
201			
Surveyed By:		Original Sheet Size:	Pack Issue:
D.W		A3	
Drawn:	Date:	Checked:	Date:
A.P	22.07.21	D.W	22.07.21
			A


The drawings comply with TEF & Vodafone Standard ICNIRP guidelines.
Designed in accordance with CORNERSTONE document: SDN0008

PROPOSED PLAN ON SOLAR PANEL ROOF @37.20m AGL
(1:125)

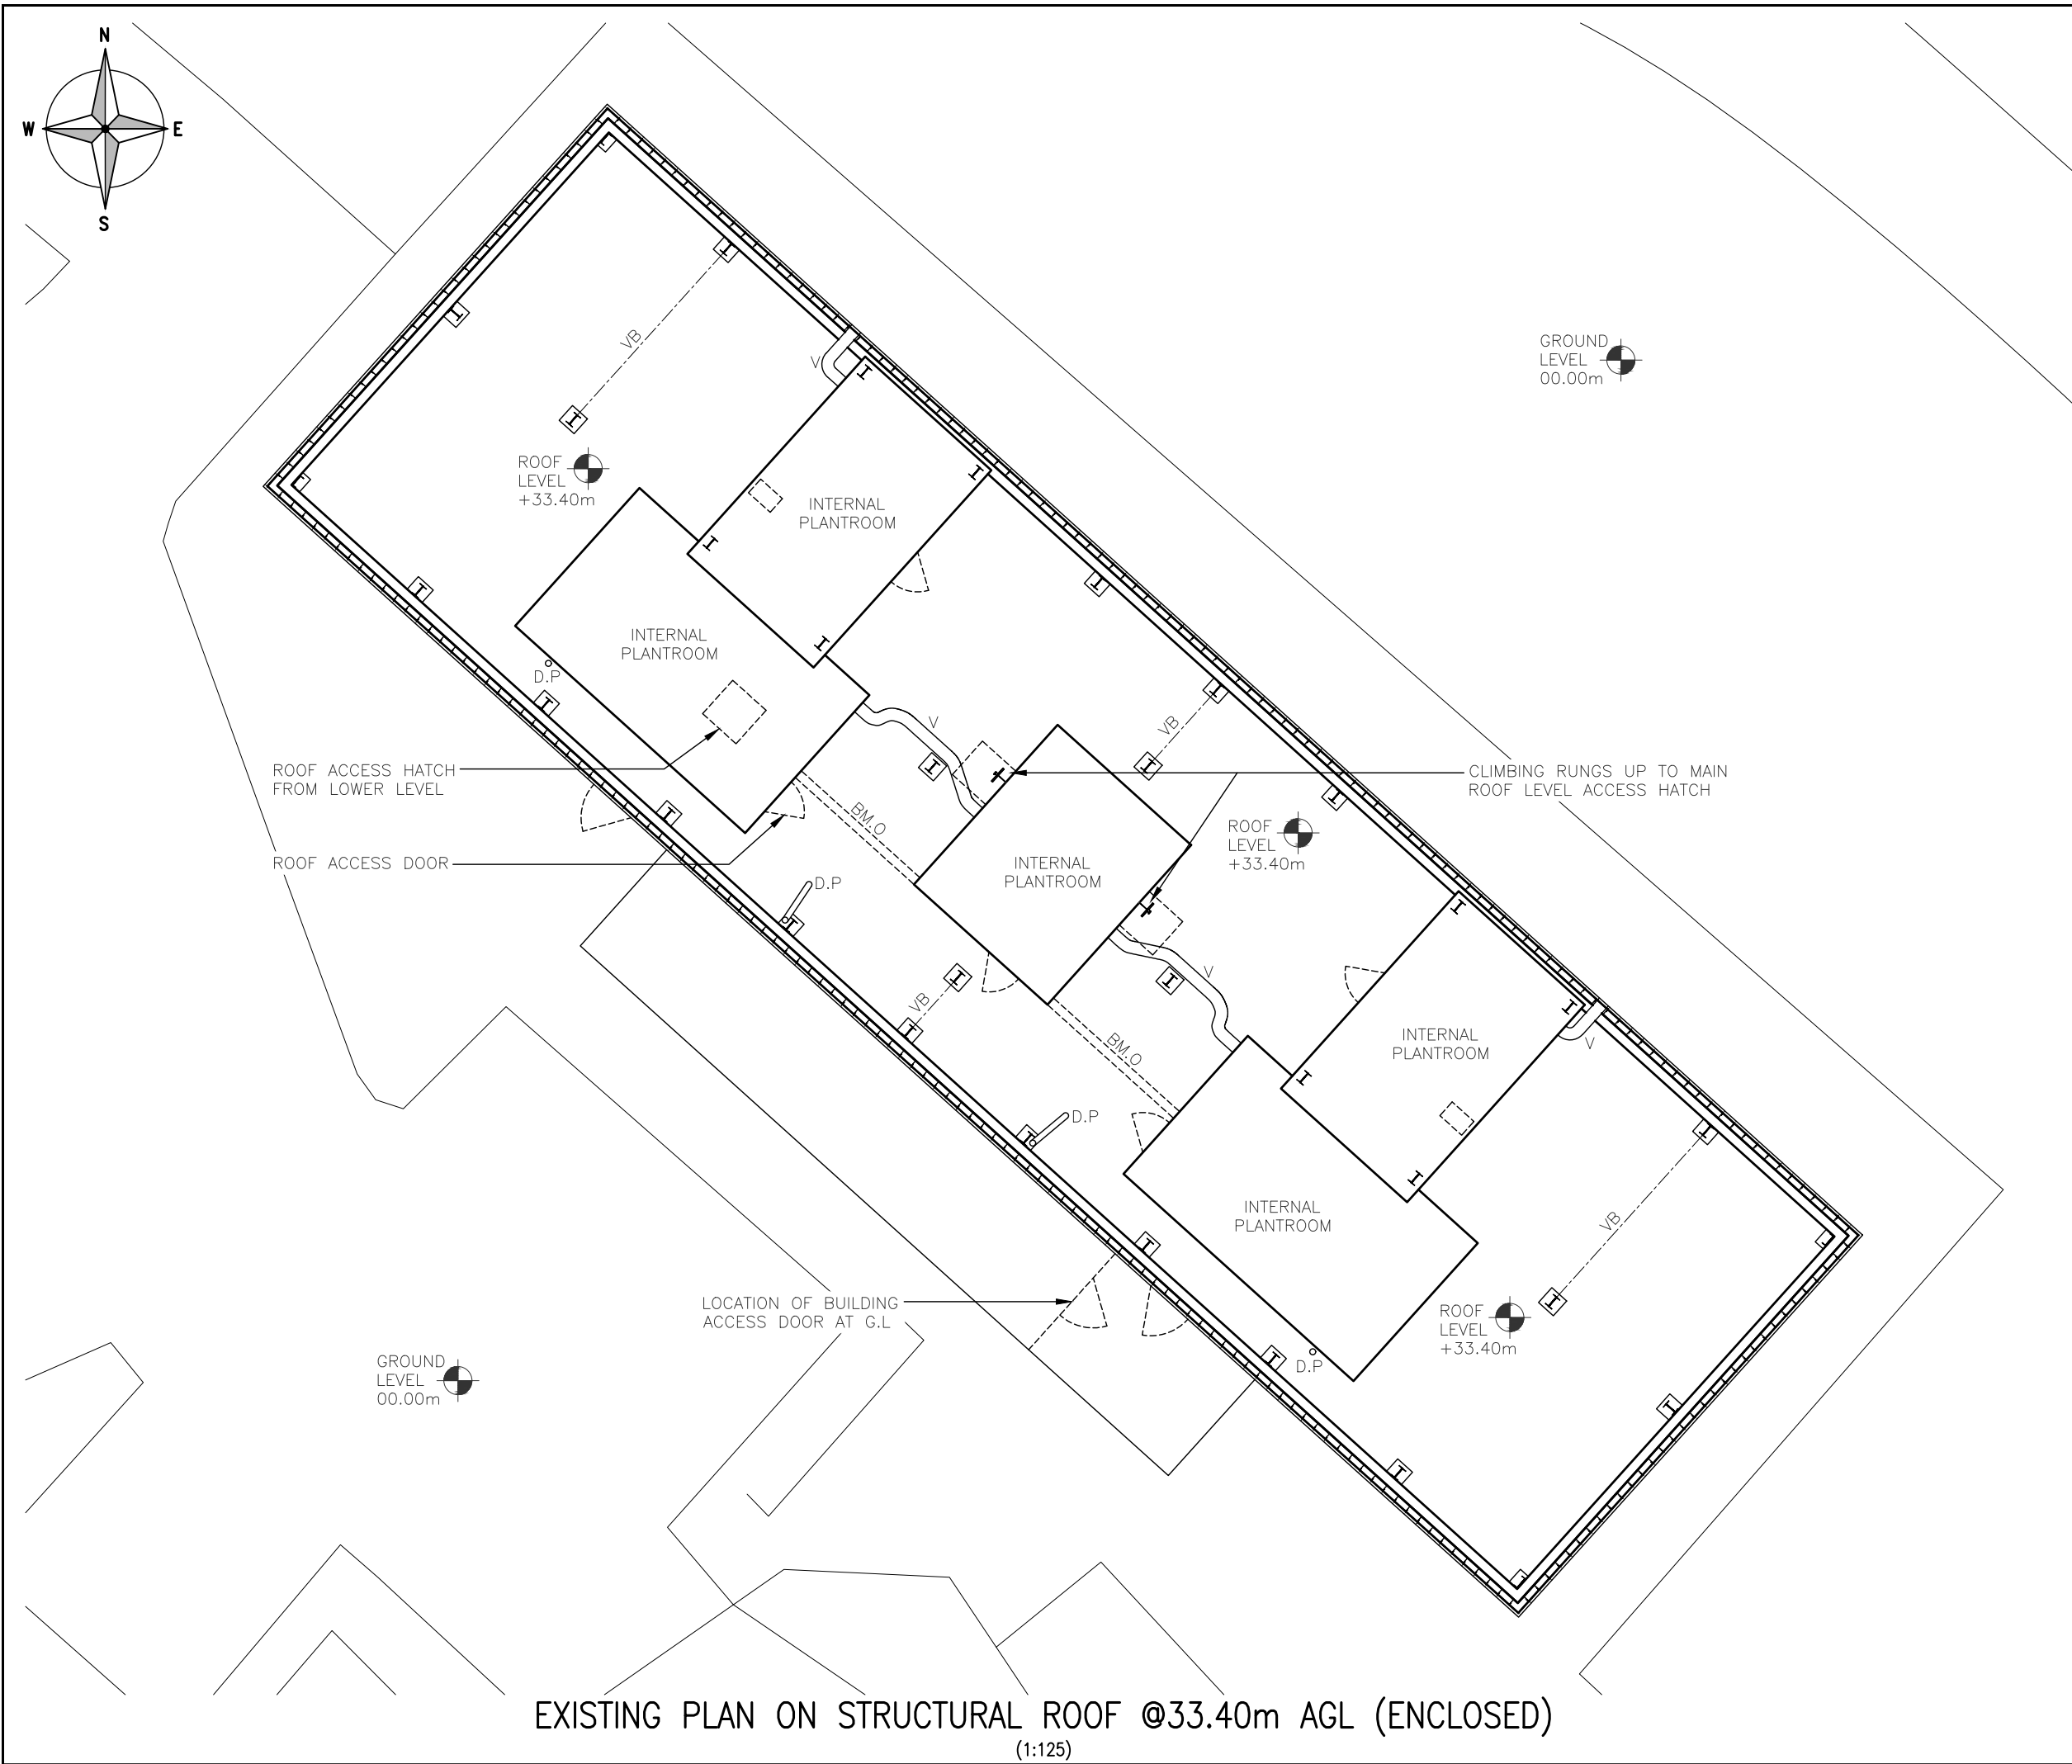

Drawn: A.P	Date: 22.07.21	Checked: D.W	Date: 22.07.21	A
---------------	-------------------	-----------------	-------------------	---

EXISTING PLAN ON STRUCTURAL ROOF @33.40m AGL (ENCLOSED)
(1:125)

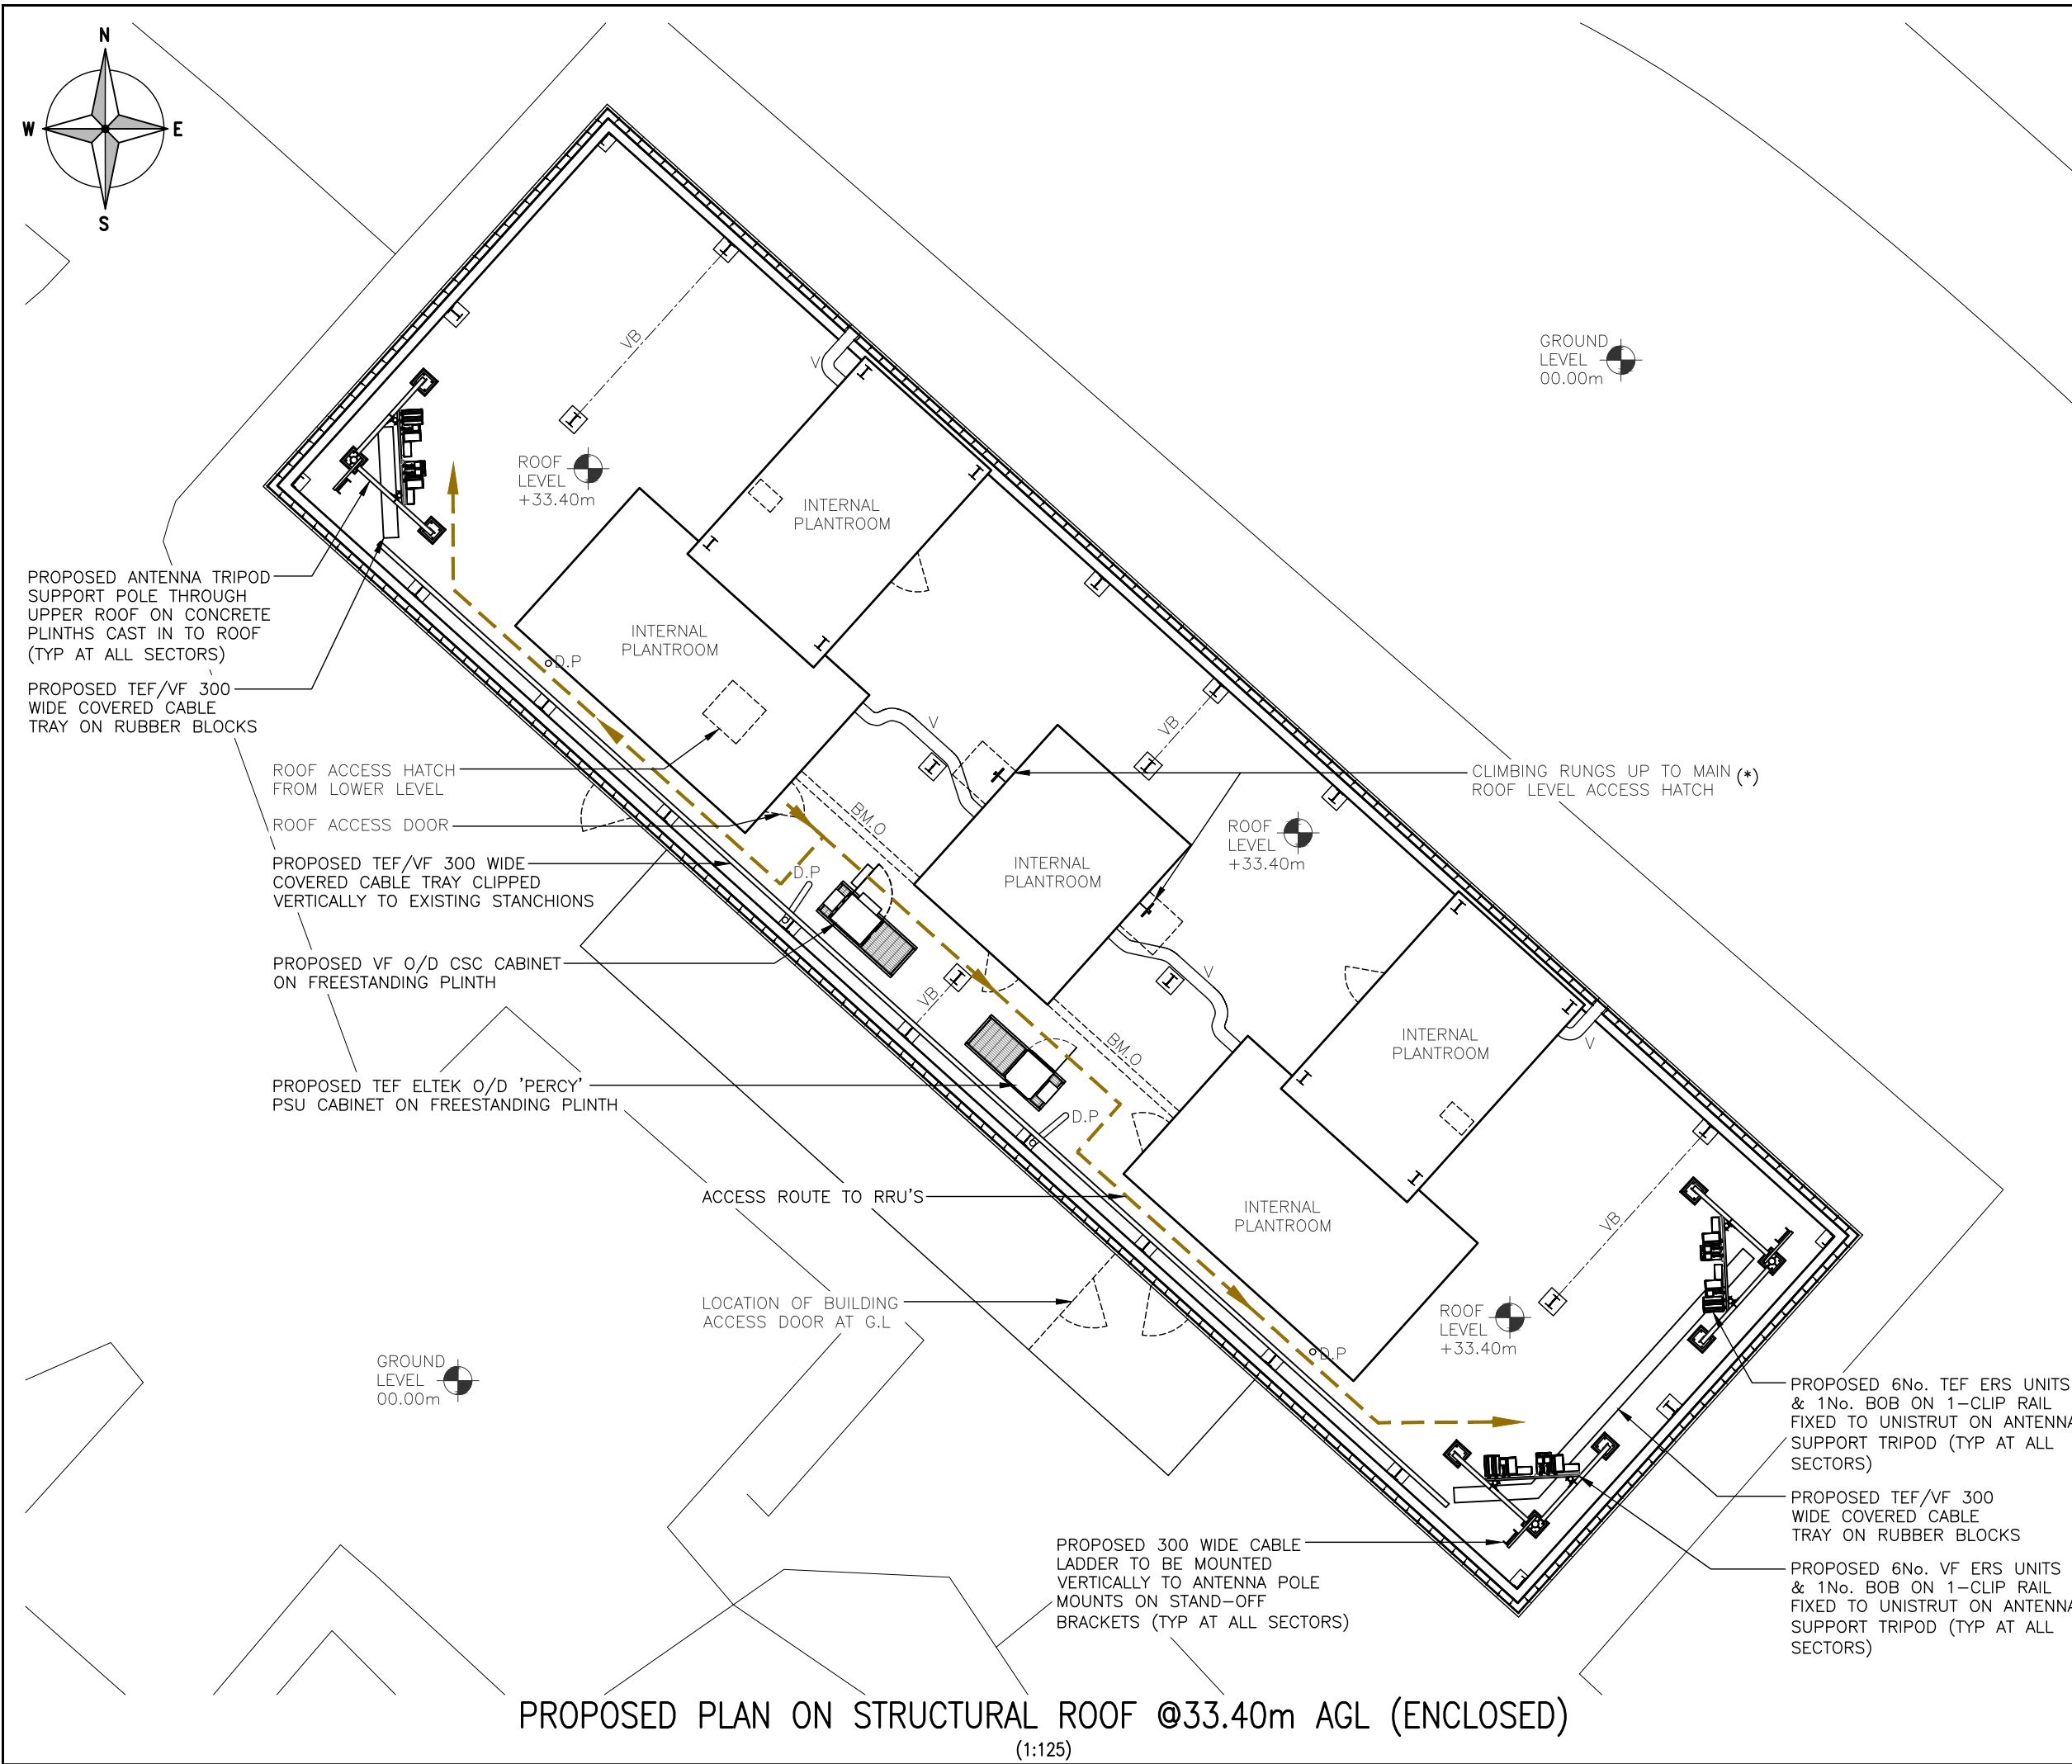

(*) - EXISTING CLIMBING SYSTEMS & HATCHES EXIT ON TO SOLAR PANEL ROOF ARE TO BE MODIFIED/IMPROVED. EXACT DETAILS T.B.C

A	Issued for Approval	A.P	D.W	22.07.21	
REV	MODIFICATION	BY	CH	DATE	



CORNERSTONE - BEACON 3

Cell Name	Op
THOMAS COURT	-

Cell ID No		
CORNERSTONE	TEF	VF
304508_00 E337454	92408	00758

Site Address / Contact Details

BEATTOCK STREET
MANCHESTER
GREATER MANCHESTER
M15 4JA

Drawing Title:
PROPOSED ROOF PLAN @33.40m AGL

Purpose of issue:	PLANNING	Dwg Rev
-------------------	----------	------------


Drawing Number:	203	A
-----------------	-----	---

Surveyed By: D.W	Original Sheet Size: A3	Pack Issue
----------------------------	-----------------------------------	---------------

Drawn:	Date:	Checked:	Date:	A
A.P	22.07.21	D.W	22.07.21	

PROPOSED PLAN ON STRUCTURAL ROOF @33.40m AGL (ENCLOSED)

(1:125)

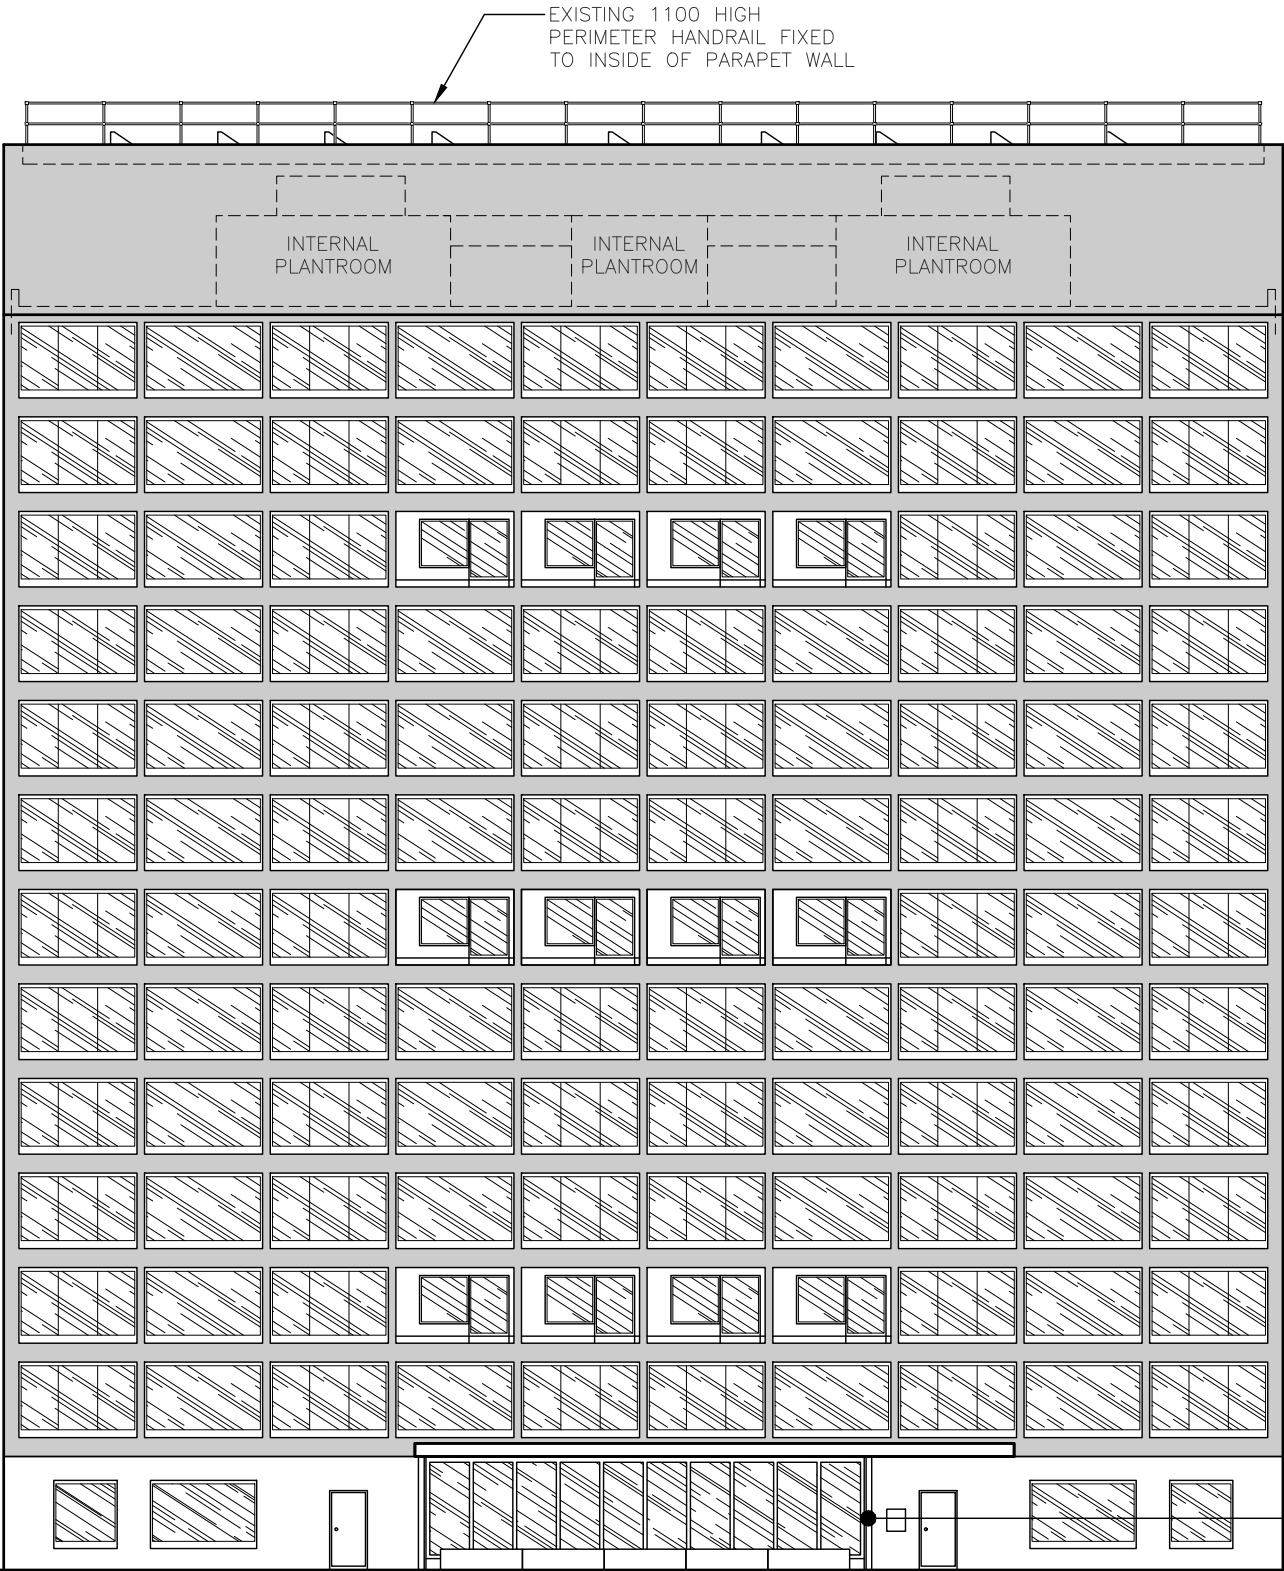

ALL DIMENSIONS ARE IN mm UNLESS NOTED OTHERWISE

N.G.R | E: 382937 N: 397220

NOTES:

A	Issued for Approval	A.P	D.W	22.07.21
REV	MODIFICATION	BY	CH	DATE



Unit E, Madison Place, Northampton Road,
Manchester, M40 5AG
Tel: 0161 785 4500
Fax: 0161 785 4501
Web: www.clarke-telecom.com



CORNERSTONE - BEACON 3

Cell Name	Opt.
THOMAS COURT	–

Cell ID No		
CORNERSTONE	TEF	VF
304508_00 E337454	92408	00758

Site Address / Contact Details

BEATTOCK STREET
MANCHESTER
GREATER MANCHESTER
M15 4JA

Drawing Title: EXISTING SITE ELEVATION				
Purpose of issue: PLANNING				Dwg Rev:
Drawing Number: 300				A
Surveyed By: D.W		Original Sheet Size: A3		Pack Issue:
Drawn: A.P	Date: 22.07.21	Checked: D.W	Date: 22.07.21	A

TOP OF PROPOSED VF/TEF ANTENNAS
+41.30m A.G.L.

U/S OF PROPOSED TEF ANTENNAS
+40.50m A.G.L.

TOP OF PROPOSED VF ANTENNAS
+40.00m A.G.L.

U/S OF PROPOSED VF/TEF ANTENNAS
+39.20m A.G.L.

SOLAR PANEL ROOF LEVEL
+37.20m A.G.L.

STRUCTURAL ROOF LEVEL
(13th FLOOR) +33.40m A.G.L.

TOP FLOOR LEVEL
(12th FLOOR) +30.50m A.G.L.

FLOOR LEVEL
(11th FLOOR) +28.00m A.G.L.

PROPOSED 300 WIDE CABLE
LADDER TO BE MOUNTED
VERTICALLY TO ANTENNA POLE
MOUNTS (TYP AT ALL SECTORS)

PROPOSED TEF/VF METER
CABINET ON CONCRETE PLINTH

G.L.

PROPOSED SAFE TO CLIMB LADDER TO
BE INSTALLED (TYP AT ALL SECTORS)

PROPOSED ROXTEC CABLE
ENTRY GLAND INSTALLED IN
ROOF (TYP AT ALL SECTORS)

EXISTING 1100 HIGH
PERIMETER HANDRAIL FIXED
TO INSIDE OF PARAPET WALL

PROPOSED 2No. TEF No. COMBINERS
FIXED TO CHS SUPPORT POLE BEHIND
ANTENNA (TYP AT ALL SECTORS)

PROPOSED 3No. VF FILTERS FIXED TO
CHS SUPPORT POLE BEHIND ANTENNA
(TYP AT ALL SECTORS)

PROPOSED 2No. TEF & 2No. VF
ANTENNAS ON NEW STAND-OFF
BRACKETS FIXED TO ANTENNA TRIPOD
SUPPORT POLE THROUGH UPPER
ROOF ON CONCRETE PLINTHS CAST
IN TO ROOF (TYP AT ALL SECTORS)

TOP OF PARAPET
+37.70m A.G.L.

PROPOSED 6No. VF ERS UNITS &
1No. BOB ON 1-CLIP RAIL FIXED
TO UNISTRUT ON ANTENNA SUPPORT
TRIPOD (TYP AT ALL SECTORS)

PROPOSED 6No. TEF ERS UNITS &
1No. BOB ON 1-CLIP RAIL FIXED
TO UNISTRUT ON ANTENNA SUPPORT
TRIPOD (TYP AT ALL SECTORS)

PROPOSED TEF ELTEK O/D 'PERCY'
PSU CABINET ON FREESTANDING PLINTH

PROPOSED VF O/D CSC CABINET
ON FREESTANDING PLINTH

LOCATION OF BUILDING ACCESS DOOR

PROPOSED SOUTH WEST (FRONT) ELEVATION
(1:200)

ALL DIMENSIONS ARE IN mm UNLESS NOTED OTHERWISE

N.G.R | E: 382937 N: 397220

NOTES:

NOTE:- ALL STEELWORK IS TO BE
DESIGNED TO BE MAN HANDLED UP
TO ROOF LEVELS AND EQUIPMENT
TO BE FLAT PACK TYPE

A	Issued for Approval	A.P	D.W	22.07.21
REV	MODIFICATION	BY	CH	DATE

CLARKE
telecom
Unit E, Madison Place, Northampton Road,
Manchester, M40 5AG
Tel: 0161 785 4500
Fax: 0161 785 4501
Web: www.clarke-telecom.com

O₂

CORNERSTONE - BEACON 3

Cell Name	Opt.
THOMAS COURT	-

Cell ID No		
CORNERSTONE	TEF	VF
304508_00 E337454	92408	00758

Site Address / Contact Details

BEATTOCK STREET
MANCHESTER
GREATER MANCHESTER
M15 4JA

Drawing Title: PROPOSED SITE ELEVATION				
Purpose of issue: PLANNING				Dwg Rev:
Drawing Number: 301				A
Surveyed By: D.W		Original Sheet Size: A3		Pack Issue:
Drawn: A.P	Date: 22.07.21	Checked: D.W	Date: 22.07.21	A

The drawings comply with TEF & Vodafone Standard ICNIRP guidelines.
Designed in accordance with CORNERSTONE document: SDN0008