




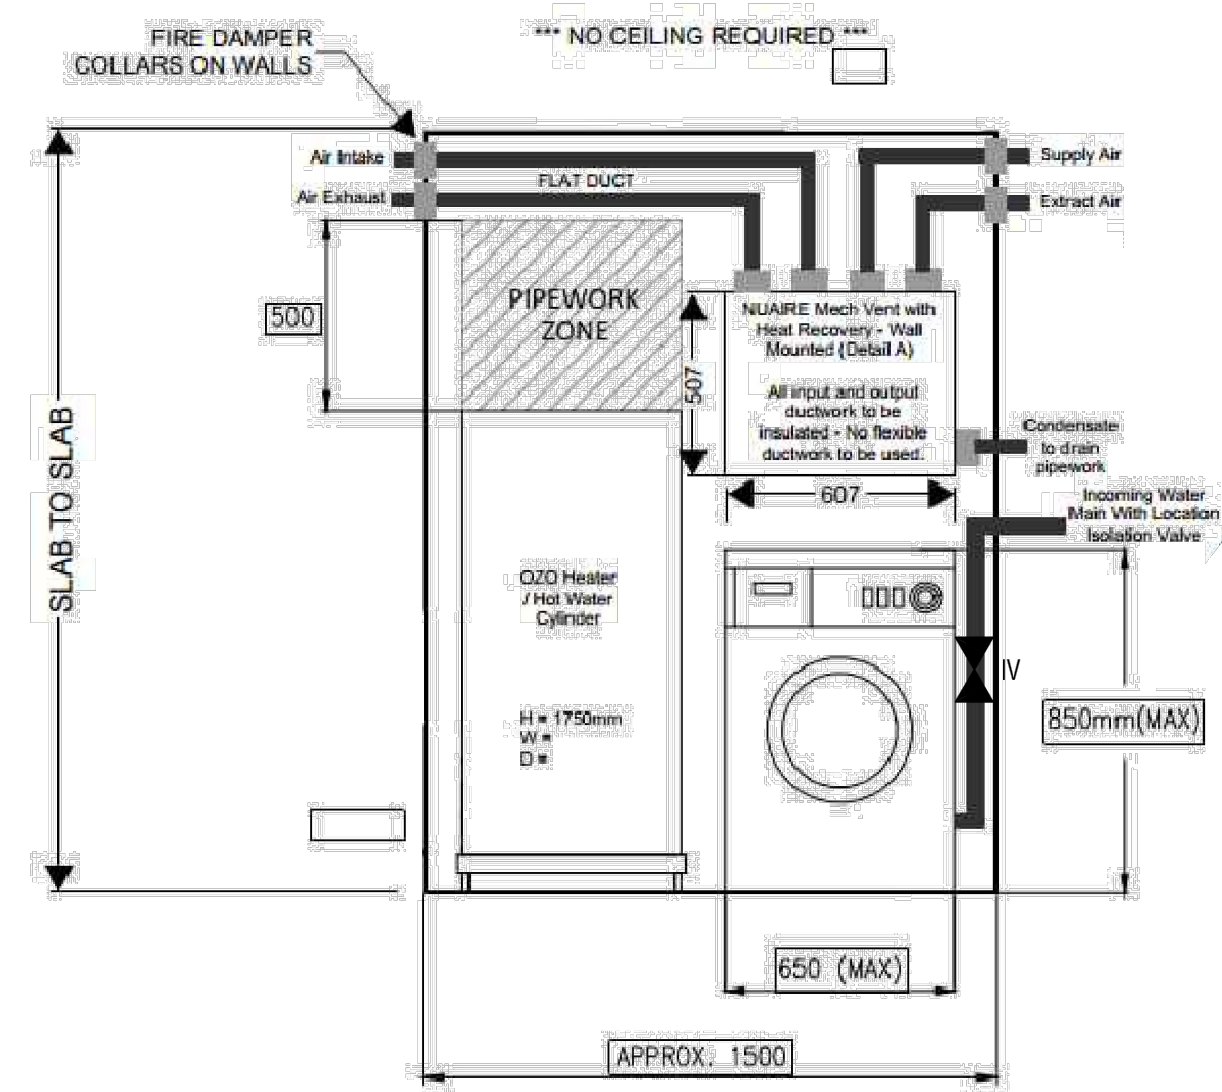


DETAIL
WATER / MECH RISER CUPBOARD
NTS

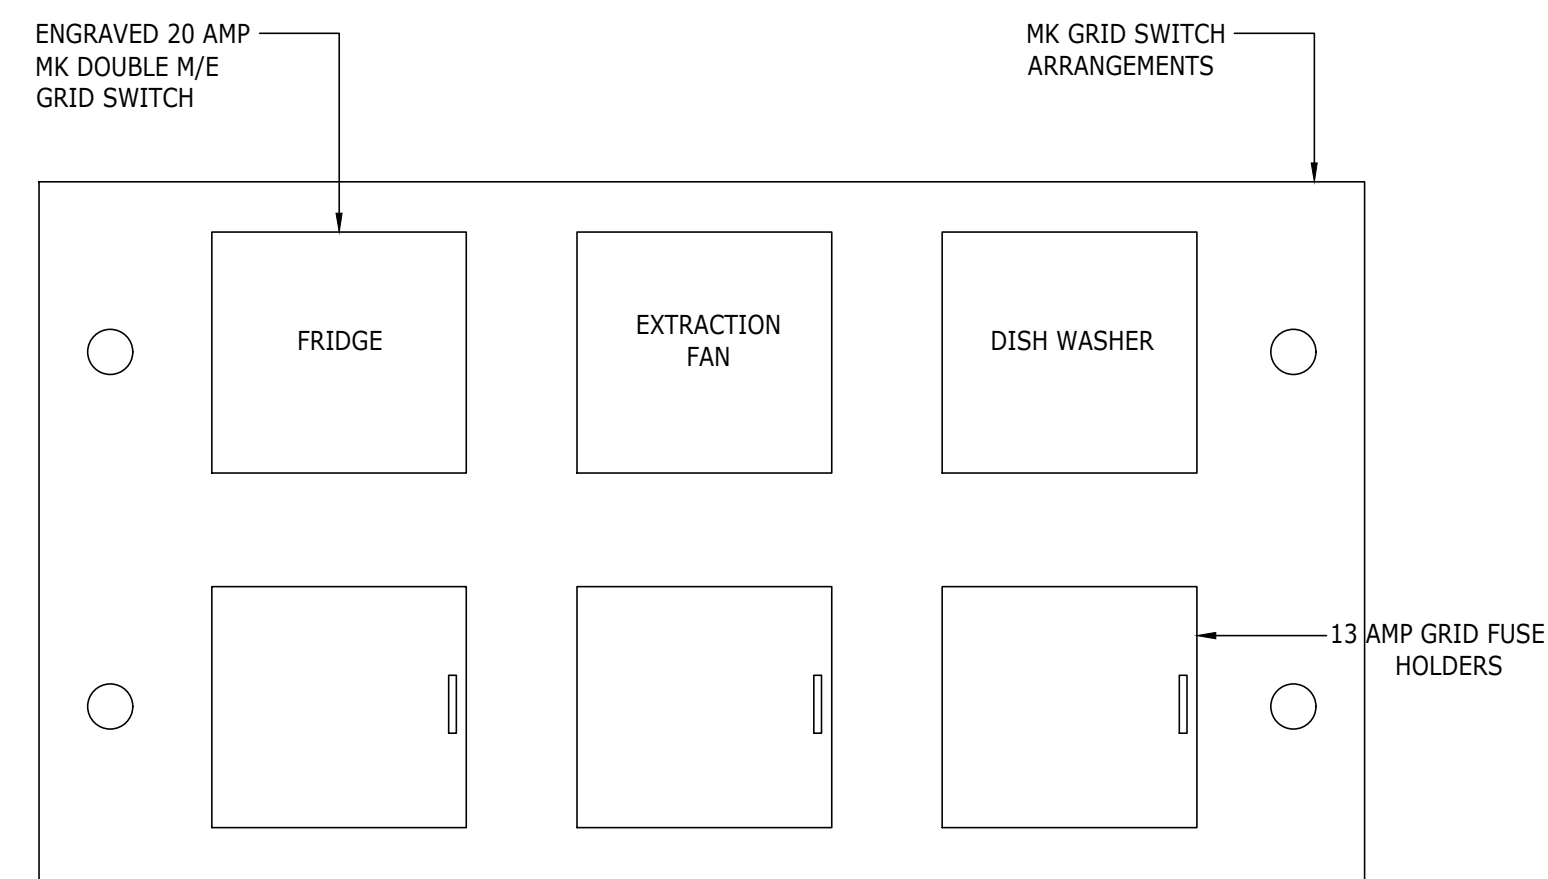

TYPICAL DETAIL
KITCHEN APPLIANCE GRID SWITCH

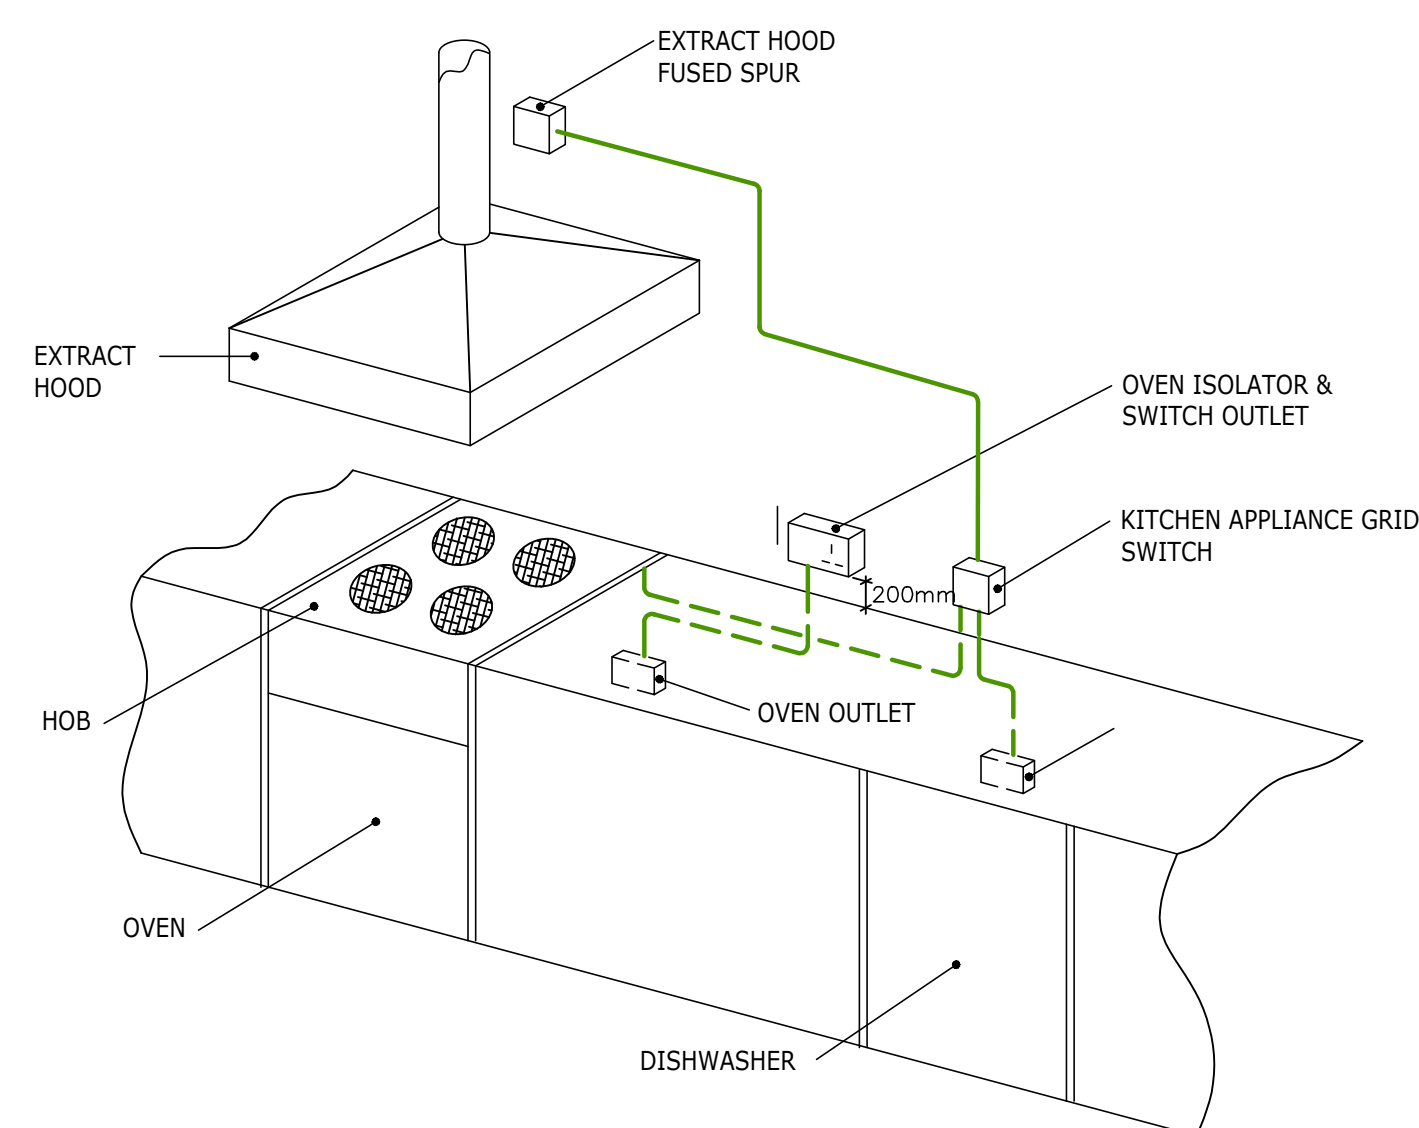

KITCHEN OUTLETS DETAIL (NTS)

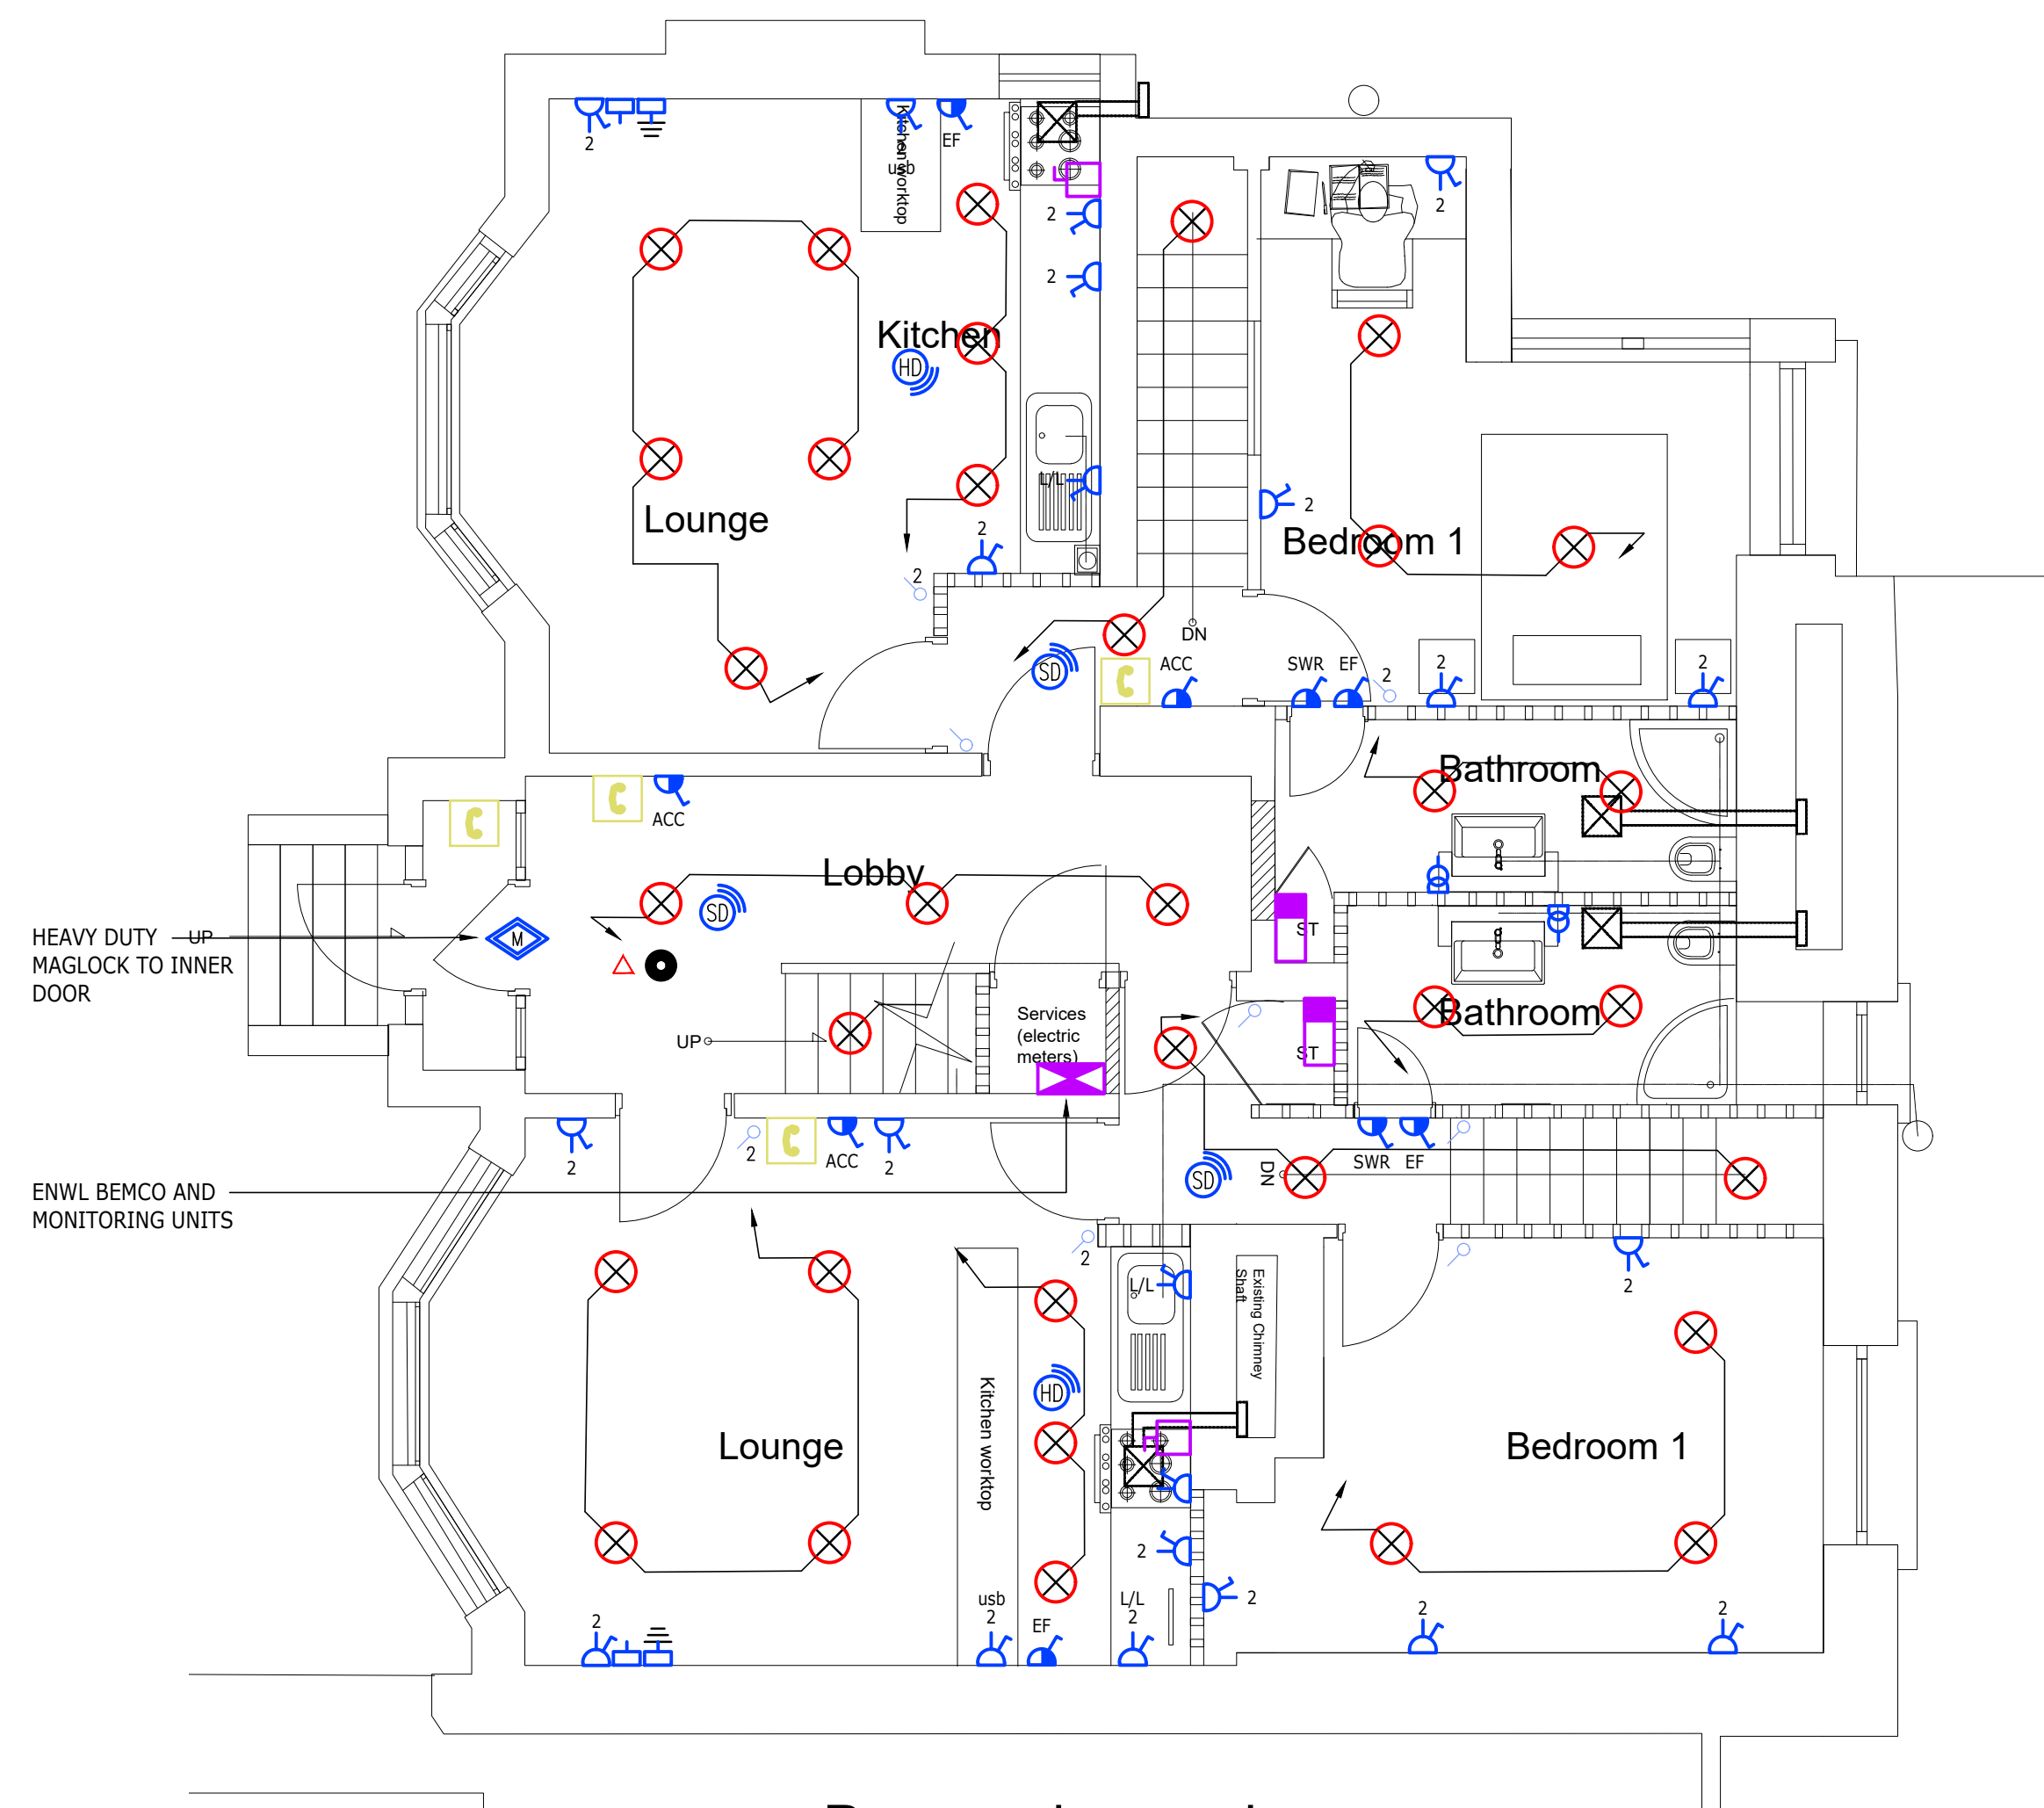

Proposed ground
floor

SMALL POWER LEGEND

- COOKER ISOLATOR
- SHAVER SOCKET
- SINGLE SWITCHED SOCKET OUTLET '2' DENOTES TWIN
- SWITCHED FUSED SPUR
- DISTRIBUTION BOARD
- DATA POINT
- TELEPHONE/INTERCOM POINT
- STAND-ALONE DOMESTIC WIRED HEAT DETECTOR/ALARM
- STAND-ALONE DOMESTIC WIRED SMOKE DETECTOR/ALARM
- INTERCOM
- MK APPLIANCE GRID SWITCH

LIGHTING LEGEND

- CEILING MOUNTED LED LIGHT FITTING
- CEILING MOUNTED LED LIGHT FITTING WITH EMERGENCY
- WALL MOUNTED LIGHT FITTING
- LED STRIP LIGHTING
- LIGHT SWITCH 'n' DENOTES No. OF GANGS
- 360° CEILING MOUNTED OCCUPANCY SENSOR
- LED WALL LIGHT c/w EMERGENCY
- EMERGENCY EXIT (LED)
- TV OUTLET

KEY

- OV OVEN
- EF EXTRACT FAN
- WD WASHER/DRYER
- HWC HOT WATER CYLINDER
- LL LOW LEVEL
- HL HIGH LEVEL
- SM SURFACE MOUNTED
- PT PENDANT FITTING
- PH PANEL HEATER
- WT WORKTOP MOUNTED
- SWR SHOWER
- HB HOB
- HD EXTRACT HOOD
- UC UNDERCOUNTER SOCKET
- ACC ACCESS CONTROL





GENERAL NOTES

- 1.00 THIS DRAWING IS SUBJECT TO COPYRIGHT AND IS NOT TO BE REPRODUCED IN PART OR WHOLE WITHOUT APPROVAL.
- 2.00 DO NOT SCALE THIS DRAWING. CHECK ALL DIMENSIONS ON SITE.
- 3.00 THIS DRAWING SHALL BE READ IN CONJUNCTION WITH THE PROJECT SPECIFICATION(S) AND ALL OTHER CONTRACT DOCUMENTATION.
- 4.00 ALL DIMENSIONS ARE IN MILLIMETERS UNLESS OTHERWISE STATED.

SMALL POWER & LIGHTING NOTES

- 1.00 DRAWINGS MUST BE READ IN CONJUNCTION WITH MECHANICAL DRAWINGS.
- 2.00 MANUAL DIMMING TO LIGHTING IN LIVING AREAS.
- 3.00 DATA & TV POINTS TO BE HAGER JOINT PLATE (BEDROOMS - SINGLES, LOUNGES - DOUBLES).
- 4.00 THE LIGHTING TYPE WITHIN ALL APARTMENTS IS SUBJECT TO CONTRACTOR/CLIENT REVIEW, BEFORE RECESSED FITTINGS ARE AGREED.
- 5.00 KITCHEN LAYOUTS ARE INDICATIVE ONLY. LIGHTING, SOCKETS AND ISOLATORS ARE ALL SUBJECT TO CONTRACTOR AND CLIENT COORDINATION.
- 6.00 WHERE POSSIBLE, ALL SERVICES SHOULD BE CONCEALED. THE ROUTING OF SERVICES SHOULD BE COORDINATED WITH DUCTING, DCHW SERVICES, BUILDING FABRIC AND STEEL WORK.
- 7.00 ALL SWITCHES AND SOCKETS ARE TO BE DECORATIVE BRUSHED FINISH.

Rev	Date	Revision	BB	DM	
			Drawn	Ck'd	
Client					
TERATT LTD					
Project					
2 SWINBOURNE GROVE WITHINGTON					
Drawing Title					
GROUND FLOOR SMALL POWER & LIGHTING LAYOUT					
 McKee Associates Ltd Unity House Westwood Park Wigan WN3 4HE Web : www.mckeeassociates.co.uk Tel : 01942 918 145					
Cad Drawn	BB	Date	JULY 2021	Scale	1:50@ (A1)
Checked	DM	Date	JULY 2021	Rev.	P1
Dwg No :		P2121 - 62 -001			

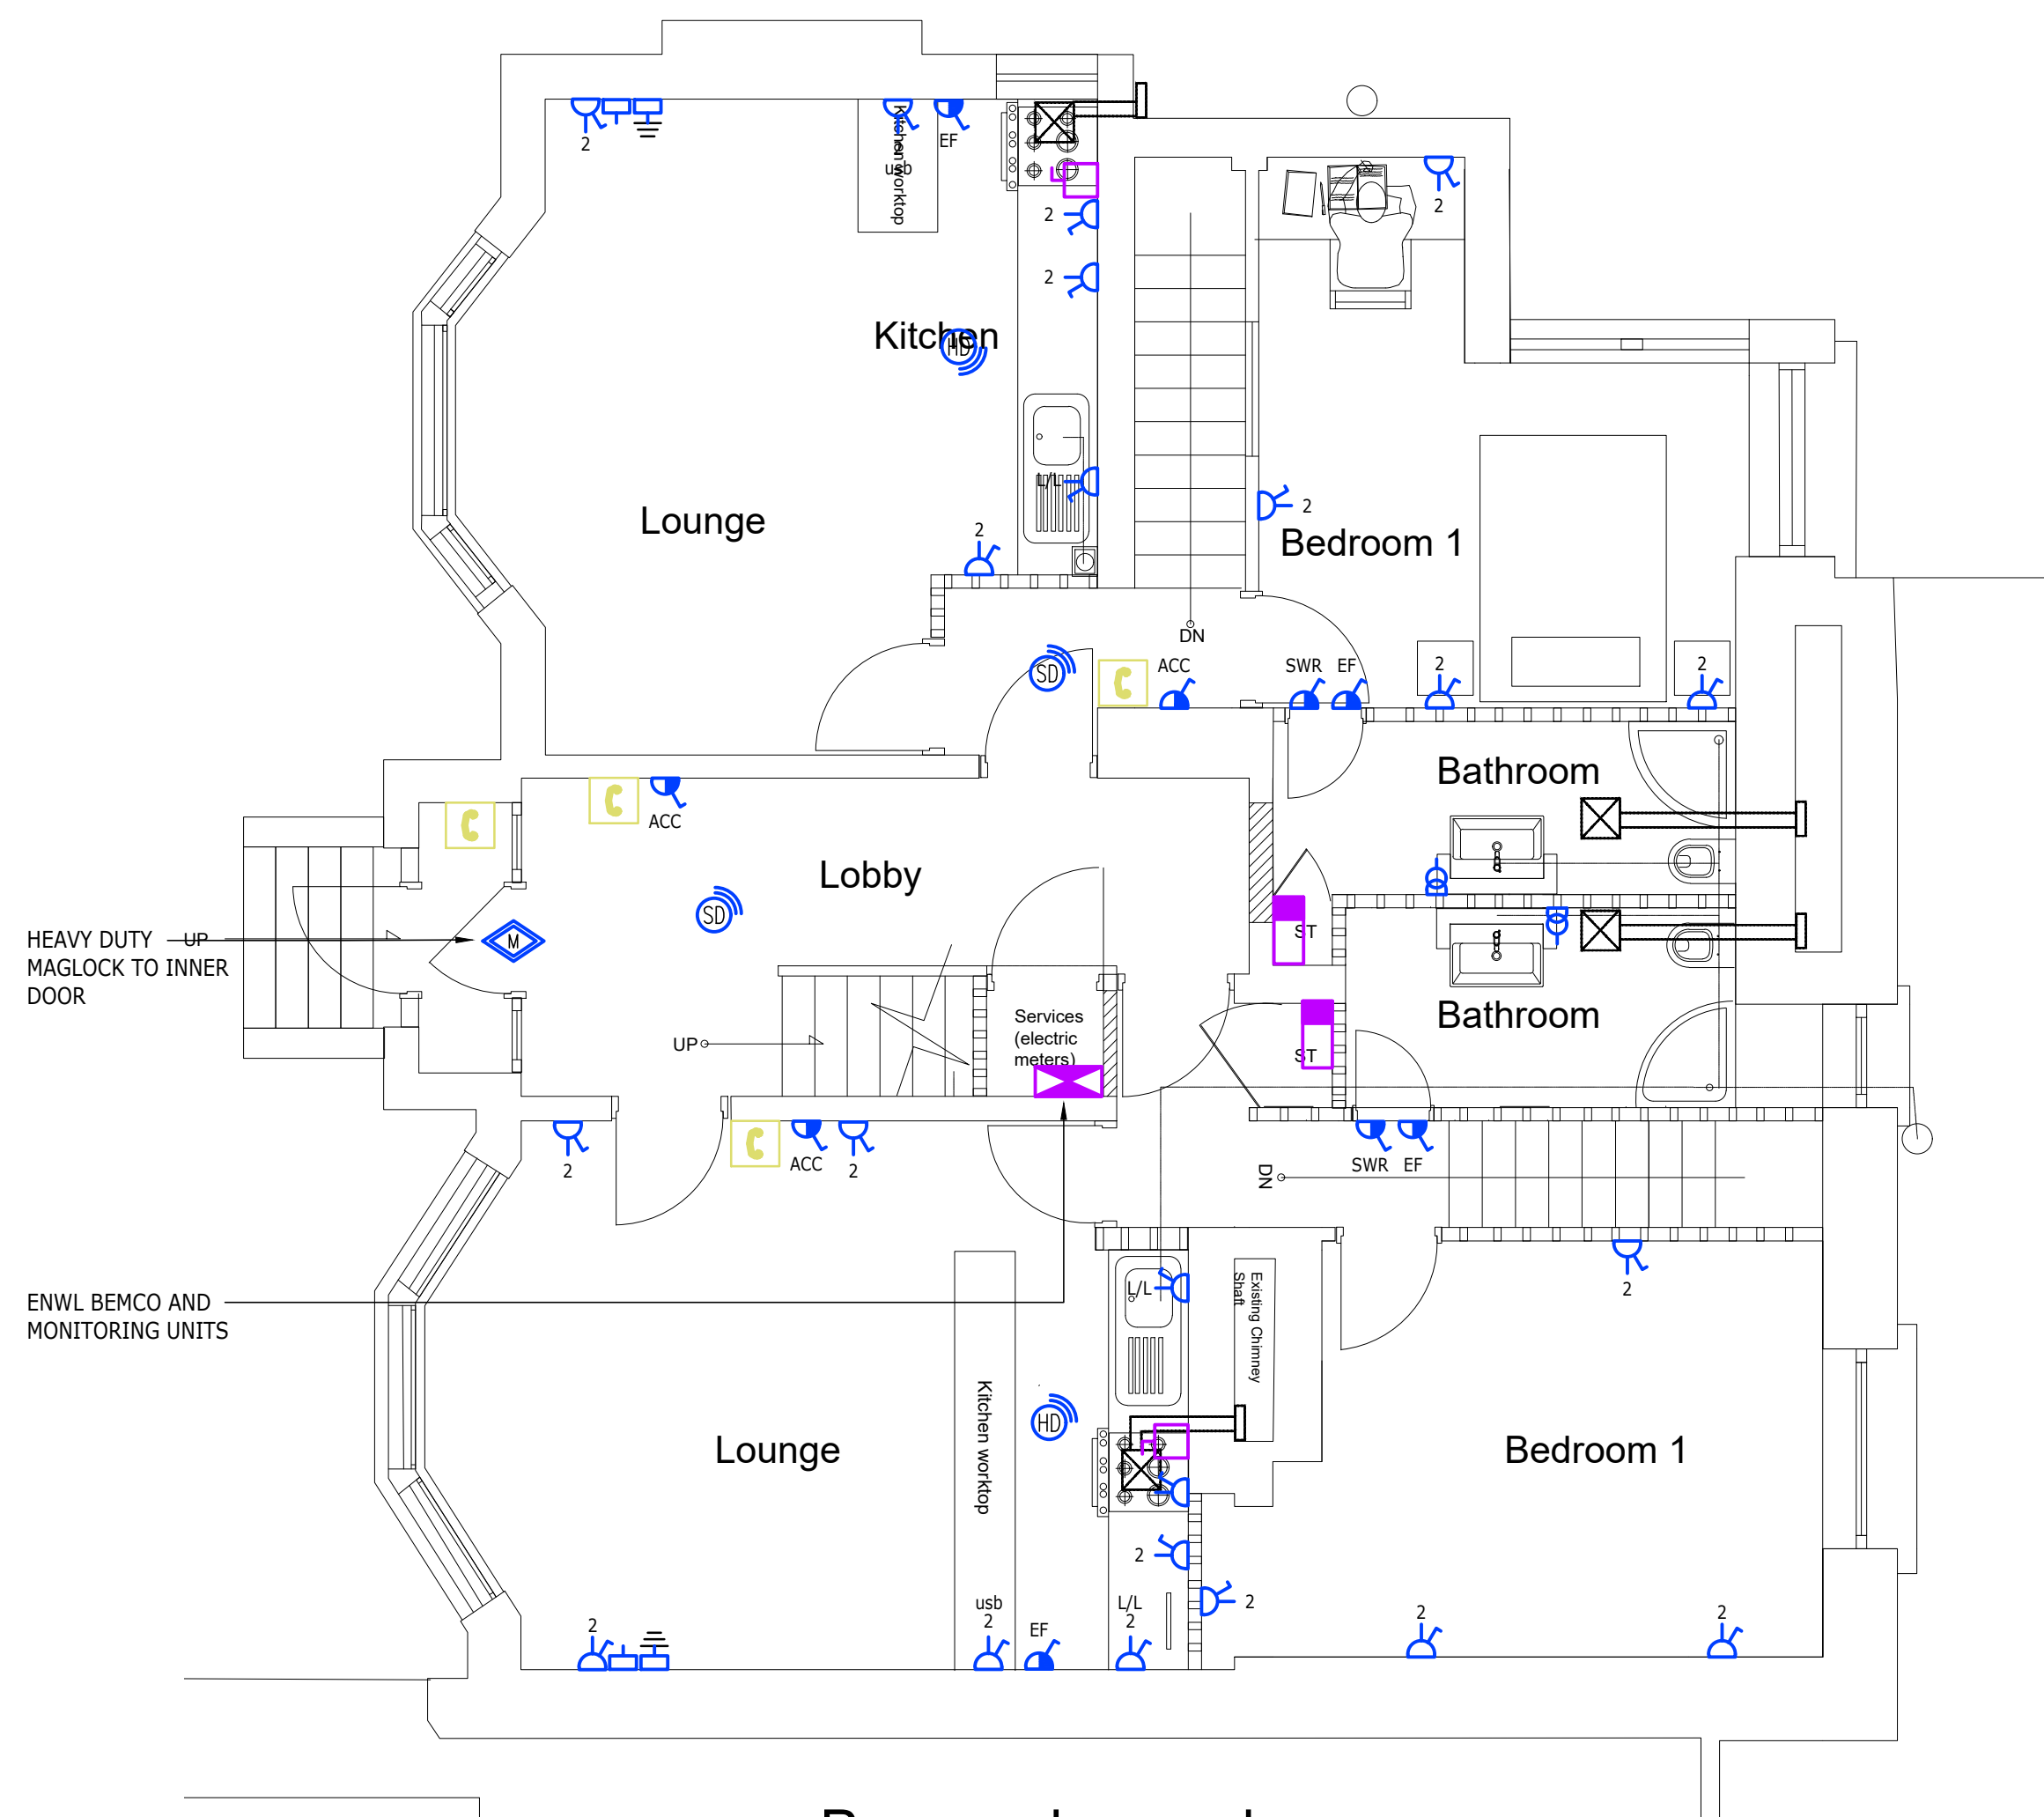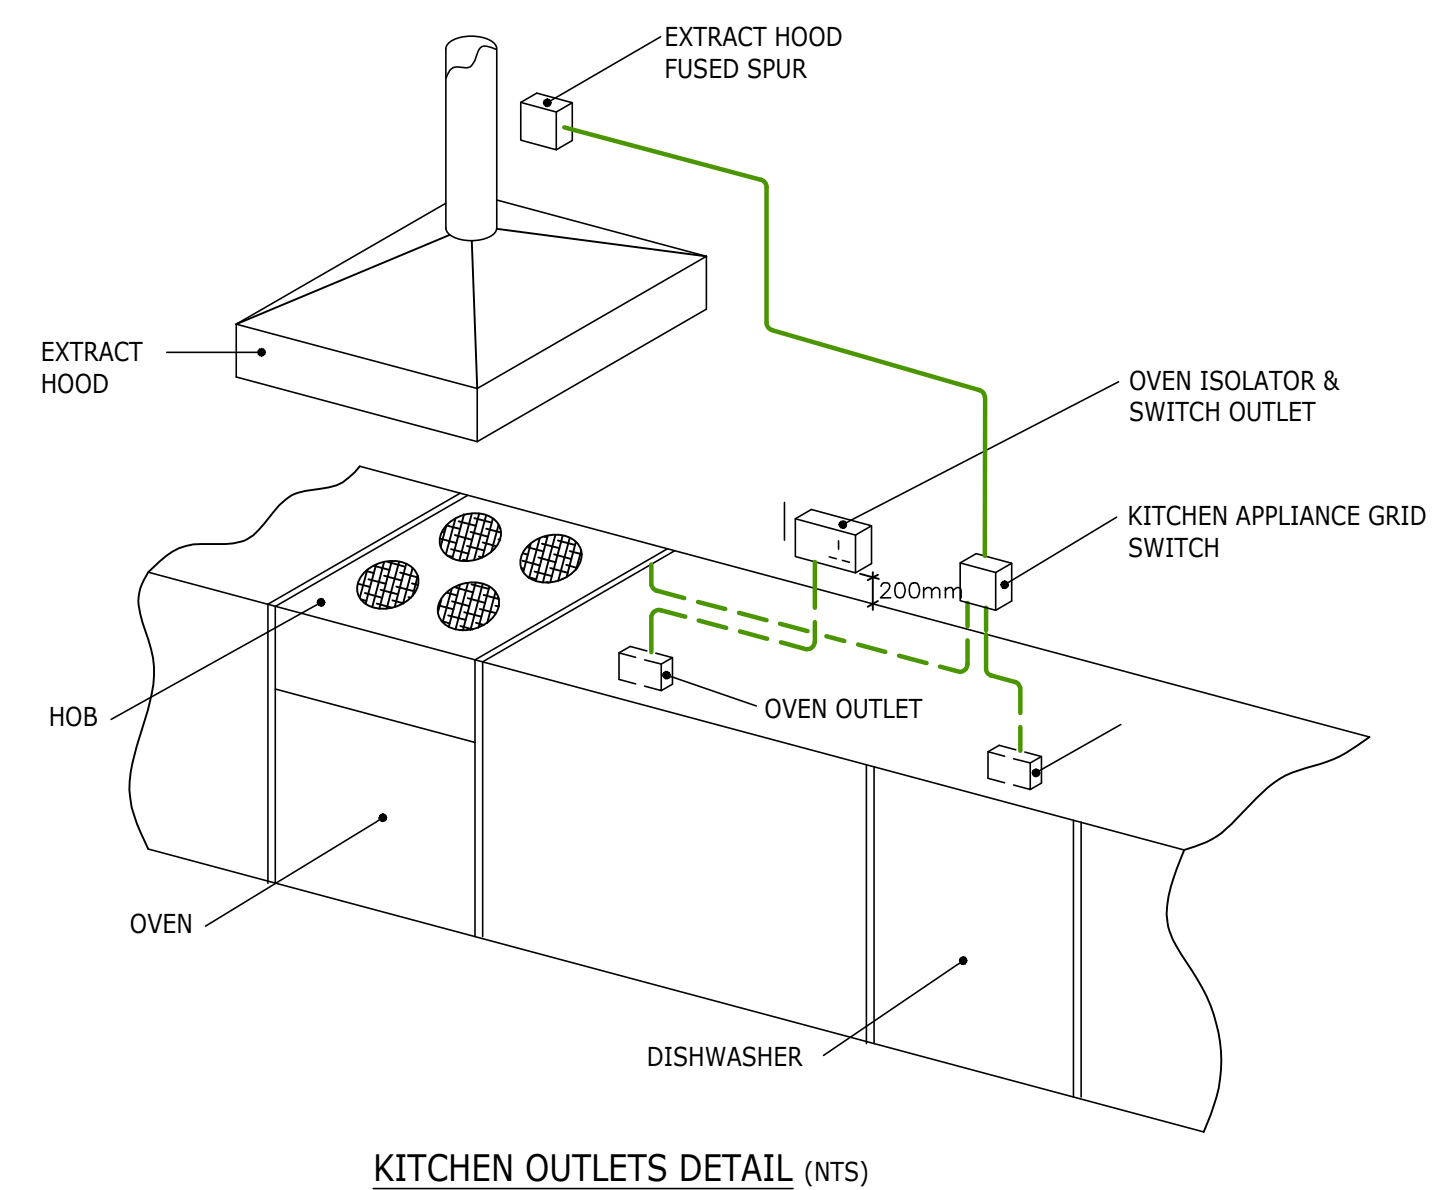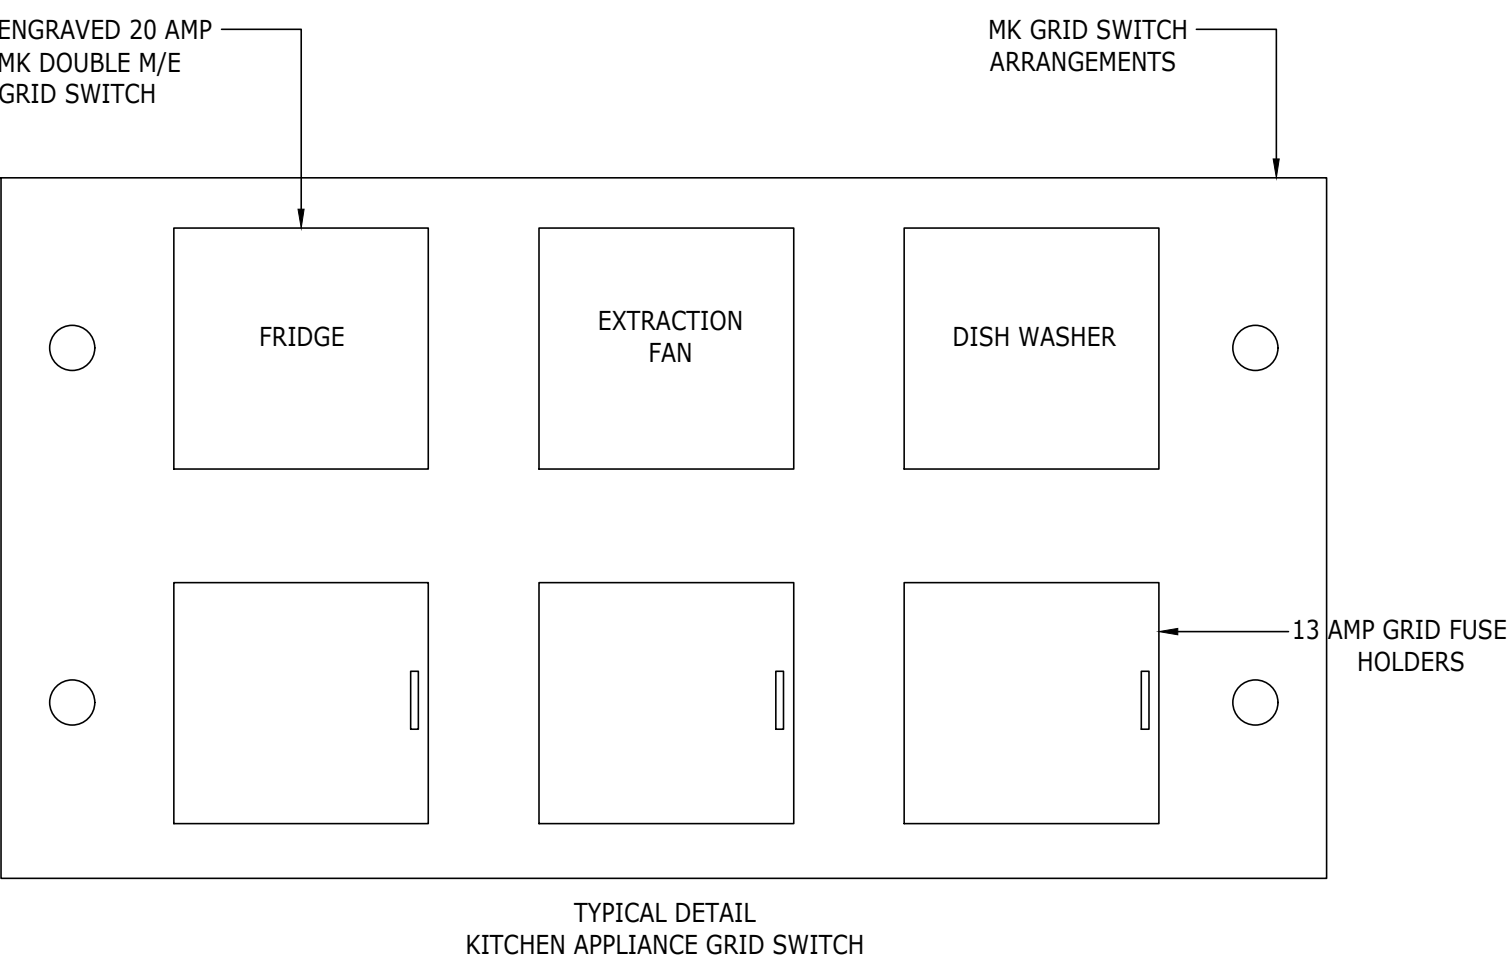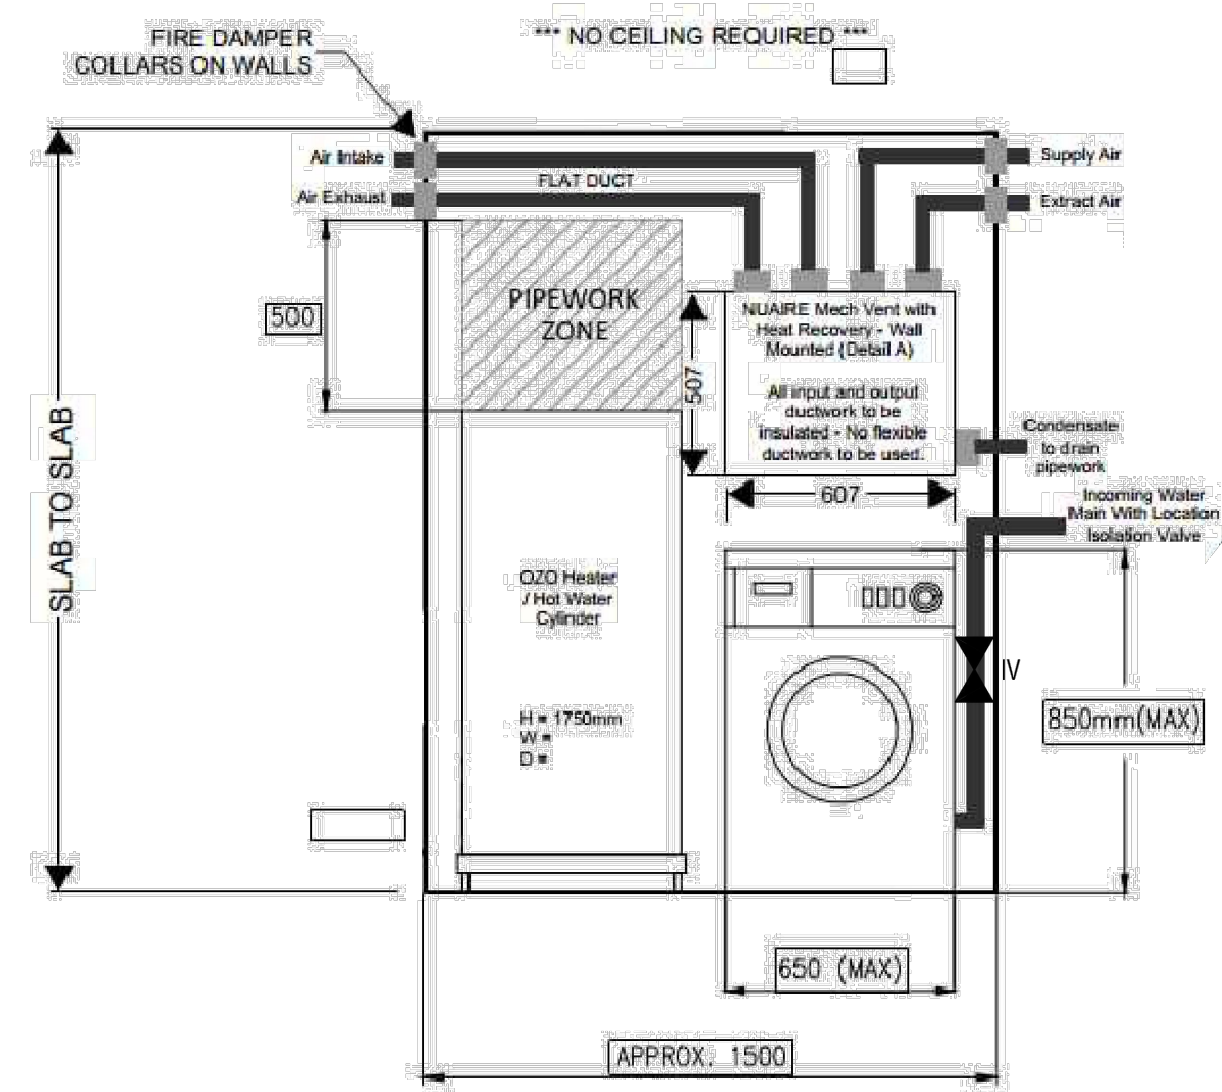

Flat 1:
2 Bedroom Flat
Area: 87.8 m²

Flat 2:

SMALL POWER LEGEND

- COOKER ISOLATOR
- SHAVER SOCKET
- SINGLE SWITCHED SOCKET OUTLET
- '2' DENOTES TWIN
- SWITCHED FUSED SPUR
- DISTRIBUTION BOARD
- DATA POINT
- TELEPHONE/INTERCOM POINT
- STAND-ALONE DOMESTIC WIRED HEAT DETECTOR/ALARM
- STAND-ALONE DOMESTIC WIRED SMOKE DETECTOR/ALARM
- INTERCOM
- MK APPLIANCE GRID SWITCH

LIGHTING LEGEND

- CEILING MOUNTED LED LIGHT FITTING
- CEILING MOUNTED LED LIGHT FITTING WITH EMERGENCY
- WALL MOUNTED LIGHT FITTING
- LED STRIP LIGHTING
- LIGHT SWITCH 'n' DENOTES No. OF GANGS
- 360° CEILING MOUNTED OCCUPANCY SENSOR
- LED WALL LIGHT c/w EMERGENCY
- EMERGENCY EXIT (LED)
- TV OUTLET

KEY

- OV OVEN
- EF EXTRACT FAN
- WD WASHER/DRYER
- HWC HOT WATER CYLINDER
- LL LOW LEVEL
- HL HIGH LEVEL
- SM SURFACE MOUNTED
- PT PENDANT FITTING
- PH PANEL HEATER
- WT WORKTOP MOUNTED
- SWR SHOWER
- HB HOB
- HD EXTRACT HOOD
- UC UNDERCOUNTER SOCKET
- ACC ACCESS CONTROL


GENERAL NOTES

- 1.00 THIS DRAWING IS SUBJECT TO COPYRIGHT AND IS NOT TO BE REPRODUCED IN PART OR WHOLE WITHOUT APPROVAL.
- 2.00 DO NOT SCALE THIS DRAWING. CHECK ALL DIMENSIONS ON SITE.
- 3.00 THIS DRAWING SHALL BE READ IN CONJUNCTION WITH THE PROJECT SPECIFICATION(S) AND ALL OTHER CONTRACT DOCUMENTATION.
- 4.00 ALL DIMENSIONS ARE IN MILLIMETERS UNLESS OTHERWISE STATED.


SMALL POWER & LIGHTING NOTES

- 1.00 DRAWINGS MUST BE READ IN CONJUNCTION WITH MECHANICAL DRAWINGS.
- 2.00 MANUAL DIMMING TO LIGHTING IN LIVING AREAS.
- 3.00 DATA & TV POINTS TO BE HAGER JOINT PLATE (BEDROOMS - SINGLES, LOUNGES - DOUBLES).
- 4.00 THE LIGHTING TYPE WITHIN ALL APARTMENTS IS SUBJECT TO CONTRACTOR/CLIENT REVIEW, BEFORE RECESSED FITTINGS ARE AGREED.
- 5.00 KITCHEN LAYOUTS ARE INDICATIVE ONLY. LIGHTING, SOCKETS AND ISOLATORS ARE ALL SUBJECT TO CONTRACTOR AND CLIENT COORDINATION.
- 6.00 WHERE POSSIBLE, ALL SERVICES SHOULD BE CONCEALED. THE ROUTING OF SERVICES SHOULD BE COORDINATED WITH DUCTING, DCHW SERVICES, BUILDING FABRIC AND STEEL WORK.
- 7.00 ALL SWITCHES AND SOCKETS ARE TO BE DECORATIVE BRUSHED FINISH.


Rev	Date	Revision	BB	DM	
			Drawn	Ck'd	
Client					
TERATT LTD					
Project					
2 SWINBOURNE GROVE WITHINGTON					
Drawing Title					
GROUND FLOOR SMALL POWER LAYOUT					
 McKee Associates Ltd Unity House Westwood Park Wigan WN3 4HE Web : www.mckeeassociates.co.uk Tel : 01942 918 145					
Cad Drawn	BB	Date	JULY 2021	Scale	1:50@A1)
Checked	DM	Date	JULY 2021	Rev.	P1
Dwg No :		P2121 - 62 -001			

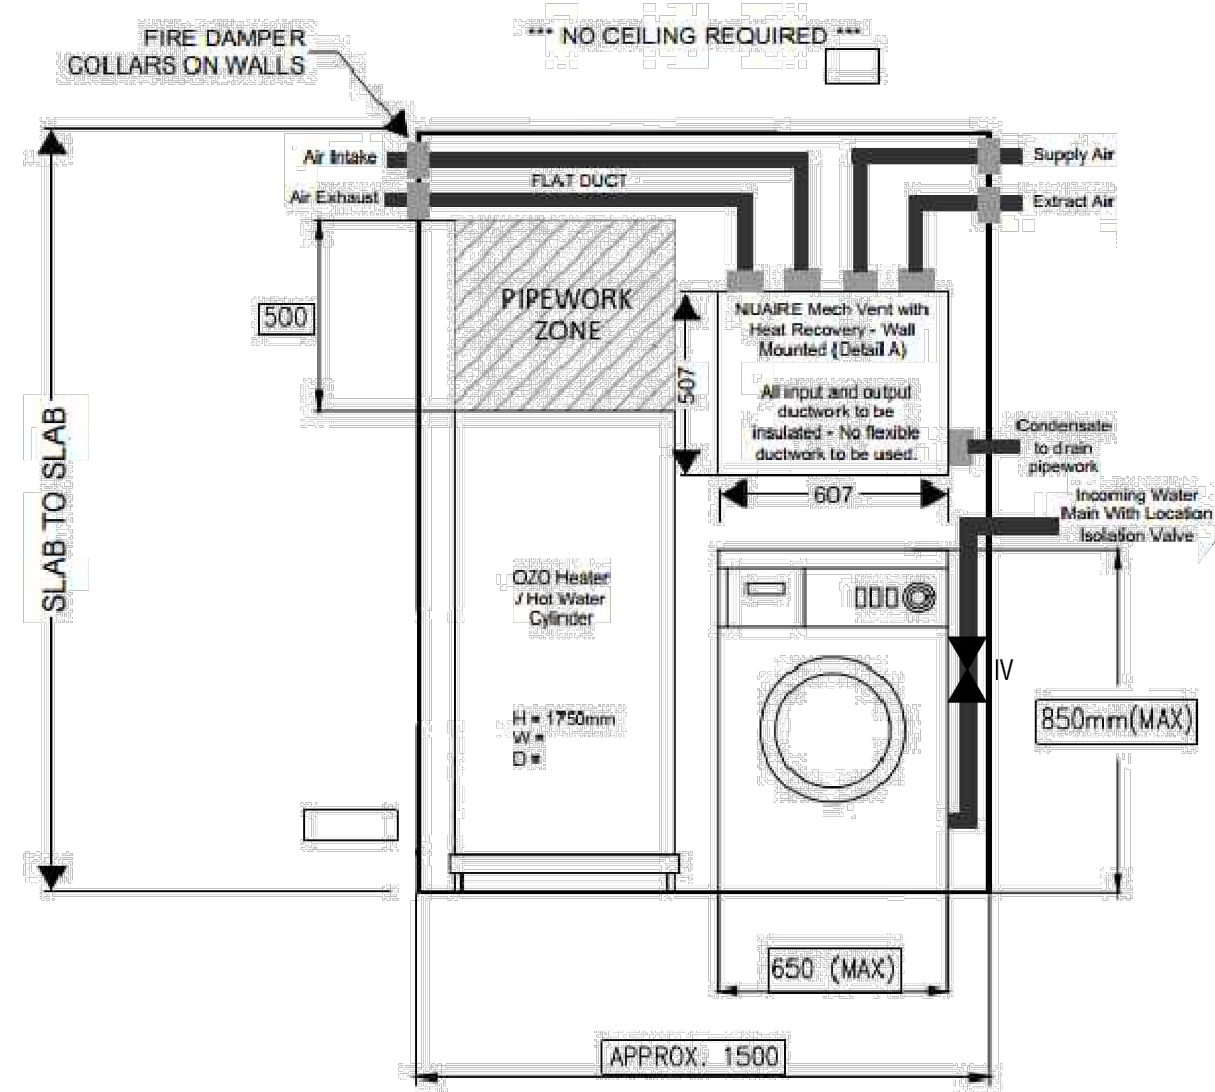


DETAIL
WATER / MECH RISER CUPBOARD
NTS

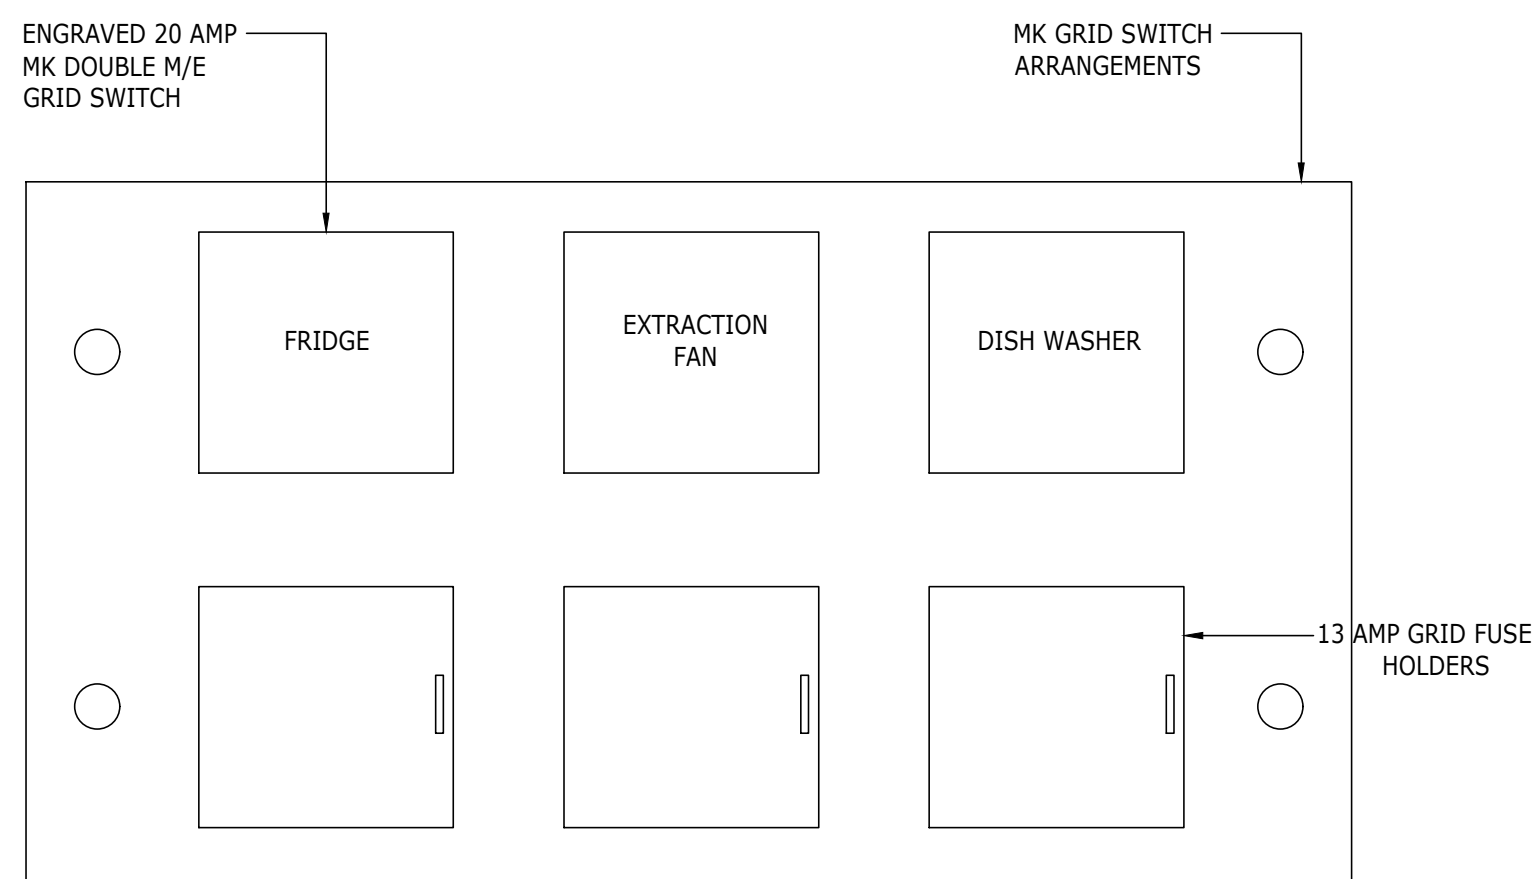

TYPICAL DETAIL
KITCHEN APPLIANCE GRID SWITCH

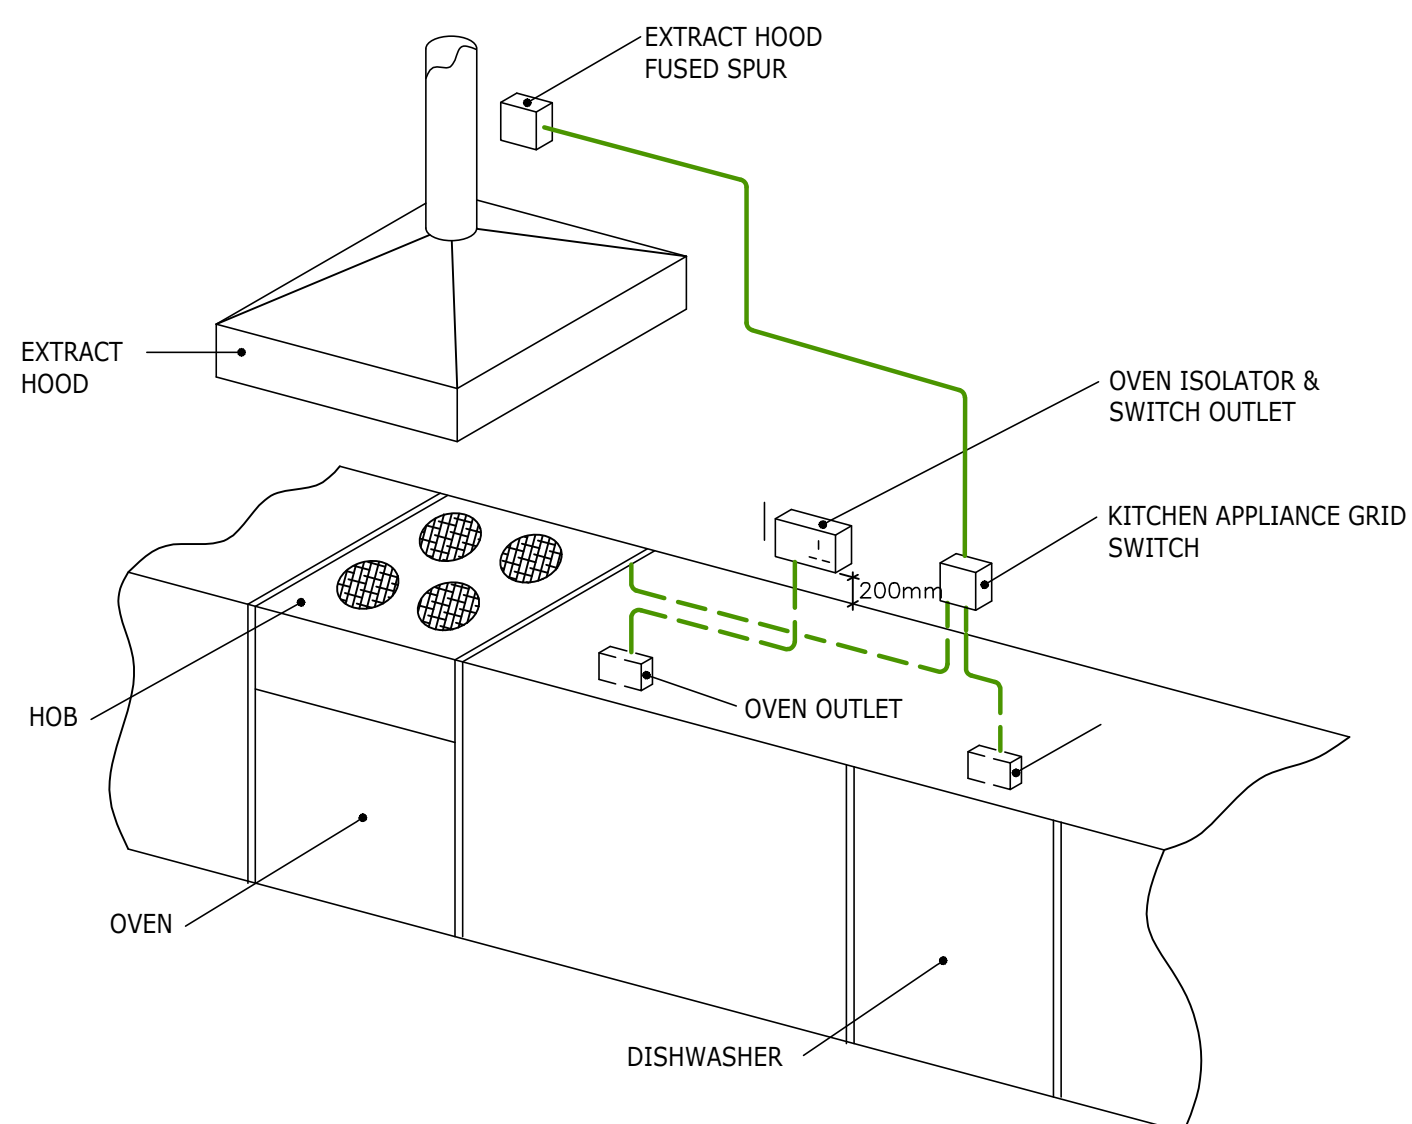

KITCHEN OUTLETS DETAIL (NTS)

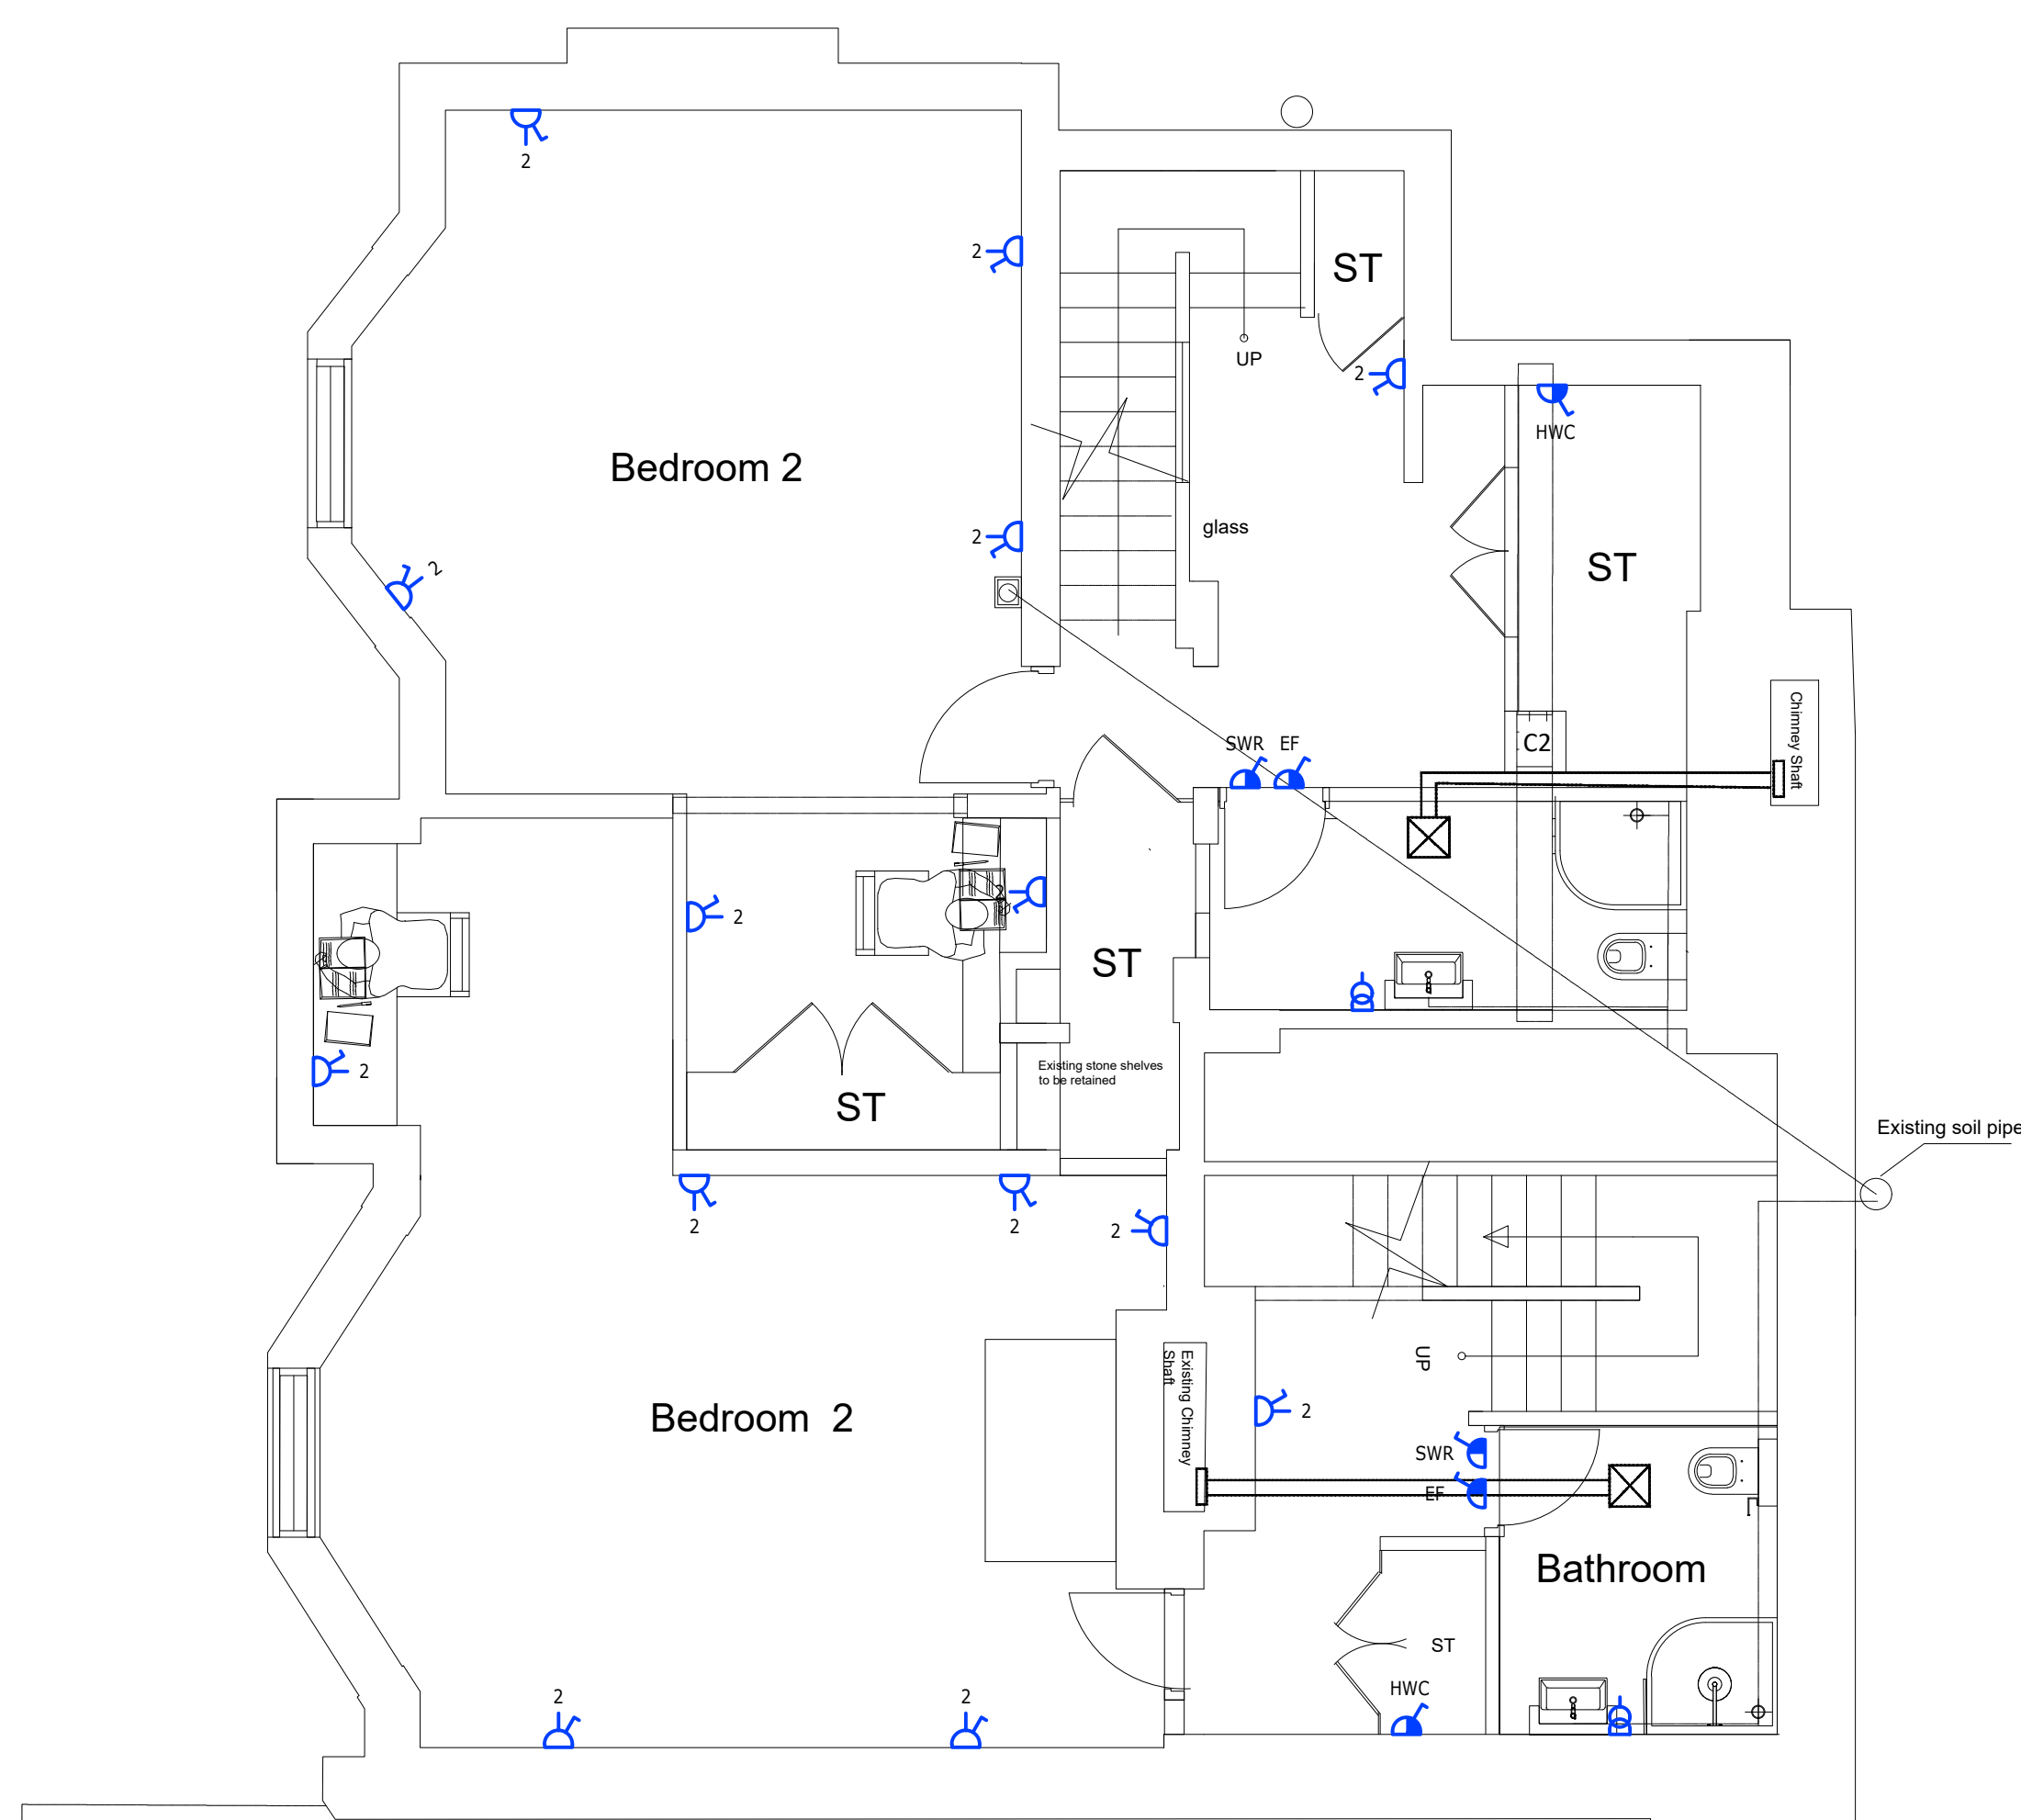

Proposed basement

Flat 1:
2 Bedroom Flat
Area: 87.8 m²

Flat 2:
1 Bedroom Flat

SMALL POWER LEGEND

- COOKER ISOLATOR
- SHAVER SOCKET
- SINGLE SWITCHED SOCKET OUTLET
- '2' DENOTES TWIN
- SWITCHED FUSED SPUR
- DISTRIBUTION BOARD
- DATA POINT
- TELEPHONE/INTERCOM POINT
- STAND-ALONE DOMESTIC WIRED HEAT DETECTOR/ALARM
- STAND-ALONE DOMESTIC WIRED SMOKE DETECTOR/ALARM
- INTERCOM
- MK APPLIANCE GRID SWITCH

LIGHTING LEGEND

- CEILING MOUNTED LED LIGHT FITTING
- CEILING MOUNTED LED LIGHT FITTING WITH EMERGENCY
- WALL MOUNTED LIGHT FITTING
- LED STRIP LIGHTING
- LIGHT SWITCH 'n' DENOTES No. OF GANGS
- 360° CEILING MOUNTED OCCUPANCY SENSOR
- LED WALL LIGHT c/w EMERGENCY
- EMERGENCY EXIT (LED)
- TV OUTLET

KEY

- OV OVEN
- EF EXTRACT FAN
- WD WASHER/DRYER
- HWC HOT WATER CYLINDER
- LL LOW LEVEL
- HL HIGH LEVEL
- SM SURFACE MOUNTED
- PT PENDANT FITTING
- PH PANEL HEATER
- WT WORKTOP MOUNTED
- SWR SHOWER
- HB HOB
- HD EXTRACT HOOD
- UC UNDERCOUNTER SOCKET
- ACC ACCESS CONTROL


GENERAL NOTES

- THIS DRAWING IS SUBJECT TO COPYRIGHT AND IS NOT TO BE REPRODUCED IN PART OR WHOLE WITHOUT APPROVAL.
- DO NOT SCALE THIS DRAWING. CHECK ALL DIMENSIONS ON SITE.
- THIS DRAWING SHALL BE READ IN CONJUNCTION WITH THE PROJECT SPECIFICATION(S) AND ALL OTHER CONTRACT DOCUMENTATION.
- ALL DIMENSIONS ARE IN MILLIMETERS UNLESS OTHERWISE STATED.

SMALL POWER & LIGHTING NOTES

- DRAWINGS MUST BE READ IN CONJUNCTION WITH MECHANICAL DRAWINGS.
- MANUAL DIMMING TO LIGHTING IN LIVING AREAS.
- DATA & TV POINTS TO BE HAGER JOINT PLATE (BEDROOMS - SINGLES, LOUNGES - DOUBLES).
- THE LIGHTING TYPE WITHIN ALL APARTMENTS IS SUBJECT TO CONTRACTOR/CLIENT REVIEW, BEFORE RECESSED FITTINGS ARE AGREED.
- KITCHEN LAYOUTS ARE INDICATIVE ONLY. LIGHTING, SOCKETS AND ISOLATORS ARE ALL SUBJECT TO CONTRACTOR AND CLIENT COORDINATION.
- WHERE POSSIBLE, ALL SERVICES SHOULD BE CONCEALED. THE ROUTING OF SERVICES SHOULD BE COORDINATED WITH DUCTING, DCHW SERVICES, BUILDING FABRIC AND STEEL WORK.
- ALL SWITCHES AND SOCKETS ARE TO BE DECORATIVE BRUSHED FINISH.

Rev	Date	Revision	BB	DM	Ck'd
Client					
TERATT LTD					
Project					
2 SWINBOURNE GROVE WITHINGTON					
Drawing Title					
BASEMENT SMALL POWER LAYOUT					
 McKee Associates Ltd Unity House Westwood Park Wigan WN3 4HE Web : www.mckeeassociates.co.uk Tel : 01942 918 145					
Cad Drawn	BB	Date	JULY 2021	Scale	1:50@ (A1)
Checked	DM	Date	JULY 2021	Rev.	P1
Dwg No :		P2121 - 62 - 002			

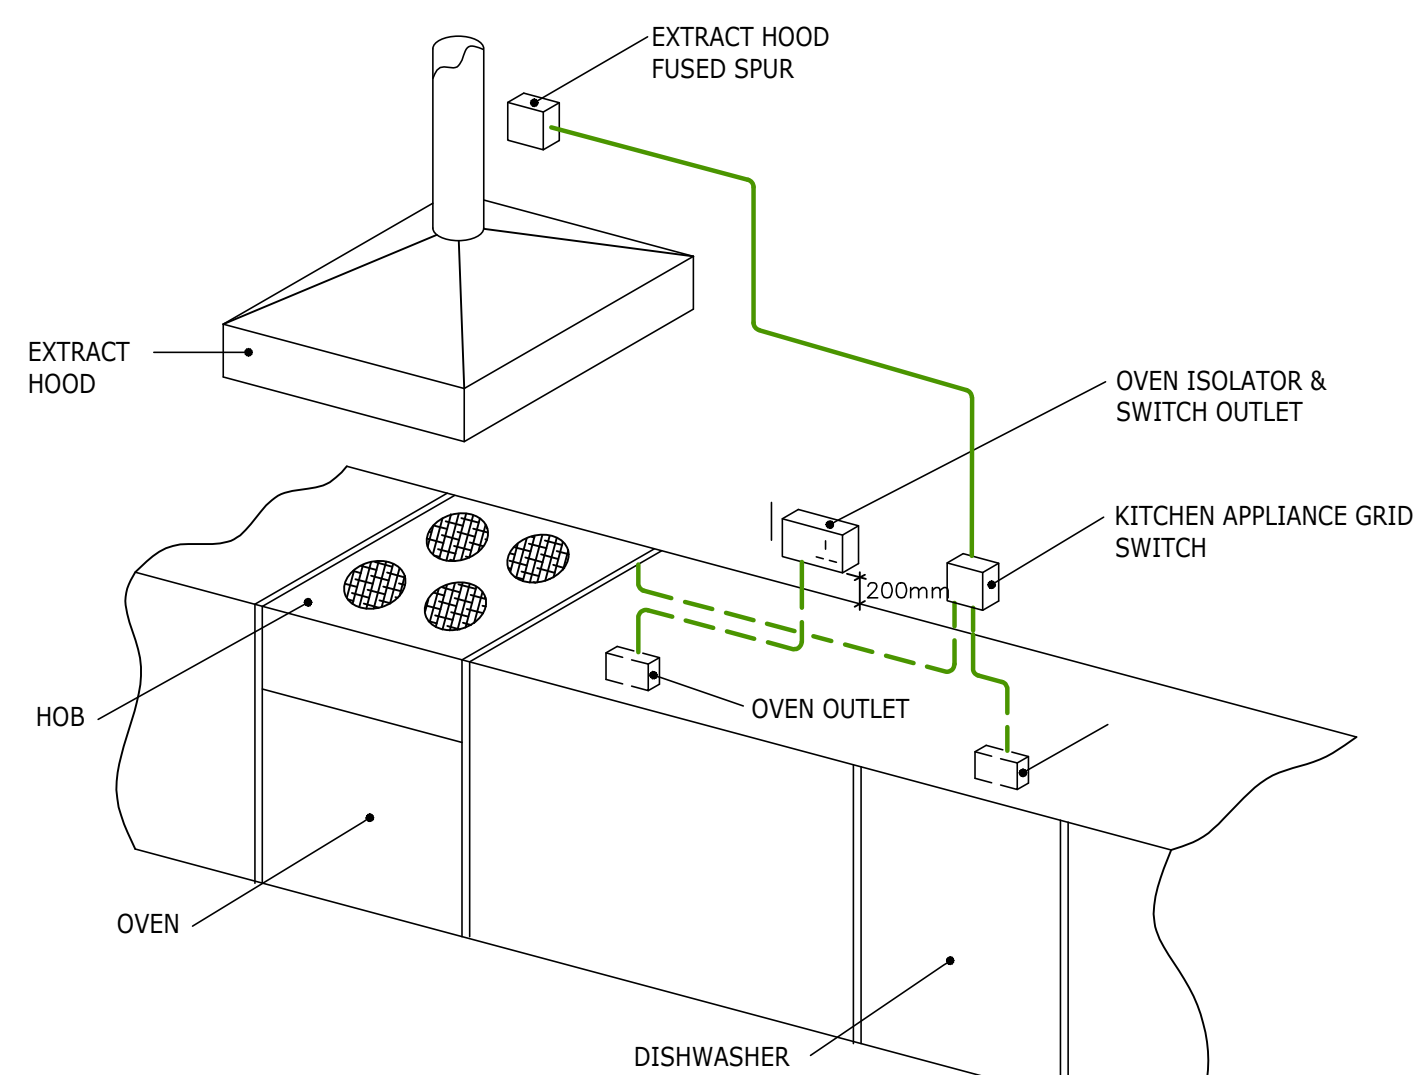

KITCHEN OUTLETS DETAIL (NTS)



Proposed first floor

- | | |
|-----|---------------------|
| OV | OVEN |
| EF | EXTRACT FAN |
| WD | WASHER/DRYER |
| HWC | HOT WATER CYLINDER |
| LL | LOW LEVEL |
| HL | HIGH LEVEL |
| SM | SURFACE MOUNTED |
| PT | PENDANT FITTING |
| PH | PANEL HEATER |
| WT | WORKTOP MOUNTED |
| SWR | SHOWER |
| HB | HOB |
| HD | EXTRACT HOOD |
| UC | UNDERCOUNTER SOCKET |
| ACC | ACCESS CONTROL |

- 1.00 THIS DRAWING IS SUBJECT TO COPYRIGHT AND IS NOT TO BE REPRODUCED IN PART OR WHOLE WITHOUT APPROVAL.
- 2.00 DO NOT SCALE THIS DRAWING. CHECK ALL DIMENSIONS ON SITE.
- 3.00 THIS DRAWING SHALL BE READ IN CONJUNCTION WITH THE PROJECT SPECIFICATION(S) AND ALL OTHER CONTRACT DOCUMENTATION.
- 4.00 ALL DIMENSIONS ARE IN MILLIMETERS UNLESS OTHERWISE STATED.

- 1.00 DRAWINGS MUST BE READ IN CONJUNCTION WITH MECHANICAL DRAWINGS.
- 2.00 MANUAL DIMMING TO LIGHTING IN LIVING AREAS.
- 3.00 DATA & TV POINTS TO BE HAGER JOINT PLATE (BEDROOMS - SINGLES, LOUNGES - DOUBLES).
- 4.00 THE LIGHTING TYPE WITHIN ALL APARTMENTS IS SUBJECT TO CONTRACTOR/CLIENT REVIEW, BEFORE RECESSED FITTINGS ARE AGREED.
- 5.00 KITCHEN LAYOUTS ARE INDICATIVE ONLY. LIGHTING, SOCKETS AND ISOLATORS ARE ALL SUBJECT TO CONTRACTOR AND CLIENT COORDINATION.
- 6.00 WHERE POSSIBLE, ALL SERVICES SHOULD BE CONCEALED. THE ROUTING OF SERVICES SHOULD BE COORDINATED WITH DUCTING, DCHW SERVICES, BUILDING FABRIC AND STEEL WORK.
- 7.00 ALL SWITCHES AND SOCKETS ARE TO BE DECORATIVE BRUSHED FINISH.

-	-	-	BB	DM
Rev	Date	Revision	Drawn	Ck'd

Client

TERATT LTD

Project

2 SWINBOURNE GROVE
WITHINGTON

Drawing Title

FIRST FLOOR
SMALL POWER LAYOUT




McKee Associates Ltd
Unity House
Westwood Park
Wigan
WN3 4HE


Web : www.mckeeassociates.co.uk
Tel : 01942 918 145

Cad Drawn	Date	Scale
BB	JULY 2021	1:50@ (A1)
Checked	Date	Rev.
DM	JULY 2021	P1


Dwg No : P2121 - 62 - 003

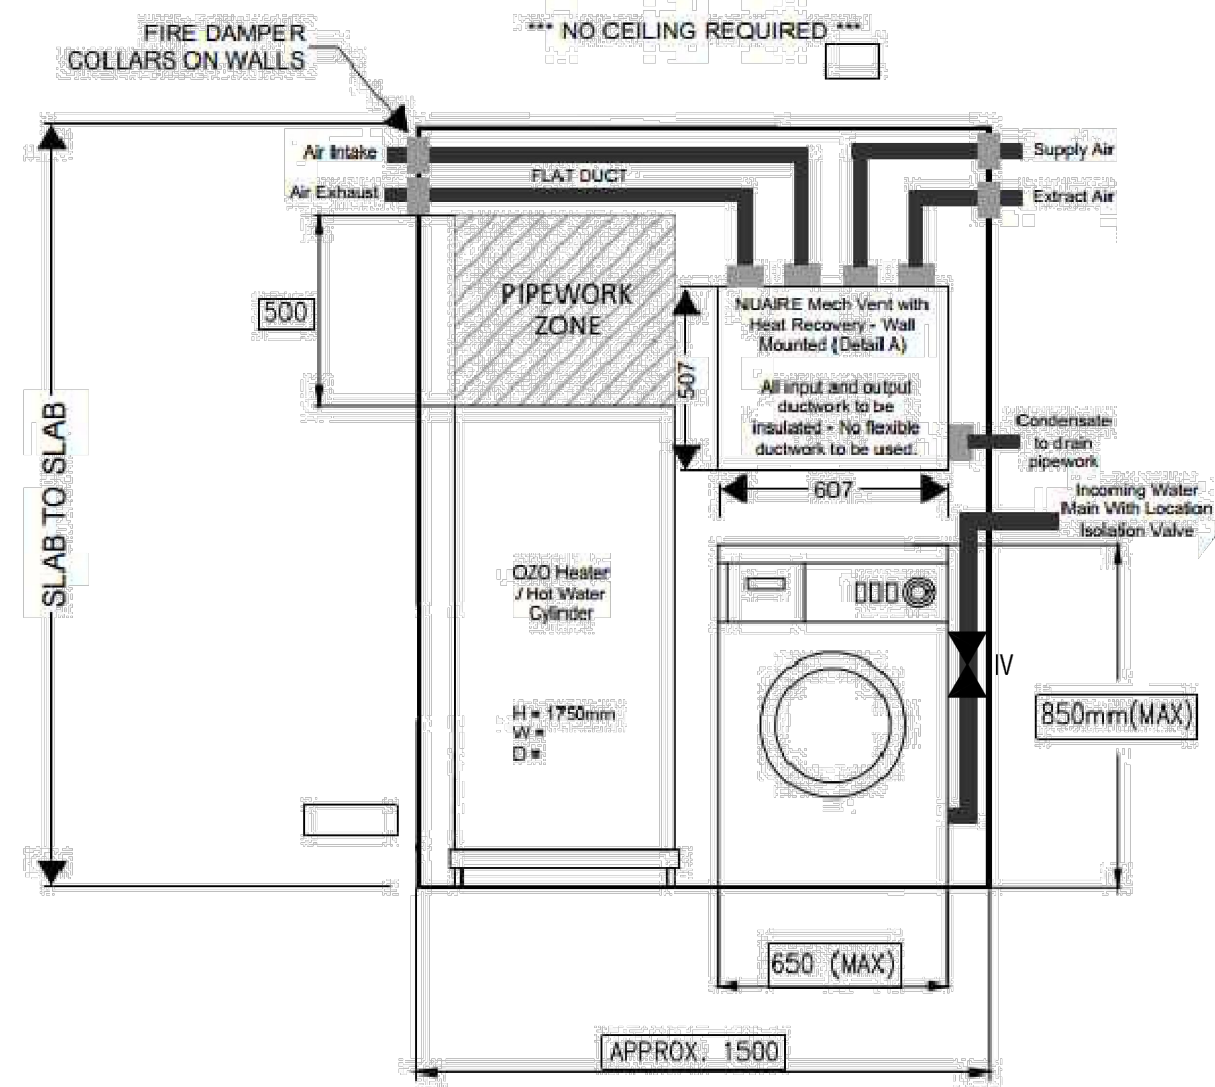


DETAIL
WATER / MECH RISER CUPBOARD
NTS

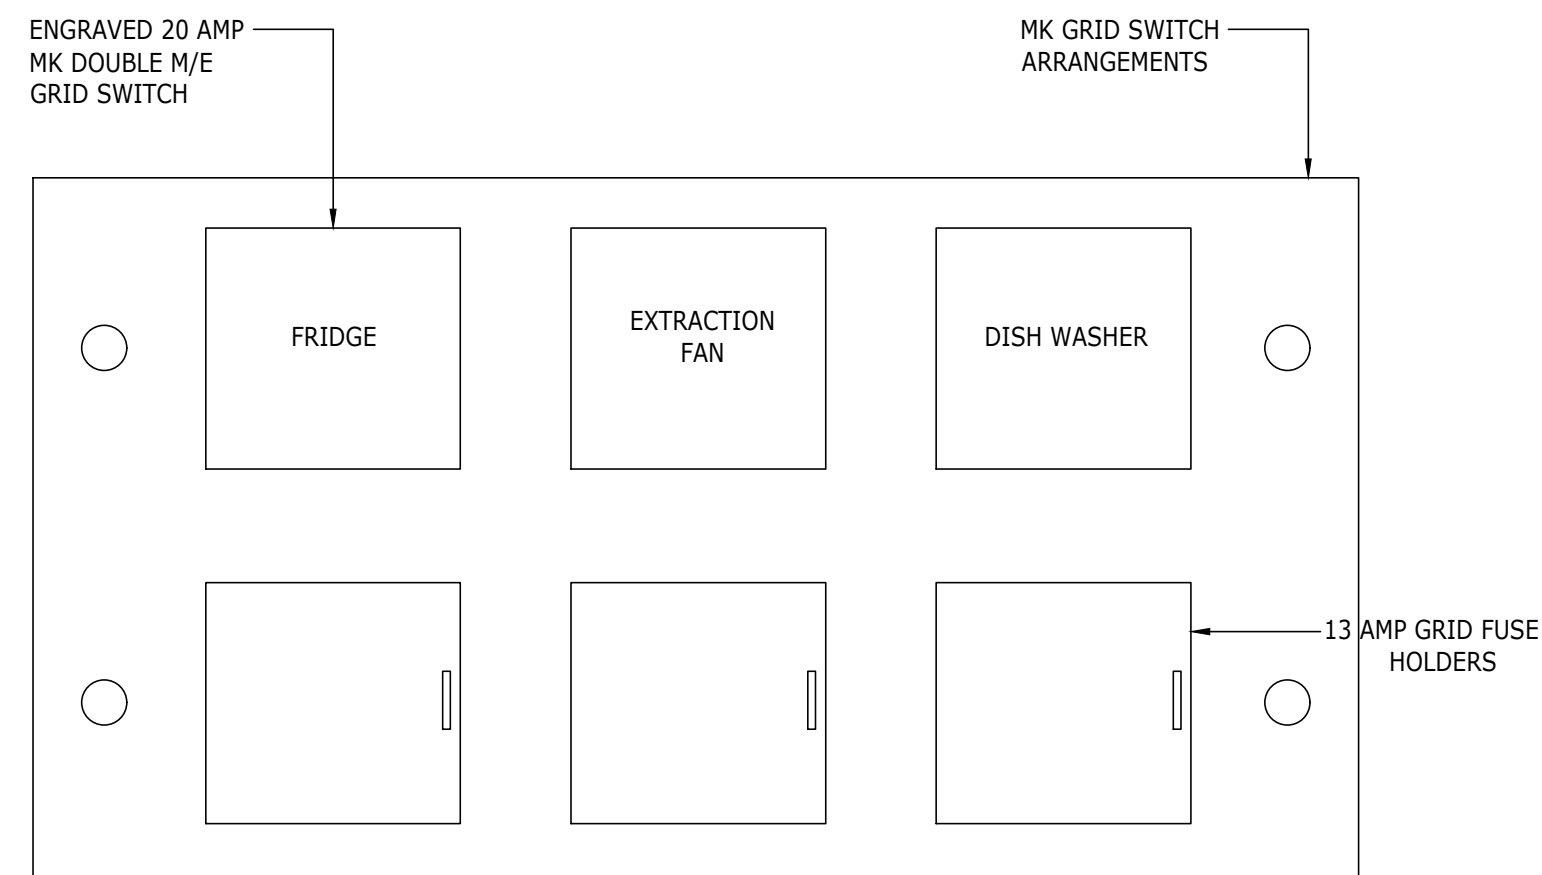

TYPICAL DETAIL
KITCHEN APPLIANCE GRID SWITCH

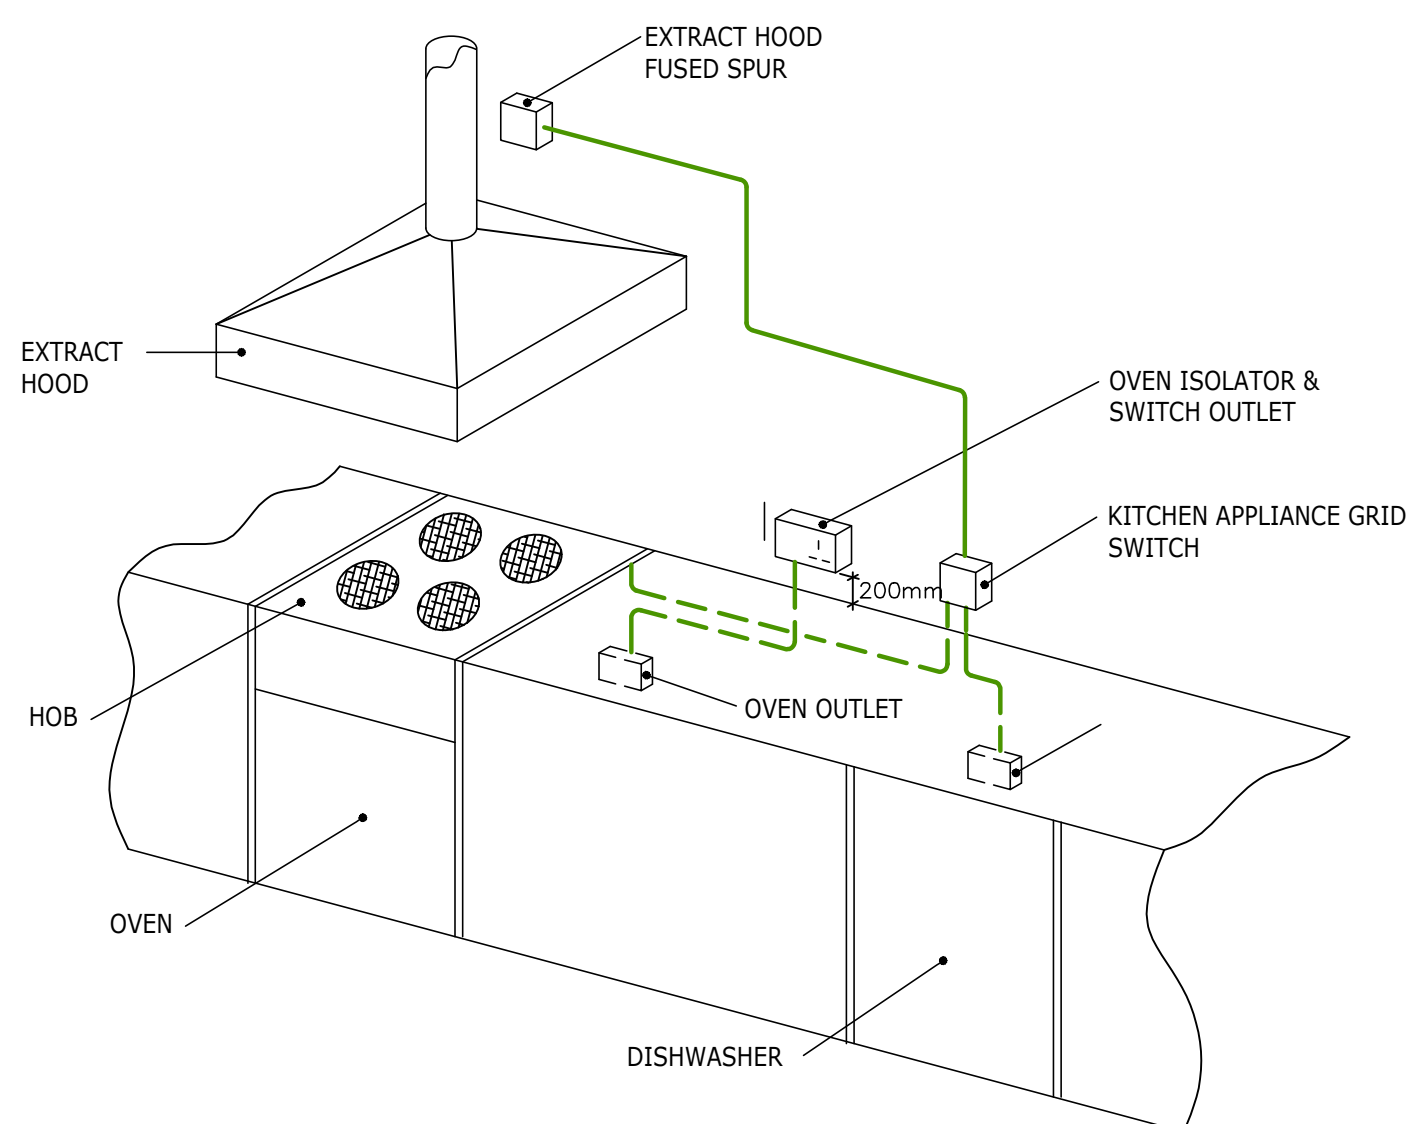

KITCHEN OUTLETS DETAIL (NTS)

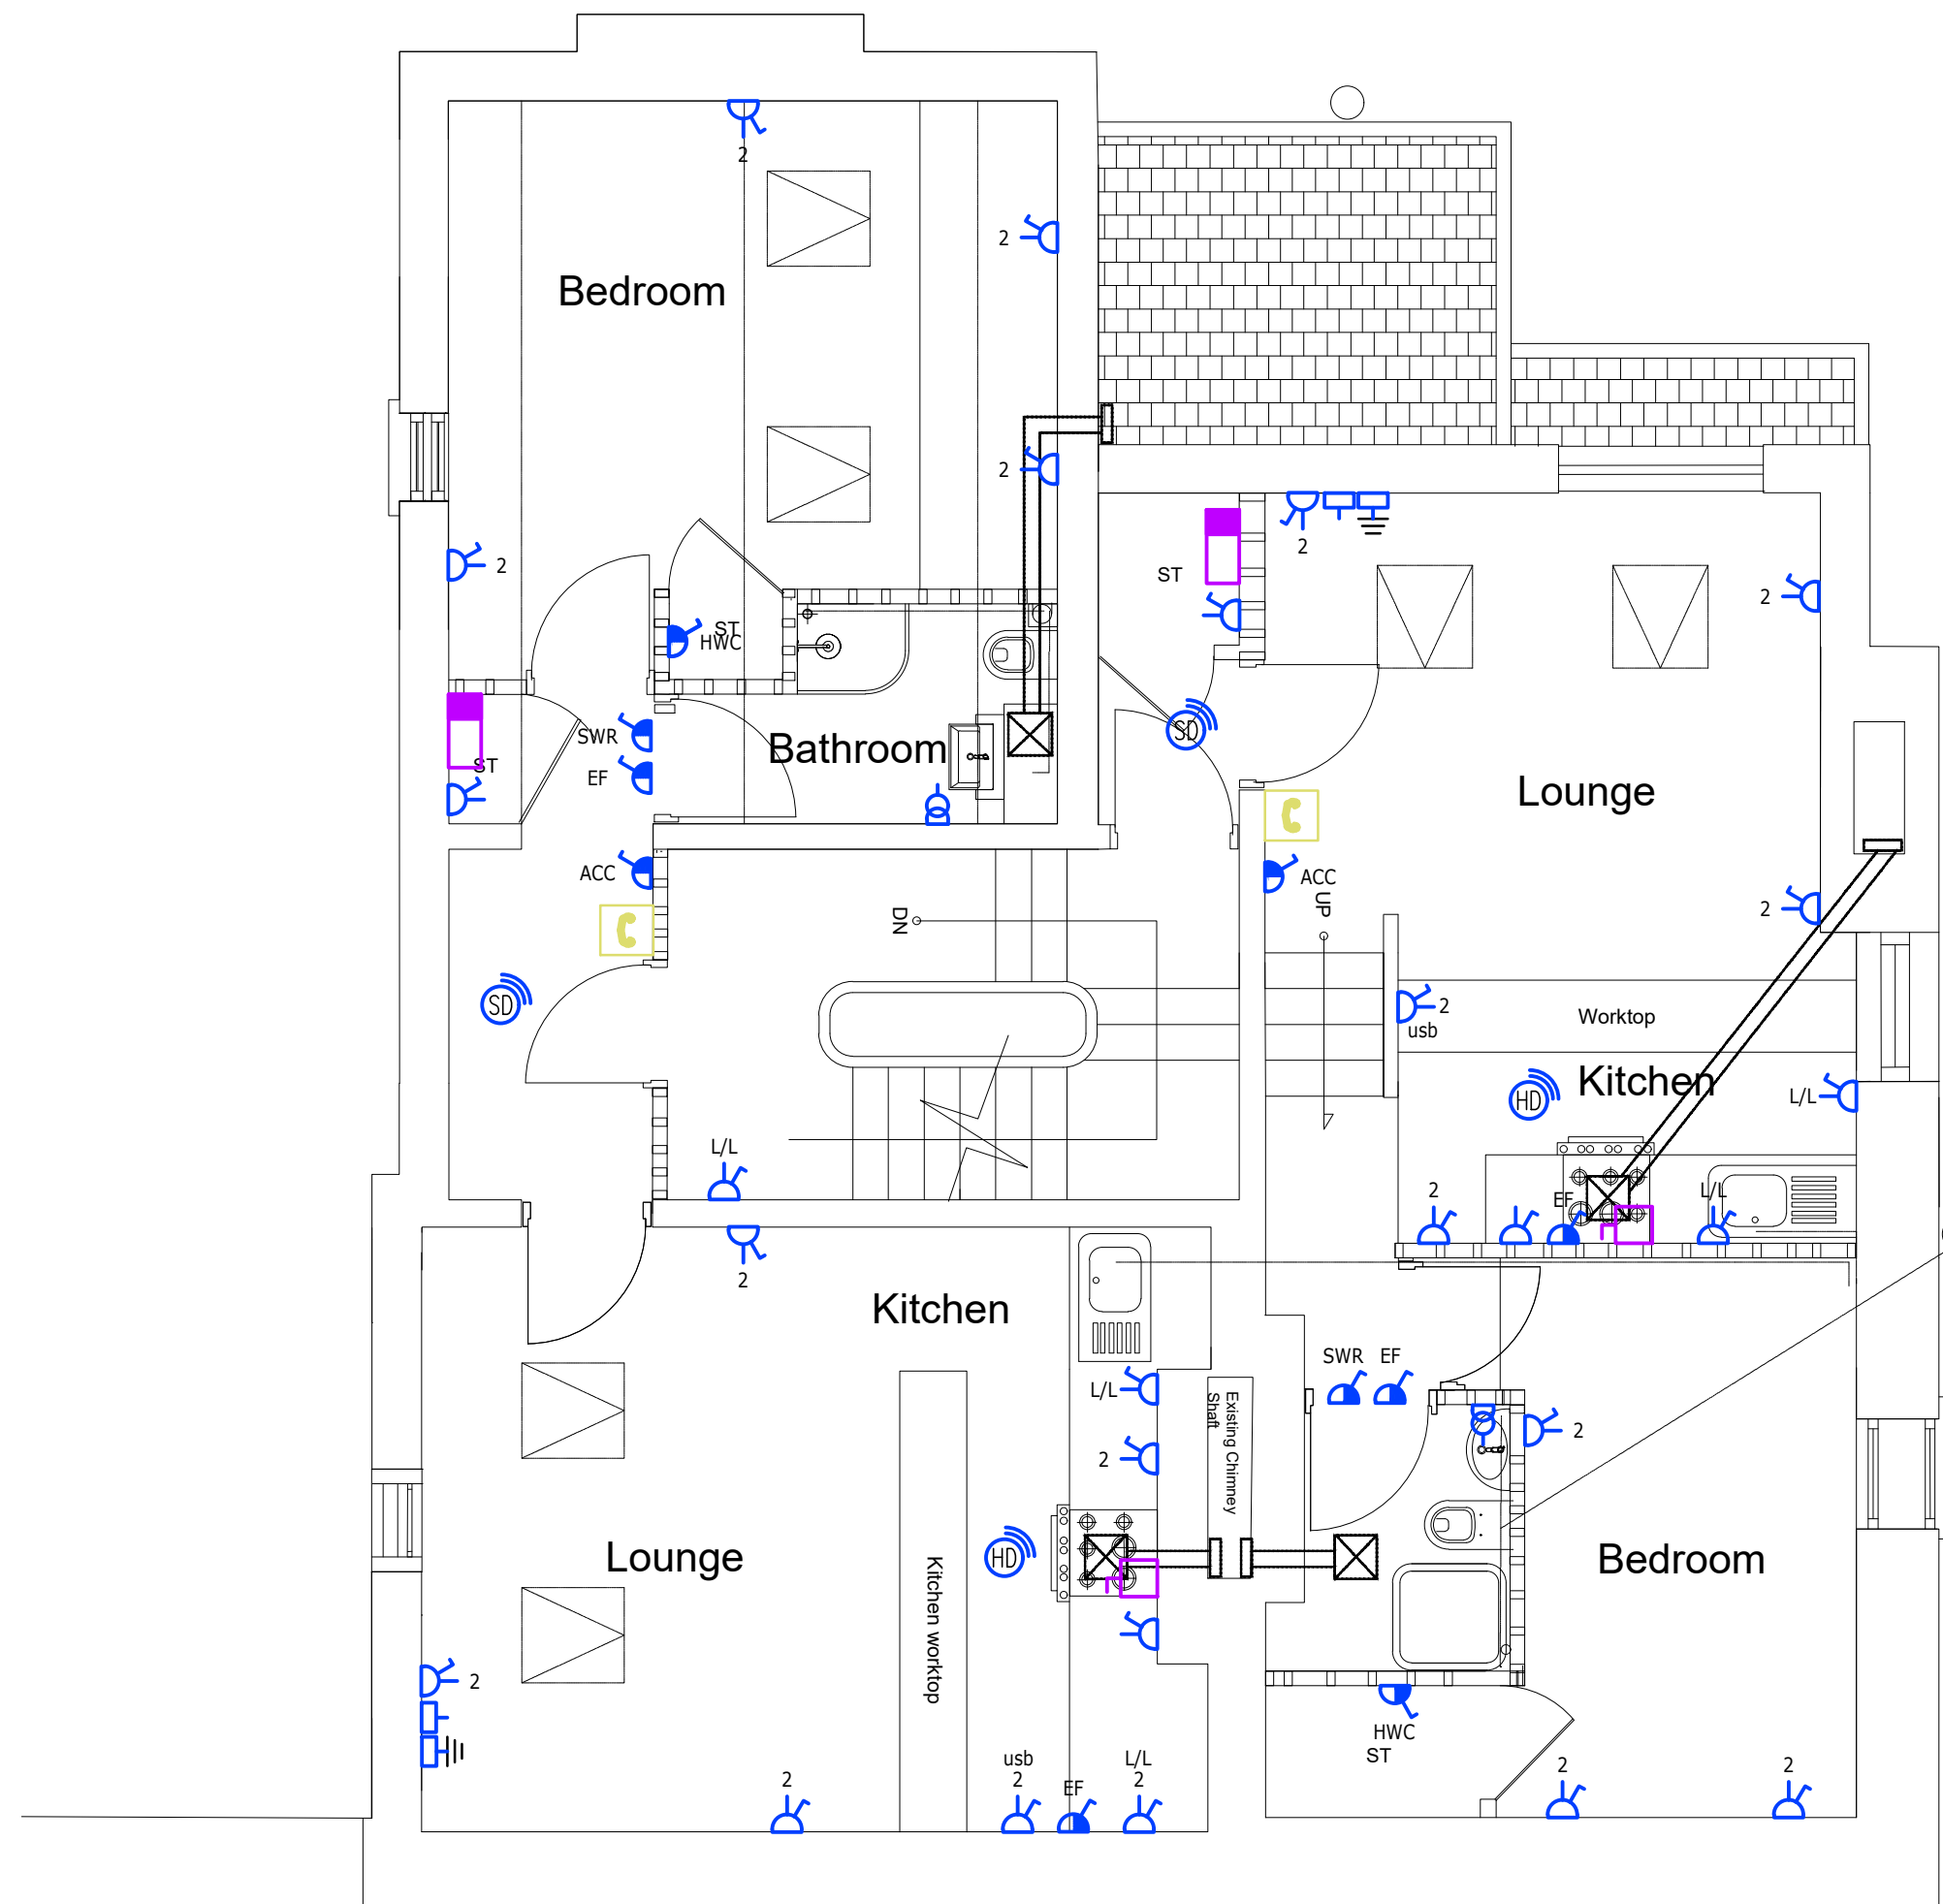

Flat 5:
1 Bedroom Flat
Area: 38.8 m²

Flat 6:
1 Bedroom Flat
Area: 47.5 m²

Proposed second
floor

SMALL POWER LEGEND

- COOKER ISOLATOR
- SHAVER SOCKET
- SINGLE SWITCHED SOCKET OUTLET
- '2' DENOTES TWIN
- SWITCHED FUSED SPUR
- DISTRIBUTION BOARD
- DATA POINT
- TELEPHONE/INTERCOM POINT
- STAND-ALONE DOMESTIC WIRED HEAT DETECTOR/ALARM
- STAND-ALONE DOMESTIC WIRED SMOKE DETECTOR/ALARM
- INTERCOM
- MK APPLIANCE GRID SWITCH

LIGHTING LEGEND

- CEILING MOUNTED LED LIGHT FITTING
- CEILING MOUNTED LED LIGHT FITTING WITH EMERGENCY
- WALL MOUNTED LIGHT FITTING
- LED STRIP LIGHTING
- LIGHT SWITCH 'n' DENOTES No. OF GANGS
- 360° CEILING MOUNTED OCCUPANCY SENSOR
- LED WALL LIGHT c/w EMERGENCY
- EMERGENCY EXIT (LED)
- TV OUTLET

KEY

- OV OVEN
- EF EXTRACT FAN
- WD WASHER/DRYER
- HWC HOT WATER CYLINDER
- LL LOW LEVEL
- HL HIGH LEVEL
- SM SURFACE MOUNTED
- PT PENDANT FITTING
- PH PANEL HEATER
- WT WORKTOP MOUNTED
- SWR SHOWER
- HB HOB
- HD EXTRACT HOOD
- UC UNDERCOUNTER SOCKET
- ACC ACCESS CONTROL

GENERAL NOTES

- THIS DRAWING IS SUBJECT TO COPYRIGHT AND IS NOT TO BE REPRODUCED IN PART OR WHOLE WITHOUT APPROVAL.
- DO NOT SCALE THIS DRAWING. CHECK ALL DIMENSIONS ON SITE.
- THIS DRAWING SHALL BE READ IN CONJUNCTION WITH THE PROJECT SPECIFICATION(S) AND ALL OTHER CONTRACT DOCUMENTATION.
- ALL DIMENSIONS ARE IN MILLIMETERS UNLESS OTHERWISE STATED.

SMALL POWER & LIGHTING NOTES

- DRAWINGS MUST BE READ IN CONJUNCTION WITH MECHANICAL DRAWINGS.
- MANUAL DIMMING TO LIGHTING IN LIVING AREAS.
- DATA & TV POINTS TO BE HAGER JOINT PLATE (BEDROOMS - SINGLES, LOUNGES - DOUBLES).
- THE LIGHTING TYPE WITHIN ALL APARTMENTS IS SUBJECT TO CONTRACTOR/CLIENT REVIEW, BEFORE RECESSED FITTINGS ARE AGREED.
- KITCHEN LAYOUTS ARE INDICATIVE ONLY. LIGHTING, SOCKETS AND ISOLATORS ARE ALL SUBJECT TO CONTRACTOR AND CLIENT COORDINATION.
- WHERE POSSIBLE, ALL SERVICES SHOULD BE CONCEALED. THE ROUTING OF SERVICES SHOULD BE COORDINATED WITH DUCTING, DCHW SERVICES, BUILDING FABRIC AND STEEL WORK.
- ALL SWITCHES AND SOCKETS ARE TO BE DECORATIVE BRUSHED FINISH.

Rev	Date	Revision	BB	DM
-	-	-	Drawn	Ck'd

Client

TERATT LTD

Project

2 SWINBOURNE GROVE
WITHINGTON

Drawing Title

SECOND FLOOR
SMALL POWER LAYOUT



McKee Associates Ltd
Unity House
Westwood Park
Wigan
WN3 4HE
Web : www.mckeeassociates.co.uk
Tel : 01942 918 145

Cad Drawn	BB	Date	JULY 2021	Scale	1:50@ (A1)
Checked	DM	Date	JULY 2021	Rev.	P1

Dwg No : P2121 - 62 - 004