



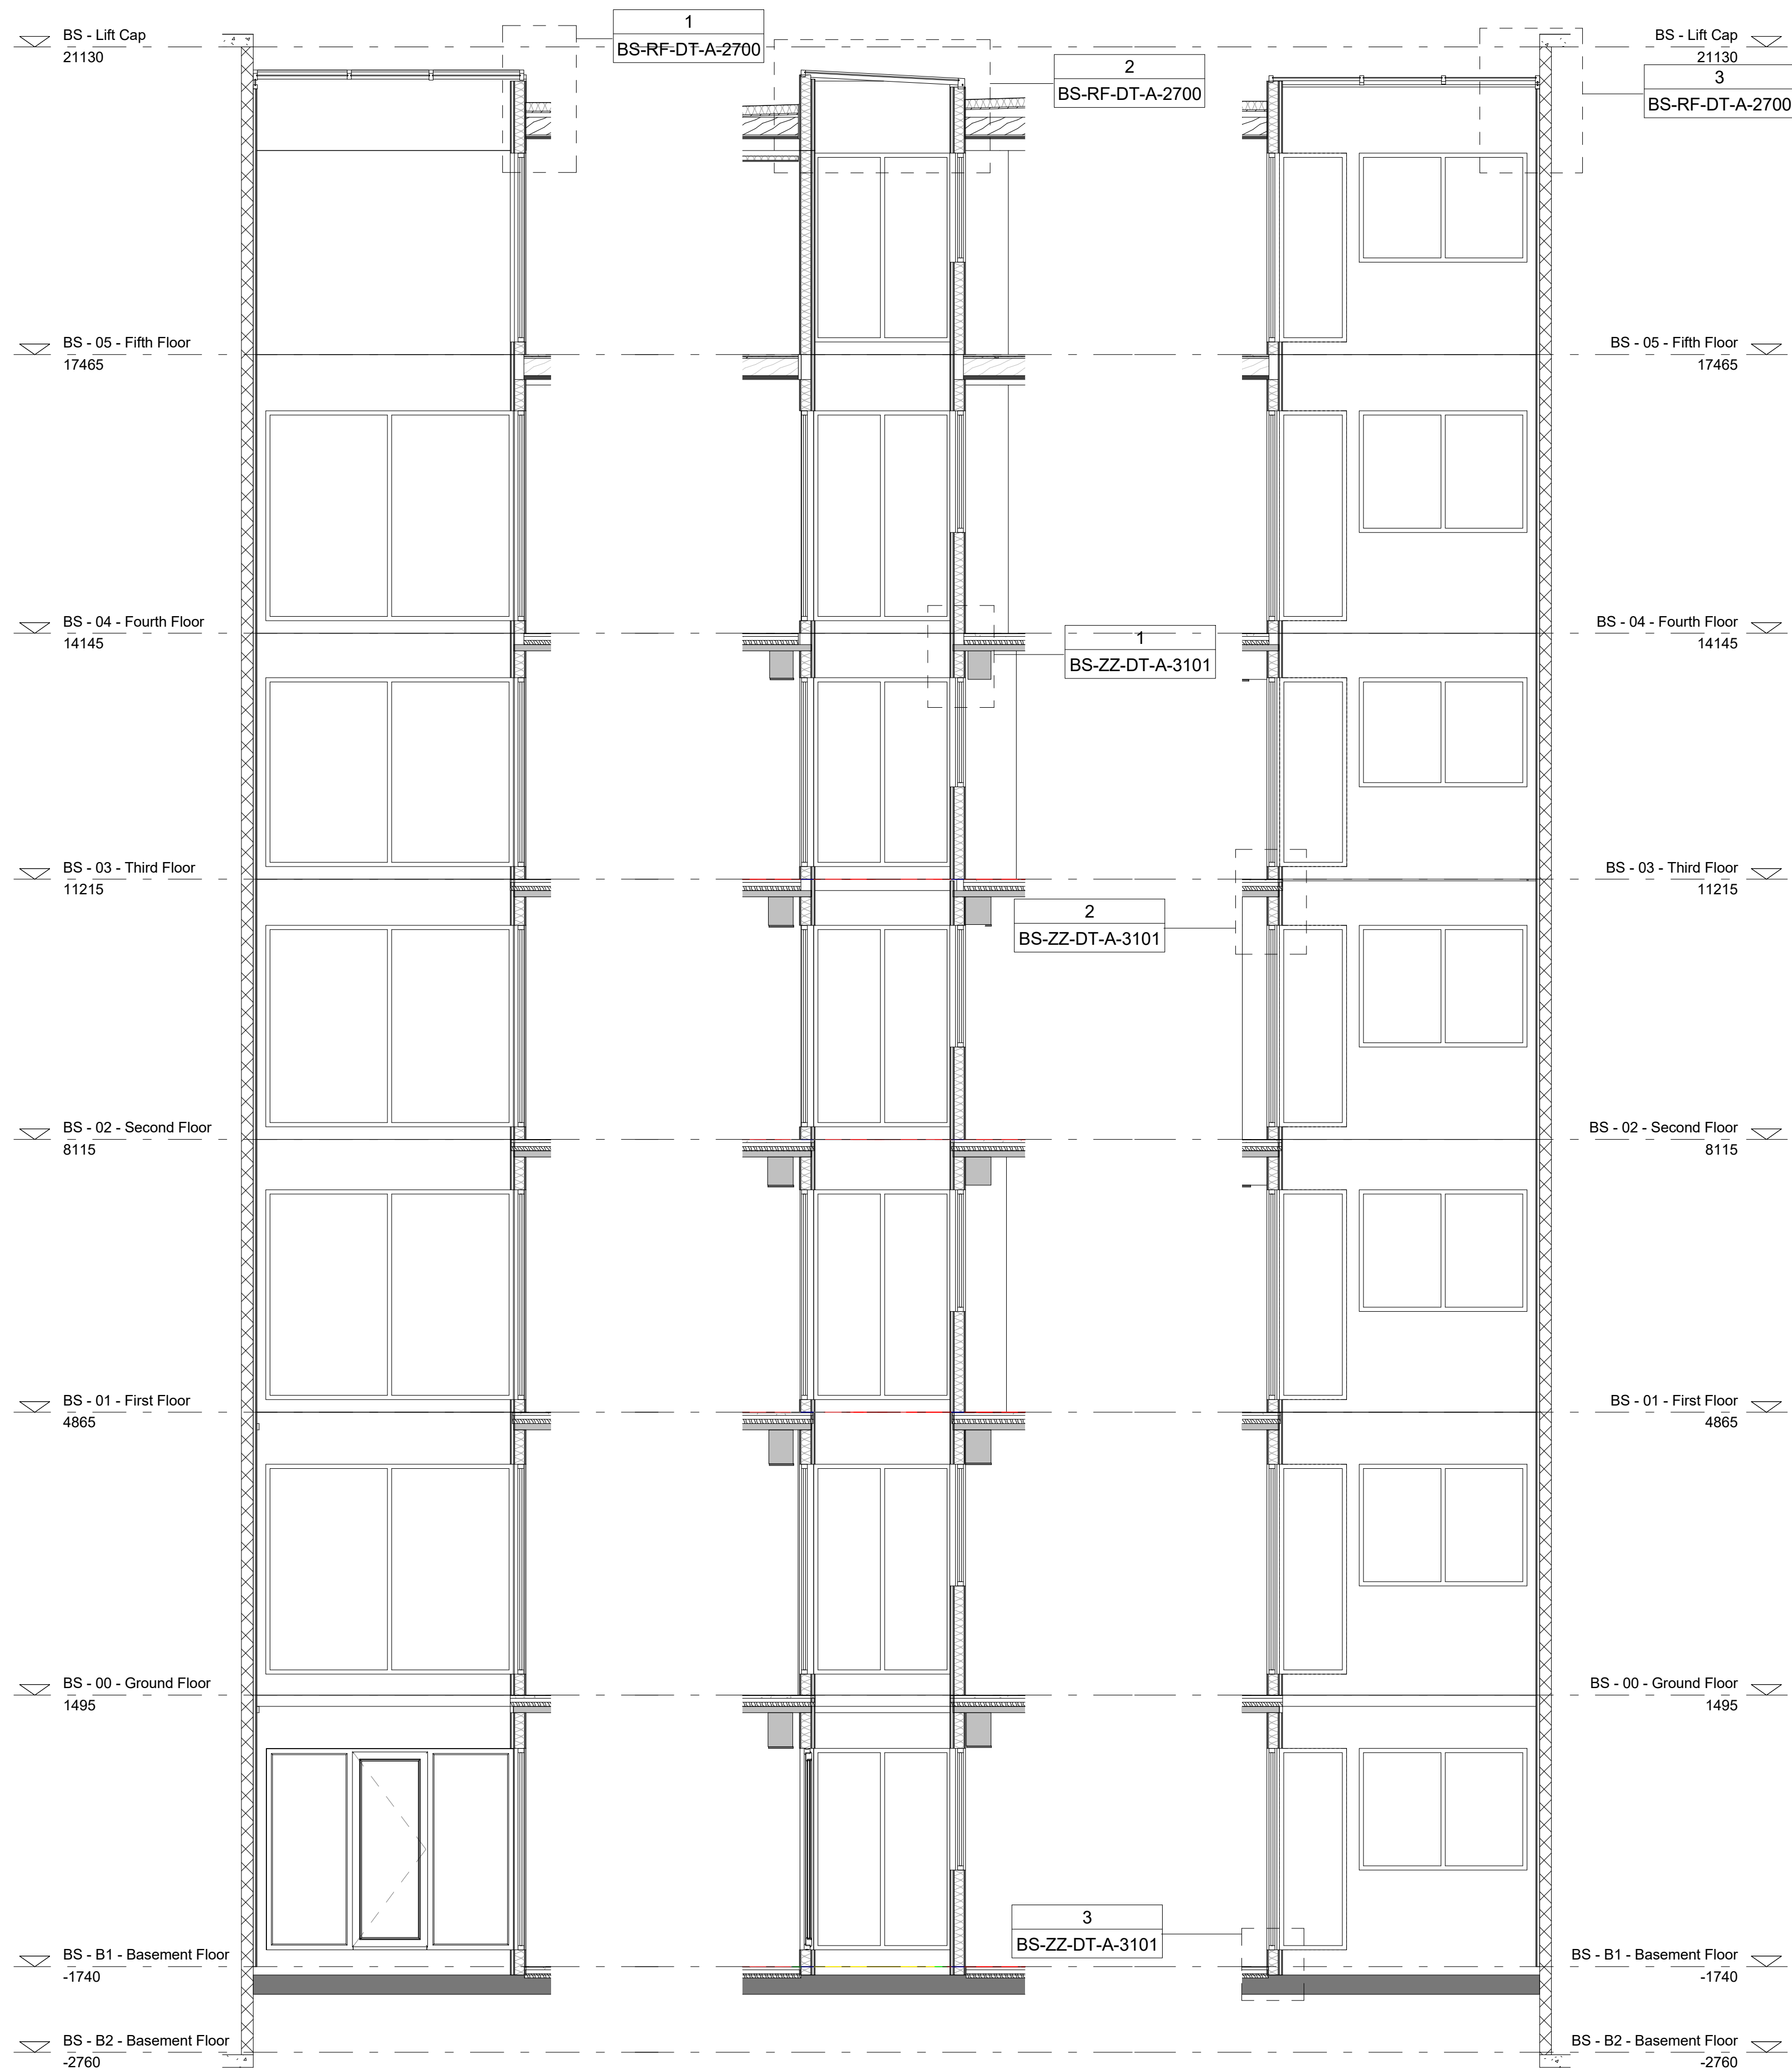


4 SECTION B - LIGHTWELL
1:50

5 SECTION A - LIGHTWELL
1:50


6 SECTION C - LIGHTWELL
1:50

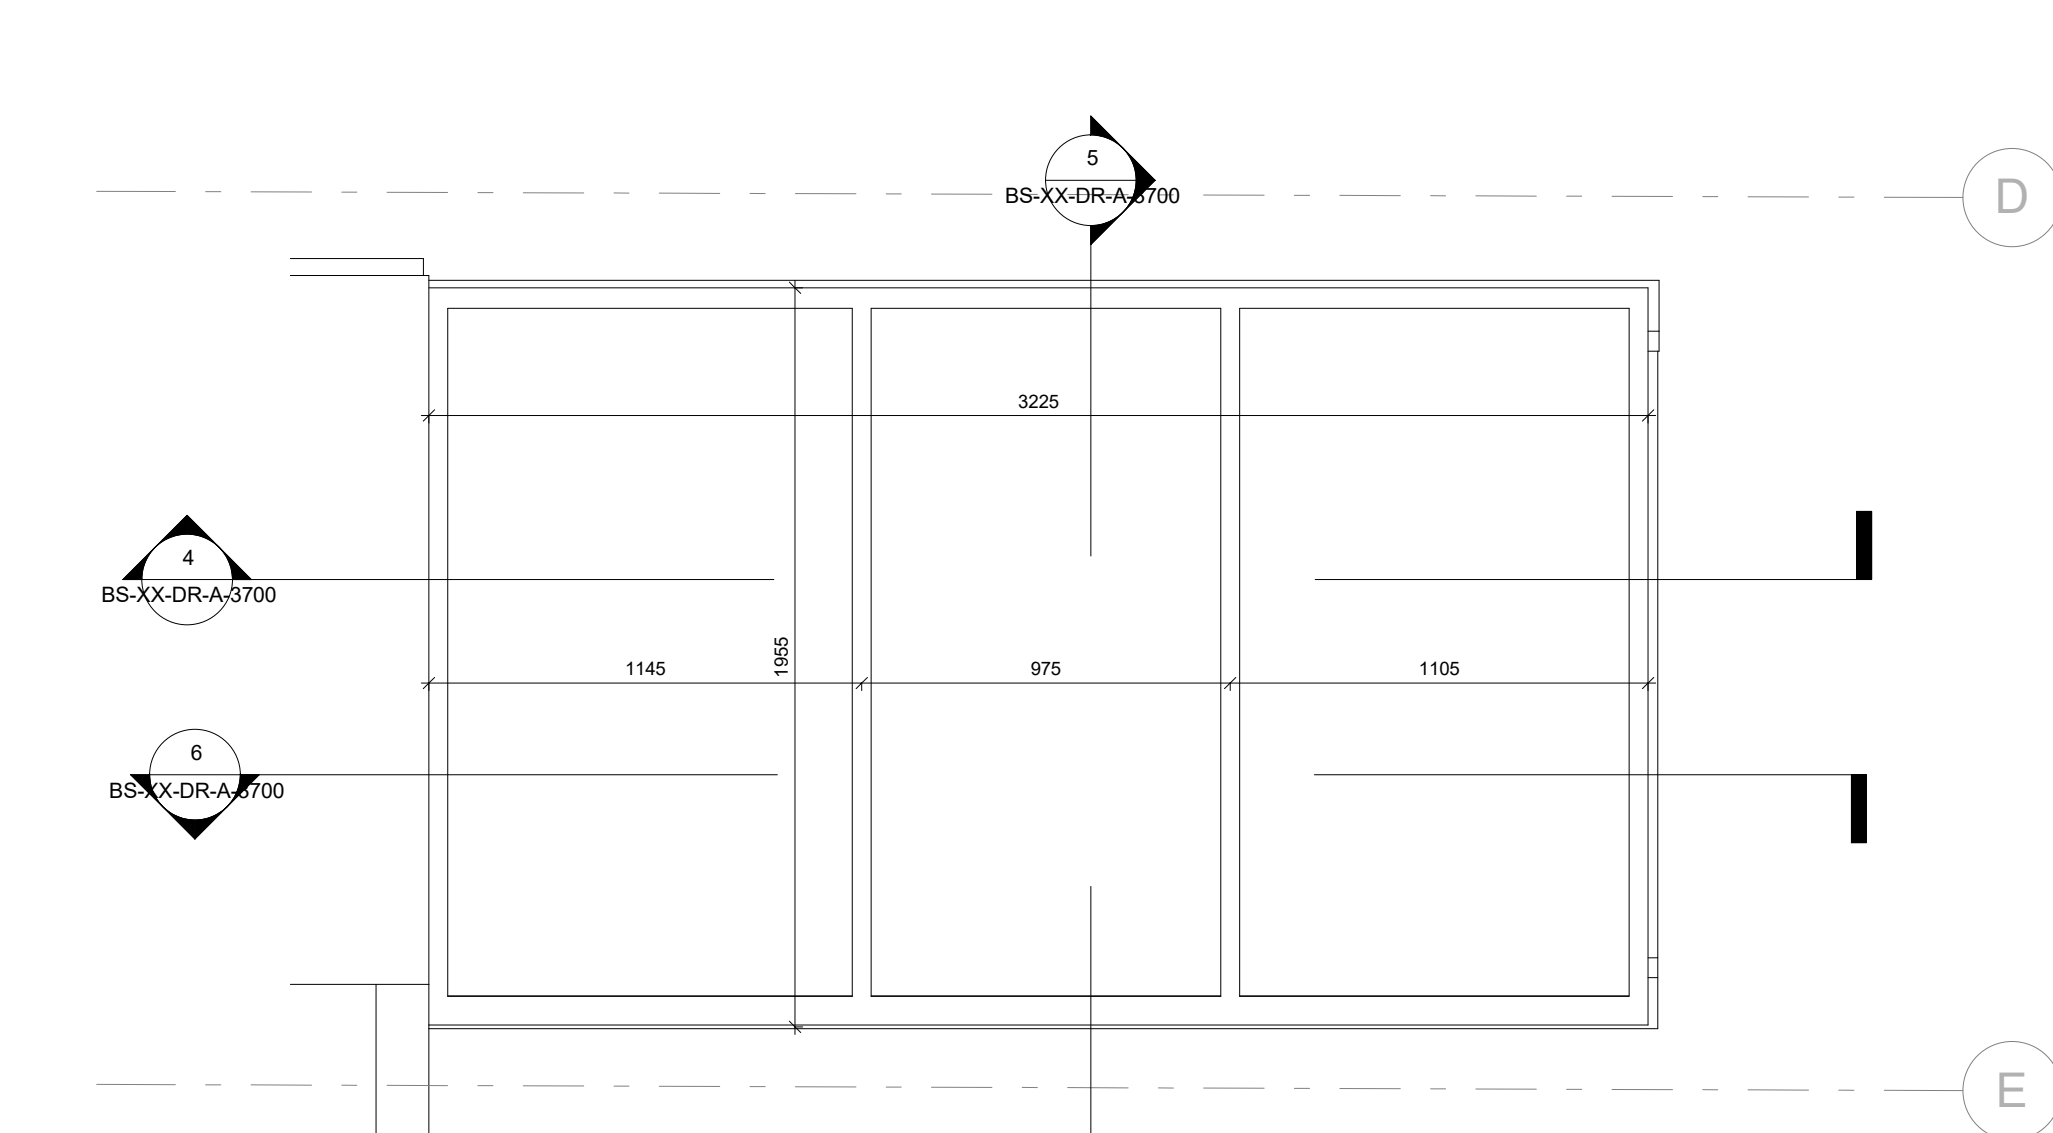

3 LIGHT WELL - ROOF LIGHT PLAN
1:20

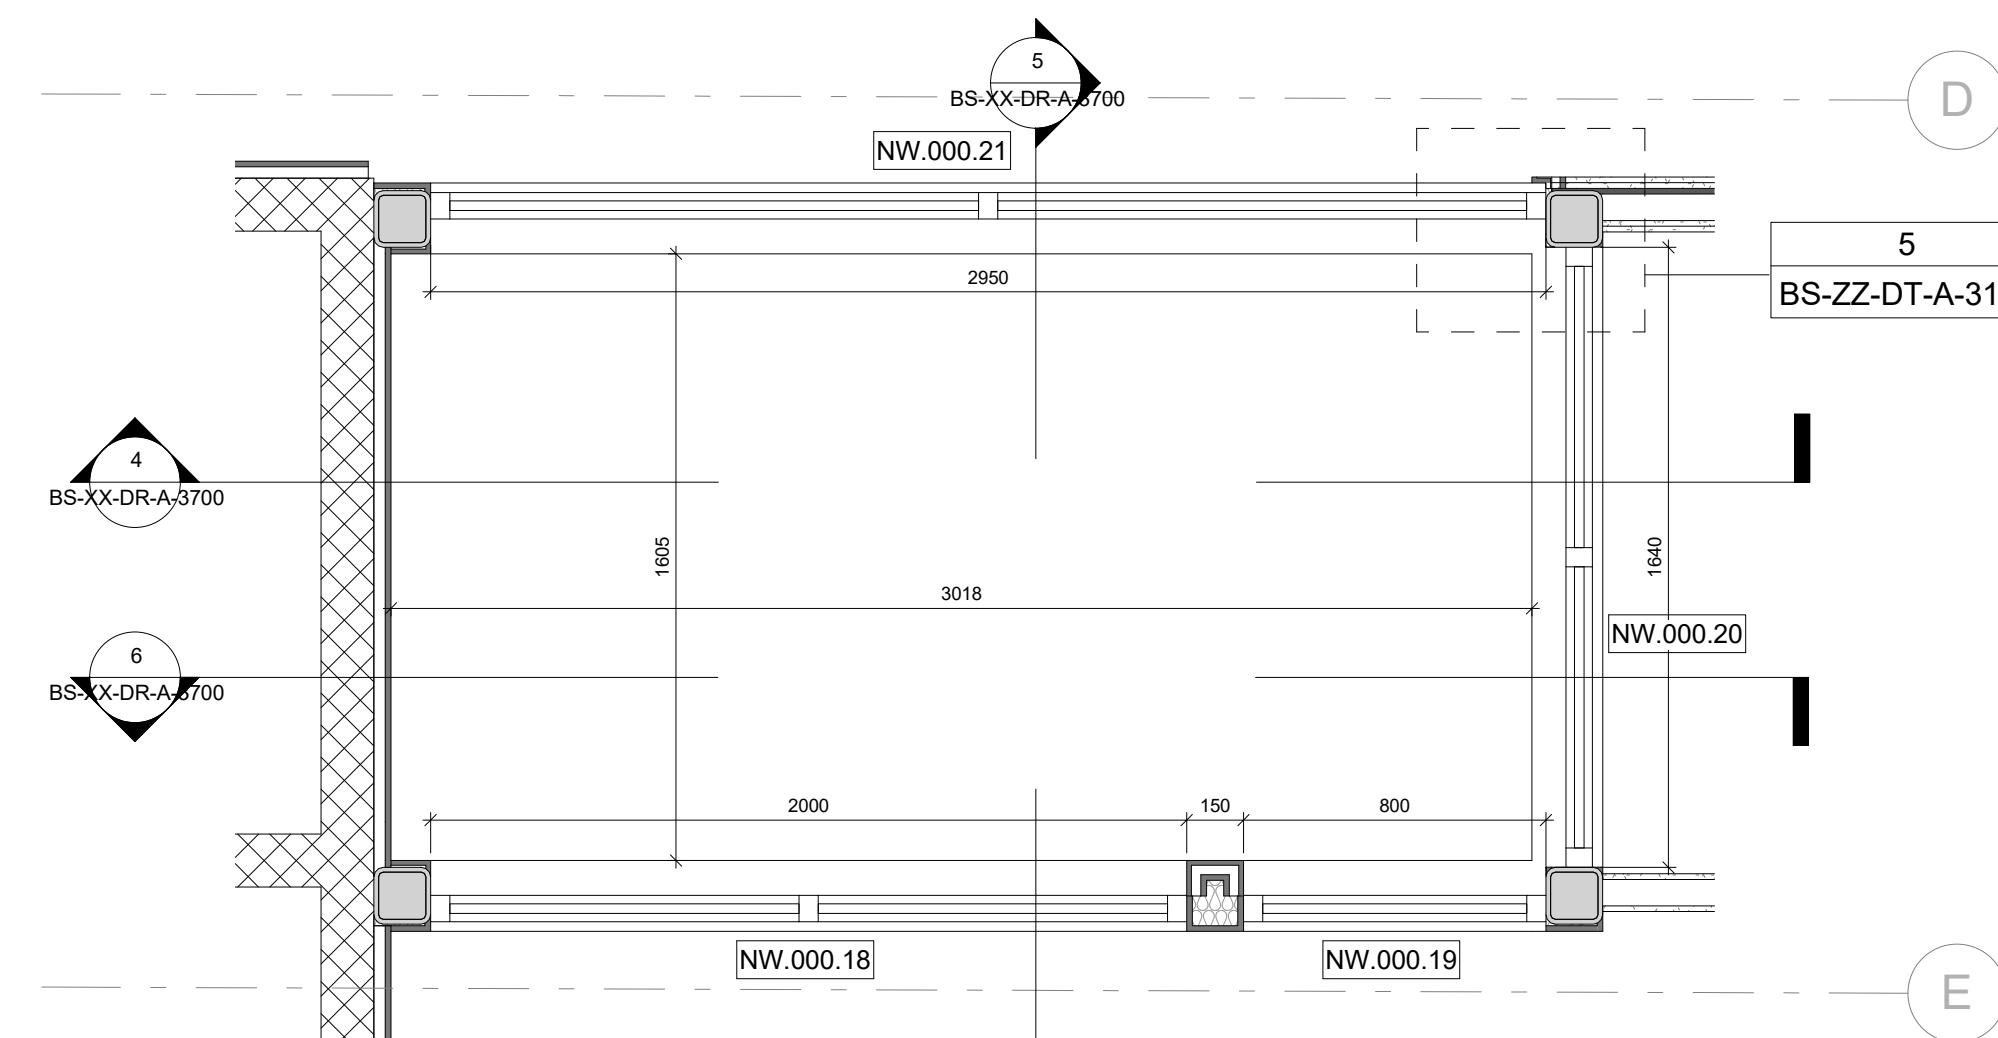

2 LIGHT WELL - TYPICAL UPPER FLOOR PLAN
1:20

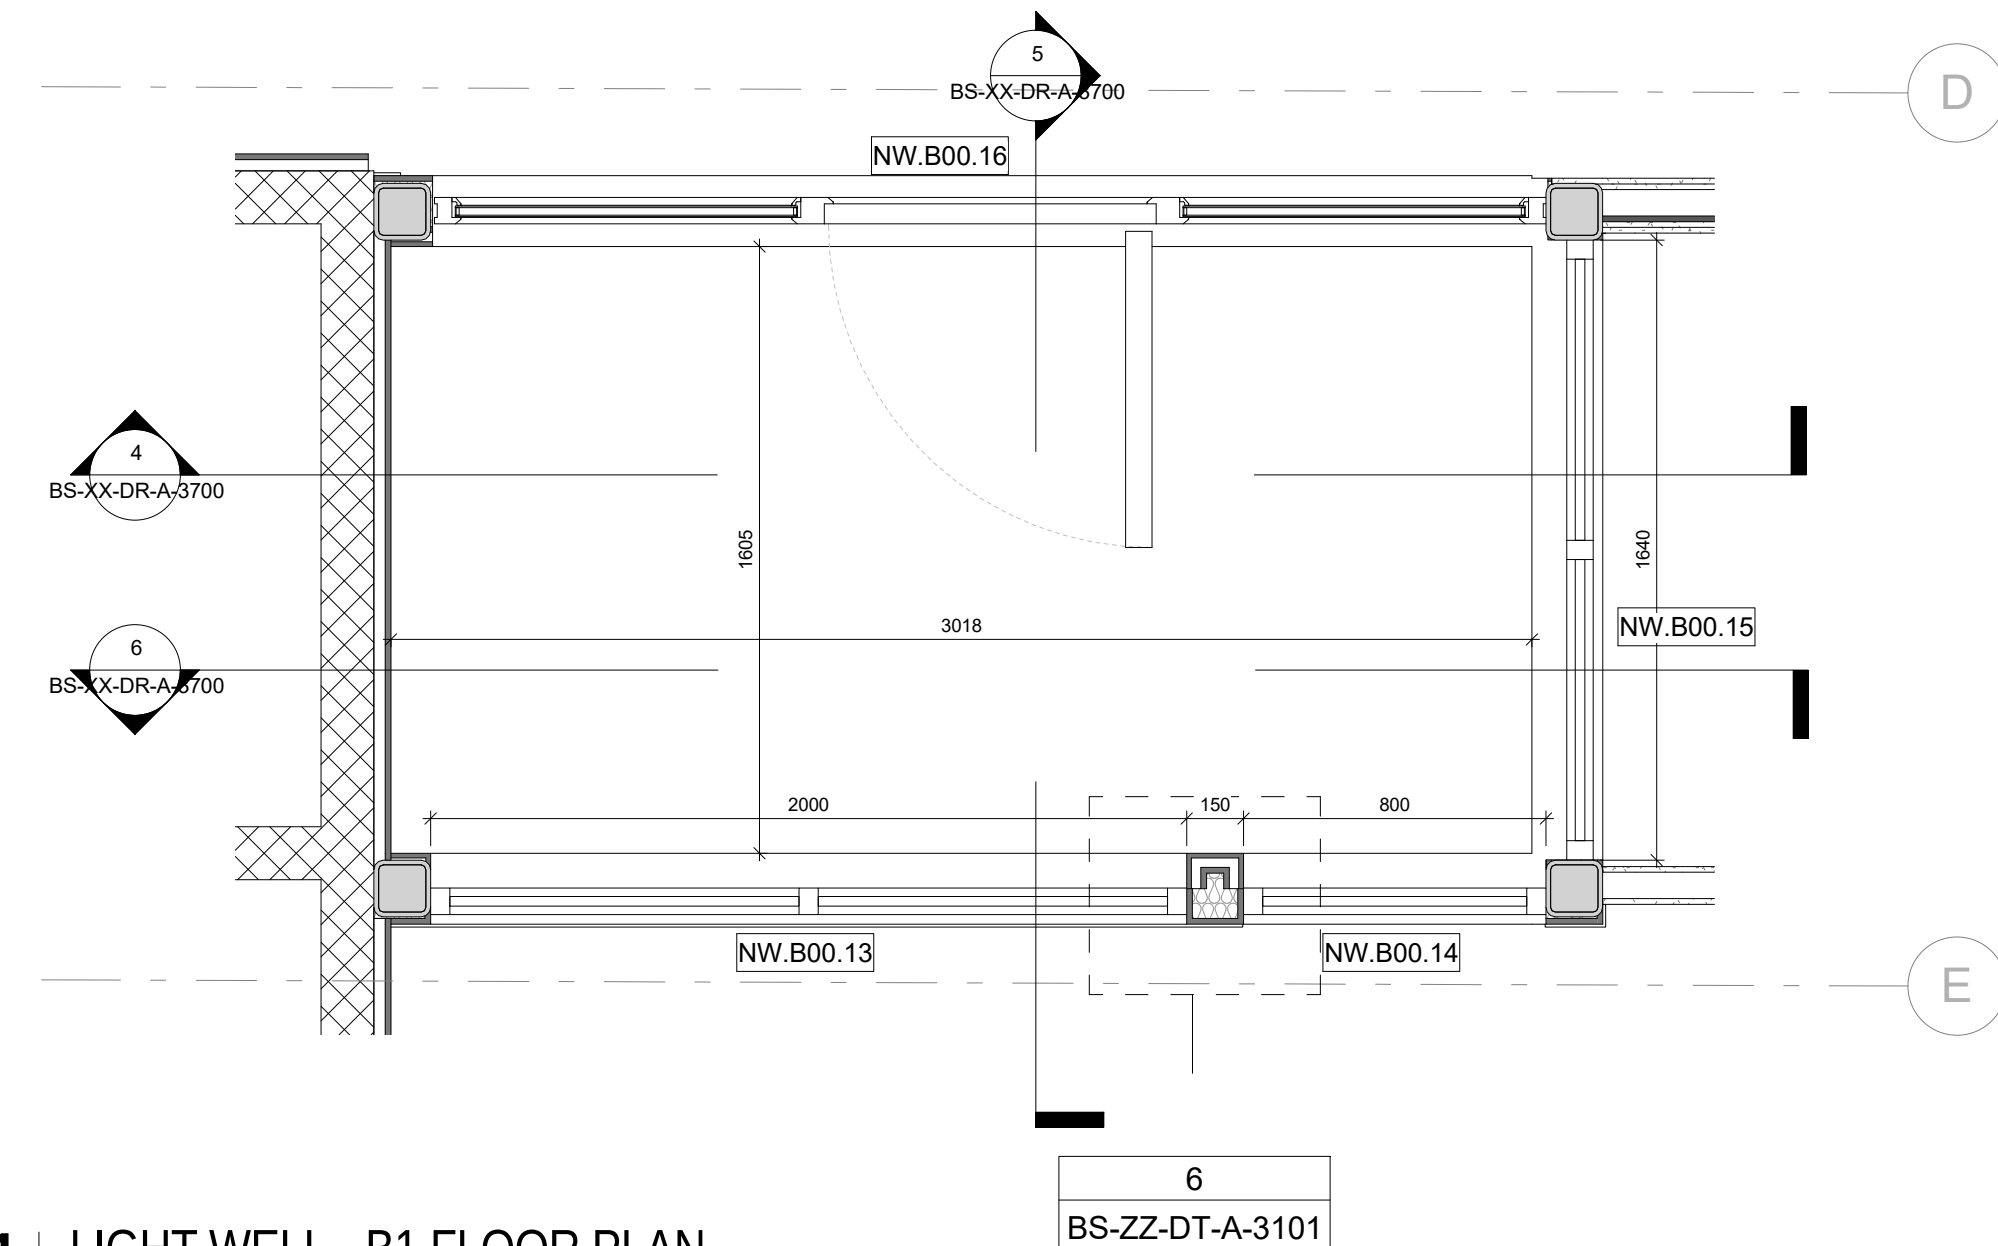

1 LIGHT WELL - B1 FLOOR PLAN
1:20

GENERAL NOTES

1. ALL DIMENSIONS ARE IN MILLIMETRES UNLESS OTHERWISE STATED.
2. ALL LEVELS ARE IN METRES UNLESS OTHERWISE STATED.
3. DIMENSIONS ARE NOT TO BE SCALED FROM THE DRAWING.
4. ALL WORK TO BE CARRIED OUT IN ACCORDANCE WITH THE CURRENT EDITION OF THE BUILDING REGULATIONS 1991 (INCLUDING AMENDMENTS) AND ALL RELEVANT BRITISH STANDARDS/CODES OF PRACTICE.
5. CONTRACTOR IS RESPONSIBLE FOR THE CORRECT SETTING OUT OF THE WORKS ON SITE. ALL DIMENSIONS TO BE CHECKED PRIOR TO FABRICATION OF MATERIALS.
6. THIS DRAWING IS TO BE READ IN CONJUNCTION WITH ALL RELEVANT DRAWINGS AND SPECIFICATIONS.
7. THIS DRAWING SHALL NOT BE DUPLICATED WITHOUT THE EXPRESS WRITTEN PERMISSION OF BEECH DESIGN AND BUILD LIMITED.

LIGHT WELL NOTES

CONTRACTOR TO CONFIRM MEASUREMENTS ON SITE BEFORE ANY PRODUCT ORDERS TAKE PLACE

TO BE READ IN CONJUNCTION WITH BUILDERSWORK DRAWINGS SERIES (36) AND (30)

TO BE READ IN CONJUNCTION WITH DRAWINGS SERIES (27) AND (31)

A ISSUED FOR TENDER NP 14-05-21

Rev Description By Date

MANCHESTER
design+build

CLIENT:

PICCADILLY WAREHOUSE

PROJECT:

BLOOMSTREET
SKY WELL
ARRANGEMENT

DRAWING TITLE

INFORMATION

DRAWING STATUS

DRAWN: NP CHECKED: NP

SCALE: As indicated DATE: 21.04.21

013-MDB-BS-XX-DR-A-3700 A

DRAWING NUMBER REV

(A3)