


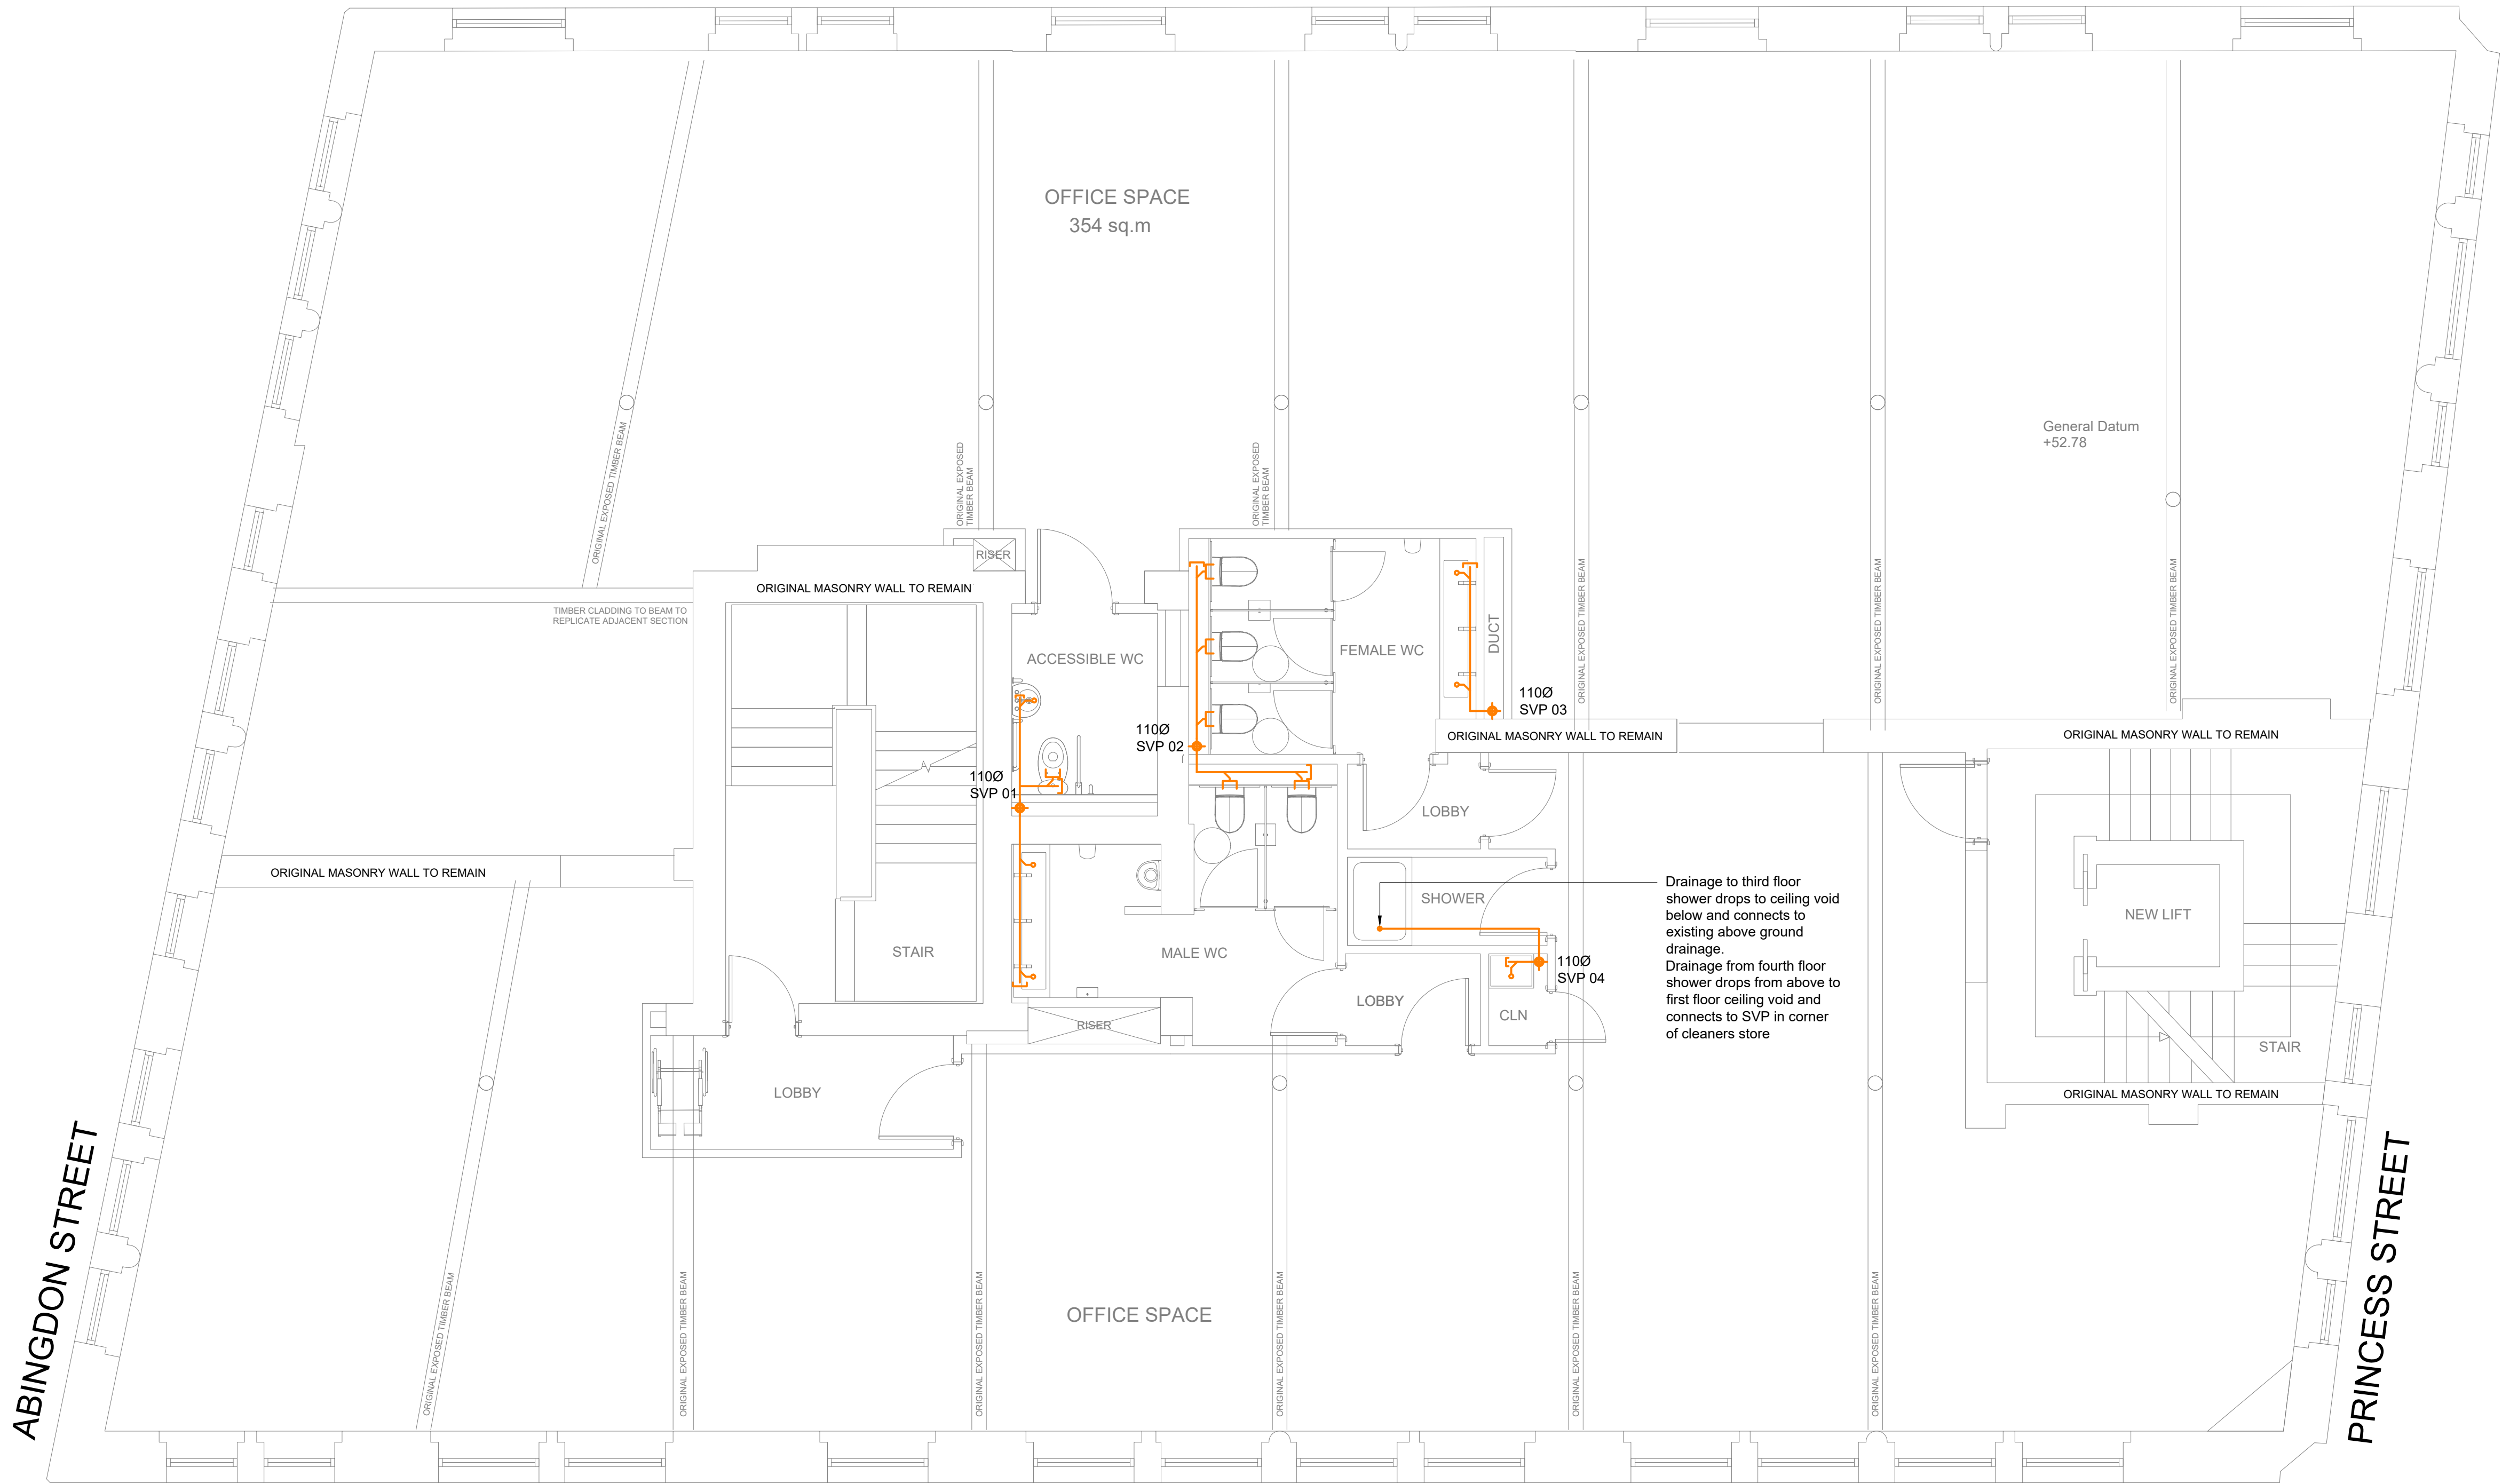

P1	21.09.21	Preliminary Issue	SM	PW	SRH
Rev	Date	Description	By	Check	App.

COPYRIGHT: THE COPYRIGHT OF THIS DRAWING IS VESTED IN CLANCY CONSULTING.
IT SHALL NOT BE USED WITHOUT PERMISSION BY ANYONE FOR ANY PURPOSE.
DO NOT SCALE THIS DRAWING ELECTRONICALLY OR MANUALLY.
WORK TO FIGURED DIMENSIONS ONLY.
ALL DIMENSIONS ARE IN MILLIMETRES UNLESS STATED OTHERWISE.
DO NOT TURN ON LAYERS THAT HAVE BEEN TURNED OFF.
DO NOT TURN OFF LAYERS THAT HAVE BEEN TURNED ON.
DRAWING MUST BE PRINTED IN BLACK AND WHITE ONLY.

Client	Lapwine Ltd
Project	105 Princess Street Manchester
Office	Altrincham
Discipline	Mechanical
Title	Indicative Third Floor Above Ground Drainage Layout
Scale @ A1	1:50
Status	Preliminary



www.clancy.co.uk

Project No.	Originator	Building/Zone	Level
7_7478	CCL	XX	03
Type	Discipline	Drawing No.	Revision
DR	M	200404	P1

Birmingham 0121 259 7800 © Lapwine 0161 616 8800 Newcastle 0191 222 0702 Norwich 01603 365300 Preston 07592 470316 Reading 0118 941 7888