

Job No. PA1484	Drawing No. VMM-TCE-XX-05-DR-M-57002	Rev C1
-------------------	---	-----------


COPYRIGHT:
The copyright of this drawing is vested in TACE. It shall not be used or reproduced without permission for any purpose.

Do NOT scale from this drawing, work only to figured dimensions.
All dimensions in millimetres unless otherwise stated.

This drawing has been created electronically, do not modify by hand.

Notes

1. This layout shall be read in conjunction with all other services, architectural and structural information, project specifications and contract documentation.

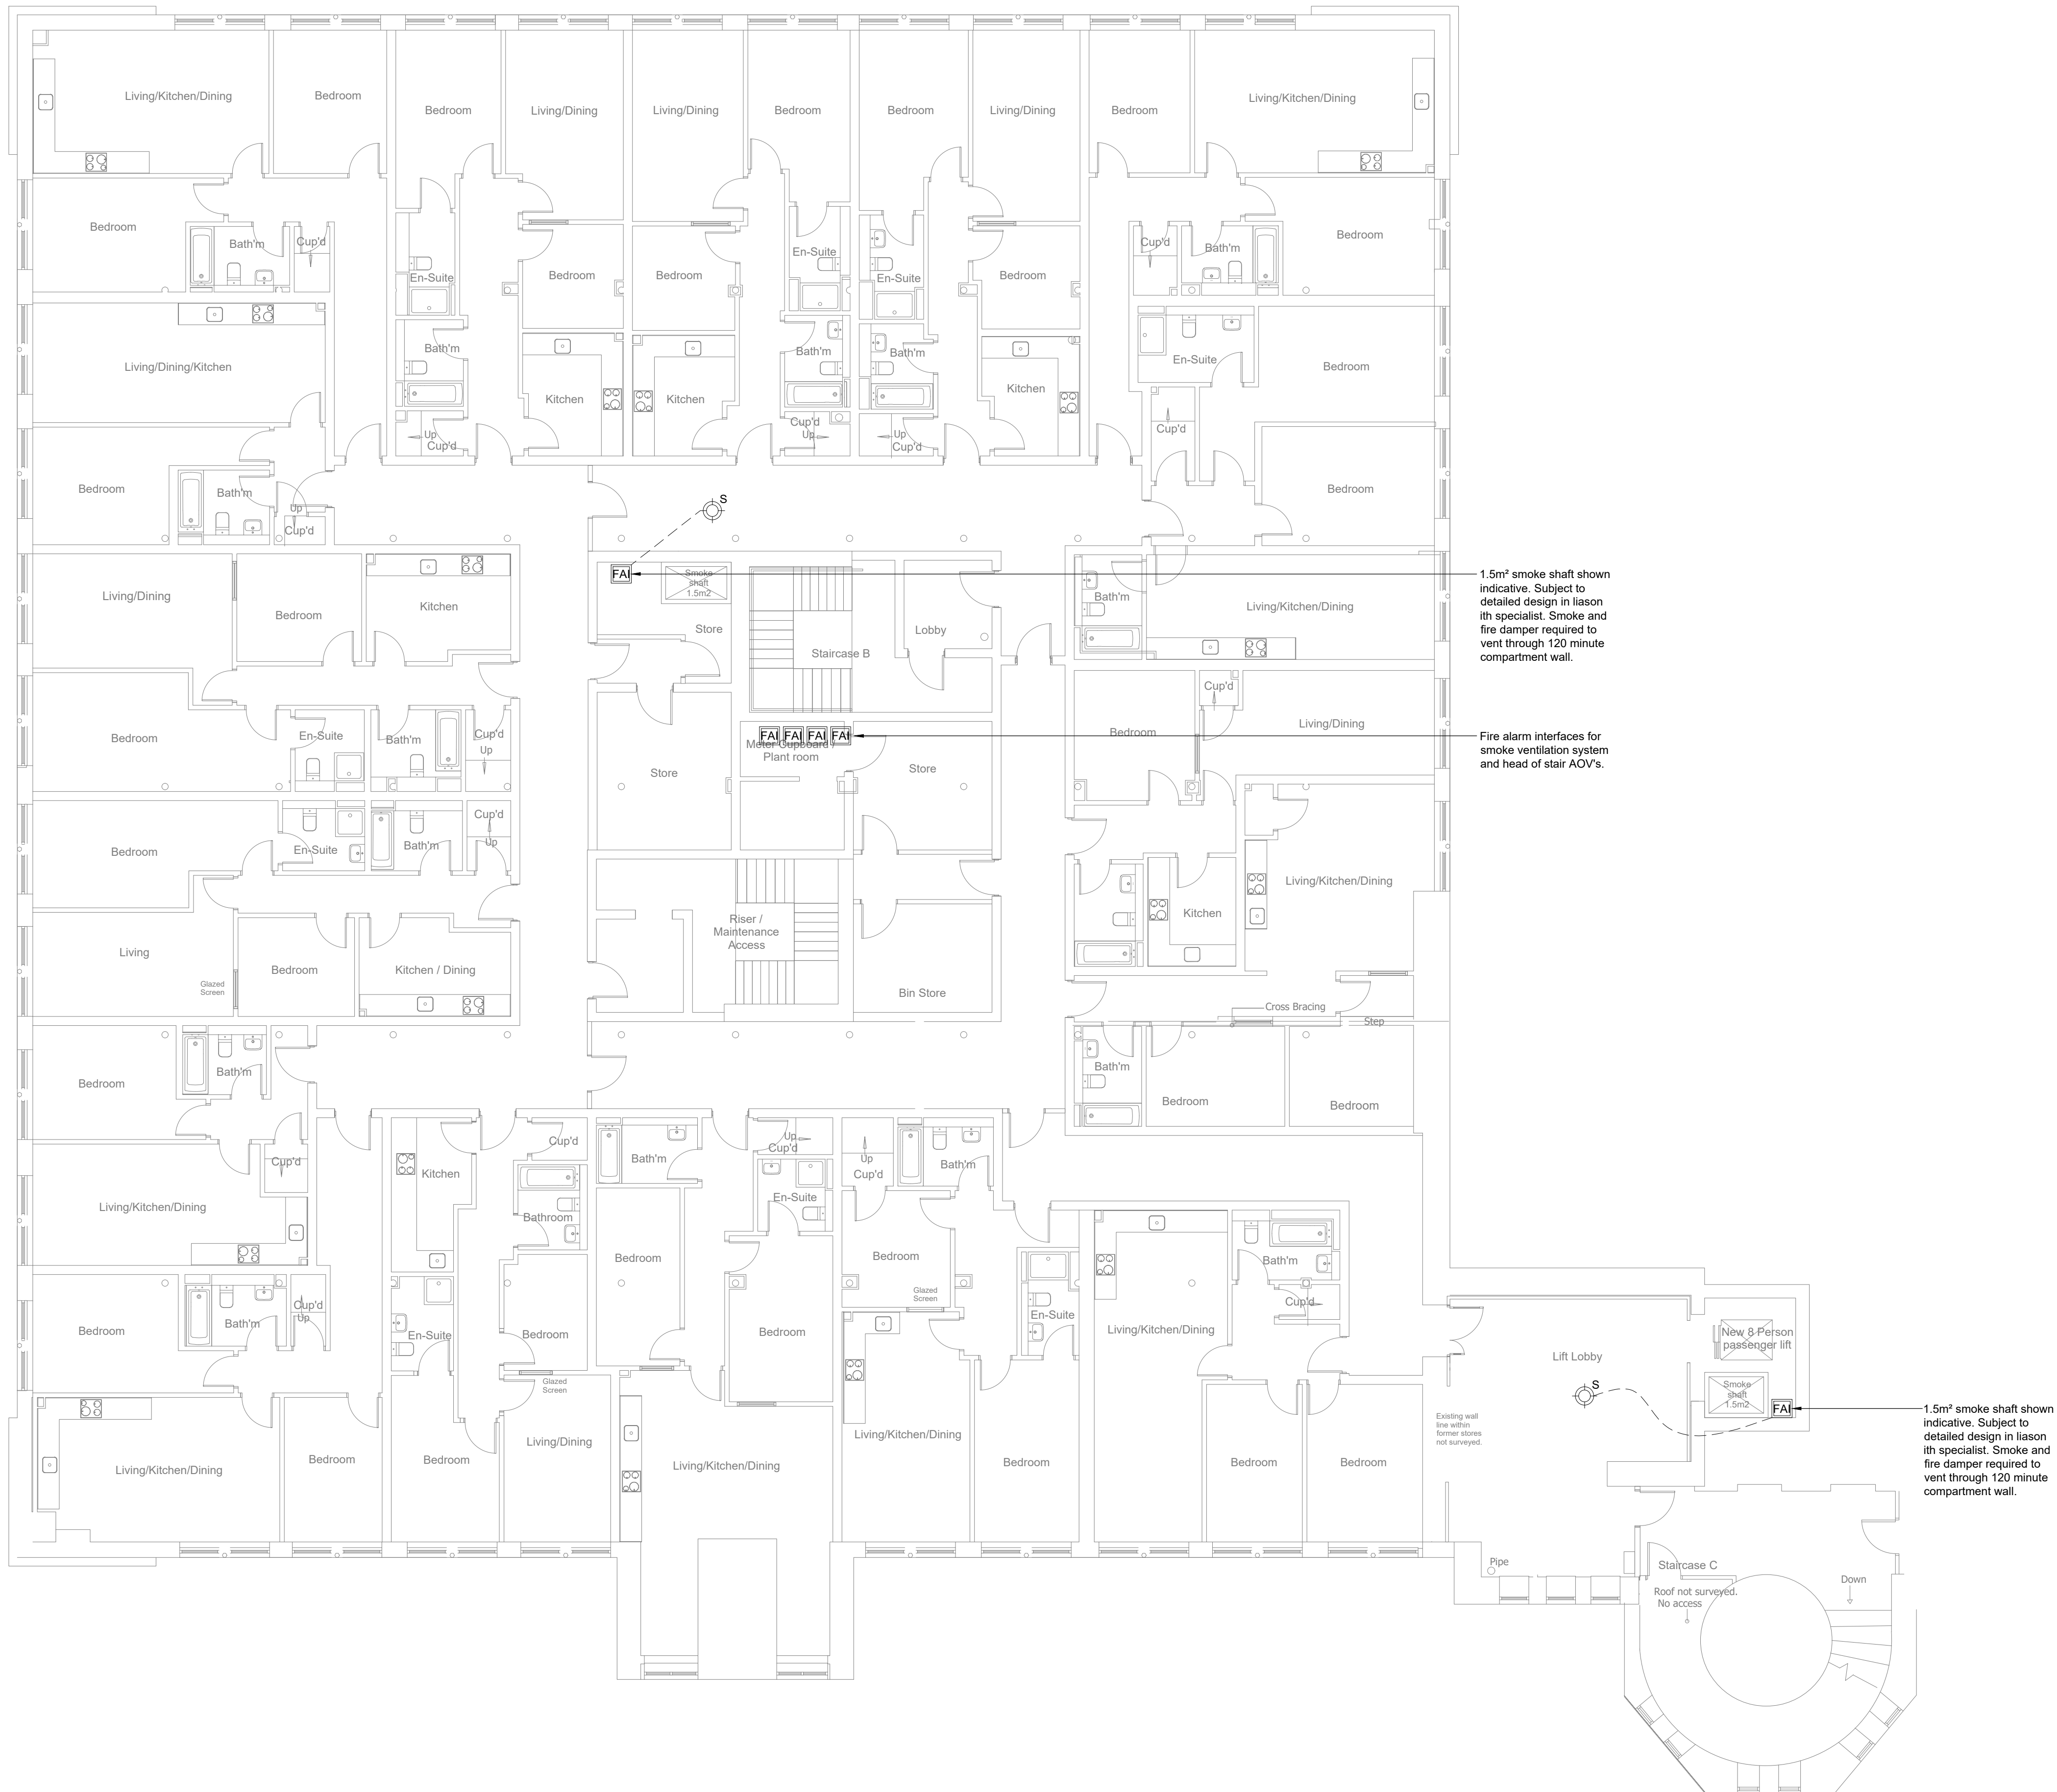

C1	NG	19.03.21	Contract Issue.
P1	NG	26.02.21	Preliminary Issue.
Rev	By	Date	Description



TACE®

THE ASSOCIATES CONSULTING ENGINEERS
Portland House
Stanley Green Business Park
Oak Green
Cheddle Hulme
Cheshire
SK8 6QL
T. 0161 486 0429
F. 0161 486 0488
E. info@tace.co.uk
W. www.tace.co.uk

Client

RFP Advisory Group

Project

Victoria Mill, Manchester

Drawing Title

Proposed Smoke Ventilation Layout Level 05

Drawn EI	Date 26.02.21	Cwd File VMM-TCE-XX-05-DR-M-57002	
Checked NG	Date 26.02.21	External Ref. -	
Approved NG	Date 26.02.21	Scale 1:100 at A1	Issue Status --
Job No. PA1484	Drawing No. VMM-TCE-XX-05-DR-M-57002	Rev C1	