

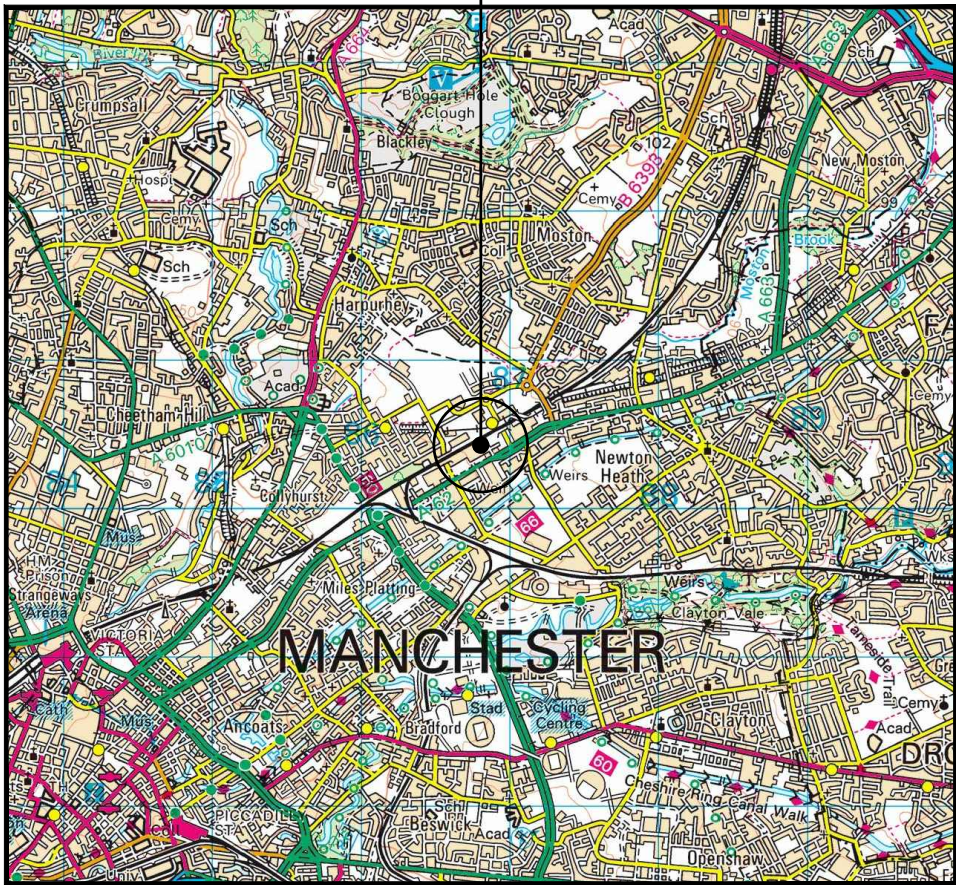
 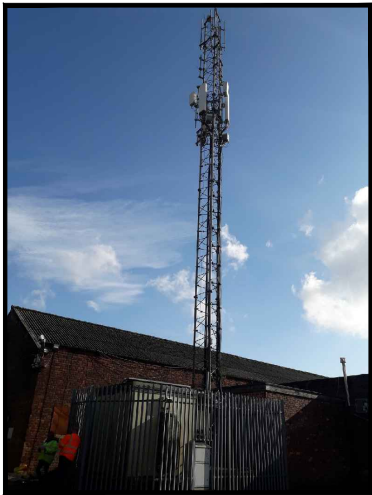
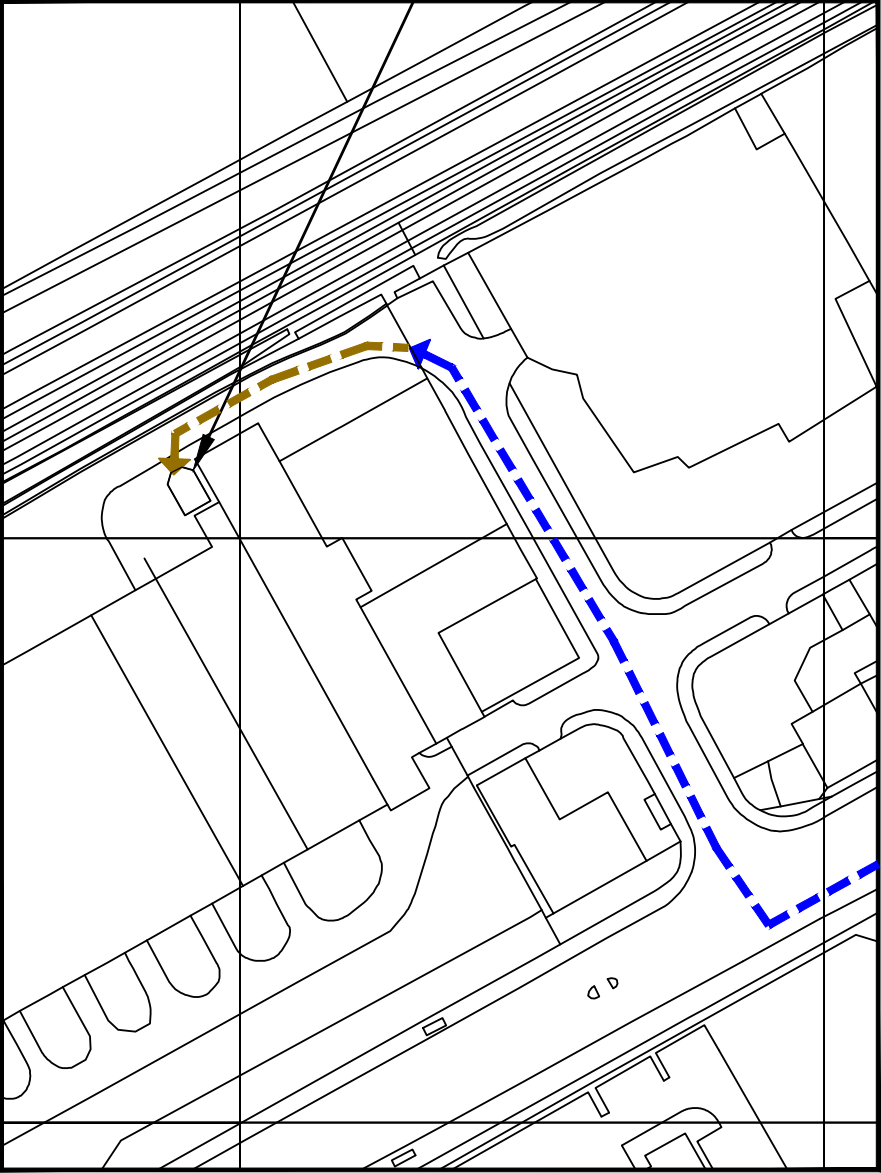


SITE LOCATION
(Scale 1:50000)
Ordnance Survey map extract
based upon Landranger map series
with the permission of the controller of
Her Majesty's Stationery Office
Licence No. 100022432
Crown copyright.

 


SITE PHOTOGRAPH

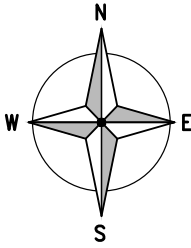

DETAILED SITE LOCATION
(Scale 1:1250)

Based upon Ordnance Survey map extract
with the permission of the Controller of
Her Majesty's Stationery Office.
Crown copyright.
Licence No. 100022432



SCALE 1:1250

ALL DIMENSIONS ARE IN mm UNLESS NOTED OTHERWISE

N.G.R. E: 386792 N: 400407

DIRECTIONS TO SITE:
LEAVE M60 AT J22 TAKE A62 EXIT TO M'CR
CITY CENTRE KEEP LEFT AT FORK AND
MERGE ONTO MANCHESTER RD/A62, FOLLOW
A62 TURN RIGHT ONTO BALTIMORE ST, TURN
LEFT AT THE END OF THE STREET THE SITE
IS ON THE LEFT BEHIND THE INDUSTRIAL
UNITS

NOTES:

A	Issued for Approval	DP	MC	30.10.20
REV	MODIFICATION	BY	CH	DATE

CLARKE telecom
Unit E, Madison Place, Northampton Road,
Manchester, M40 5AG
Tel: 0161 785 4500
Fax: 0161 785 4501
Web: www.clarke-telecom.com

O₂
CORNERSTONE - BEACON 3 UNWIND

Cell Name	Opt.
LLOYDS WAREHOUSING	—

Cell ID No		
CORNERSTONE	TEF	VF
122321_31 E305079	092555	3398

Site Address / Contact Details		
LLOYDS WAREHOUSING HOLT STREET NEWTON HEATH GREATER MANCHESTER M40 5AP		


Drawing Title: SITE LOCATION MAPS

Purpose of issue:	PLANNING	Dwg Rev:
-------------------	----------	----------

Drawing Number:	100	A
-----------------	-----	---

Surveyed By:	SBB	Original Sheet Size:	A3	Pack Issue:
--------------	-----	----------------------	----	-------------

Drawn:	DP	Date:	30.10.20	Checked:	MC	Date:	30.10.20	C
--------	----	-------	----------	----------	----	-------	----------	---

 

CLARKE
telecom

Unit E, Madison Place, Northampton Road,
Manchester, M40 5AG
Tel: 0161 785 4500
Fax: 0161 785 4501
Web: www.clarke-telecom.com

CORNERSTONE - BEACON 3 UNWIND

Address / Contact Details

LLOYDS WAREHOUSING
HOLT STREET
NEWTON HEATH
GREATER MANCHESTER
M40 5AP

G SITE PLAN

PLANNING

Original Sheet Size:

Date: 7-10-00



(1:100)

 **CLARKE**
telecom

Unit E, Madison Place, Northampton Road,
Manchester, M40 5AG
Tel: 0161 785 4500
Fax: 0161 785 4501
Web: www.clarke-telecom.com

 σ_2

CORNERSTONE - BEACON 3 UNWIND

Cell Name	Opt.
LLOYDS WAREHOUSING	-

Cell ID No		
CORNERSTONE	TEF	VF

122321_31 E305079	092555	3398
----------------------	--------	------

LLOYDS WAREHOUSING
HOLT STREET
NEWTON HEATH
GREATER MANCHESTER
M40 5AP

Drawing Title: PROPOSED SITE PLAN

Purpose of issue:	PLANNING	Dwg Rev:
-------------------	----------	-------------

Drawing Number:	201	B
-----------------	-----	---

Surveyed By:	SBB		Original Sheet Size:		A3	Pack
Drawn:	DP	Date:	30.10.20	Checked:	MC	Date:
						30.10.20
						C

ALL DIMENSIONS ARE IN mm UNLESS NOTED OTHERWISE

N.G.R E: 386792 N: 400407

NOTES:

C	Existing GPS added	DP	MC	04.03.21	
B	Existing VF dish added	DP	MC	05.02.21	
A	Issued for Approval	DP	MC	30.10.20	
REV	MODIFICATION	BY	CH	DATE	

CLARKE

telecom

Unit E, Madison Place, Northampton Road,
Manchester, M40 5AG
Tel: 0161 785 4500
Fax: 0161 785 4501
Web: www.clarke-telecom.com

O₂

CORNERSTONE - BEACON 3 UNWIND

Cell Name		Opt.
LLOYDS WAREHOUSING		—
Cell ID No		
CORNERSTONE	TEF	VF
122321_31	092555	3398
E305079		
Site Address / Contact Details		

Drawing Title: EXISTING SITE ELEVATION			
Purpose of issue:		PLANNING	
Drawing Number:		300	
Surveyed By: SBB		Original Sheet Size: A3	
Drawn: DP	Date: 30.10.20	Checked: MC	Date: 30.10.20
		C	

EXISTING SOUTH WEST ELEVATION
(1:125)

EXISTING 1No. VF DISH (D1) FIXED TO HEADFRAME

C/L OF EXISTING VF DISH (D1)
+26.0m AGL

TOP OF EXISTING VF ANTENNAS
+19.5m AGL

U/S OF EXISTING VF ANTENNAS
+18.6m AGL

U/S OF EXISTING VF ANTENNAS
+17.5m AGL

EXISTING GPS ANTENNA FIXED TO ANTENNA POLE

EXISTING 6No. VF ANTENNAS FIXED TO SUPPORT POLES ON YOKE BRACKET

EXISTING 6No. VF RRU's MOUNTED ON OFFSET BRACKETS AND POLES

EXISTING VF 26.0m HIGH ADC 1003UP LATTICE TOWER ON SHARED CONCRETE BASE.

TREE HEIGHT
+10.0m AGL

ROOF HEIGHT
+8.0m AGL

VF 450 WIDE CABLE LADDER

CABLE TRAY ON CABIN ROOF

VF EQUIPMENT CABIN ON SHARED CONCRETE BASE


2.4m HIGH PALISADE FENCE C/W 1.0m ACCESS GATE

G.L.

REDUNDANT OLO METER CABINET ON CONCRETE BASE WITHIN FENCE LINE

VF METER CABINET ON SHARED CONCRETE BASE (BEHIND)

ALL DIMENSIONS ARE IN mm UNLESS NOTED OTHERWISE									
N.G.R		E: 386792		N: 400407					
NOTES:									
C	Headframe added, VF antennas raised			DP	MC	04.03.21			
B	Tower swapped and dishes added			DP	MC	05.02.21			
A	Issued for Approval			DP	MC	30.10.20			
REV	MODIFICATION			BY	CH	DATE			
CLARKE telecom Unit E, Madison Place, Northampton Road, Manchester, M40 5AG Tel: 0161 785 4500 Fax: 0161 785 4501 Web: www.clarke-telecom.com									
O₂ CORNERSTONE - BEACON 3 UNWIND									
Cell Name					Opt.				
LLOYDS WAREHOUSING					-				
Cell ID No									
CORNERSTONE	TEF				VF				
122321_31	092555				3398				
E305079									
Site Address / Contact Details									
LLOYDS WAREHOUSING HOLT STREET NEWTON HEATH GREATER MANCHESTER M40 5AP									
Drawing Title: PROPOSED SITE ELEVATION									
Purpose of issue:					Dwg Rev:				
PLANNING									
Drawing Number:					301				
Surveyed By:				Original Sheet Size:		Pack			
SBB				A3		Issue:			
Drawn:	Date:	Checked:	Date:						
DP	30.10.20	MC	30.10.20	C					

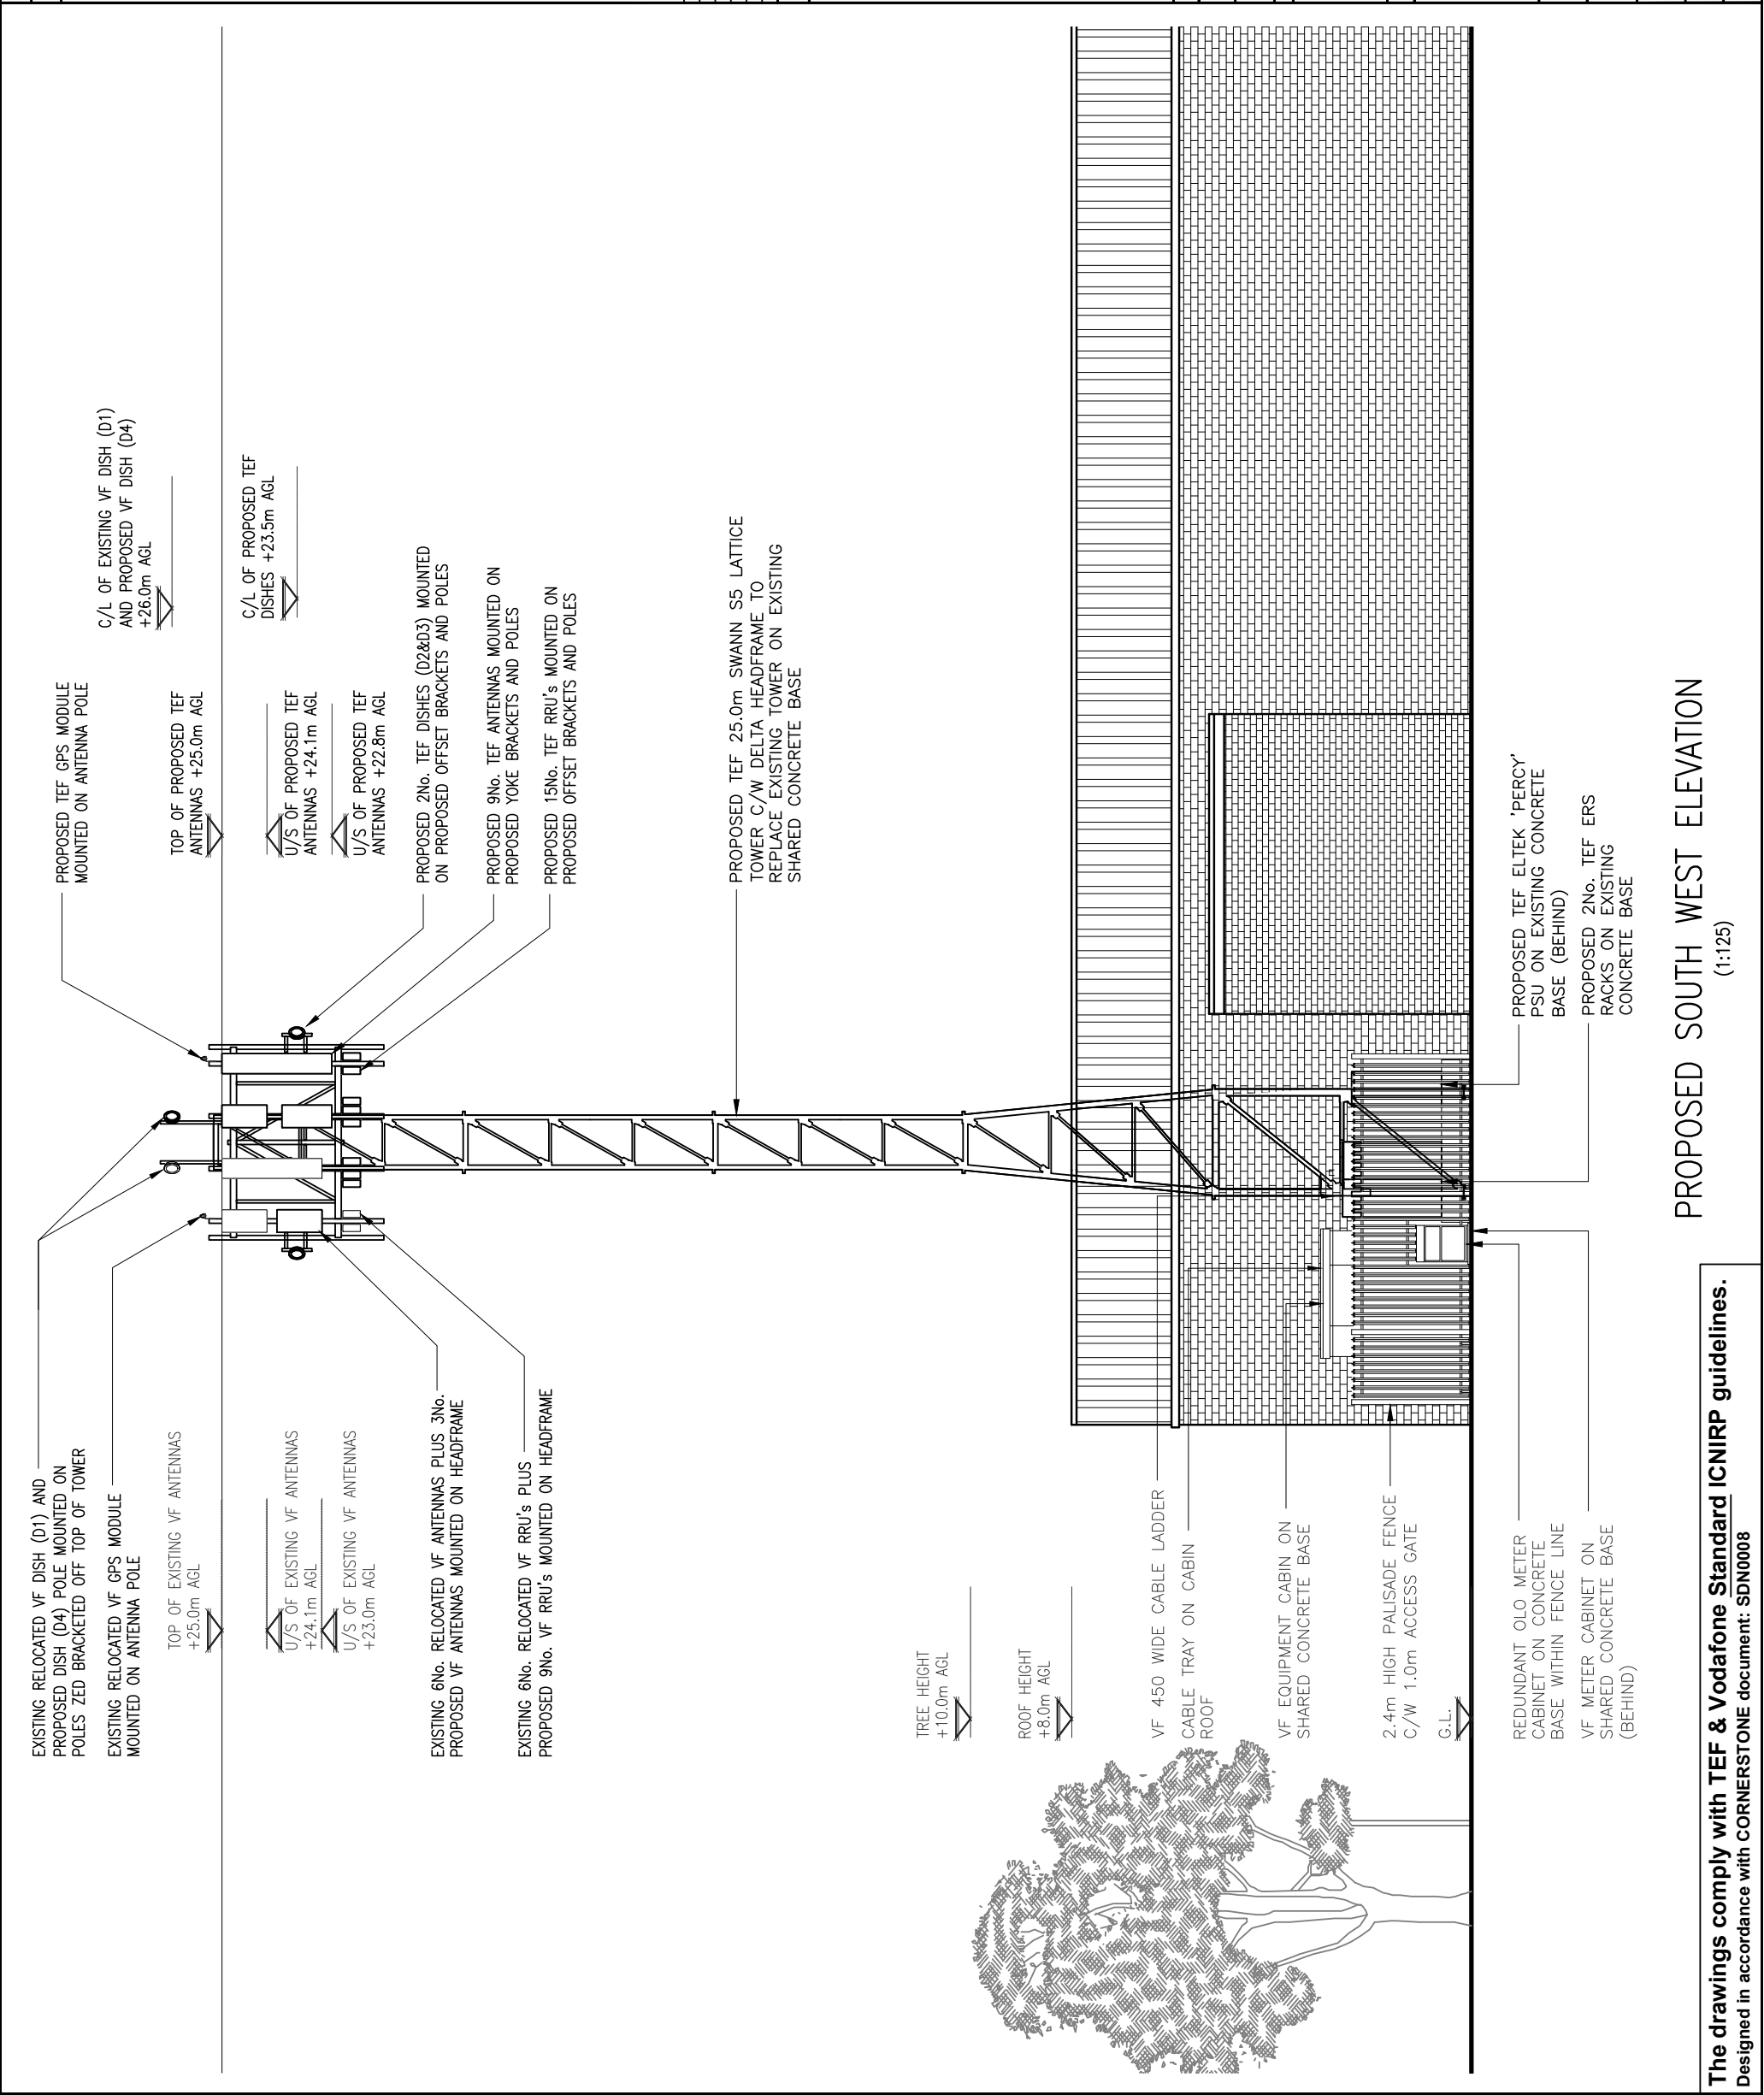

The drawings comply with TEF & Vodafone Standard ICNIRP guidelines.
Designed in accordance with CORNERSTONE document: SDN0008