


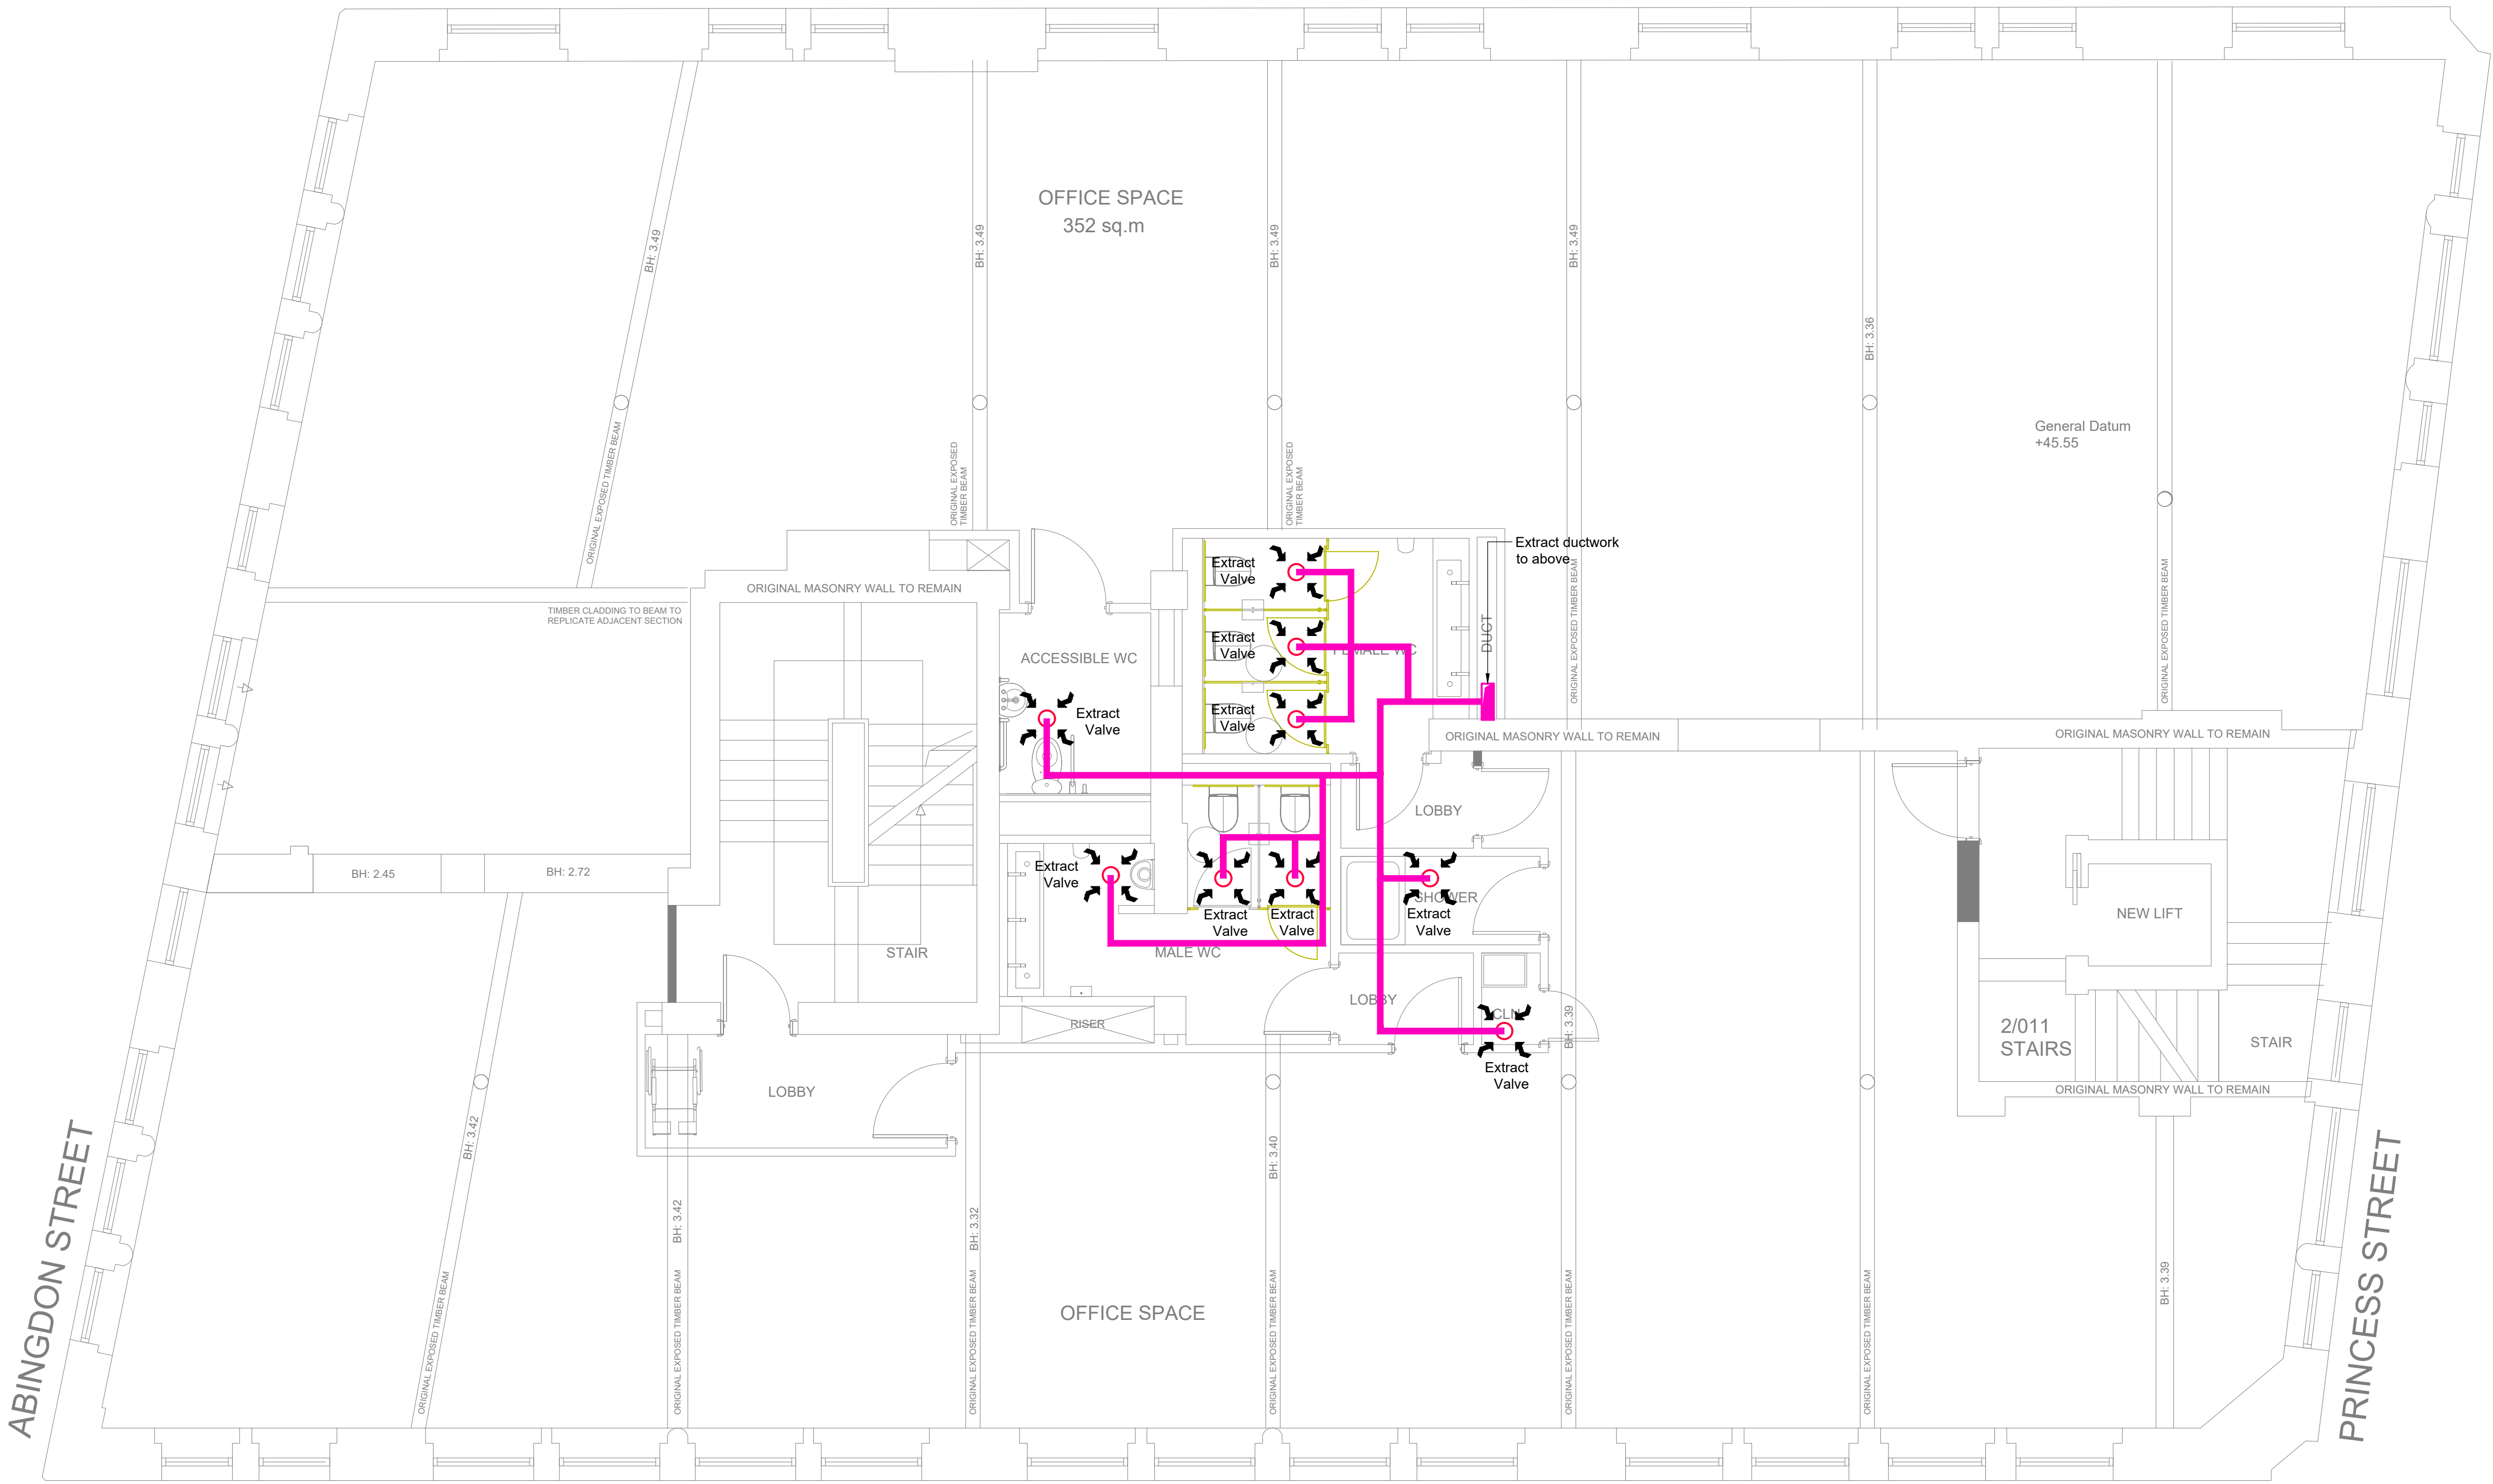

|     |          |                   |    |       |      |
|-----|----------|-------------------|----|-------|------|
| P1  | 21.09.21 | Preliminary Issue | SM | PW    | SRH  |
| Rev | Date     | Description       | By | Check | App. |

COPYRIGHT: THE COPYRIGHT OF THIS DRAWING IS VESTED IN CLANCY CONSULTING.  
IT SHALL NOT BE USED WITHOUT PERMISSION BY ANYONE FOR ANY PURPOSE.  
DO NOT SCALE THIS DRAWING ELECTRONICALLY OR MANUALLY.  
WORK TO FIGURED DIMENSIONS ONLY.  
ALL DIMENSIONS ARE IN MILLIMETRES UNLESS STATED OTHERWISE.  
DO NOT TURN ON LAYERS THAT HAVE BEEN TURNED OFF.  
DO NOT TURN LAYERS THAT HAVE BEEN FROZEN.  
DRAWING MUST BE PRINTED IN BLACK AND WHITE ONLY.

|            |                                               |
|------------|-----------------------------------------------|
| Client     | Lapwine Ltd                                   |
| Project    | 105 Princess Street<br>Manchester             |
| Office     | Altrincham                                    |
| Discipline | Mechanical                                    |
| Title      | Indicative Second Floor<br>Ventilation Layout |
| Scale @ A1 | 1:50                                          |
| Status     | Preliminary                                   |



www.clancy.co.uk

|             |            |               |          |
|-------------|------------|---------------|----------|
| Project No. | Originator | Building/Zone | Level    |
| 7_7478      | CCL        | XX            | 02       |
| Type        | Discipline | Drawing No.   | Revision |
| DR          | M          | 200203        | P1       |