


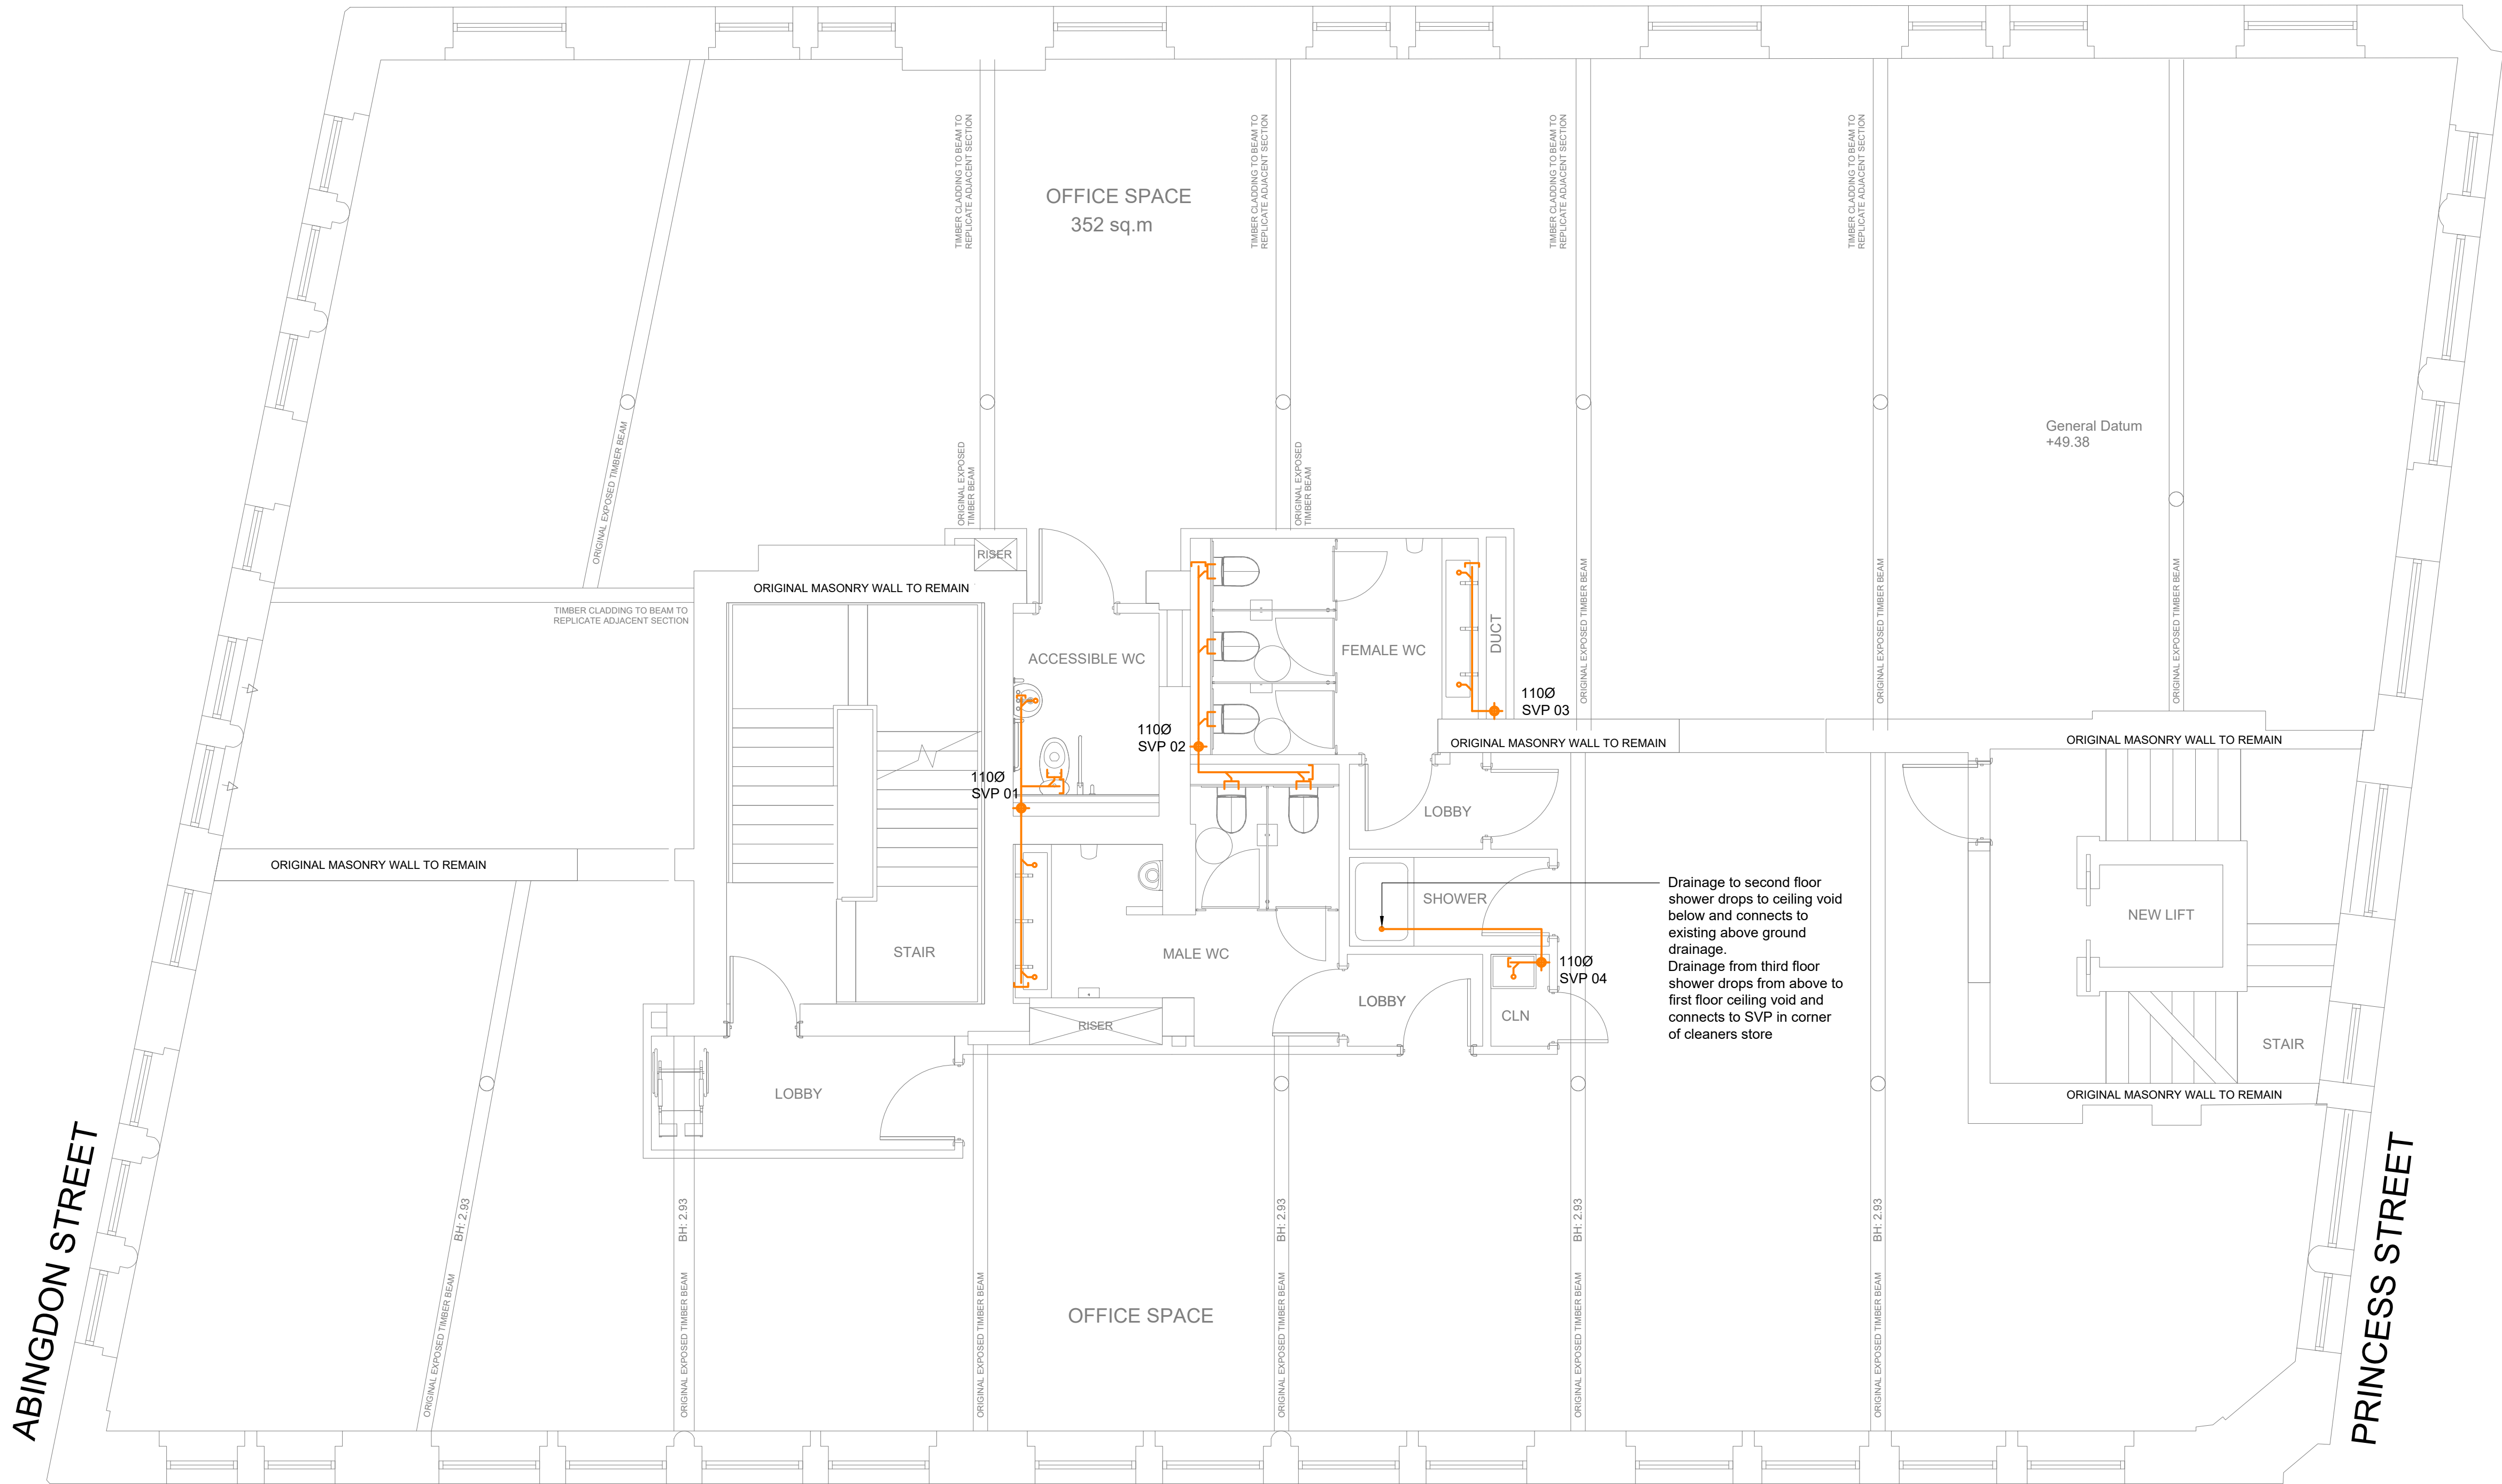

P1	21.09.21	Preliminary Issue	SM	PW	SRH
Rev	Date	Description	By	Check	App.

COPYRIGHT: THE COPYRIGHT OF THIS DRAWING IS VESTED IN CLANCY CONSULTING.
IT SHALL NOT BE USED WITHOUT PERMISSION BY ANYONE FOR ANY PURPOSE.
DO NOT SCALE THIS DRAWING ELECTRONICALLY OR MANUALLY.
WORK TO FIGURED DIMENSIONS ONLY.
ALL DIMENSIONS ARE IN MILLIMETRES UNLESS STATED OTHERWISE.
DO NOT TURN ON LAYERS THAT HAVE BEEN TURNED OFF.
DO NOT TURN LAYERS THAT HAVE BEEN FROZEN.
DRAWING MUST BE PRINTED IN BLACK AND WHITE ONLY.

Client	Lapwine Ltd
Project	105 Princess Street Manchester
Office	Altrincham
Discipline	Mechanical
Title	Indicative Second Floor Above Ground Drainage Layout
Scale @ A1	1:50
Status	Preliminary



www.clancy.co.uk

Project No.	Originator	Building/Zone	Level
7_7478	CCL	XX	02
Type	Discipline	Drawing No.	Revision
DR	M	200403	P1

Birmingham 0121 250 7800, Glasgow 0141 222 1720, Liverpool 0151 227 5900, London 020 3077 0970, Manchester 0161 616 8800, Newcastle 0191 222 0702, Norwich 01603 365000, Preston 07592 470316, Reading 01181 941 7888