

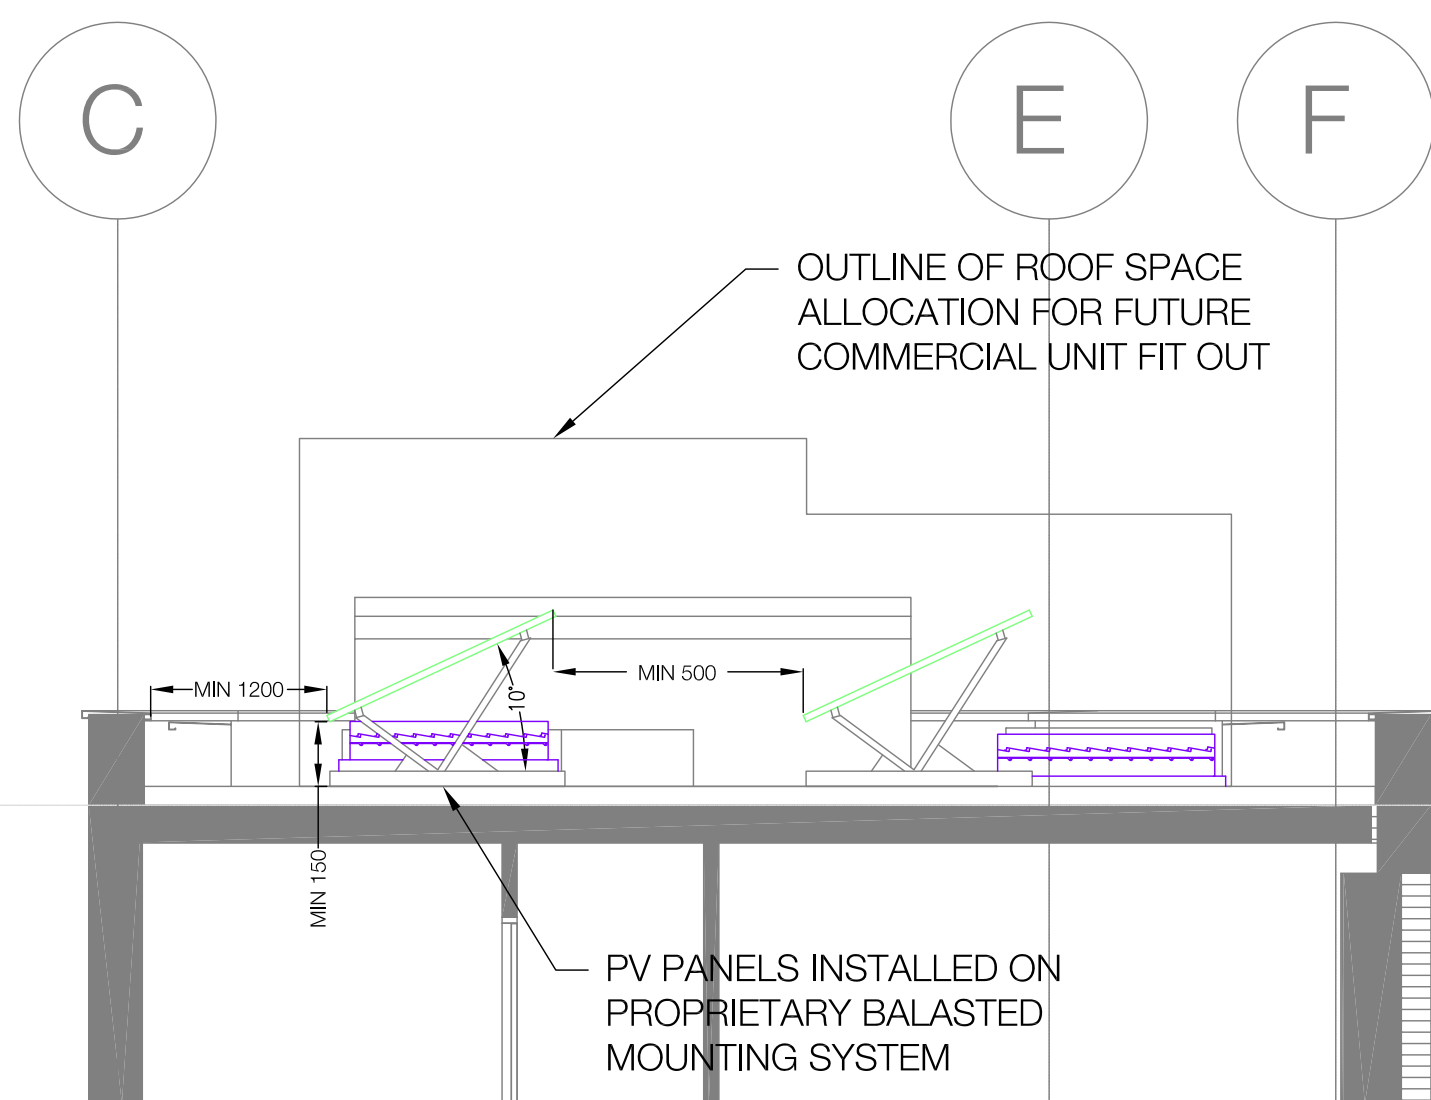


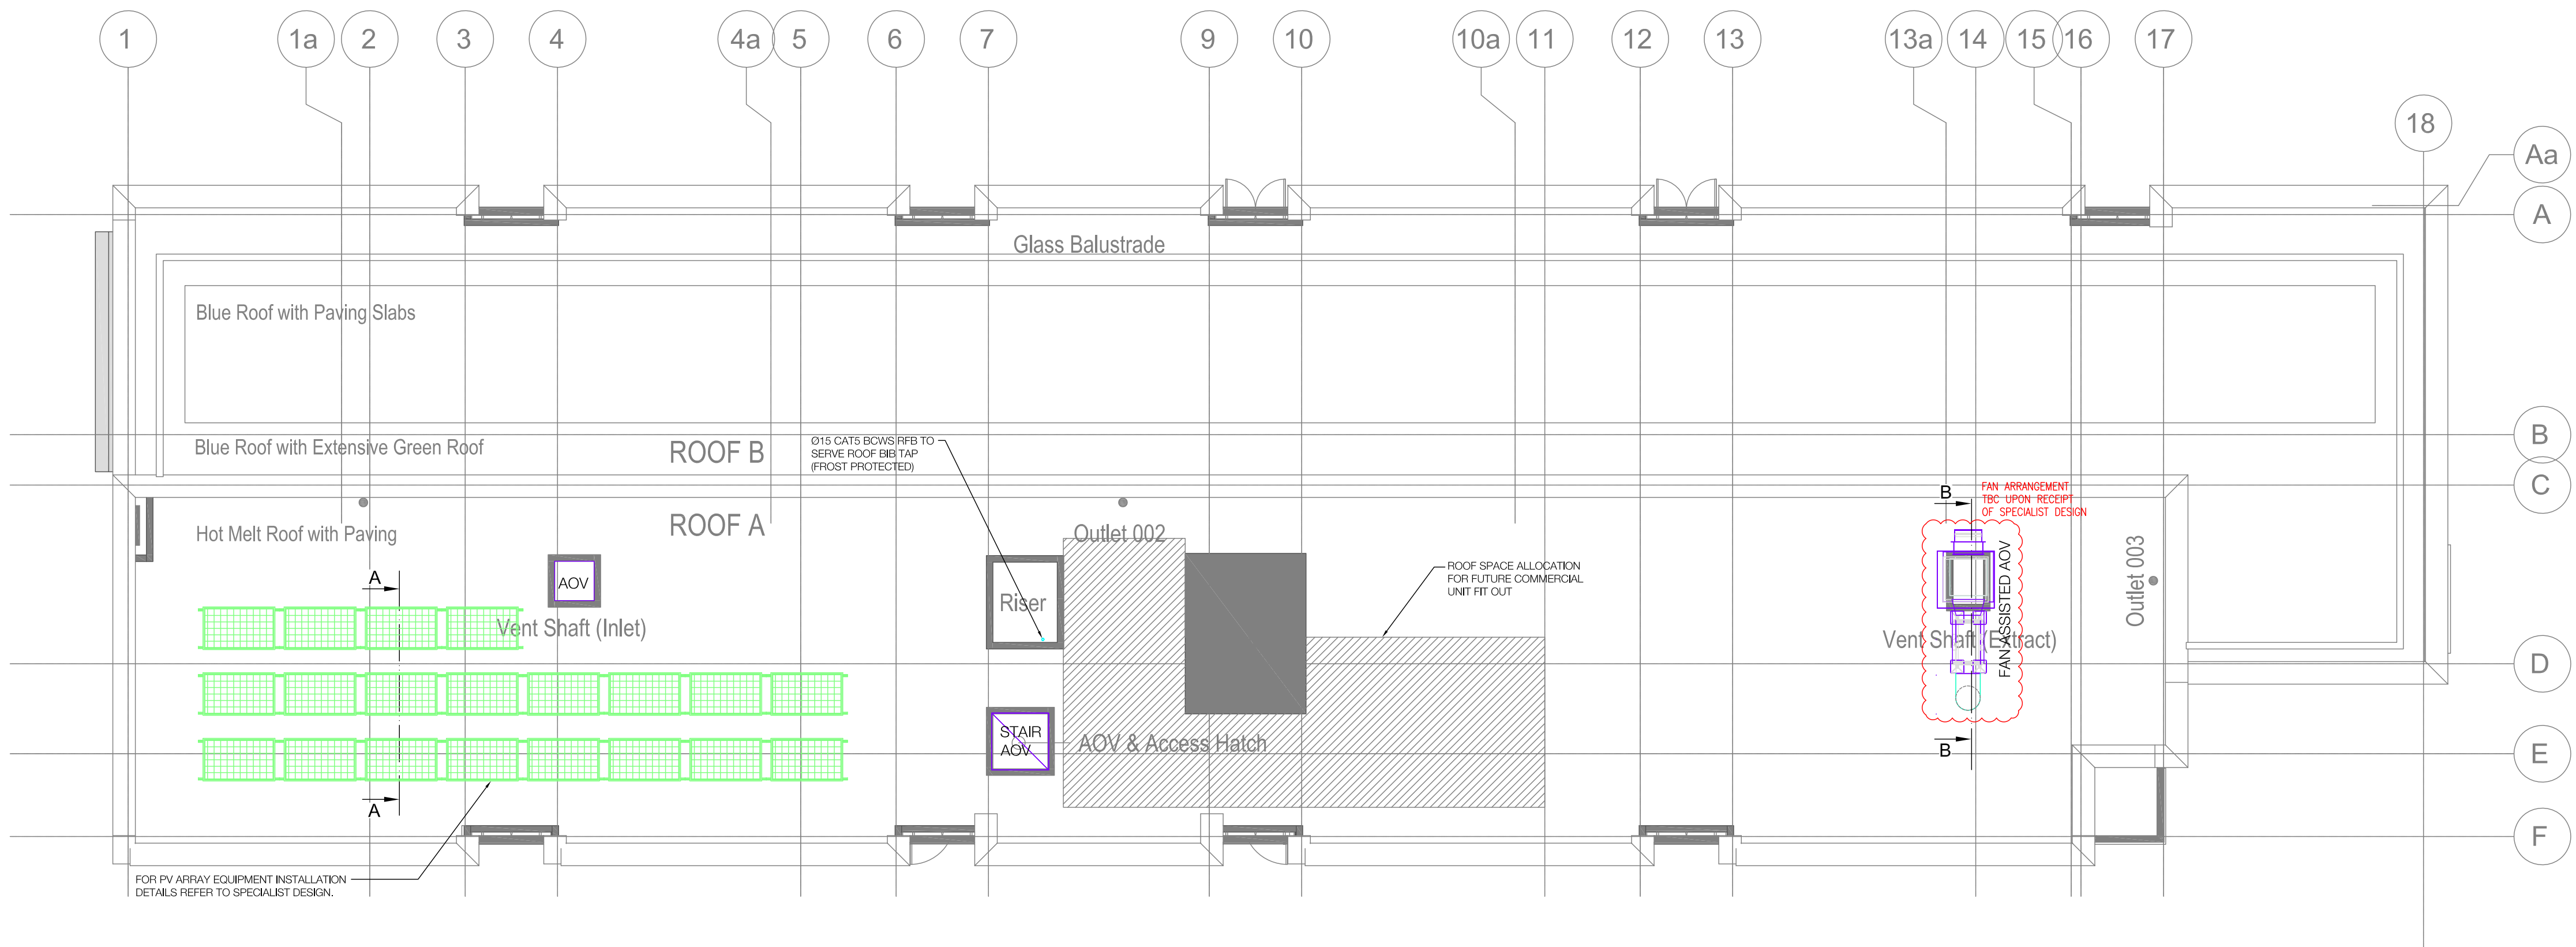

SECTION A-A
Scale 1:50

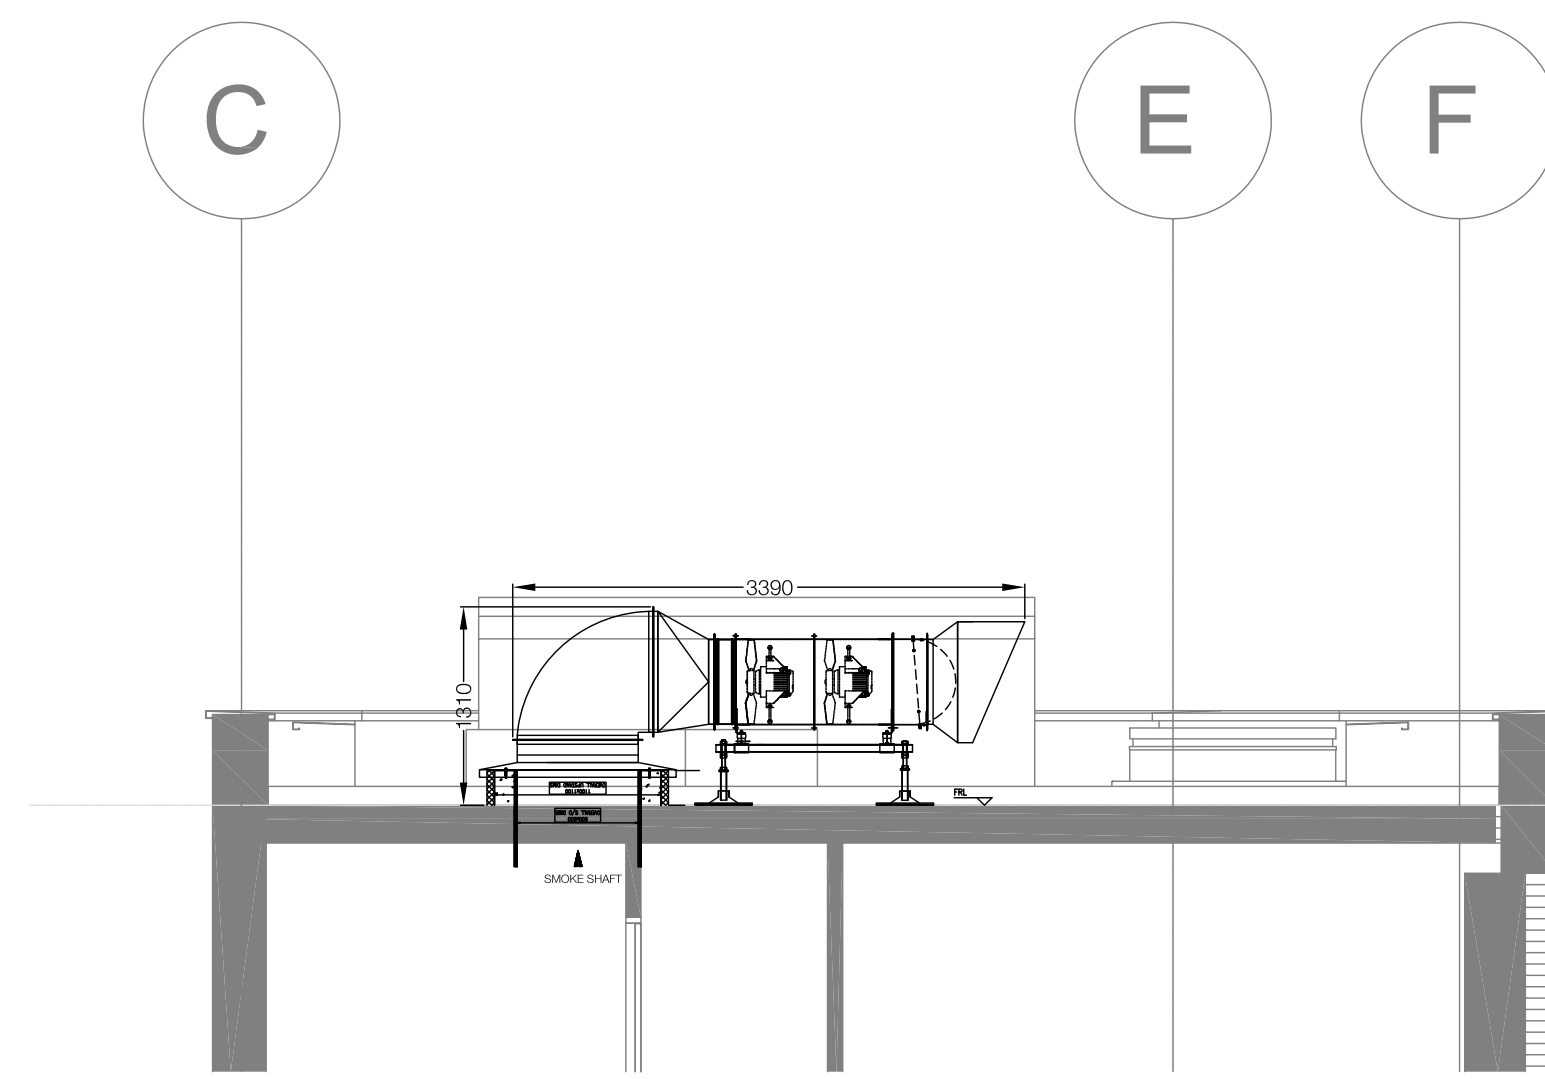

SECTION B-B
Scale 1:50

DESIGNED	MC	05.07.21	DRAWN	MC	05.07.21	APPROVED	-
REV							
C2							PV ARRAY UPDATED
DESIGNED	MC	12.05.21	DRAWN	MC	12.05.21	APPROVED	-
REV							
C1							CONSTRUCTION ISSUE

STATUS: CONSTRUCTION



CLIENT: CANNOCK BUILDING SERVICES

PROJECT: OLDHAM STREET
MANCHESTER

TITLE: MECHANICAL SERVICES
BLOCK B
ROOF PLANT LAYOUT

SCALE:	1:100 @ A1	DATE:	APRIL 2021
DRAWN:	MC	ENGINEER:	MC
CHECKED:		APPROVED:	

20161

BB - M

50 - 02

C2