


REVISIONS

Rev	Date	Description
Rev A:	21/07/21	Plan up-dated to suit comments by Police. DMM

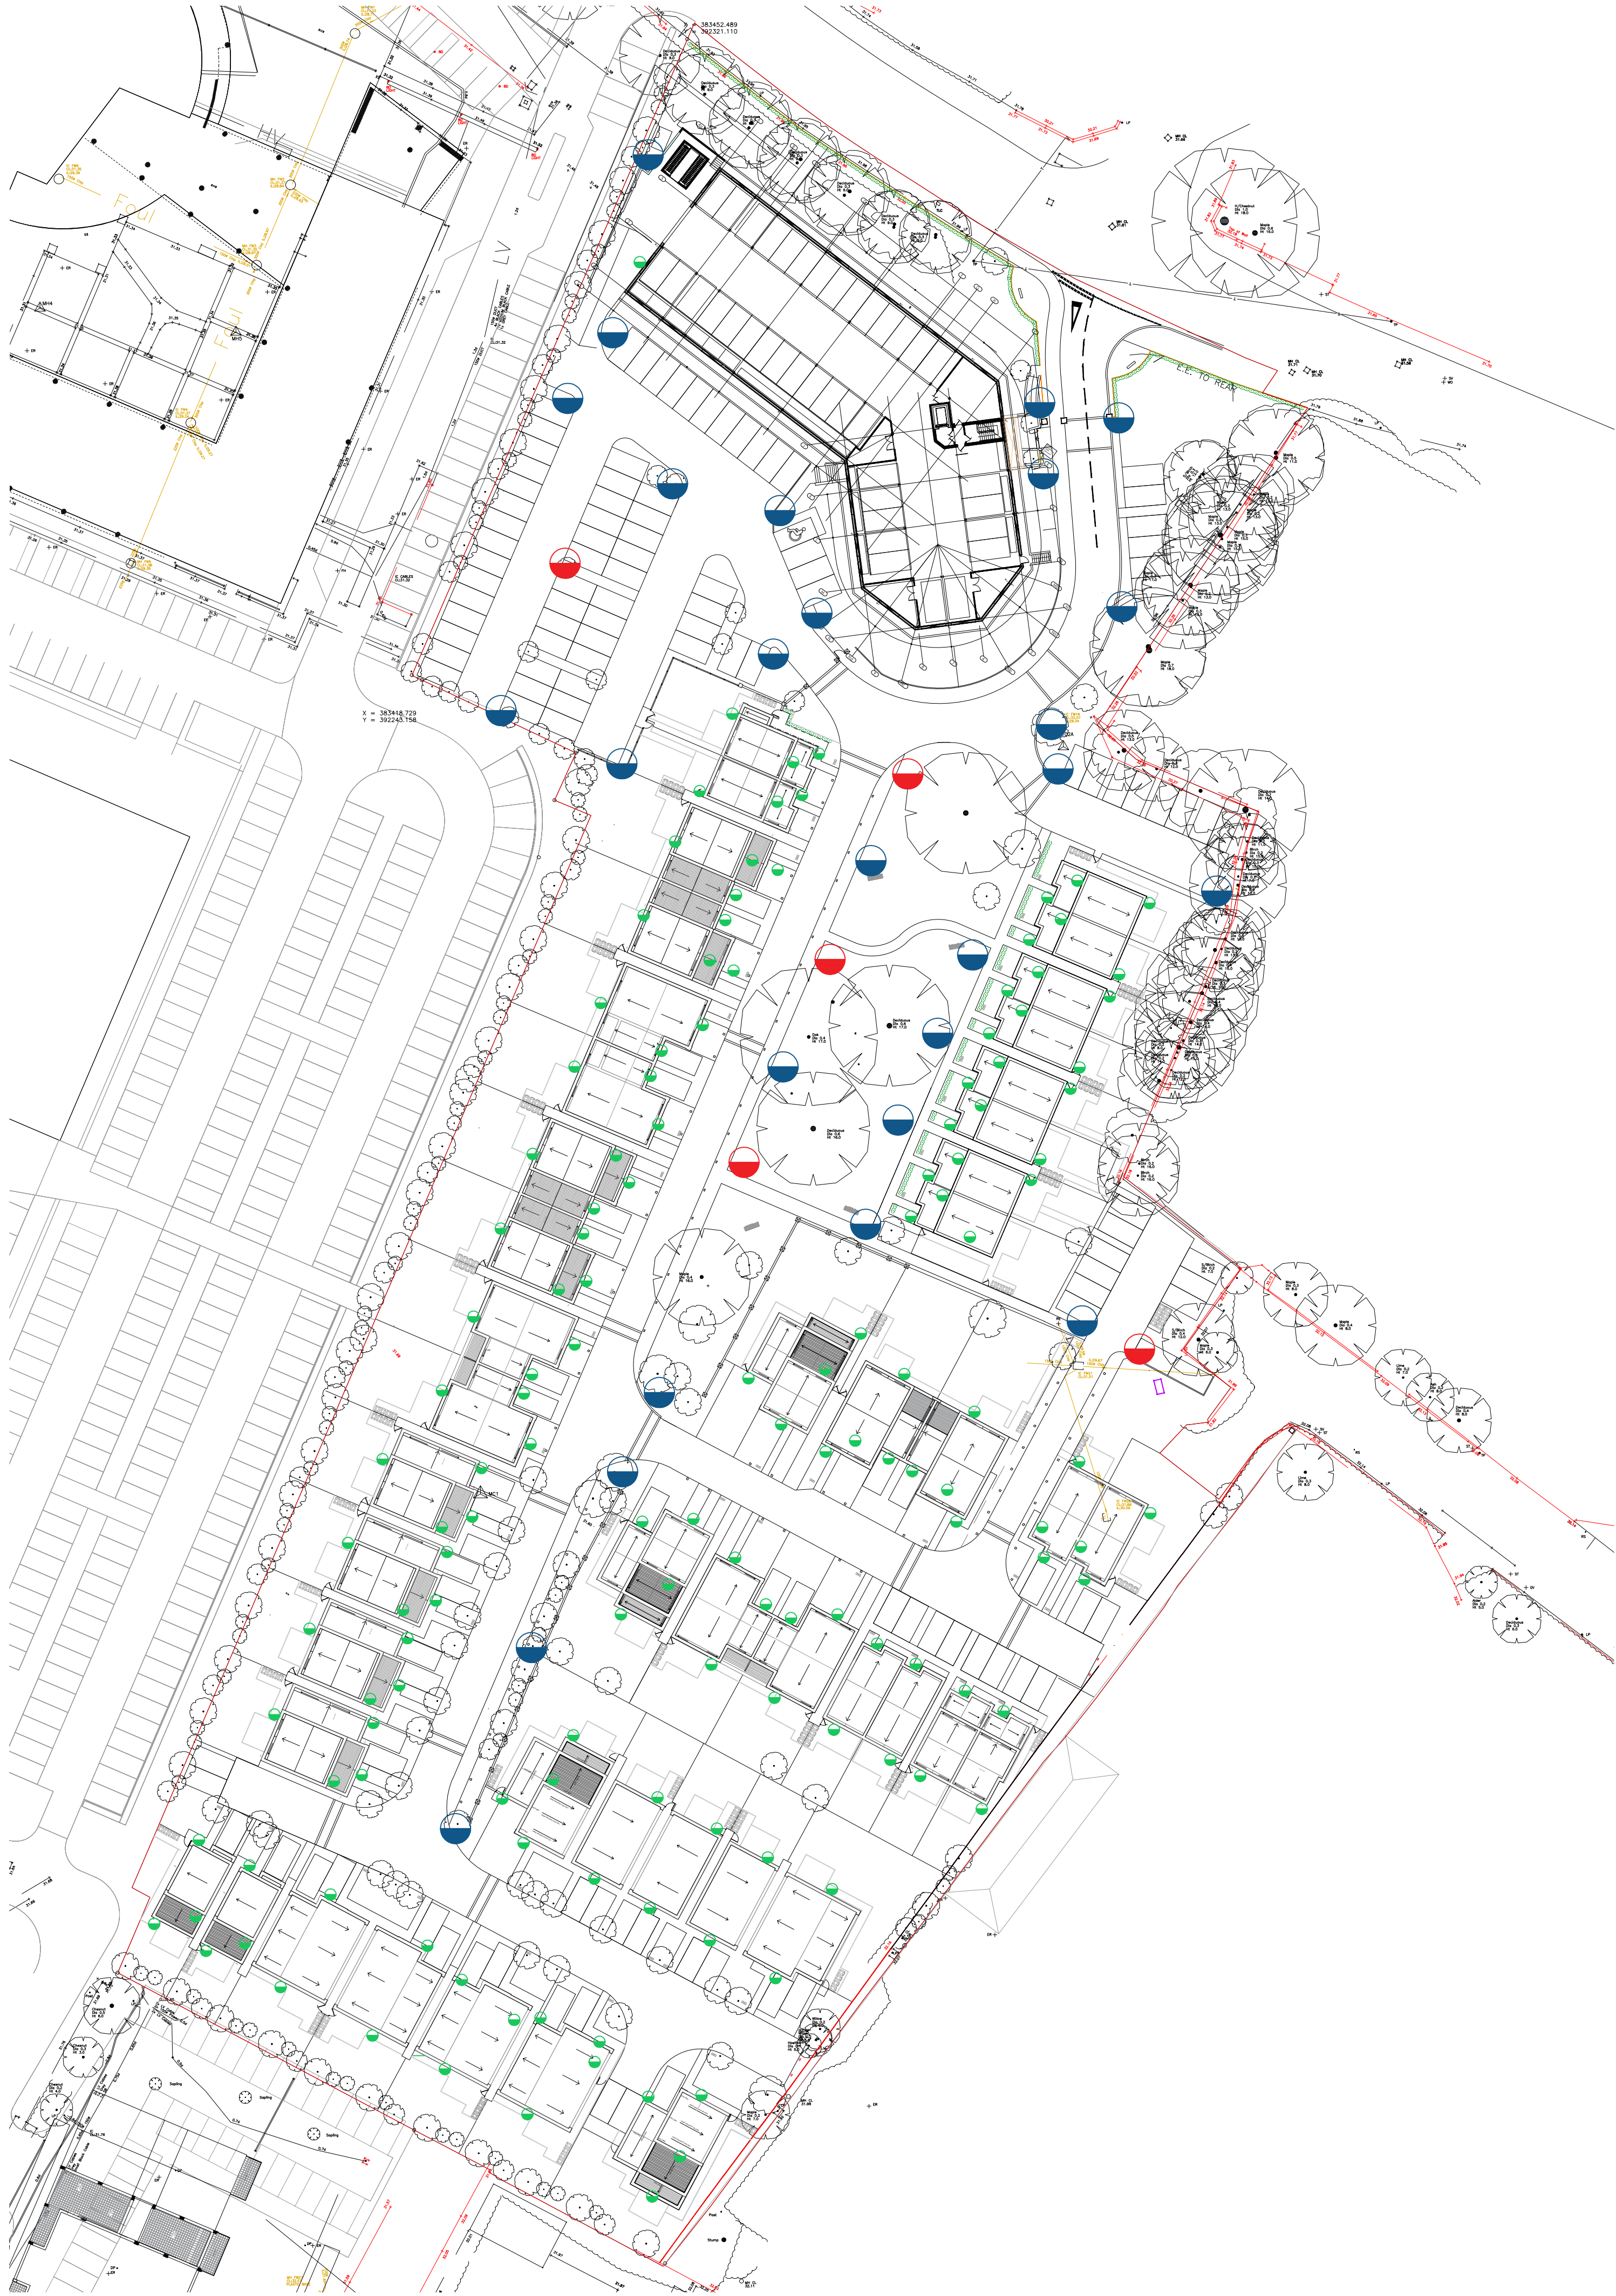

A - Kingfisher,
Tauri Streetlight



B - Kingfisher
Deco Bollard



C - Concord, Scope Wall

KEY	DESCRIPTION	QUANTITY
A	'Tauri' Streetlight from Kingfisher Lighting. 40W LED module column. Height - 3000mm	5
B	'Deco Bollard' from Kingfisher Lighting. 20W LED module bollard luminaire. Height - 1000mm	20
C	'Scope Wall' from Concord. 3.8W LED wall mounted luminaire with downward light ONLY. Wall mounted at circa.1800m AGL. Lights fixed to illuminate entrances and private terraces	Houses: 143 Apt: tbc

WARNING
Critical Dimensions required by Consultants/
Contractors/ Subcontractors must not be scaled
from this drawing. Dimensions required are to be
obtained from the drawing office

Site Plan
Proposed Lighting
Scheme

121-00- 2121/A

Scale 1:500 @A1 Date April 21
Drawn DMM/RW Checked

Siemens
Nell Lane
West Didsbury
Manchester

P.J.Livesey Living Space Ltd
Ashburton Park
Ashburton Road West
Trafford Park
Manchester M17 1AF
Tel : 0161 873 7878
Fax : 0161 873 8185
design@pjlivesey.co.uk

COPYRIGHT
This Drawing may not be used or reproduced in
any way without the written consent of the
P.J.Livesey Group Limited

The P. J. Livesey Group Ltd

www.pjlivesey-group.co.uk