


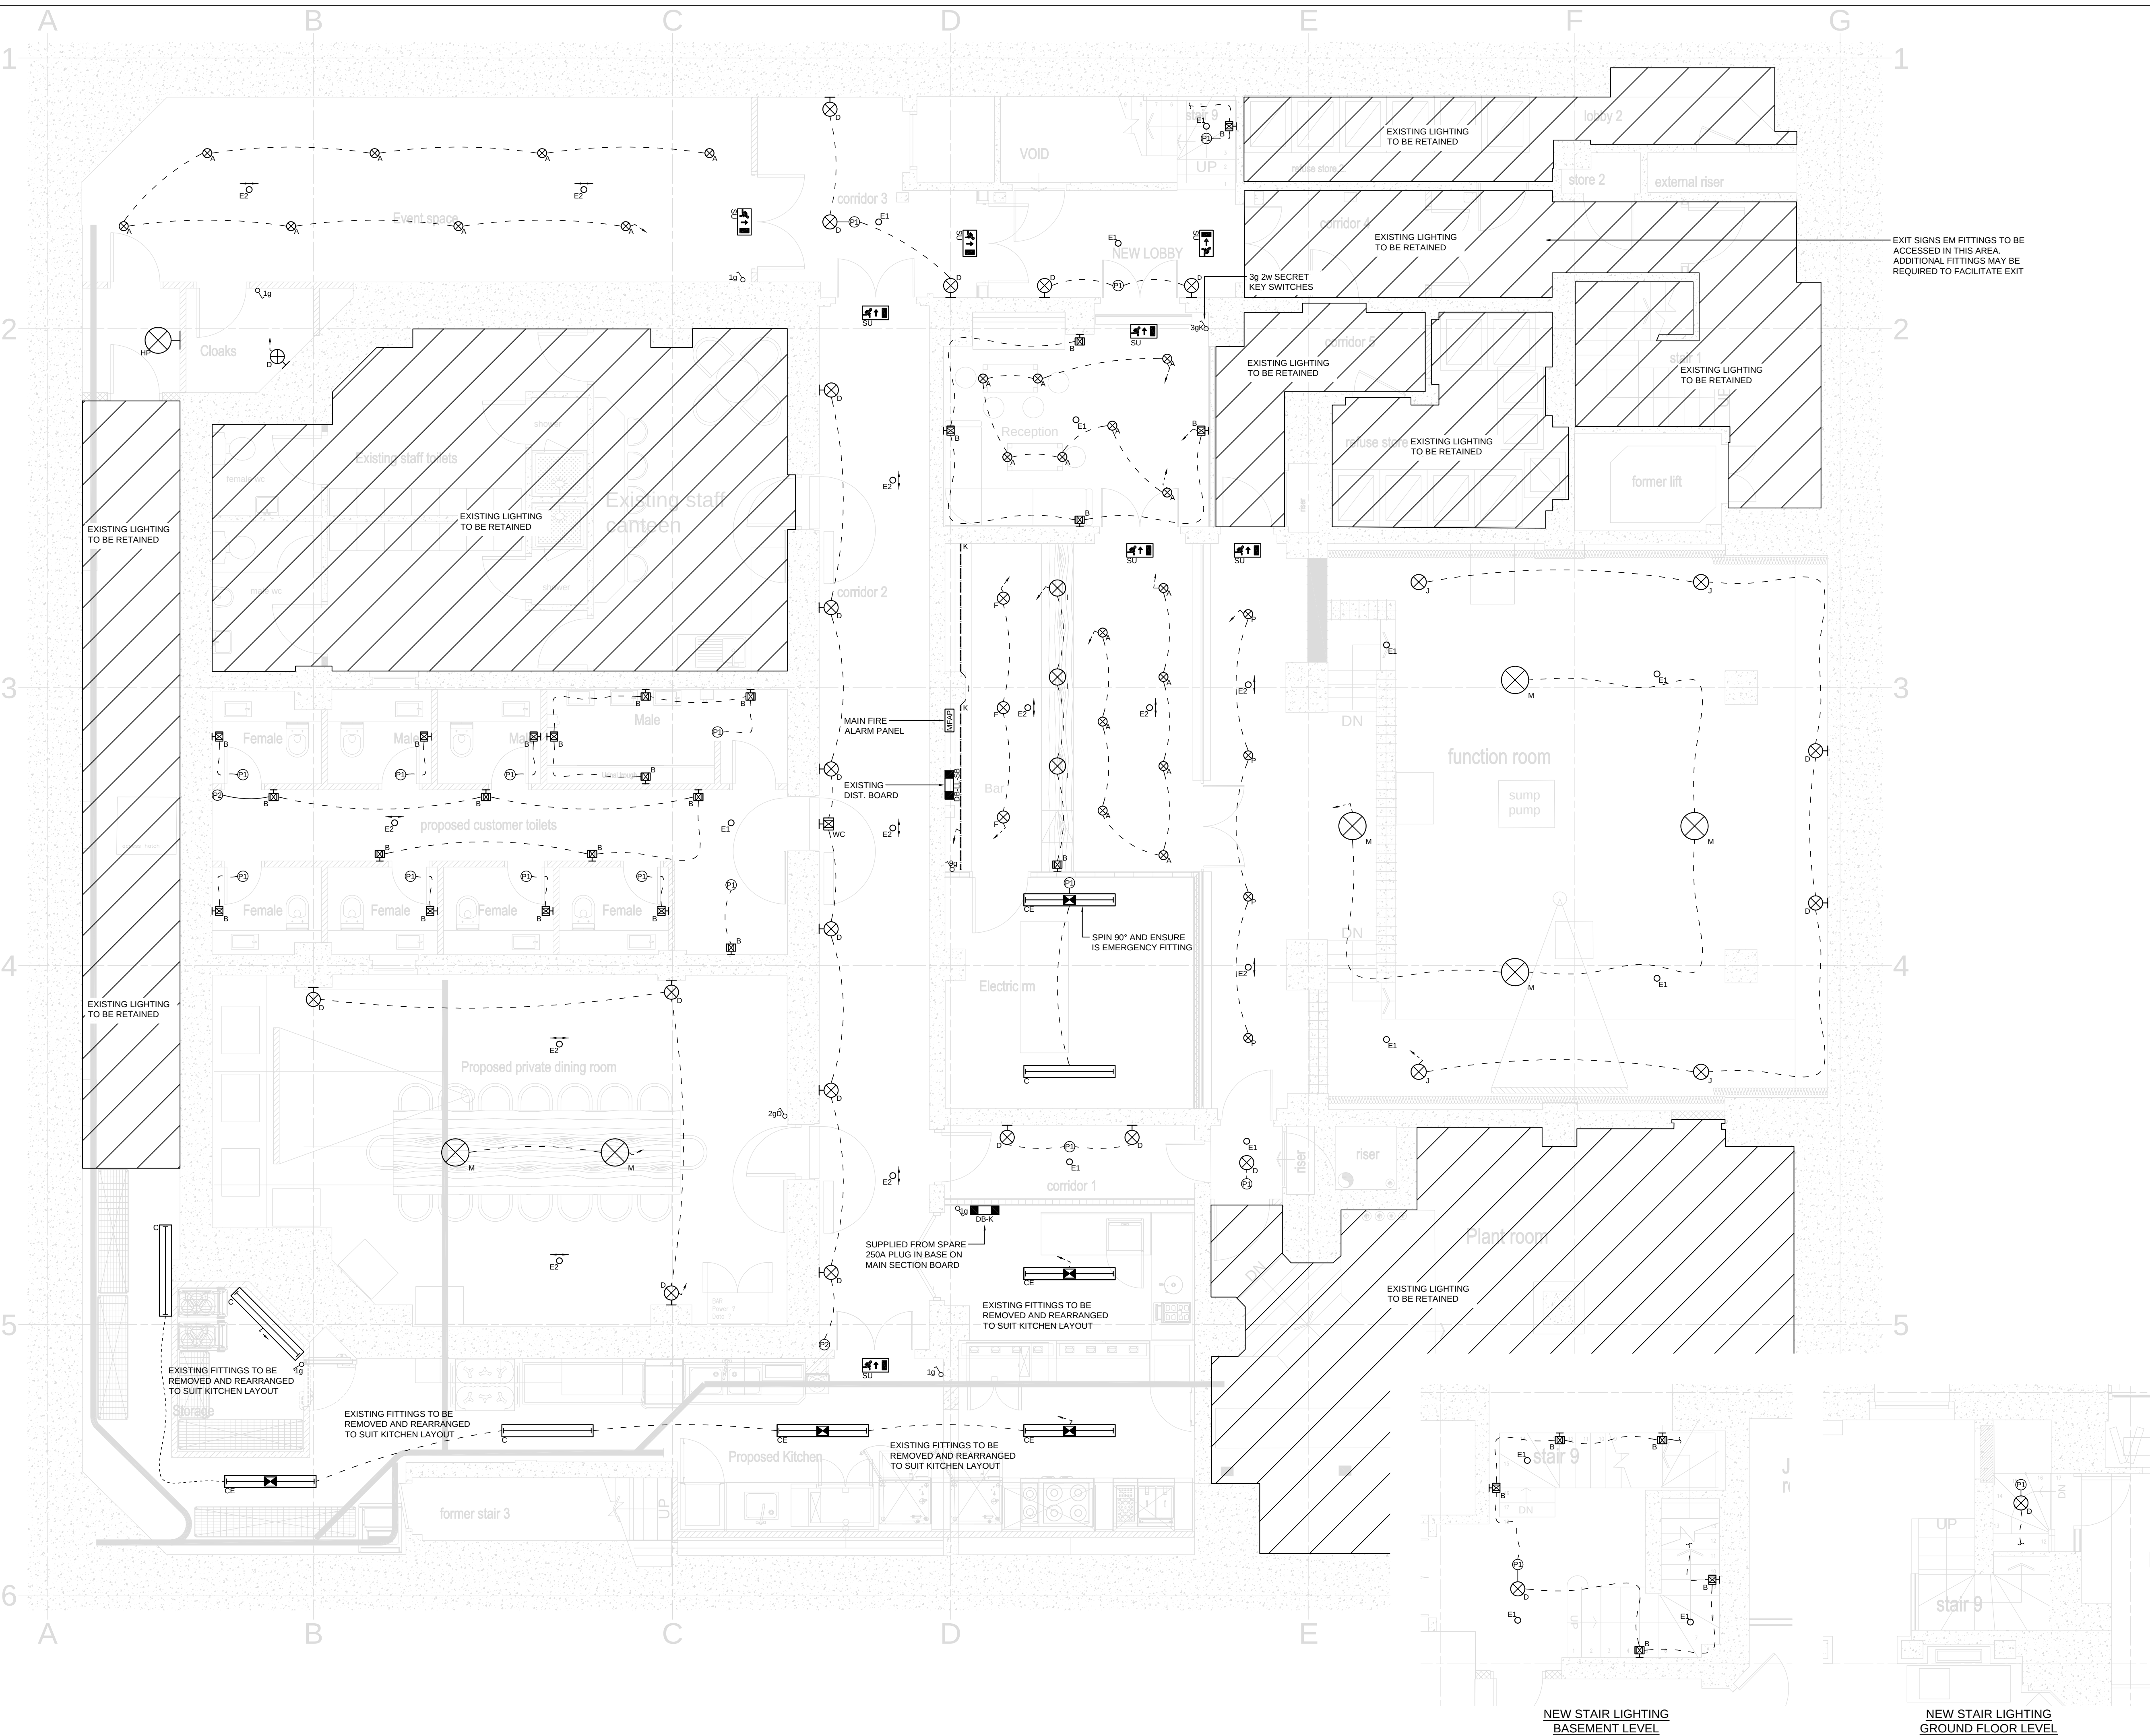

- NOTES:
1. LIGHTING AND FIRE TO BE FED VIA SURFACE BLACK HIGH IMPACT PLASTIC CONDUIT.
 2. DIMMABLE ROTARY SWITCH IN PRIVATE DINING ROOM TO BE VARILIGHT INTELLIGENT DINNER MK MODULE INSERT.
 3. LIGHTING IN KITCHEN TO BE COORDINATED ONCE KITCHEN DESIGN FINALISED.
 4. FITTINGS A & M TO BE LEFT AT CEILING ROSE. PENDANT TO BE PROVIDED/INSTALLED BY OTHERS.
 5. CORRIDOR 4 AND ALTERNATIVE ESCAPE LIGHTING TO BE RETAINED. LIGHTING TO BE ASSESSED AND ENSURED IN GOOD WORKING ORDER.
 6. RECEPTION/BAR LIGHTING 2WAY CONTROLLED FROM BEHIND BAR & RECEPTION ENTRANCE. RECEPTION/ENTRANCE SWITCHES TO BE SECRET KEY TYPE.

- GENERAL & EMERGENCY LIGHTING LEGEND:
- ⊗ CEILING ROSE FOR SMALL PENDANT TO BE SUPPLIED BY OTHERS
 - ⊗^B CHANTELE OVAL ALUMINIUM BULKHEAD c/w 2700K E27 LED LAMP WALL MTD
 - ⊗^C EXISTING VAPOUR PROOF FITTING (IF FITTING NOT GOOD CONDITION TO BE REPLACED WITH SOUTHGATE NEPTUNE)
 - ⊗^D CHANTELE DISTRESSED ALUMINIUM BULKHEAD c/w 2700K E27 LED LAMP CEILING AND WALL MTD
 - ⊗^E SOUTHGATE EXIT SIGN SU - DENOTES SUSPENDED ARROW AS DEPICTED
 - ⊗^{E1} SOUTHGATE STANDALONE EMERGENCY LED c/w OPEN AREA OPTIC
 - ⊗^{E2} SOUTHGATE STANDALONE EMERGENCY LED c/w CORRIDOR OPTIC. DIRECTION AS DEPICTED BY ARROW
 - ⊗^J SOUTHGATE SURFACE HAYLEY LED IN RAL 700K 2700K 4000K
 - ⊗^M SOUTHGATE SURFACE POLARIS LED 4000K
 - ⊗^P CHANTELE OPAL SCHOOL HOUSE PENDANT c/w 2700K E27 LED LAMP
 - ⊗^S CHANTELE CONTEMPORARY PENDANT SMOKE GLASS SHADE c/w 2700K E27 LED FILAMENT LAMP
 - ⊗^K OSRAM VF600-G3-827-05 2700K LED TAPE IN ALUMINIUM EXTRUSION
 - ⊗^M CEILING ROSE FOR LARGE PENDANT TO BE SUPPLIED BY OTHERS
 - ⊗^P CHANTELE CAGE PENDANT c/w 2700K E27 LED FILAMENT LAMP
 - ⊗^{WC} CHANTELE INDUSTRIAL STYLE W.C. SIGN LIGHT c/w E14 LED
 - ⊗^{EX} EX-OR LS3100RSM SURFACE MOUNTED PRESENCE DETECTOR PIR
 - ⊗^{EX} EX-OR SGL1500P SURFACE MOUNTED MID RANGE PRESENCE DETECTOR PIR
 - ⊗^{LG} LIGHT SWITCH NUMBER OF GANGS AS INDICATED MK METAL CLAD

01	19.02.19	BR	PRELIMINARY ISSUE
REV	DATE	BY	DESCRIPTION
DRAWING STATUS: PRELIMINARY			
A. F. CONNELL LTD			
INDUSTRIAL & COMMERCIAL ELECTRICAL & MECHANICAL CONTRACTORS			
1 ALFRED STREET, WEST VALE, HALIFAX, WEST YORKSHIRE, HX4 8LT. TEL: 01422 310400, FAX: 01422 310033. Email: electrical@afconnell.com, mechanical@afconnell.com			
  			
PROJECT: HOTEL GOTHAM BASEMENT REFURBISHMENT 100 KING STREET, MANCHESTER			
DRAWING TITLE: ELECTRICAL SERVICES LIGHTING LAYOUT LOWER BASEMENT			
SCALE: 1:50 @ A1	DRAWN: MJ	CHECKED: BR	DATE: FEB '19
PROJECT No: C5782	DRAWING No: C5782-63-(-01)-01	REV: 01	