


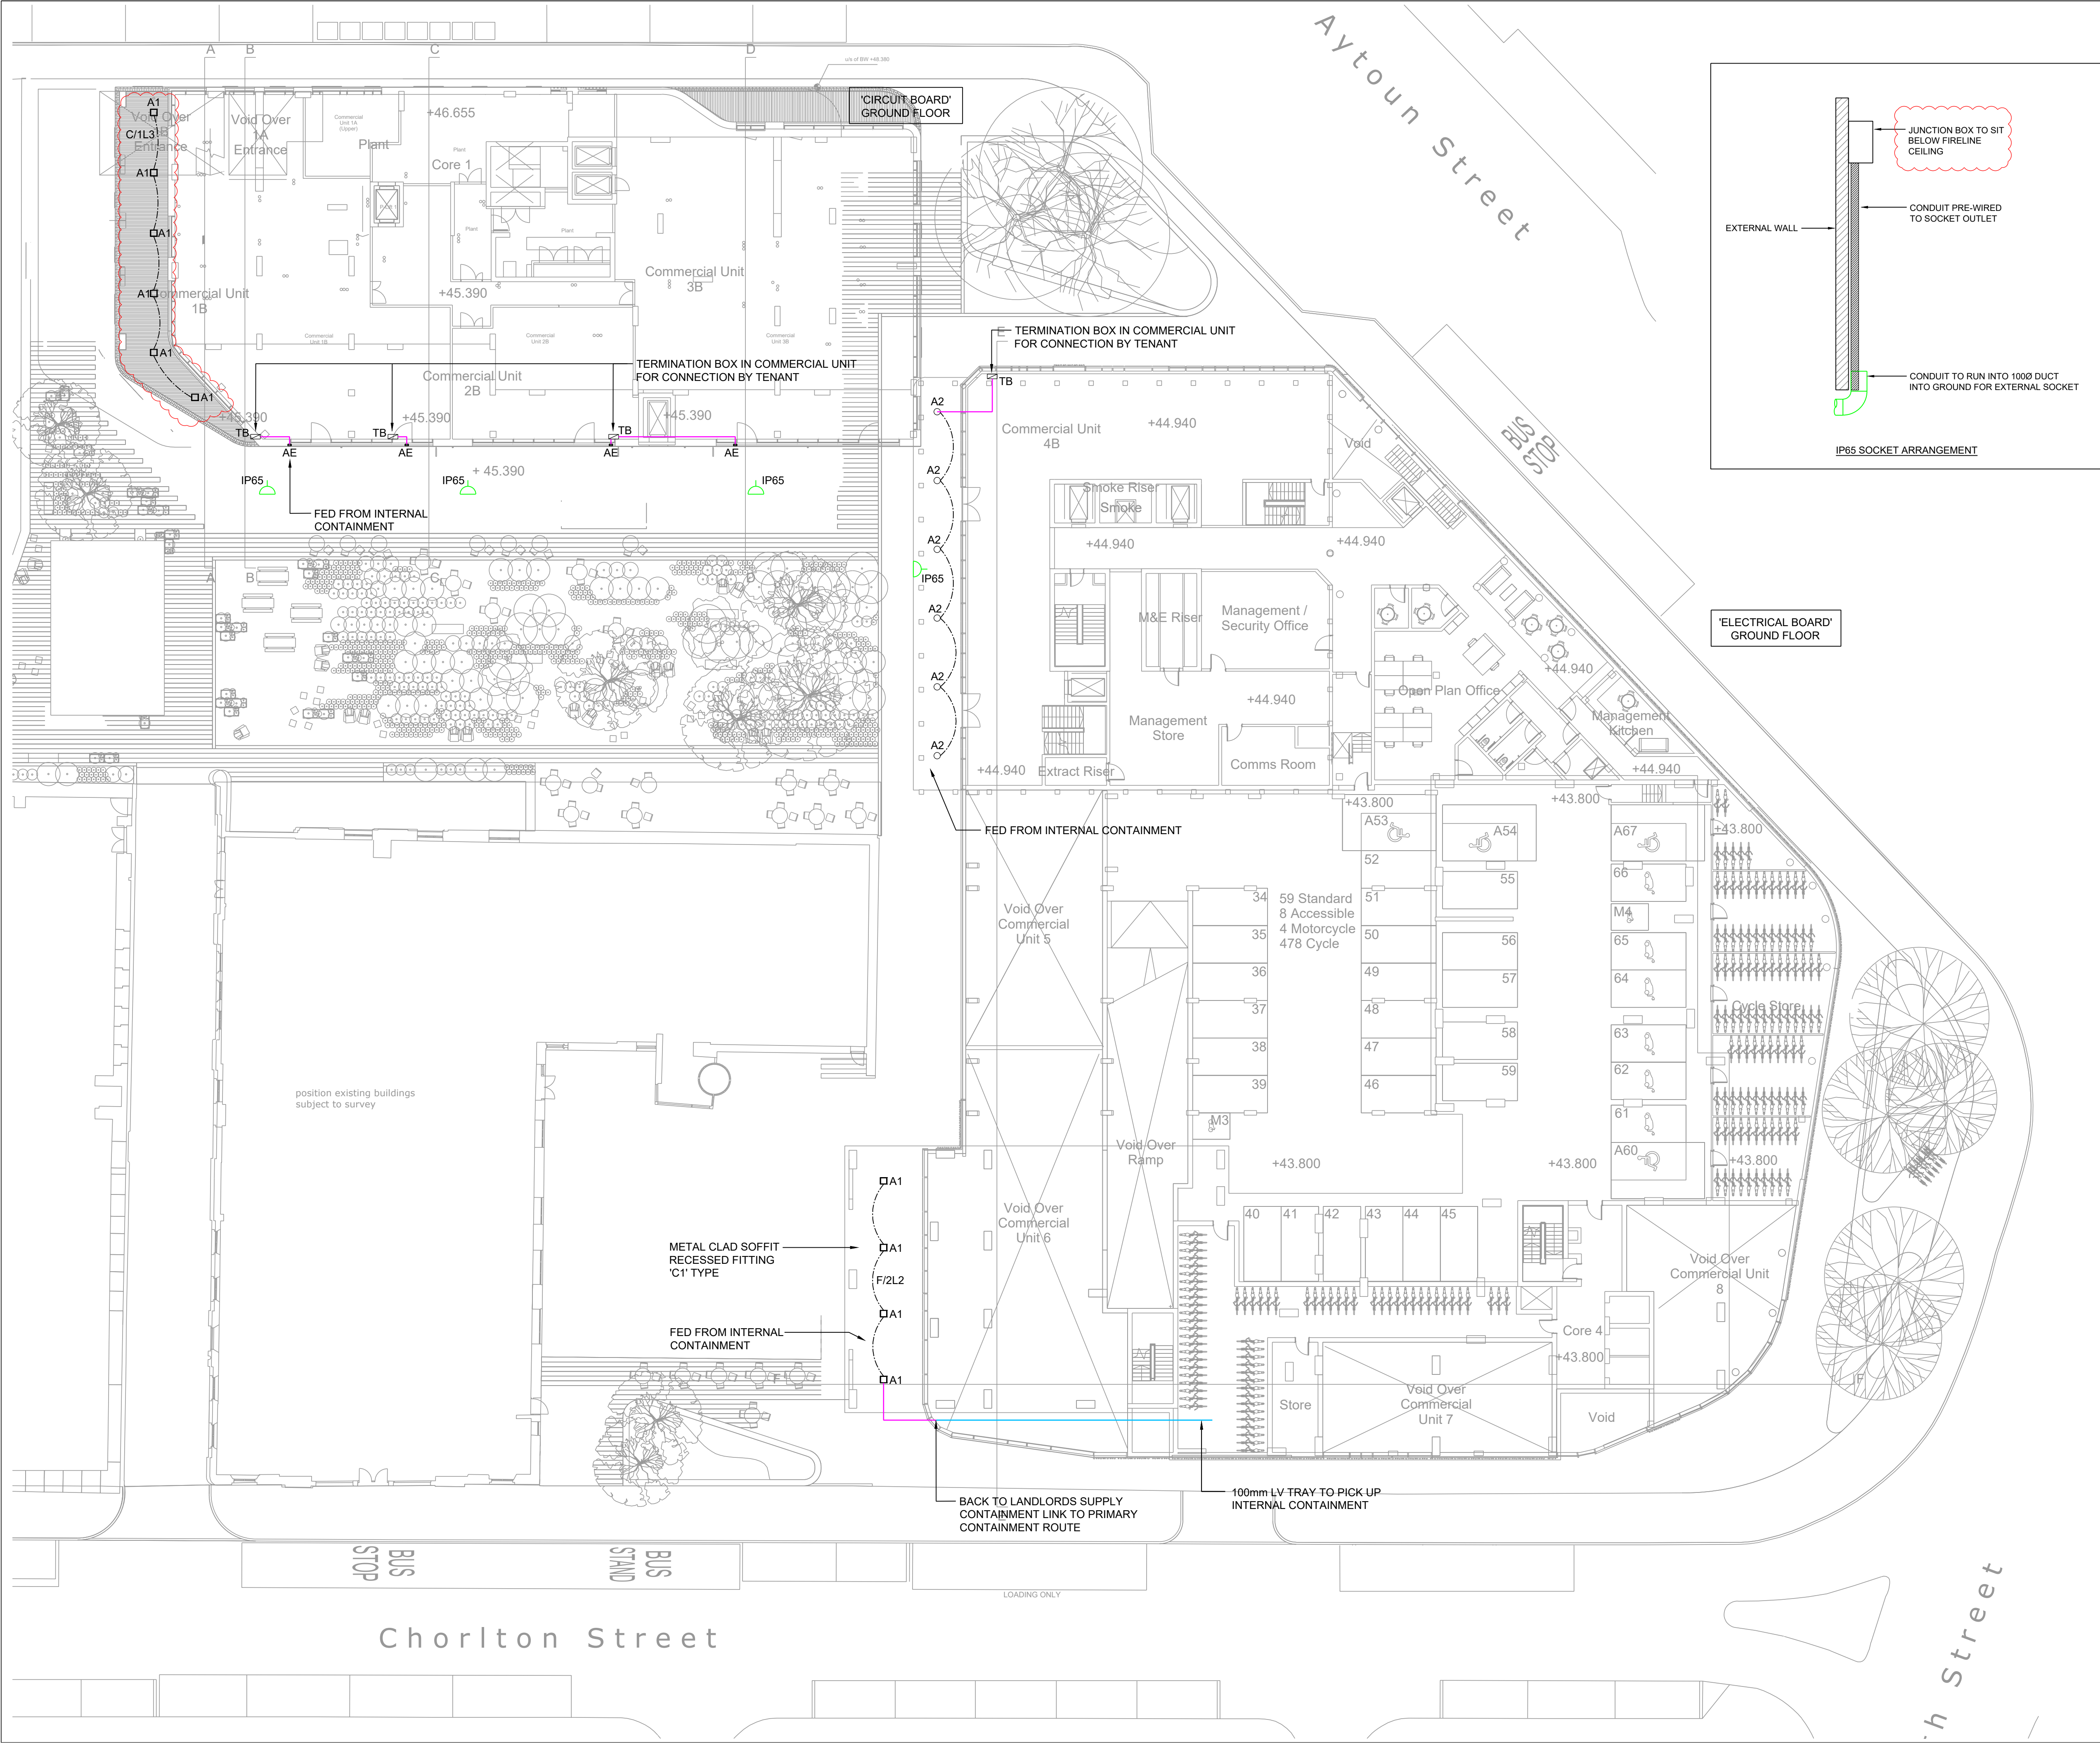

Building Outline Information	
Architect's Drawing No.	Date
B&F PROJECT NUMBER: 4006	

- NOTES**
- LIGHTING TO BE CONTROLLED VIA TIMECLOCK & PHOTOCELL.
 - SPARE DUTY TO BE TERMINATED IN DRAW PIT OUTSIDE OF BUILDING FOR FUTURE.
- LEGEND**
- UNDERGROUND PVC DUCT - SIZE AS SHOWN
 - 50x50mm L&P TRUNKING
 - DRAW PIT 600x600
 - 'E' DENOTES 3 HR INTEGRAL EMERGENCY

LUMINAIRE PARTS LIST				
INDEX	MANUFACTURER	LUMINAIRE TYPE	CONNECTED LOAD	COMMENTS
A	SPURLITE LTD	WALL MOUNTED LED LUMINAIRE	5W	WALL MOUNTED
A1	SPURLITE LTD	RECESSED LED SQUARE LUMINAIRE	5W	SQUARE RECESSED
A2	SPURLITE LTD	RECESSED LED CIRCULAR LUMINAIRE	5W	CIRCULAR RECESSED
B	SPURLITE LTD	PRETUS XTP POLISHED-OPAL 19W 150mm 4000K 80Ra	19 W	RECESSED
C	SPURLITE LTD	SLIMLINE LOW PROFILE LED SURFACE MOUNTED	11 W / M	WITH EXTERNAL CANOPIES
D	SPURLITE LTD	HARMON 5W 25x15 3000K 80Ra	5 W	GROUND RECESSED
F	SPURLITE LTD	JORY S FLOOD 200 245LM 5W 3000K 80Ra	5 W	GROUND MOUNTED ON A WIRE - 1500MM HANGERS
G	SPURLITE LTD	JORY S FLOOD 100 120 150W 5W 3000K 80Ra	5 W	GROUND MOUNTED ON A WIRE - 1500MM HANGERS
H1	SPURLITE LTD	SLIMLINE LOW PROFILE LED SURFACE MOUNTED	11W / M	HALL ROCKETTOP OF BENCH
H2	SPURLITE LTD	SLIMLINE LOW PROFILE LED SURFACE MOUNTED	11W / M	SMALL CODE OF BENCH
I	SPURLITE LTD	SLIMLINE LOW PROFILE LED SURFACE MOUNTED	11W / M	ON COUNTER
J	SPURLITE LTD	HARMON 5W 25x15 3000K 80Ra	5 W	GROUND RECESSED

C03	CONSTRUCTION ISSUE	SB	11.02.20
C02	CONSTRUCTION ISSUE	GP	07.11.19
C01	CONSTRUCTION ISSUE	SB	17.10.19
Rev	Description	Drawn	Date

Briggs & Forrester Living Ltd
Bembridge House
Bembridge Drive
Kingsthorpe
Northampton
NN2 6LZ
www.briggsandforrester.co.uk
Registered in England No. 1807941
Tel: (01604) 720072

Client:
Mount Anvil

Project:
Kampus
Manchester

Drawing Title:
EXTERNAL LIGHTING LAYOUT
LEVEL 01

Scale: 1:200 @ A1
Checked: DW
Drawing Number: 4006-BAF-ZZ-01-DR-E-(63)-013
C03
Suitability: S4
Drawing Status: CONSTRUCTION

This drawing is copyright and may not be reproduced either in part or full without written permission from Briggs & Forrester Group Ltd.
DO NOT SCALE OFF THIS DRAWING

bsi.
BIM Verified
Design & Construction
Capital Delivery
PAS 1192-2
VC 658367