


ISO A1 594mm x 841mm
Approved: VB
Checked: JW
Designer: JW
Project Management Initials:
Last saved by: JOSEPH WATTON(2021.03.26)
Filename: Z:\UK\UMCRS\JOSS\PR305460_MANCHESTER_COLLEGE900_CAD_GIS\910_CAD\CIVIL\CURRENT DRAWINGS\278\CC-ACM-278-XX-DR-C-0002 P03.DWG
Last Plotted: 2021.03.26

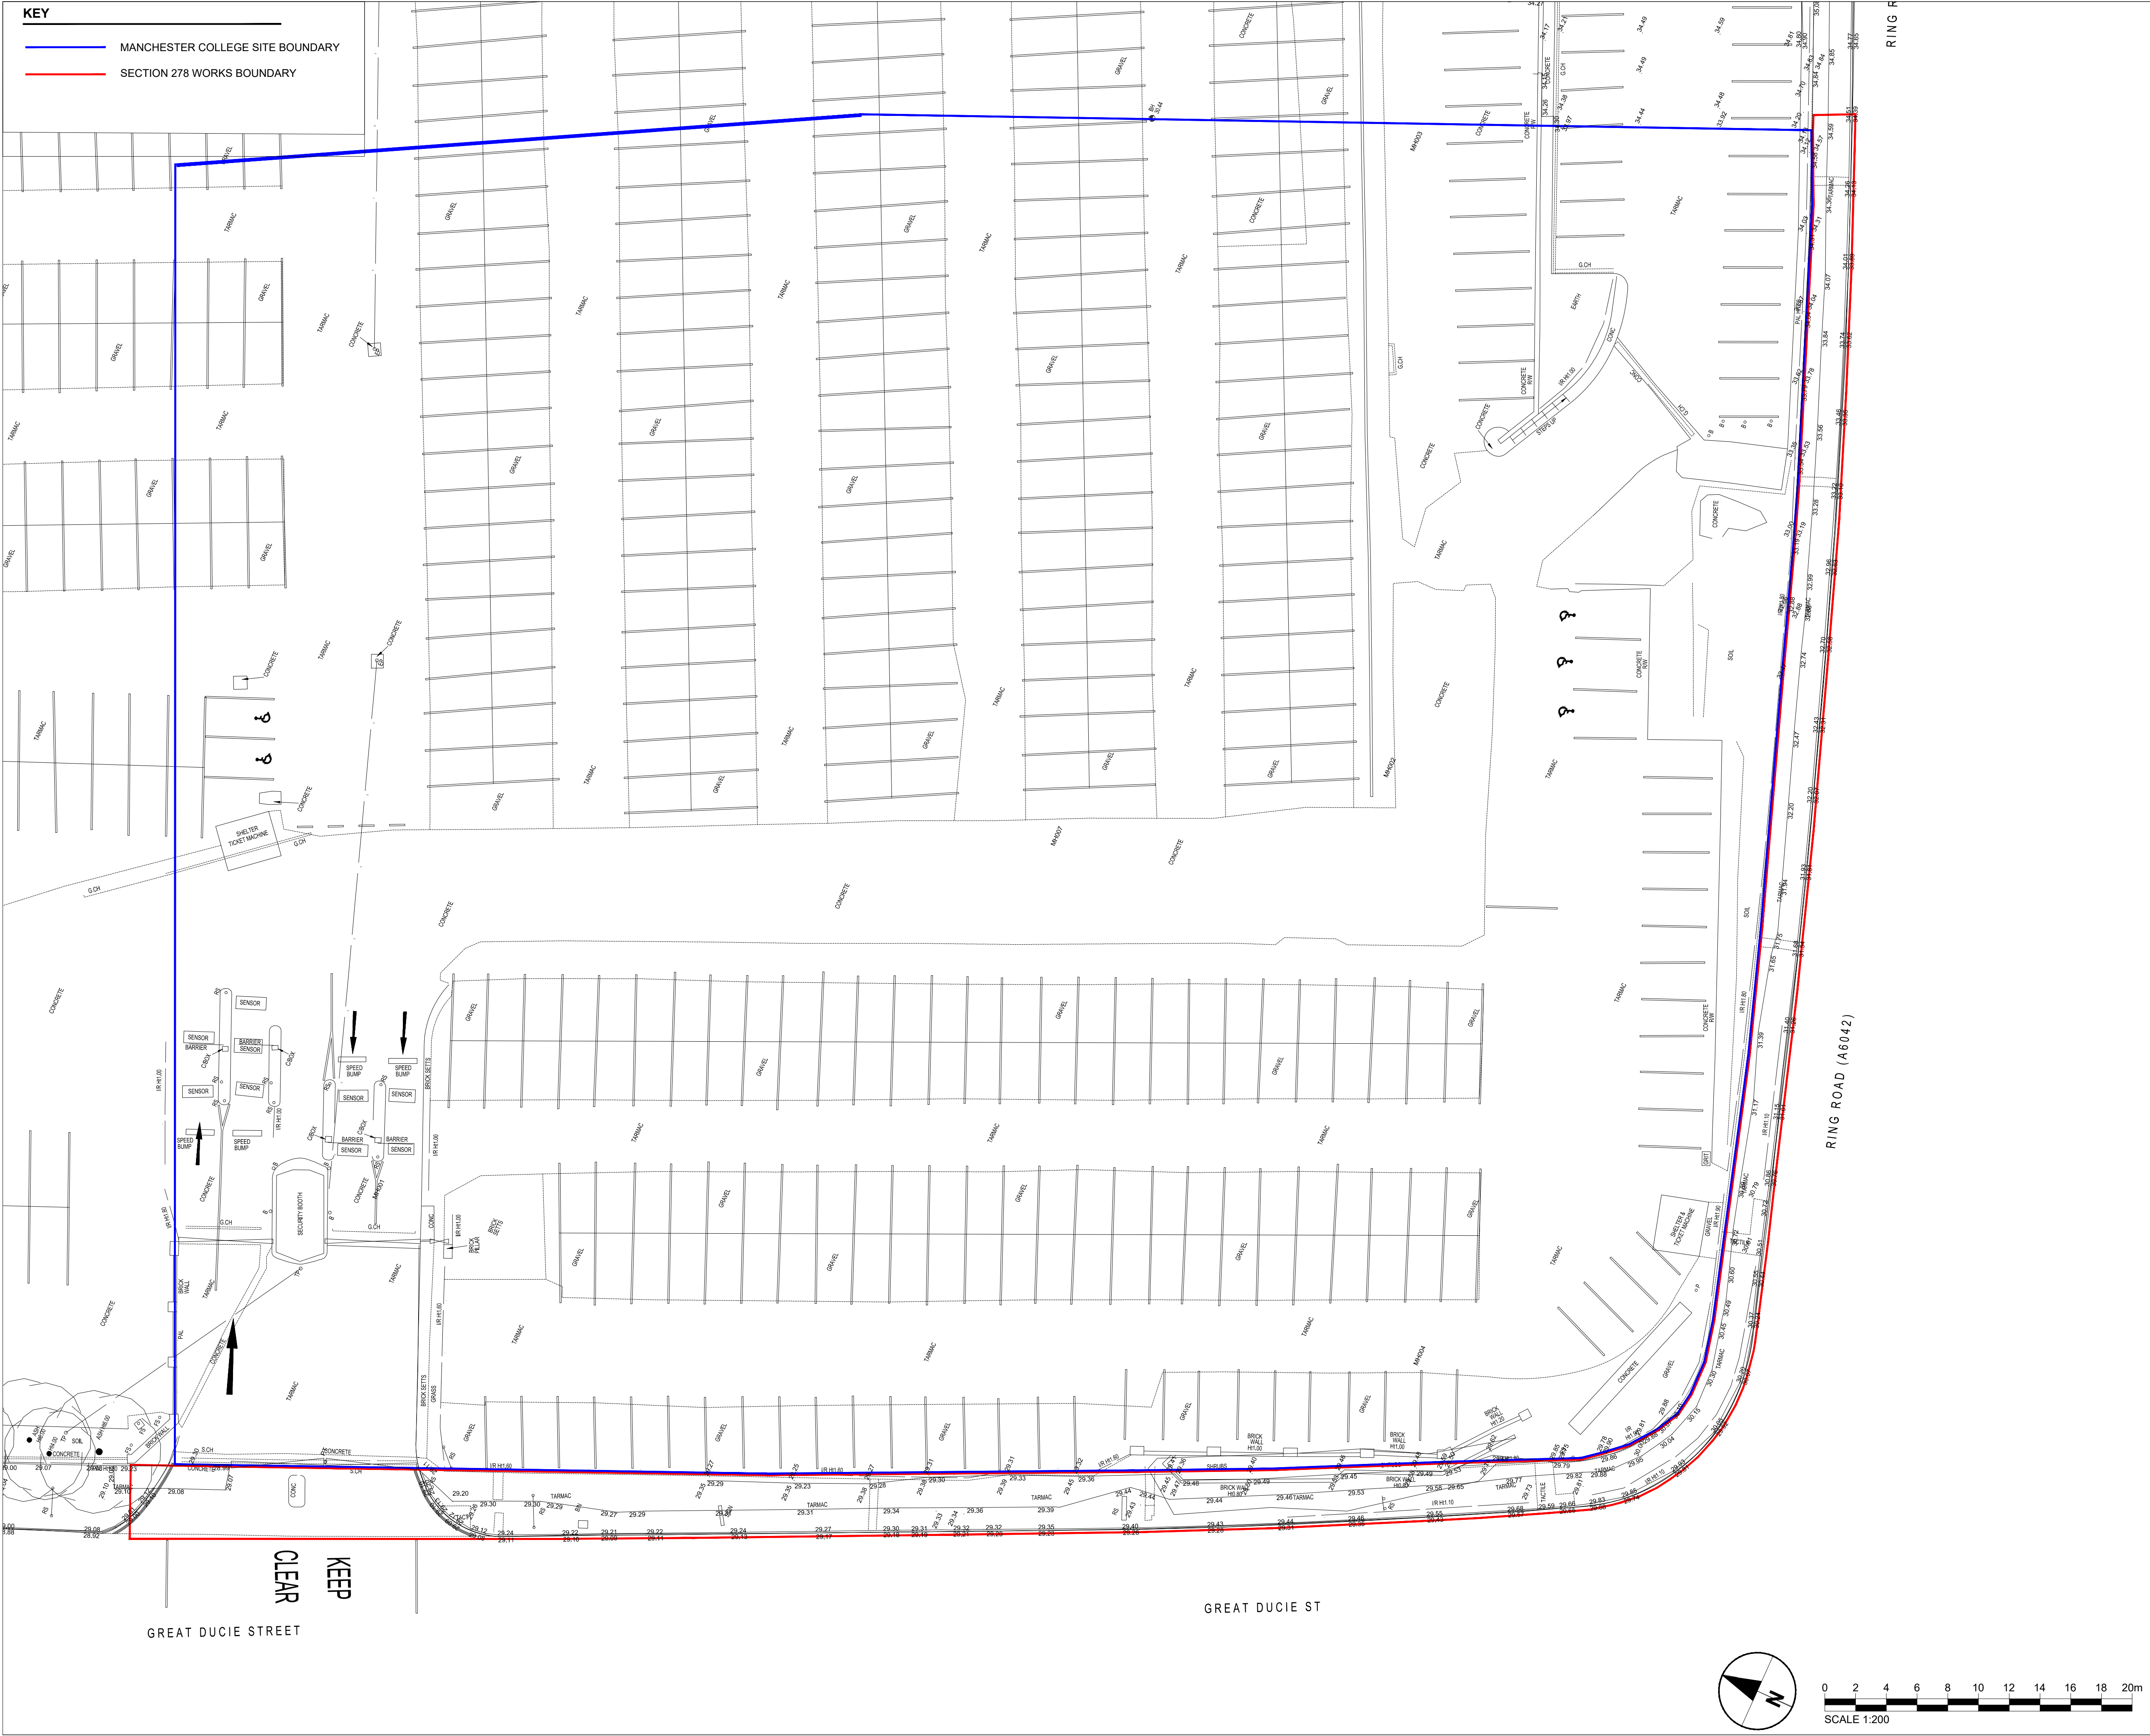

AECOM

PROJECT
MANCHESTER COLLEGE
LTE CITY CENTRE

CLIENT
THE MANCHESTER COLLEGE

CONSULTANT
AECOM Ltd.
Bridgewater House
58-60 Whitworth Street
Manchester, M1 6LT.
+44 (0)161 907 3500 tel www.aecom.com

NOTES

1. DO NOT SCALE FROM THIS DRAWING. ONLY STATED DIMENSIONS ARE TO BE USED.

ISSUE/REVISION		
P03	26/03/21	NEW TOPO OVERLAID
P02	11/08/20	ISSUED TO MCC
P01	04/08/20	DRAFT ISSUE
I/R	DATE	DESCRIPTION

PROJECT NUMBER
60594458

SHEET TITLE
SECTION 278 AGREEMENT
EXISTING SITE PLAN

SHEET NUMBER
CC-ACM-278-XX-DR-C-0002