



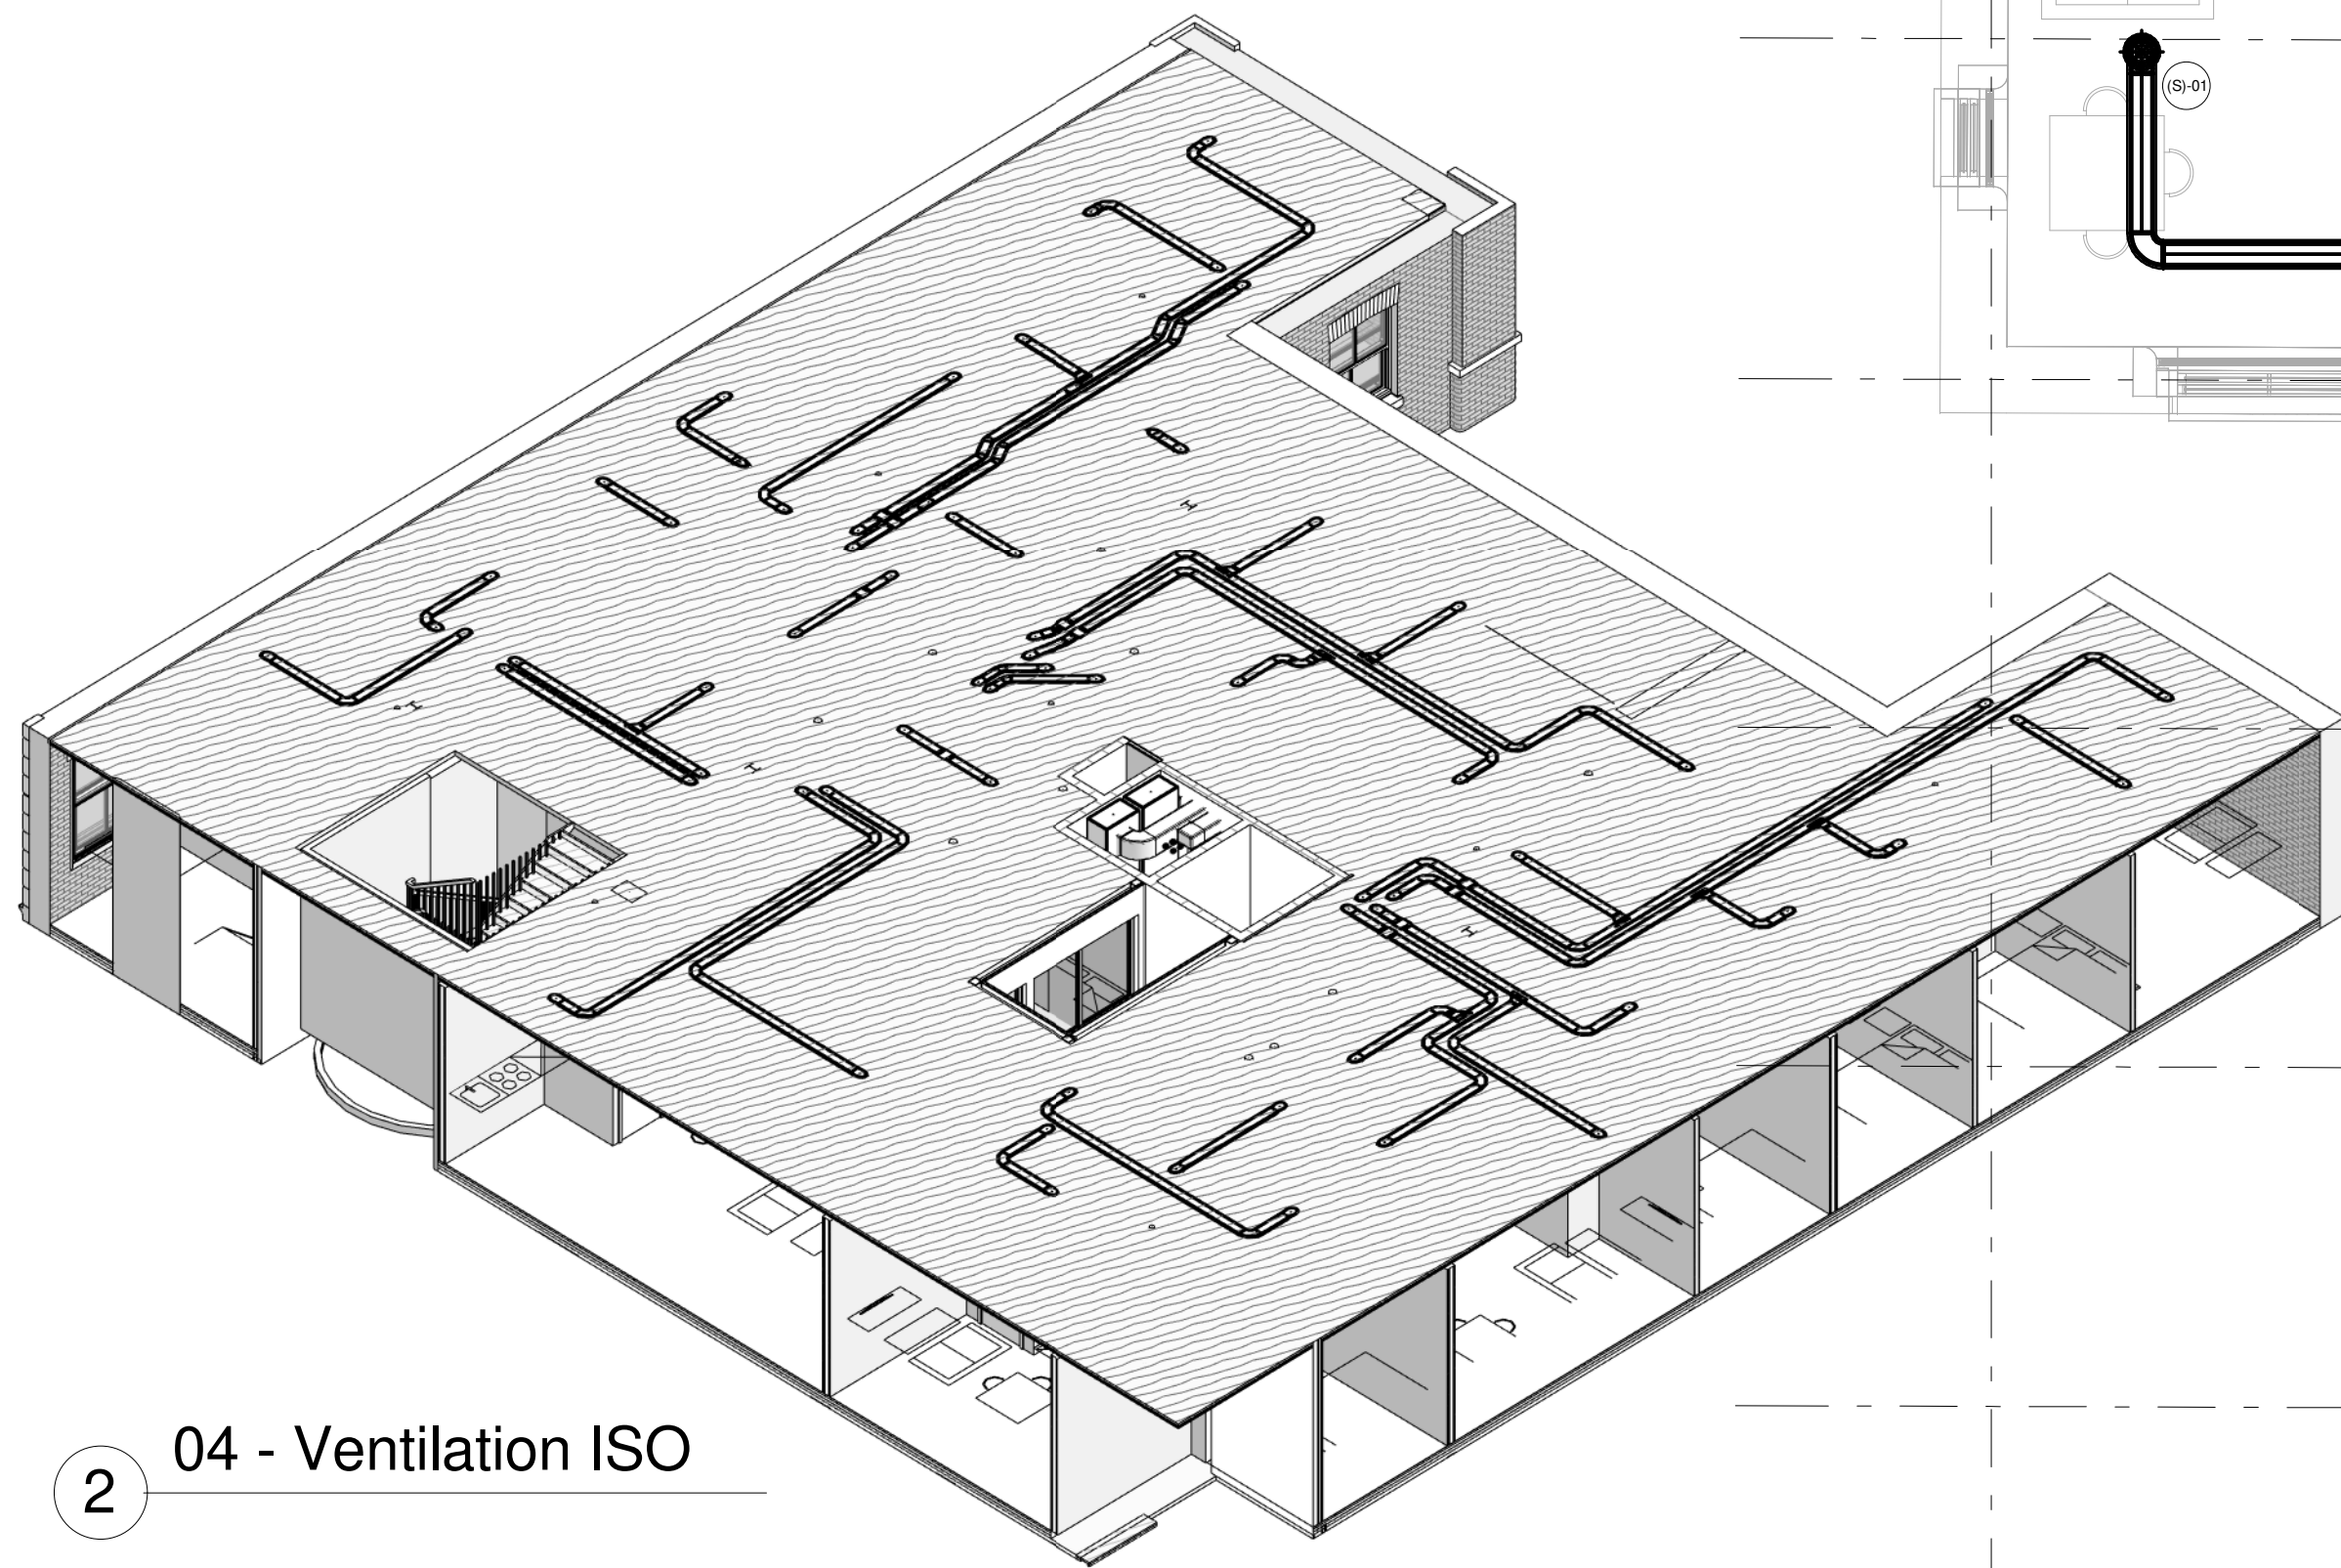

04 - Ventilation ISO

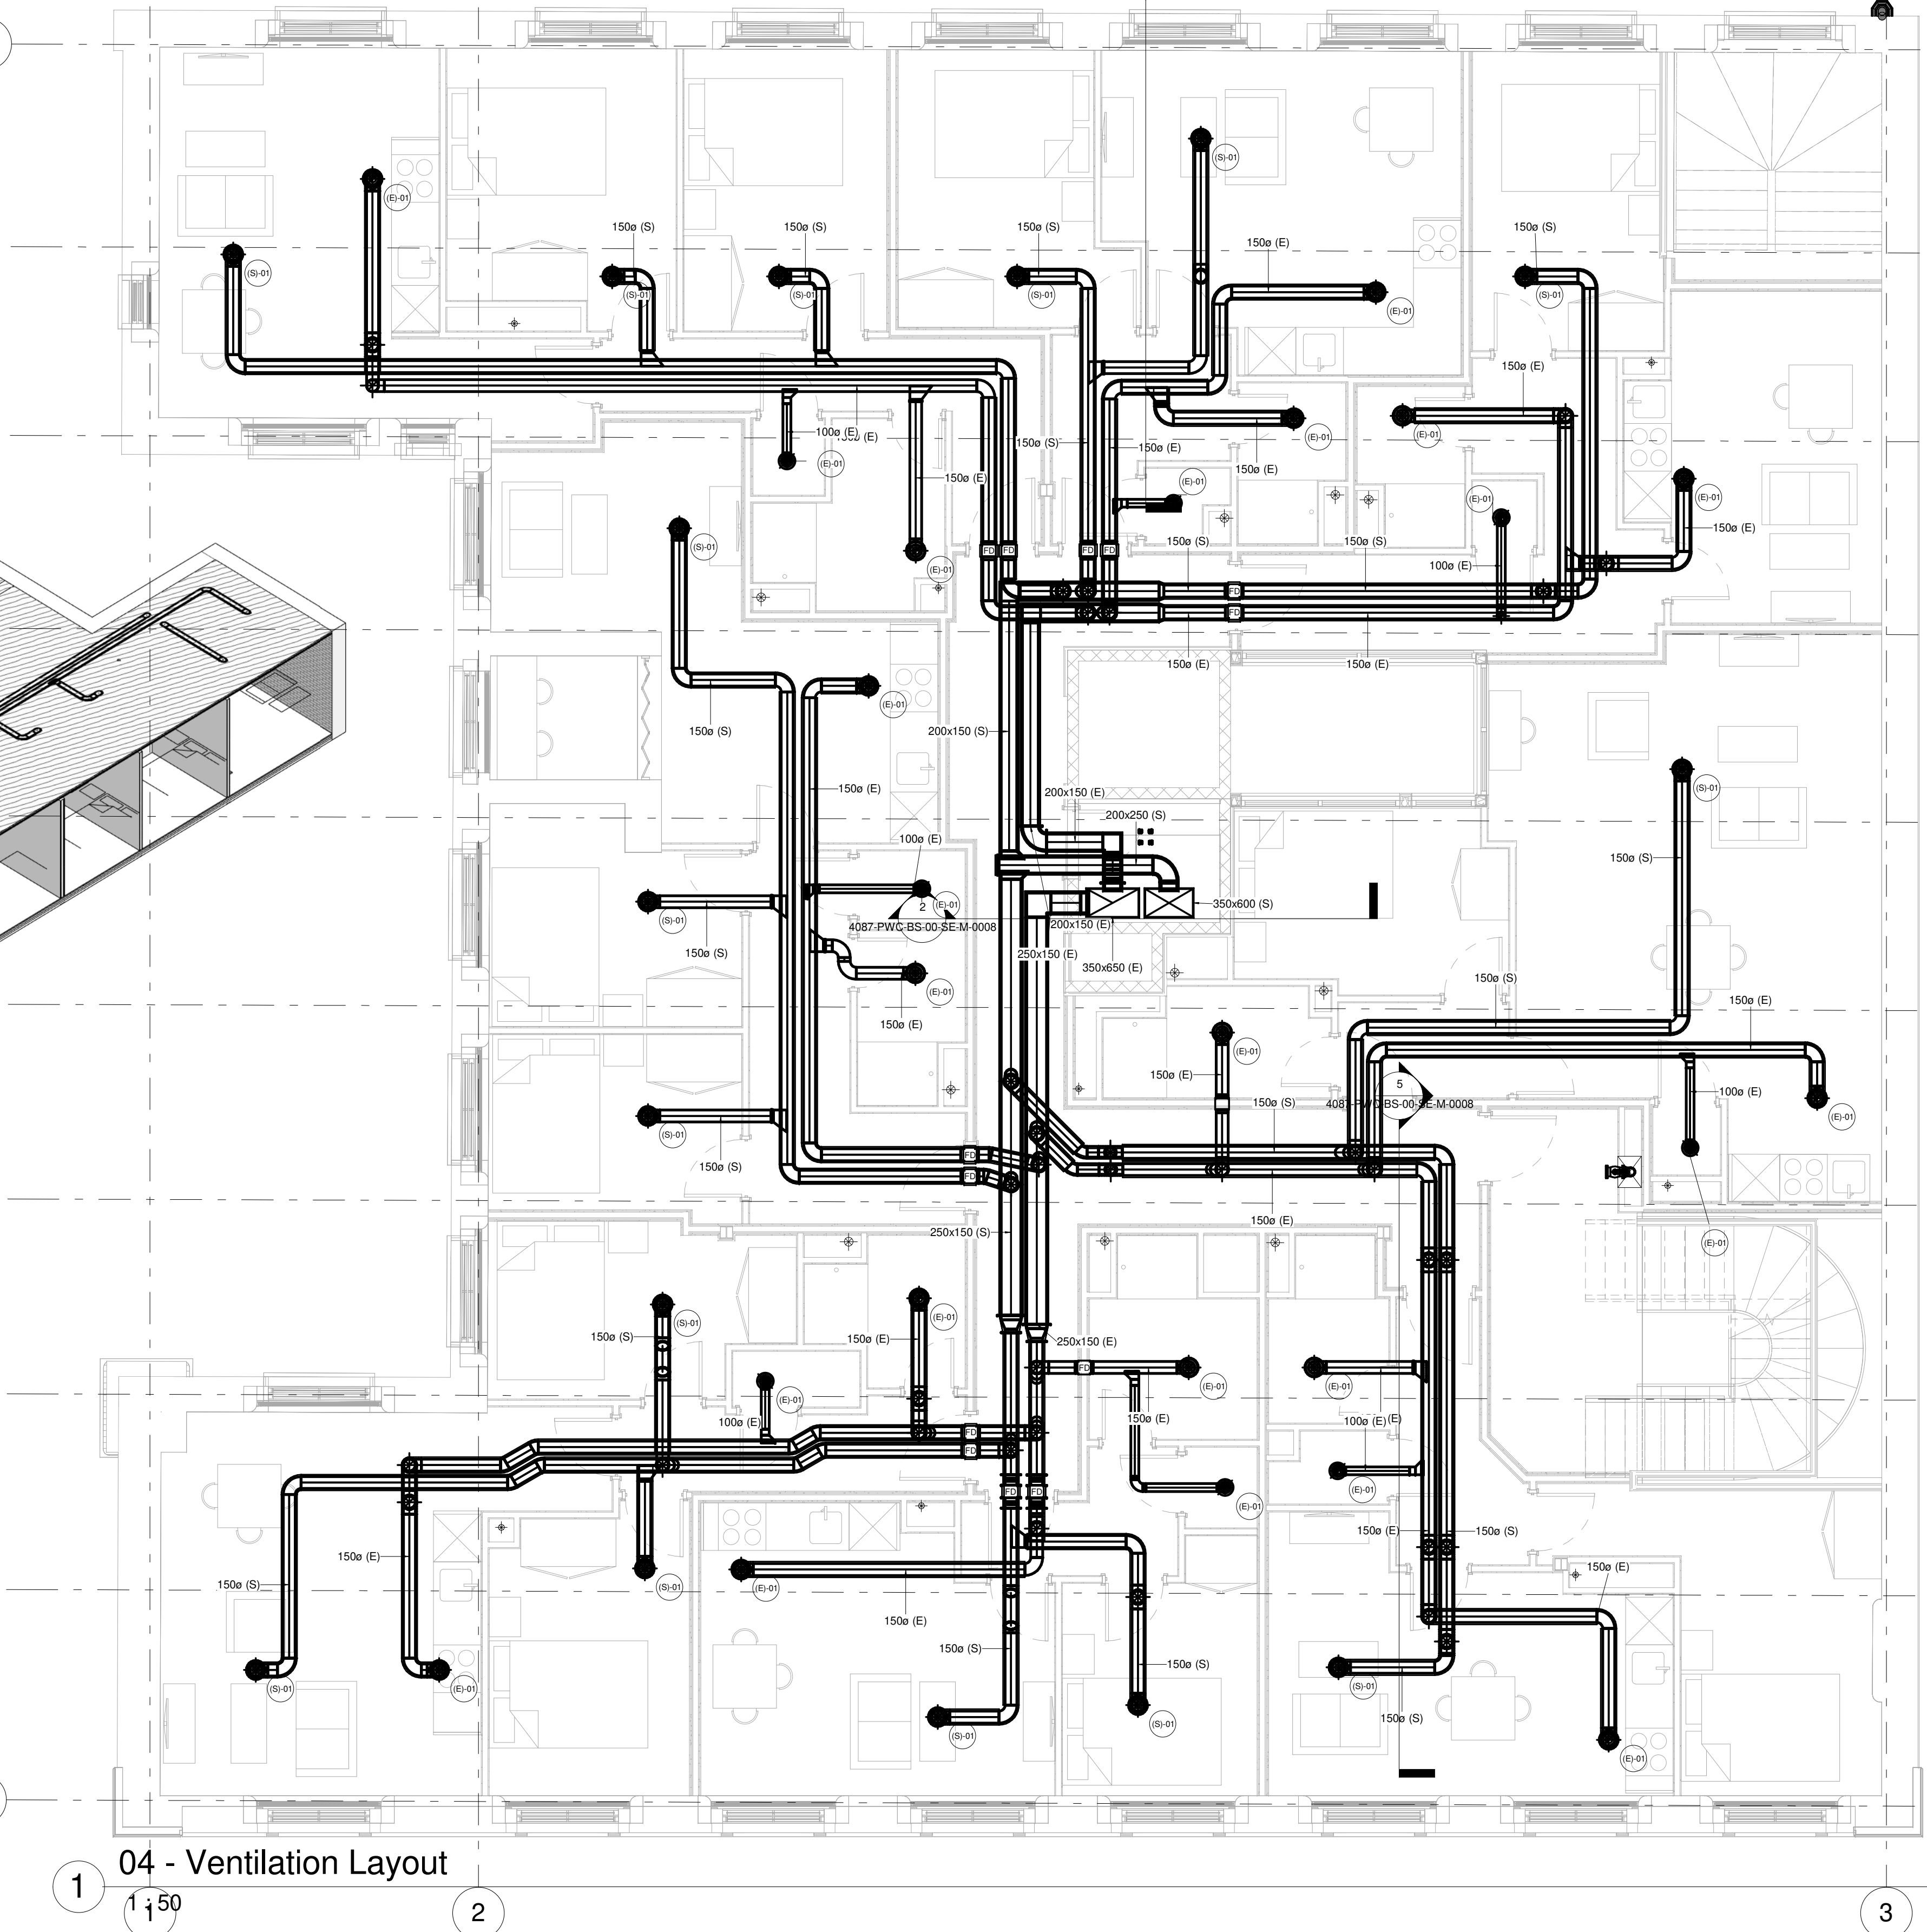

- GENERAL NOTES :
1. ALL SERVICE ROUTES DETAILED ARE APPROXIMATE. THE CONTRACTOR SHALL BE RESPONSIBLE FOR DETERMINING THE EXACT ROUTES AND POSITIONS OF ALL INSTALLED SERVICES AND EQUIPMENT.
 2. THE EXACT POSITION OF ALL SERVICES AND EQUIPMENT SHALL BE AGREED BY THE CONTRACT ADMINISTRATOR.
 3. THE CONTRACTOR SHALL BE RESPONSIBLE FOR FULLY CO-ORDINATING ANY SERVICES INSTALLED WITH THE BUILDING FABRIC AND SERVICES INSTALLED BY OTHERS.
 4. THIS DRAWING SHALL BE READ IN CONJUNCTION WITH ALL MECHANICAL, ELECTRICAL, ARCHITECTURAL AND STRUCTURAL DRAWINGS, CONTRACT DOCUMENTATION AND SPECIFICATION FOR THE WORKS.
 5. THIS DRAWING FORMS PART OF THE SPECIFICATION FOR THE WORKS.
 6. ALL DIMENSIONS SHOWN ARE IN MILLIMETRES.
 7. DO NOT SCALE FROM THIS DRAWING

T2	Issued For Tender	21-04-21
T1	Issued For Tender	16-04-21
Rev	Description	Issue Date

Client Name :
BEECH CONSTRUCTION

Project :
BLOOM STREET

Title :
Fourth Floor - Ventilation Layout



■ Burnham House, 373 Bury New Road,
Manchester, M25 1AW.
Tel: 0161 773 1177
manchester@parker-wilson.co.uk

□ 2nd Floor, 72, Cannon Street,
London EC4N 6AE.
Tel: 0207 251 4500
london@parker-wilson.co.uk

www.parker-wilson.co.uk

PWC PROJECT No. 4087	Drawn by : MK	Checked by : PG
Scale 1 : 50	Size A1	Date : Issue Date
Drawing Number 4087-PWC-BS-04-PL-M-0006	Rev T2	

5/21/2021 5:31:59 PM