


REVISION	DATE	DESCRIPTION
-	06.05.21	PLANNING ISSUE

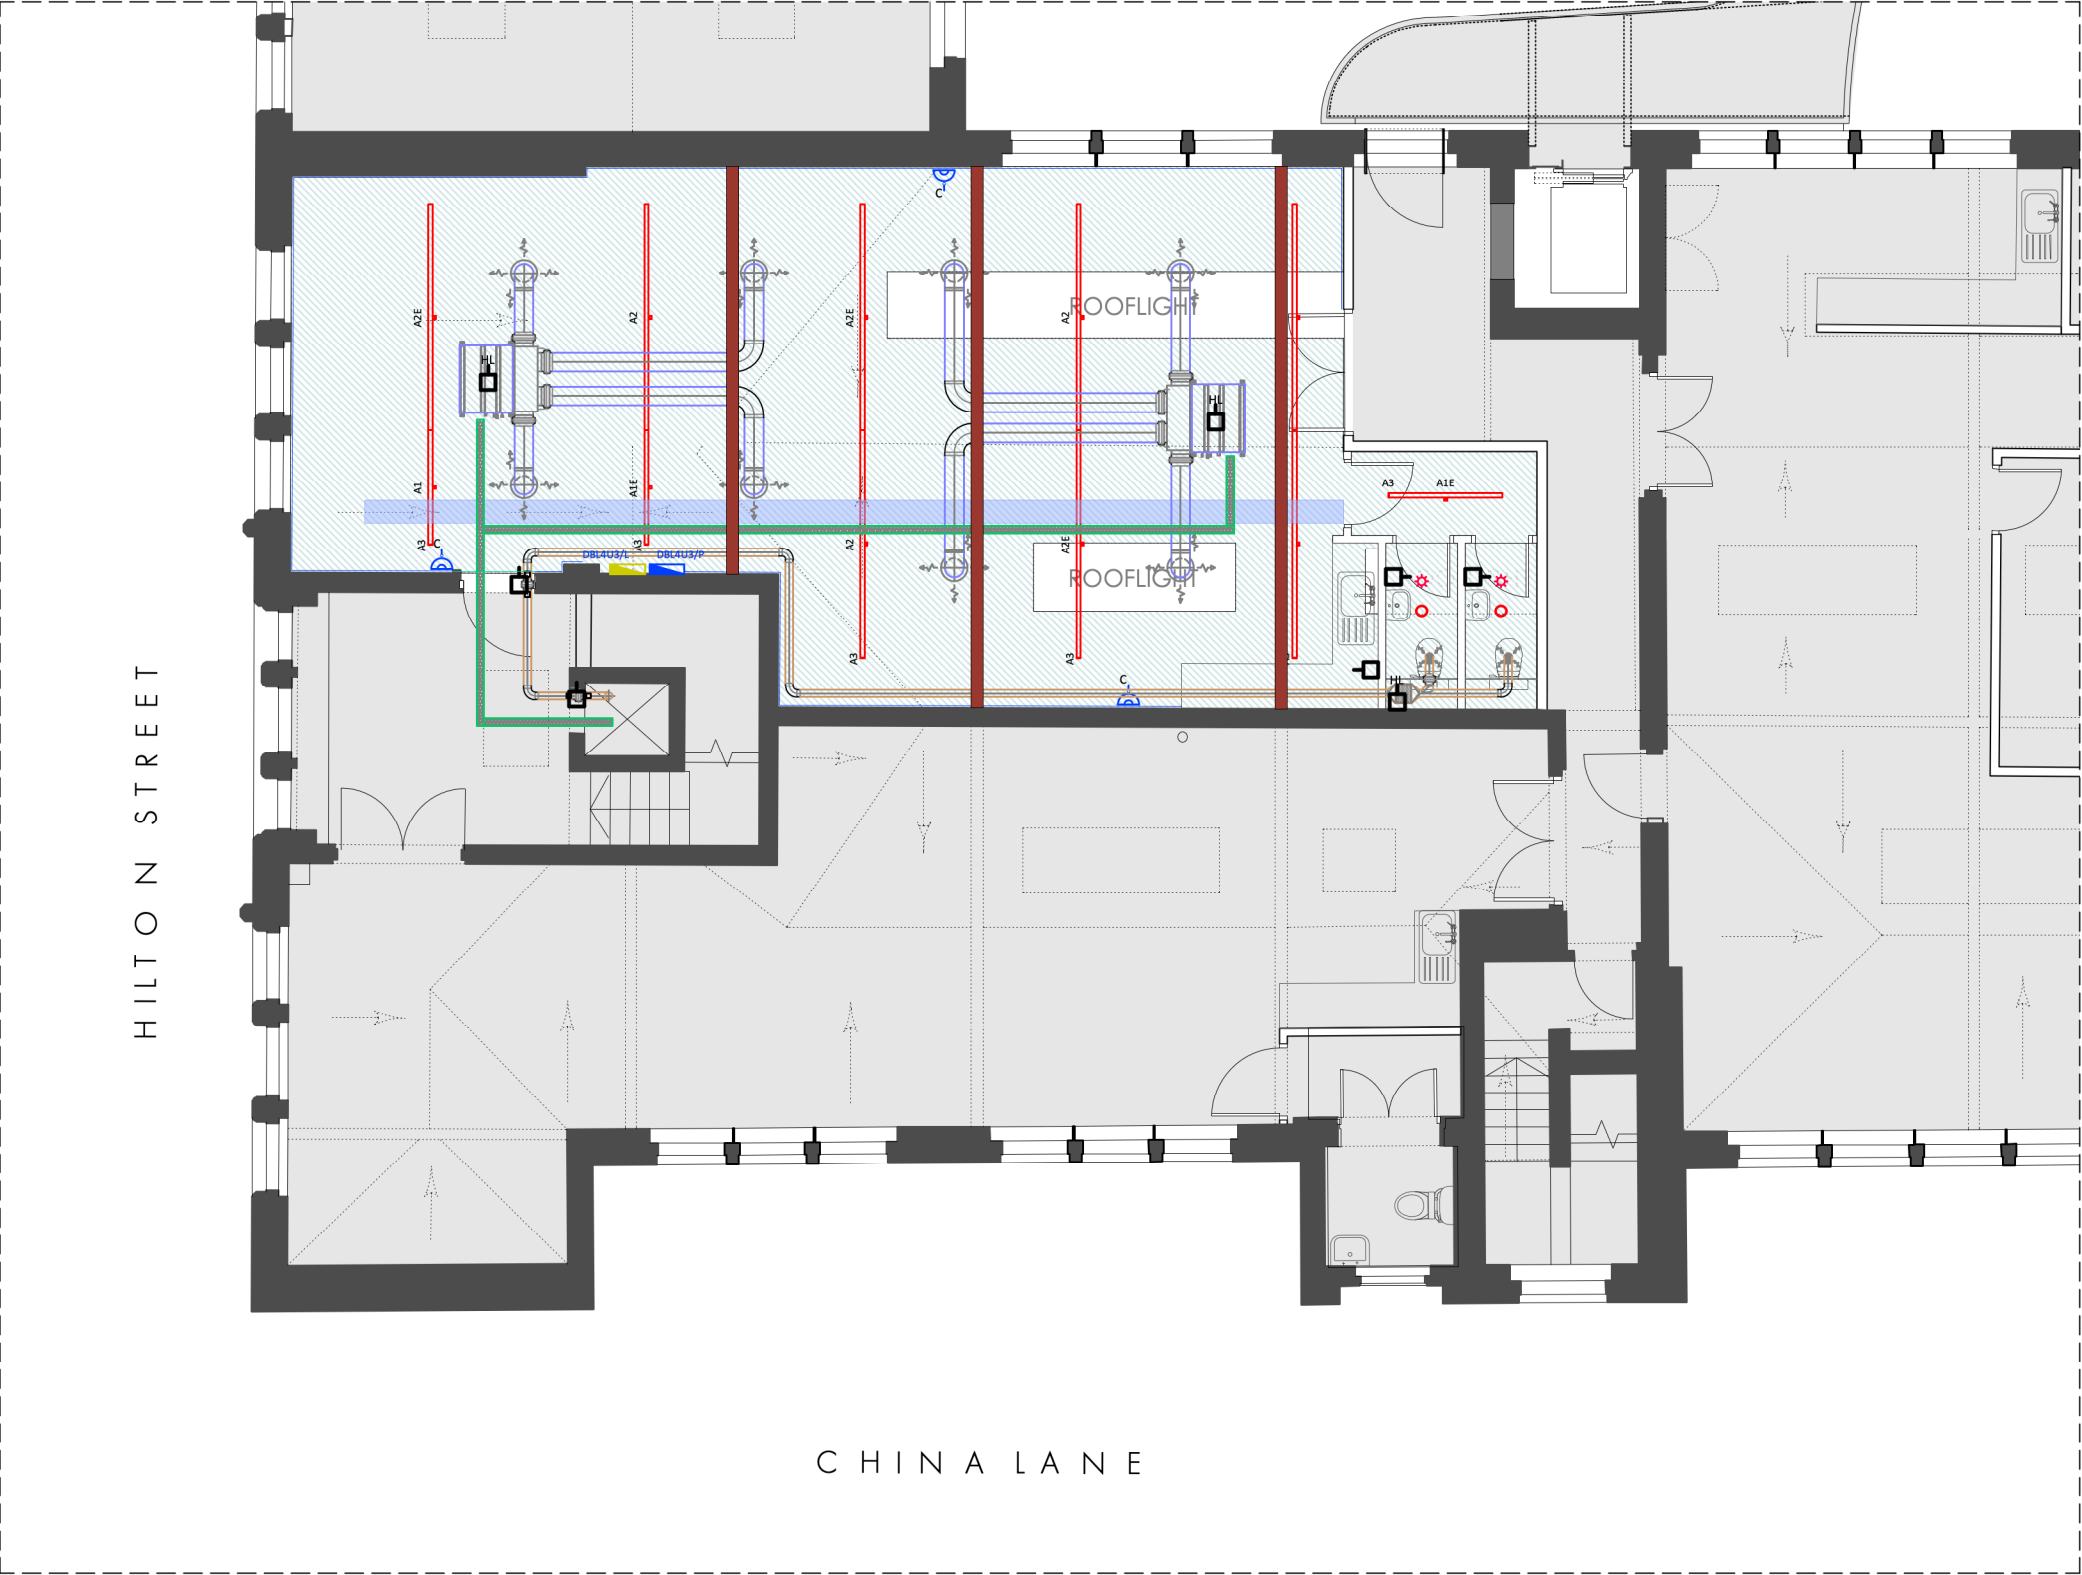


REFLECTED CEILINGS KEY

- EXISTING PLASTERED CEILING
- ORIGINAL TIMBER TRUSSES EXPOSED
- AREA NOT SUBJECT OF THIS APPLICATION
SEE APPLICATIONS No.s 122935/LO/2019& 123242/FO/2019

MECHANICAL AND ELECTRICAL KEY

- ELECTRICAL SYMBOL LEGEND:
- A1 Thorlux 30/45w LED 1500mm Hi-Bar Suspended Continuous Luminaire - Smart Scan (Colour TBC)
 - A1E Thorlux 30/45w LED 1500mm Hi-Bar Suspended Continuous Luminaire - Smart Scan Emergency (Colour TBC)
 - A2 Thorlux 60/90w LED 3000mm Hi-Bar Suspended Continuous Luminaire - Smart Scan (Colour TBC)
 - A2E Thorlux 60/90w LED 3000mm Hi-Bar Suspended Continuous Luminaire - Smart Scan Emergency (Colour TBC)
 - A3 Thorlux Hi-Bar Suspended End Kit
 - A4 Thorlux Hi-Bar Suspension Kit
- VENTILATION LEGEND:
- Extract Fan
 - Extract Grille
 - Volume Control Damper
 - Smoke & Fire Damper
 - Access Panel
 - 300mm x 25mm Galvanised Cable Tray
 - Mitsubishi PEFY Series Fan Coil Unit (Or Equal & Approved)
 - Supply Circular Swirl c/w Coanda Plate (Gilberts Or Equal & Approved)
 - Volume Control Damper
 - Supply Air Ductwork
 - Refrigerant Pipework (High Level)

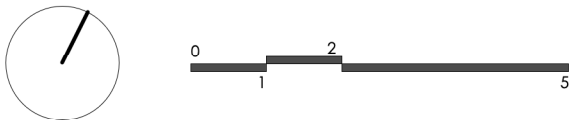

PLANNING

OMI Architects

31 Blackfriars Road, Salford, Manchester, M3 7AQ
+44(0)161 832 3242 / info@omiarchitects.com / www.omiarchitects.com

PROJECT	FOURWAYS HOUSE				
DRAWING	FIFTH FLOOR - PROPOSED CEILINGS PLAN				
DATE	APR' 21	DRAWN BY	KT	SCALE	1:100@A3
JOB NO.	1412	DWG. NO.	L 2237		

FOURWAYS HOUSE, FIFTH FLOOR
PROPOSED REFLECTED CEILINGS PLAN

1.100 @ A3