
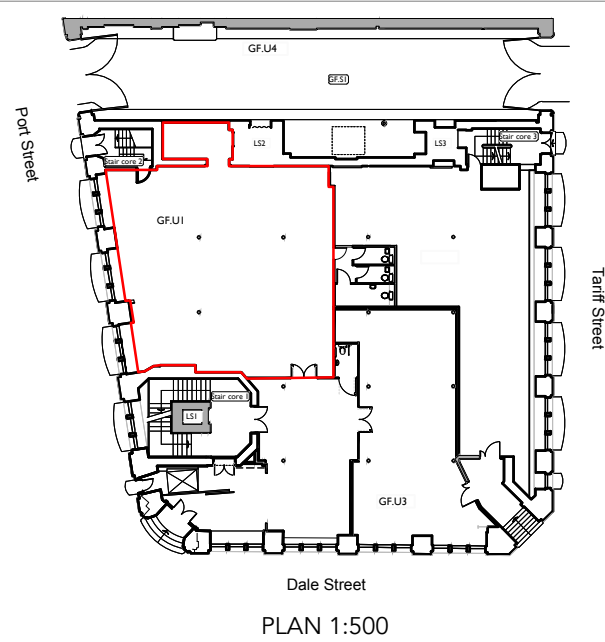


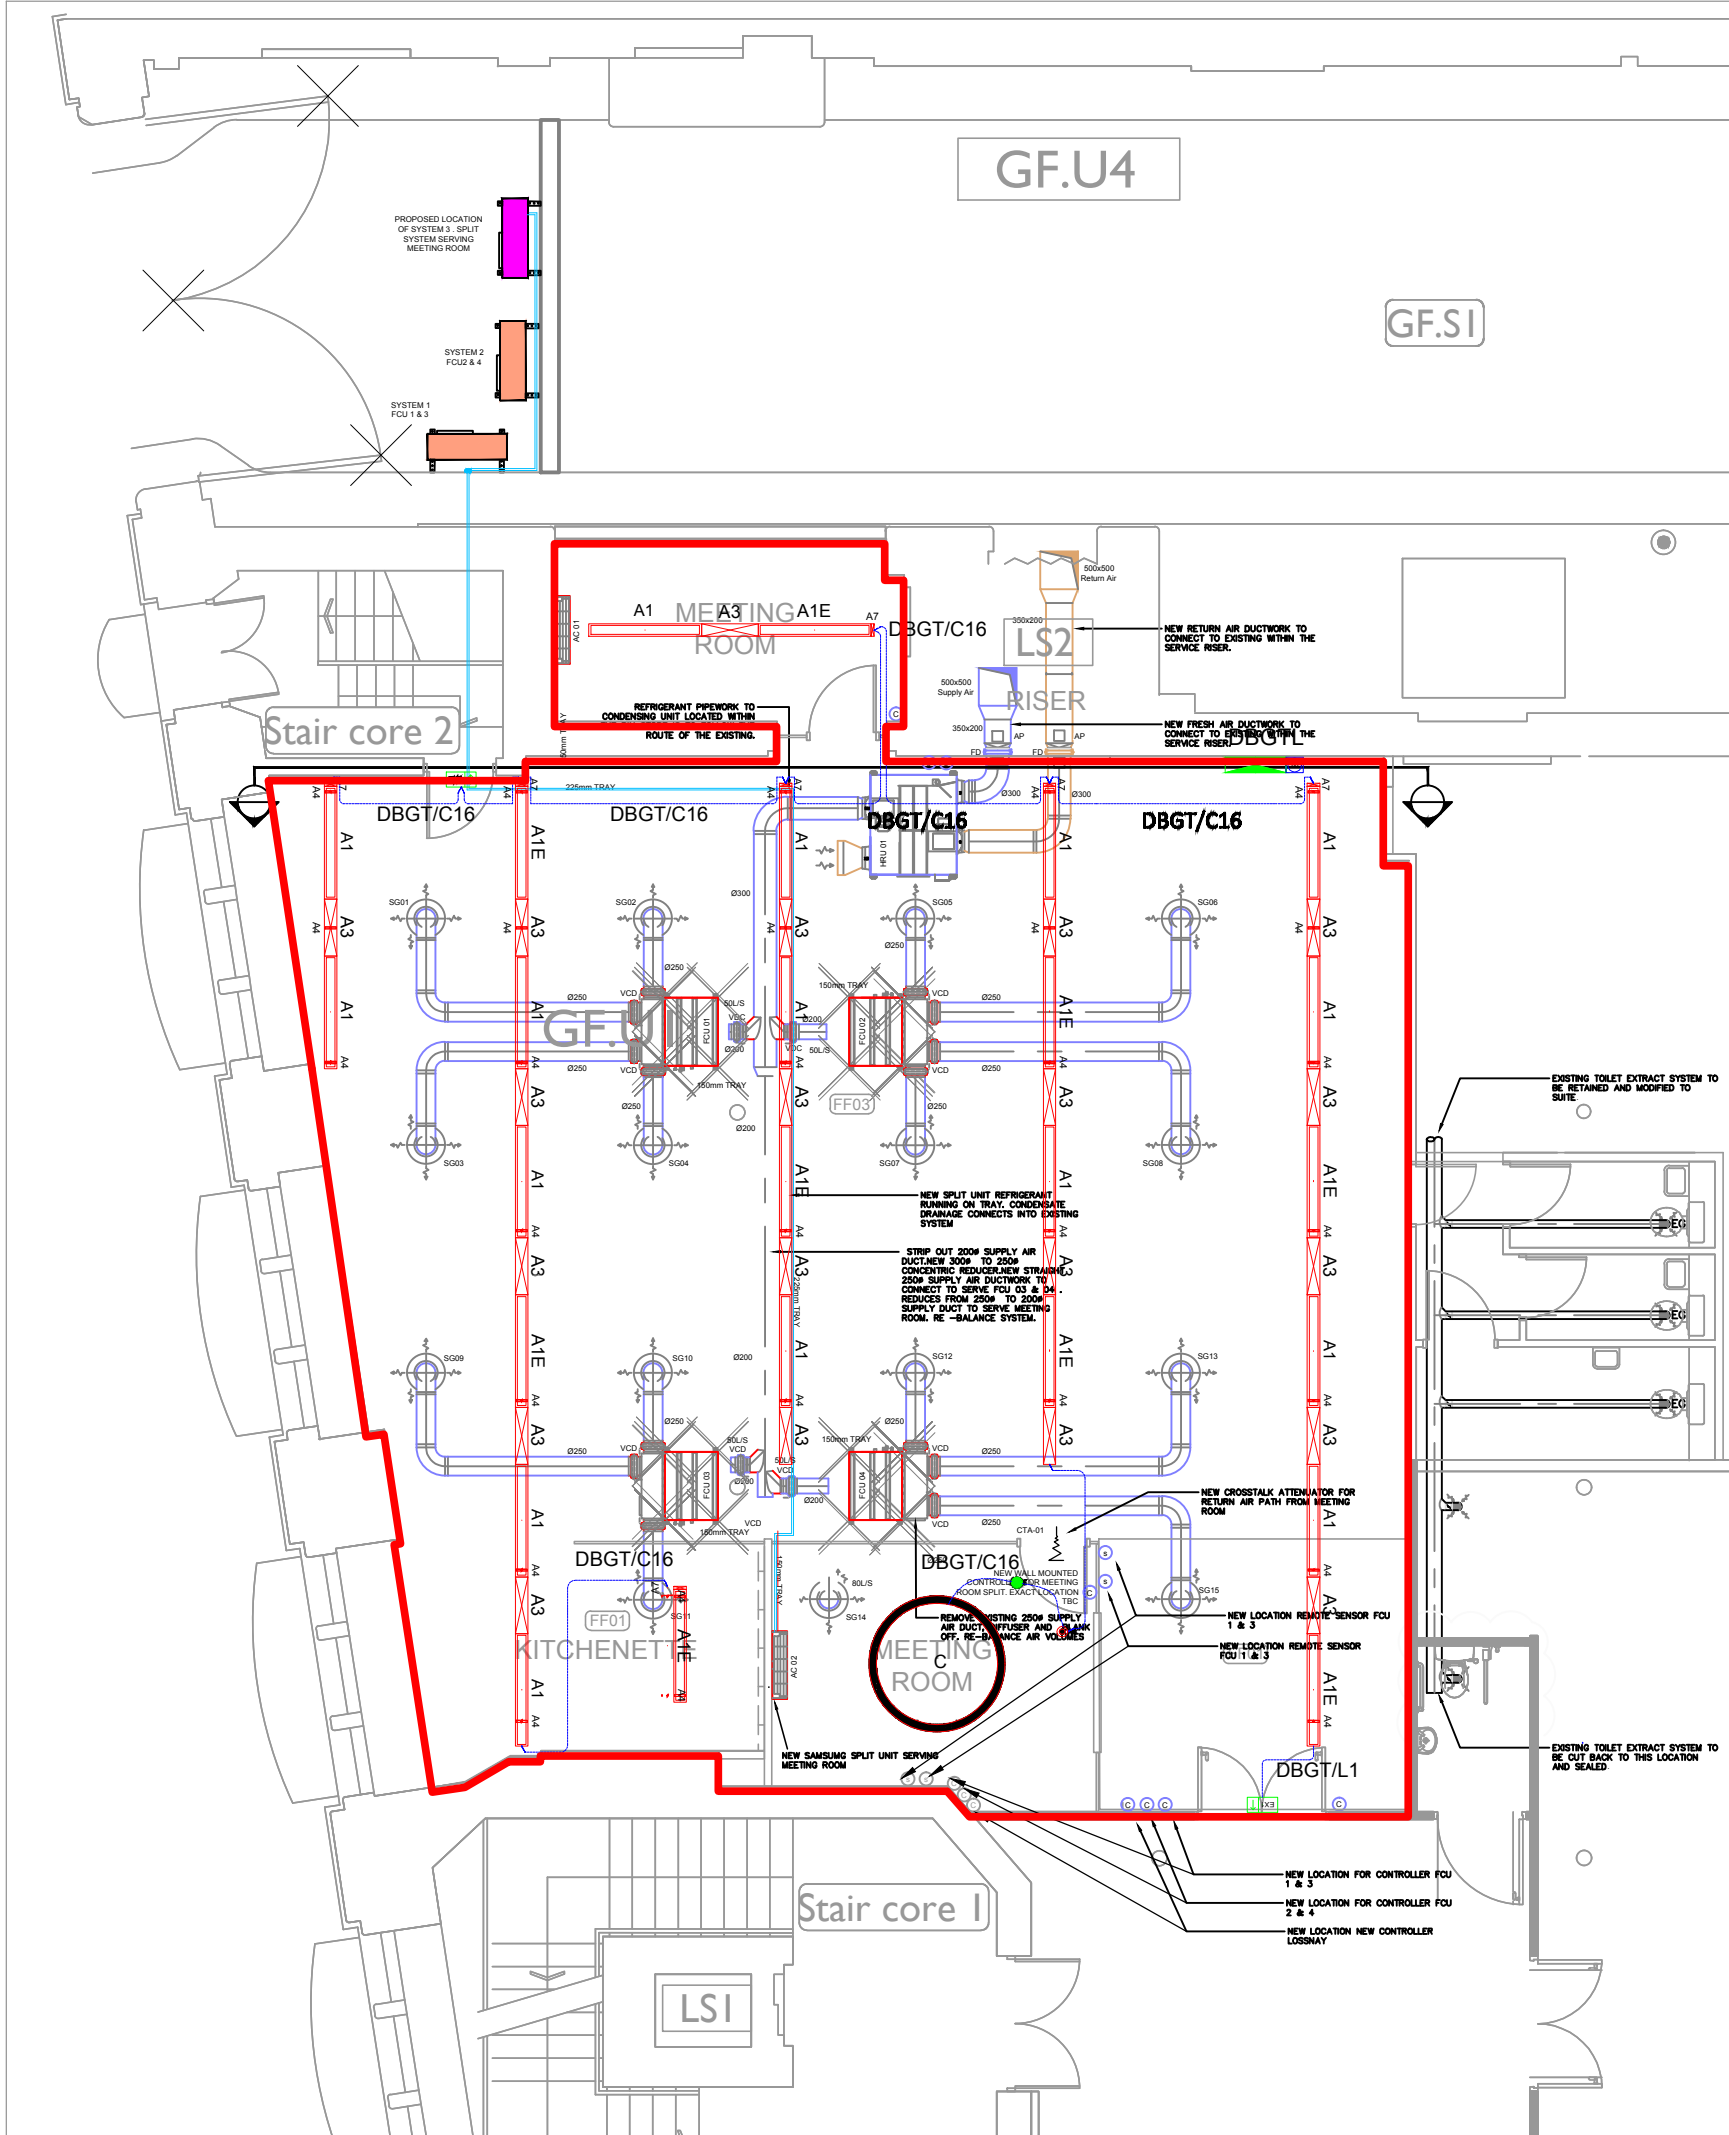

LIGHTING LEGEND			
	22 way split load distribution board	ow energy metering	
	EXISTING THORLUX 31W LED 1500mm LIGHT LINE SUSPENDED SMARTSCAN LUMINAIRE		
	EXISTING THORLUX 31W LED 1500mm LIGHT LINE SUSPENDED SMARTSCAN LUMINAIRE c/w 3HR EMERGENCY BACK UP		
	EXISTING THORLUX 1000mm INFILL SECTION		
	THORLUX SUSPENSION KIT		
	THORLUX END KIT		
	EXISTING 18W LED RECESSED DOWNLIGHTER LUMINAIRE		
	EXISTING 18W LED RECESSED DOWNLIGHTER LUMINAIRE c/w 3HR EMERGENCY BACK UP		
	LIGHTING MOTIONS CENTRO HALO 25 1800mm DIA 4000K (BLACK)		
	RECESSED 3W LED EMERGENCY DOWNLIGHTER c/w 3HR EMERGENCY BACK UP (BLACK)		
	EXISTING 2.8 W DOOR EXIT SIGN c/w 3HR EMERGENCY BACK UP		
	PIR DETECTION		
	SWITCHED FUSED SPUR		
ABBREVIATES THE FOLLOWING			
	EXTRACT FAN		
	CEILING VOID		

AC / VENTILATION LEGEND		
	SUPPLY DUCT (UP & DOWN)	
	EXHAUST DUCT (UP & DOWN)	
	SUPPLY TOP REGISTER OR GRILLE (WALL TYPE)	
	EXHAUST OR RETURN CEILING REGISTER OR GRILLE	
	EXHAUST OR RETURN BOTTOM REGISTER OR GRILLE (WALL TYPE)	
	EXHAUST OR RETURN REGISTER OR TOP GRILLE (WALL TYPE)	
	VANED ELBOW & AIR SPLIT TYPE DUCT TAKE-OFF	
	CONNECT NEW DUCT TO EXISTING DUCT	
	INCLINED RISE, IN DIRECTION OF AIR FLOW	
	INCLINED DROP, IN DIRECTION OF AIR FLOW	
	LIMIT OF DEMOLITION	
	FLEXIBLE CONNECTION	
	VANED ELBOW (PROVIDE ALL SQUARE OR RECTANGULAR ELBOWS WITH VANES EVEN IF SYMBOL IS MISSING)	
	VANED ELBOW (SHORT RADIUS)	
	STANDARD RADIUS ELBOW	
	LOUVER (LOUVER SPECIFIED IN ARCHITECTURAL SECTION)	
	FLEXIBLE DUCTWORK (INSULATED)	
	SUPPLY DUCT	
	EXTRACT DUCT	
	VOLUME CONTROL DAMPER	
	REFRIGERANT PIPEWORK	
	SUPPLY DIFFUSER	
	EXTRACT AIR VALVE	
	DUCTED FAN COIL UNIT	
	CONDENSATE DRAINS	
	OVAL SUPPLY DIFFUSER	
	CONTAINMENT TRAY	
	BALANCING DAMPER	
	EXTRACT FAN	
	ACCESS PANEL	
	FAN COIL WALL MOUNTED CONTROLLER	
	AT-SOB Controller	
	Fire Damper	
	Fire/Smoke Damper	
	Cross Talk Attenuator	

MEETING ROOM SPLIT UNIT POWER INVERTER R32			
TAG	DESCRIPTION	MANUFACTURER	MODEL OR SERIES
AC-02	OUTDOOR	SAMSUNG	AR12TXCAAWKXEU
	INDOOR	SAMSUNG	AR12TXCAAWKXEU

CROSS TALK ATTENUATORS			
TAG	SIZE	DESCRIPTION	BASIS OF DESIGN
		CONSTRUCTION	
		TYPE	SHAPE MANUFACTURER
CTA 1	CROSSTALK	ROUND	HOTCHISS AIR
		DIMENSIONS	MODEL OR SERIES
		250mm x 500mm	CTA 200
		AIR VOL (m³/s)	Ps
		0.072	N/a

NOTES:

Copyright of this drawing is vested in the Contractor and it must not be copied or reproduced without consent.

All dimensions are in Millimeters (mm) unless indicated. Contractor to check all dimensions prior to commencing work onsite & adopt responsibility for dimensional accuracy prior to works.

Drawing to be read in conjunction with all relevant information. Any discrepancies found between information on this drawing, given elsewhere or recorded onsite shall be reported to the Contractor immediately.

DO NOT SCALE FROM THIS DRAWING...
If unsure ask!

PROPOSED GROUND FLOOR RCP PLAN

drawing no. 21.029-ID-4-GF-PVL-0 date 29 APR 21 scale 1:100@A3 rev.

