



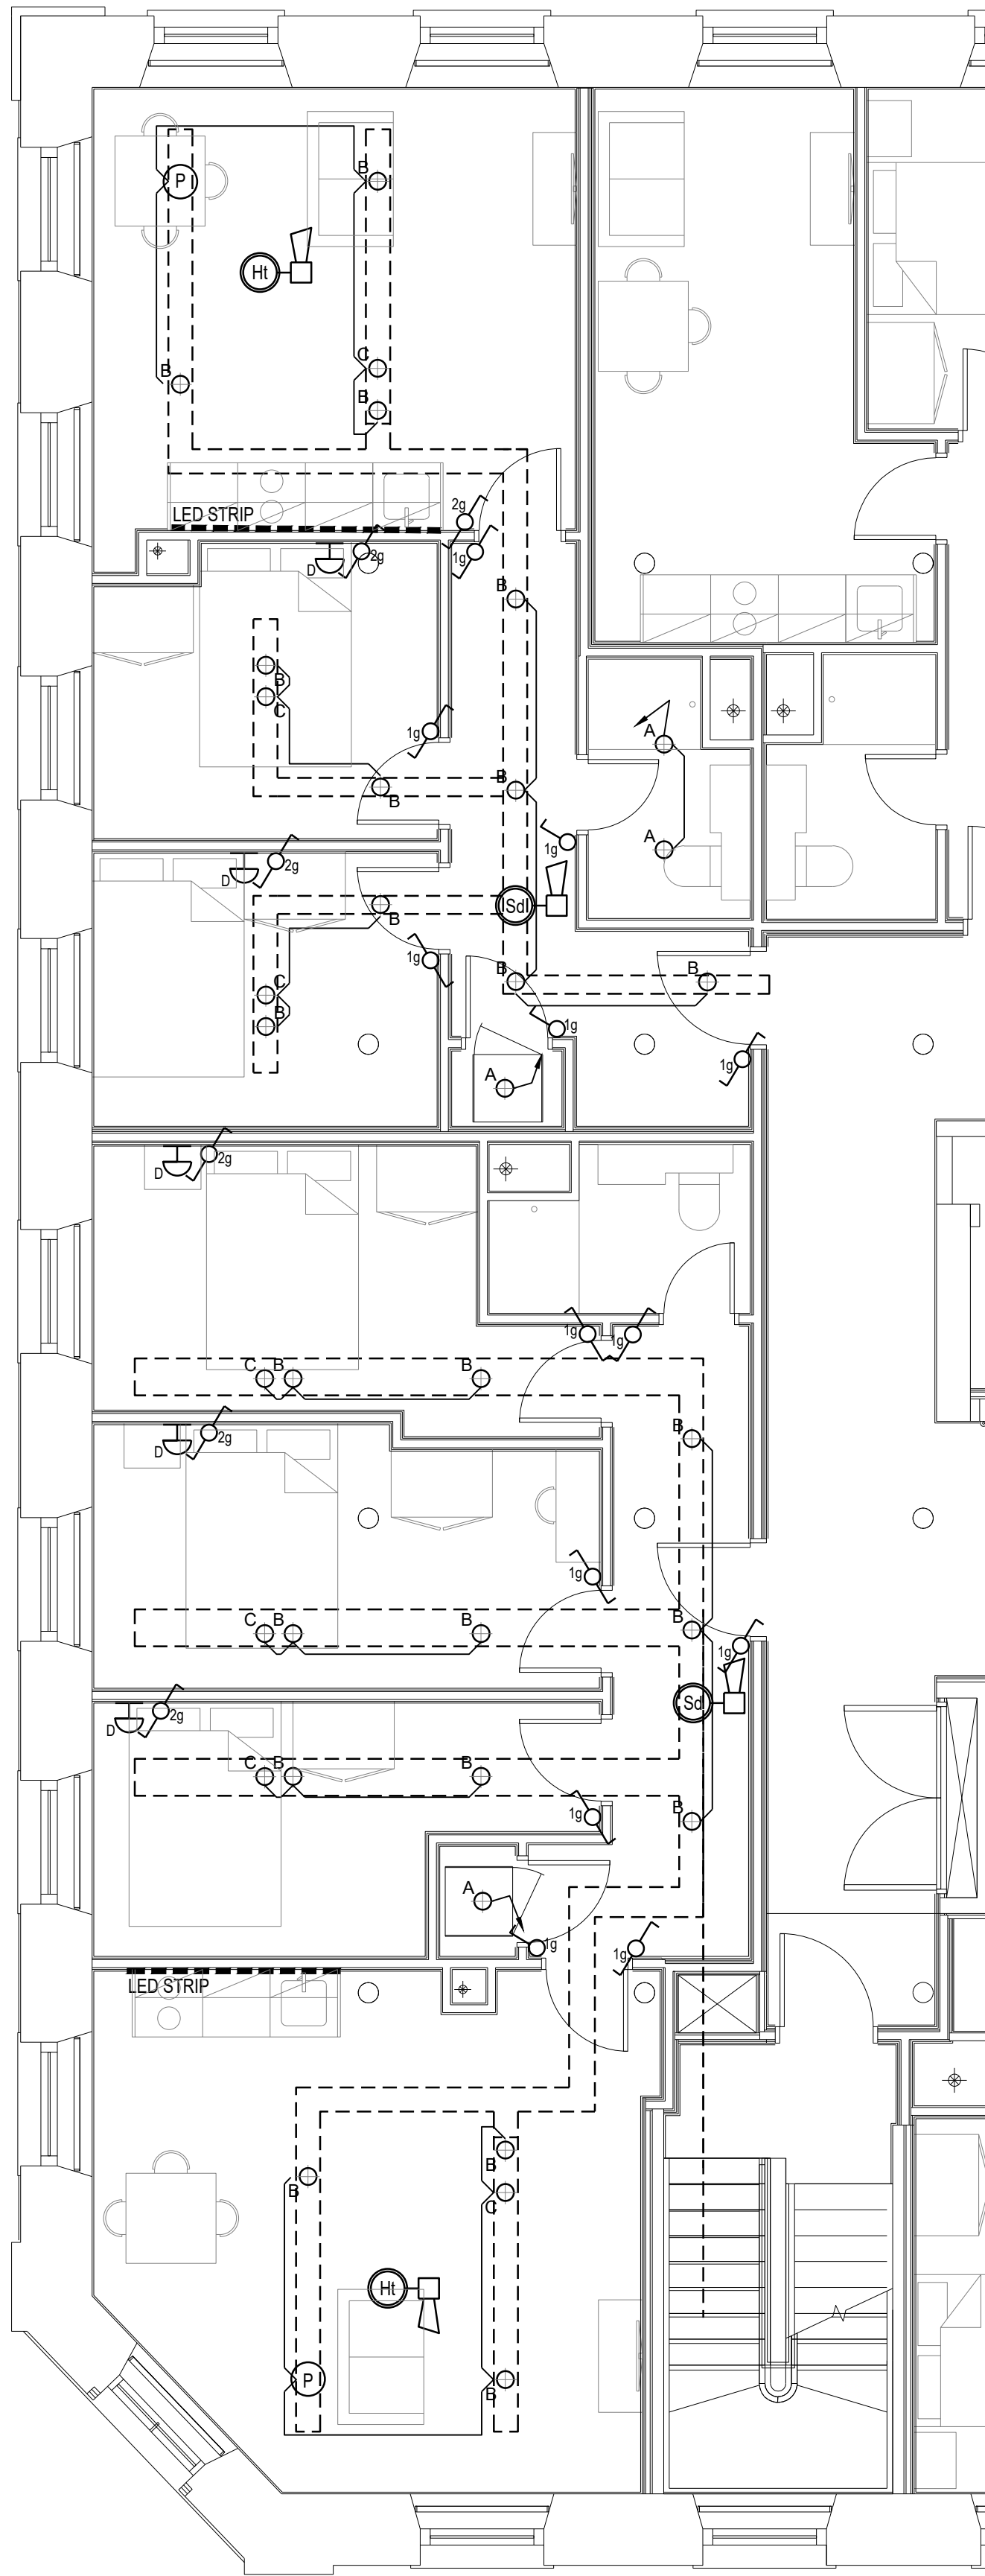

Proposed Second Floor

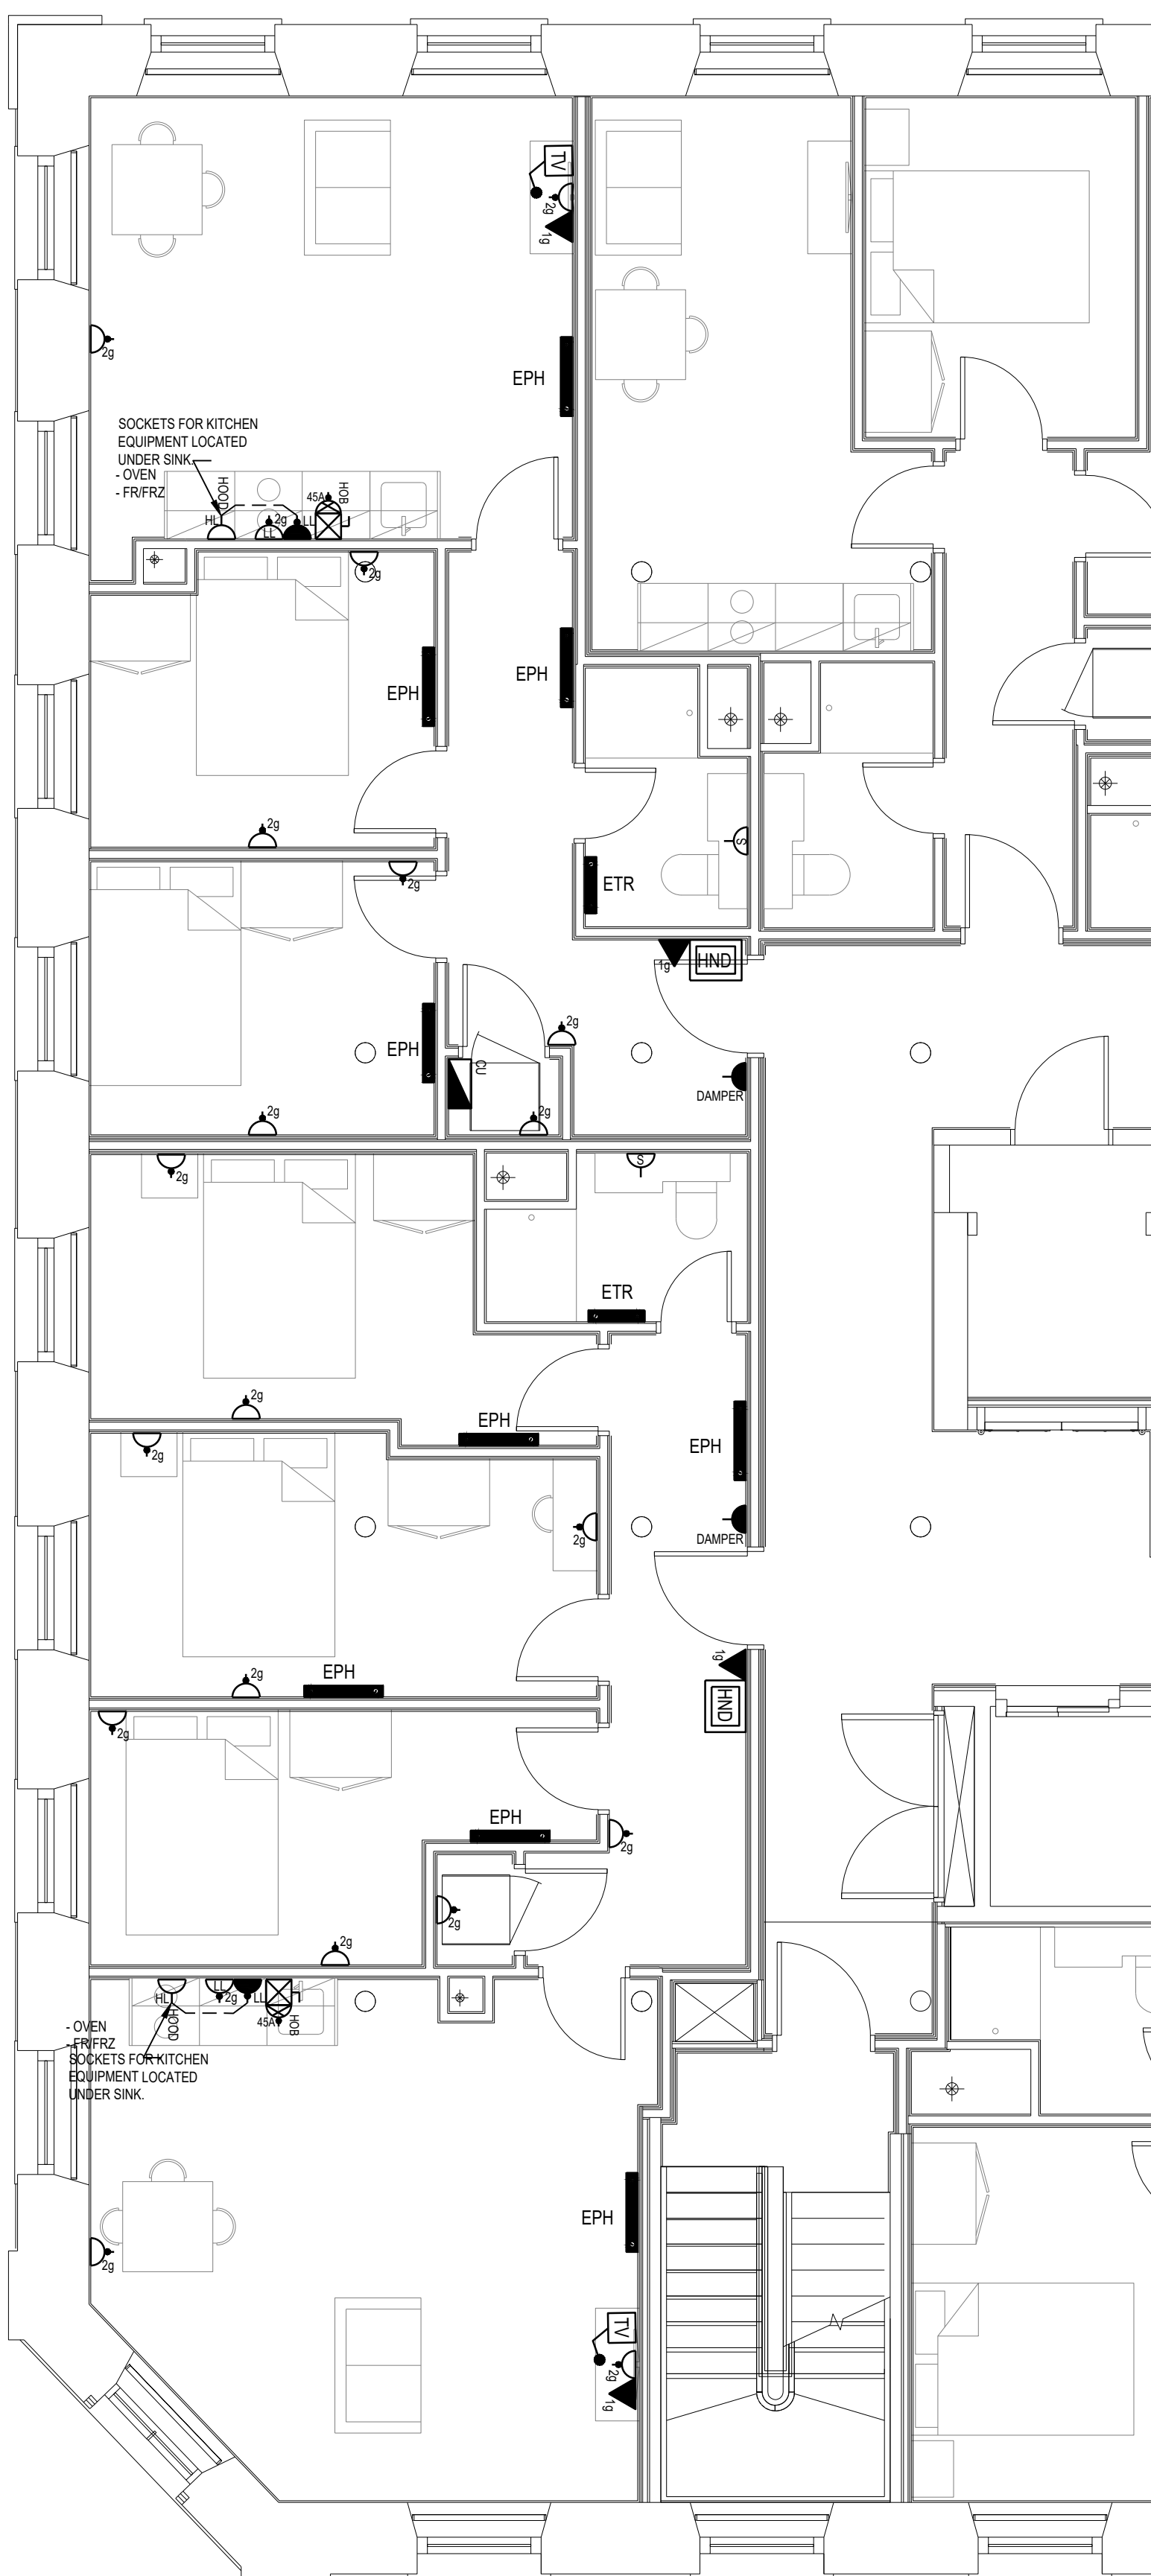

Proposed Second Floor

- LEGEND
- CIRCULAR SURFACE MOUNTED LUMINAIRE  
x = FITTING TYPE (SEE LIGHTING SCHEDULE)
  - CIRCULAR RECESSED LUMINAIRE  
x = FITTING TYPE (SEE LIGHTING SCHEDULE)
  - CIRCULAR RECESSED DOWNLIGHT  
x = FITTING TYPE (SEE LIGHTING SCHEDULE)
  - DOUBLE FLUORESCENT LUMINAIRE  
x = FITTING TYPE (SEE LIGHTING SCHEDULE)
  - SINGLE FLUORESCENT LUMINAIRE  
x = FITTING TYPE (SEE LIGHTING SCHEDULE)
  - WALL MOUNTED LUMINAIRE  
x = FITTING TYPE (SEE LIGHTING SCHEDULE)
  - EMERGENCY EXIT
  - PULL CORD  
x = FITTING TYPE (SEE LIGHTING SCHEDULE)
  - 1 WAY LIGHT SWITCH - xg = No. OF GANGS
  - 2 WAY LIGHT SWITCH - xg = No. OF GANGS
  - LIGHTING CONTROL MODULE  
xx = DENOTES MAXIMUM CIRCUITS
  - PIR-OCUPANCY SENSOR
  - FITTINGS INDICATED WITH 'E' DENOTES 3HR MAINTAINED EMERGENCY PACK INTEGRAL. PLEASE REFER TO SPECIFICATION FOR DETAILS
  - INDICATES CIRCUITS BETWEEN PIR AND LIGHTING CONTROL MODULE
  - INDICATES CIRCUITS BETWEEN LIGHTING CONTROL MODULE AND LIGHT FITTINGS
  - INDICATES LIGHTING CIRCUITS
  - SMOKE DETECTOR
  - HEAT DETECTOR

- LEGEND
- 13A SWITCHED SOCKET OUTLET.  
Xg = No. OF GANGS.
  - 13A UN-SWITCHED SOCKET OUTLET.  
Xg = No. OF GANGS.
  - 13A SWITCHED FUSED SPUR.
  - 13A UN-SWITCHED FUSED SPUR.
  - CLEANERS SOCKET (LOW LEVEL).
  - SHOWER SOCKET.
  - ISOLATOR.  
XX3N = TP OR SPBN  
XXA = RATING AMPS.
  - DISTRIBUTION BOARD.
  - INTERCOM HANDSET
  - RJ45 DATA OUTLET  
Xg = No. OF GANGS.
  - RJ45 VOICE / TELEPHONE OUTLET  
Xg = No. OF GANGS.
  - WIRELESS ACCESS POINT.
  - HIGH LEVEL.
  - LOW LEVEL.
  - WITHIN CEILING VOID.
  - ABOVE WORKTOP

- NOTES
- ALL SERVICE ROUTES DETAILED ARE APPROXIMATE. THE CONTRACTOR SHALL BE RESPONSIBLE FOR DETERMINING THE EXACT ROUTES AND POSITIONS OF ALL INSTALLED SERVICES AND EQUIPMENT.
  - THE EXACT POSITION OF ALL SERVICES AND EQUIPMENT SHALL BE AGREED BY THE CONTRACT ADMINISTRATOR.
  - THE CONTRACTOR SHALL BE RESPONSIBLE FOR FULLY CO-ORDINATING ANY SERVICES INSTALLED WITH THE BUILDING FABRIC AND SERVICES INSTALLED BY OTHERS.
  - THIS DRAWING SHALL BE READ IN CONJUNCTION WITH ALL MECHANICAL, ELECTRICAL, ARCHITECTURAL AND STRUCTURAL DRAWINGS, CONTRACT DOCUMENTATION AND SPECIFICATION FOR THE WORKS.
  - THIS DRAWING FORMS PART OF THE SPECIFICATION FOR THE WORKS.
  - ALL DIMENSIONS SHOWN ARE IN MILLIMETRES.
  - DO NOT SCALE FROM THIS DRAWING.
  - EXISTING SERVICES SHOWN FAINT.
- LIGHTING NOTES
- ALL LUMINAIRES TO COME COMPLETE WITH LED DRIVERS AND LAMPS. THE CONTRACTOR SHALL BE RESPONSIBLE FOR ORDERING THE CORRECT LUMINAIRES AND FIXING ACCESSORIES WHICH ARE COMPATIBLE WITH THE INTENDED CEILING SYSTEMS AND STRUCTURE IN EACH RESPECTIVE AREA.
  - ALL LUMINAIRE POSITIONS ARE INDICATIVE FOR TENDER PURPOSES. ALL FINAL LOCATIONS TO BE AGREED BY THE ELECTRICAL SERVICES CONTRACTOR THROUGH CONSULTATION WITH THE PROJECT ARCHITECT PRIOR TO INSTALLATION.
  - FOR MORE ACCURATE LUMINAIRE DETAILS, PLEASE REFER TO THE LUMINAIRE SCHEDULE.
- SMALL POWER NOTES
- ALL WIRELESS ACCESS POINTS SHALL BE CEILING MOUNTED AND CO-ORDINATED WITH CEILING SERVICES. PLEASE REFER TO ARCHITECT'S DRAWINGS FOR SETTING OUT DETAILS.
  - ALL SOCKET / DATA OUTLETS POSITIONS ARE INDICATIVE ONLY. FINAL SETTING OUT TO BE IN ACCORDANCE WITH ARCHITECT'S DRAWINGS.
  - THE CONTRACTOR SHALL ALLOW FOR WIRING TO THE SMOKE FIRE DAMPER IN EACH APARTMENT, DAMPER CONTROLLER AND FIRE ALARM INTERFACE UNITS TO BE PROVIDED BY THE MECHANICAL CONTRACTOR.

|                                                                                                                                   |               |                      |
|-----------------------------------------------------------------------------------------------------------------------------------|---------------|----------------------|
| T1                                                                                                                                | 21-05-21      | ISSUED FOR TENDER    |
| REV                                                                                                                               | DATE          | REVISION DESCRIPTION |
| CLIENT<br>BEECH HOLDINGS                                                                                                          |               |                      |
| PROJECT<br>PICCADILLY WAREHOUSE                                                                                                   |               |                      |
| TITLE<br>ELECTRICAL SERVICES - TYPICAL APARTMENT LAYOUT                                                                           |               |                      |
| <br><b>Parker Wilson Consulting</b>          |               |                      |
| ■ Burnham House, 373 Bury New Road,<br>Manchester, M25 1AW<br>T: 0161 773 1177 F: 0161 773 9977<br>manchester@parker-wilson.co.uk |               |                      |
| □ 2nd Floor, 72, Cannon Street.<br>London EC4N 6AE<br>T: 0207 251 4500<br>london@parker-wilson.co.uk<br>www.parker-wilson.co.uk   |               |                      |
| DRAWN BY<br>AL                                                                                                                    | CHECKED<br>DM | APPROVED BY<br>PG    |
| SCALE<br>NTS                                                                                                                      | SIZE<br>A1    | DATE<br>APRIL 21     |
| DRAWING No<br>4087-PWC-MH-B1-PL-E-0040                                                                                            | REV<br>T1     |                      |

TENDER