

NOTES:
All dimensions must be checked on site and not scaled from this drawing.

Ref.	Date	Revisions	By
P01	30.08.19	PRELIMINARY ISSUE	B.W.
C01	25.10.19	CONSTRUCTION ISSUE	B.C.
C02	29.01.20	REVISIONS AS CLOUDED	B.W.
C03	08.12.20	REVISIONS AS CLOUDED	C.P.
C04	10.02.21	CANOPY & EXT LTG AMENDED	B.C.
C05	12.04.21	AMENDED AS CLOUDED	C.P.
C06	27.05.21	AMENDED AS CLOUDED	C.P.

GENERAL NOTES:

- ALL DIMENSIONS ARE IN MILLIMETRES UNLESS OTHERWISE INDICATED.
- THIS DRAWING IS TO BE READ IN CONJUNCTION WITH THE DISTRIBUTION BOARD SCHEDULES AND LIGHTING TECHNICAL SUBMITTALS.
- PRINCIPLE CONTRACTOR TO ENSURE ALL EMERGENCY EXIT SIGNAGE POSITIONS / DIRECTION ARROWS ARE AGREED WITH BUILDING CONTROL PRIOR TO CONSTRUCTION.
- ALL EMERGENCY LIGHT FITTINGS TO BE POWERED FROM LOCAL LIGHT CIRCUIT.
- ARCHITECT TO CONFIRM SETTING OUT LOCATIONS OF ALL FIXTURES AND PROVIDE REFLECTED CEILING PLANS FOR SITE USE.
- ABOVE DOOR B24 LUMINAIRES TO BE SWITCHED VIA DEDICATED KEY SWITCH IN RISER.

INTERNAL LIGHTING LEGEND:

B23	ASTORIA/820/84
B24	LIL/2/500/36"
H	HEN/1500/84 4K 350mA
D	LBD/1630/4
L1	WPZ/4/2910/84
L2	WPZ/5/3650/84
L3	WPZ/5/6210/84
W1E	ZMP LED/3217/84
EXT	EXTERNAL EMERGENCY CIRCULAR BULKHEAD
EC	LED2/KIT/CORRIDOR OPTIC
EO	LED2/KIT/OPEN AREA OPTIC

'E' DENOTES LUMINAIRE TO C/W 3 HOUR INTEGRAL EMERGENCY BATTERY

EMERGENCY EXIT LEGEND:

E1	LED EXIT SIGN WALL MOUNTED ARROW UP
E2	LED EXIT SIGN CEILING MOUNTED ARROW UP
E3	LED EXIT SIGN CEILING MOUNTED ARROW DOWN
E4	LED EXIT SIGN CEILING MOUNTED DOUBLE SIDED
E5	LED EXIT SIGN CEILING MOUNTED ARROW RIGHT
E6	LED EXIT SIGN CEILING MOUNTED ARROW LEFT
E7	LED EXIT SIGN CEILING MOUNTED ARROW LEFT (DIAGONAL DOWN)

LIGHTING CONTROL LEGEND:

P1	SURFACE 360, INFRARED PRESENCE DETECTOR
P2	FLUSH 360, DALI INFRARED PRESENCE DETECTOR
P3	MID RANGE DALI MICROWAVE SENSOR
P4	FLUSH 360, DALI INFRARED PRESENCE DETECTOR (LONG RANGE)
P5	SURFACE 360, DALI INFRARED PRESENCE DETECTOR
'X'	RETRACTIVE SWITCH - 'X' DENOTES No. OF GANGS
	TWO-WAY RETRACTIVE SWITCH
	INTERMEDIATE RETRACTIVE SWITCH
	EMERGENCY KEY SWITCH

	CIRCUIT LINE
	SWITCH LEADER

FEATURE LIGHTING LEGEND:



B20	DELTALIGHT MAXISPY ON 93035 DIM1 DIRECTIONAL EXPOSED SPOT
B21	DELTALIGHT BOXY XL R 93037 DIM1 EXPOSED SPOT
B22	FLOS FEATURE PENDANT
B26	FLOS RUNNING MAGNET 2.0 SPOT LIGHT
B27	FLOS LIGHT STRIPE 900mm
B28	FLOS RECESSED COMPASS BOX 170mm(L) x 95mm(W) x 205mm(D)
B29	2530mm RECESSED MILLIE OPAL LED LINEAR

CONSTRUCTION



Building Services Engineering

Unit 9-10 Olympic Court, Boardmans Way,
Whitehills Business Park, Blackpool, FY4 5GU
Tel: 01253 760160
E-mail: info@ameon.co.uk

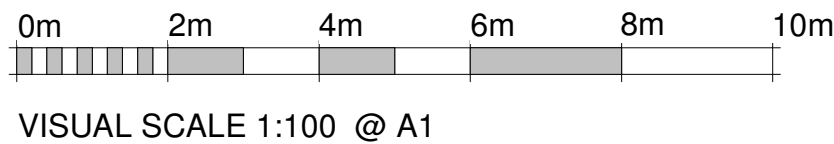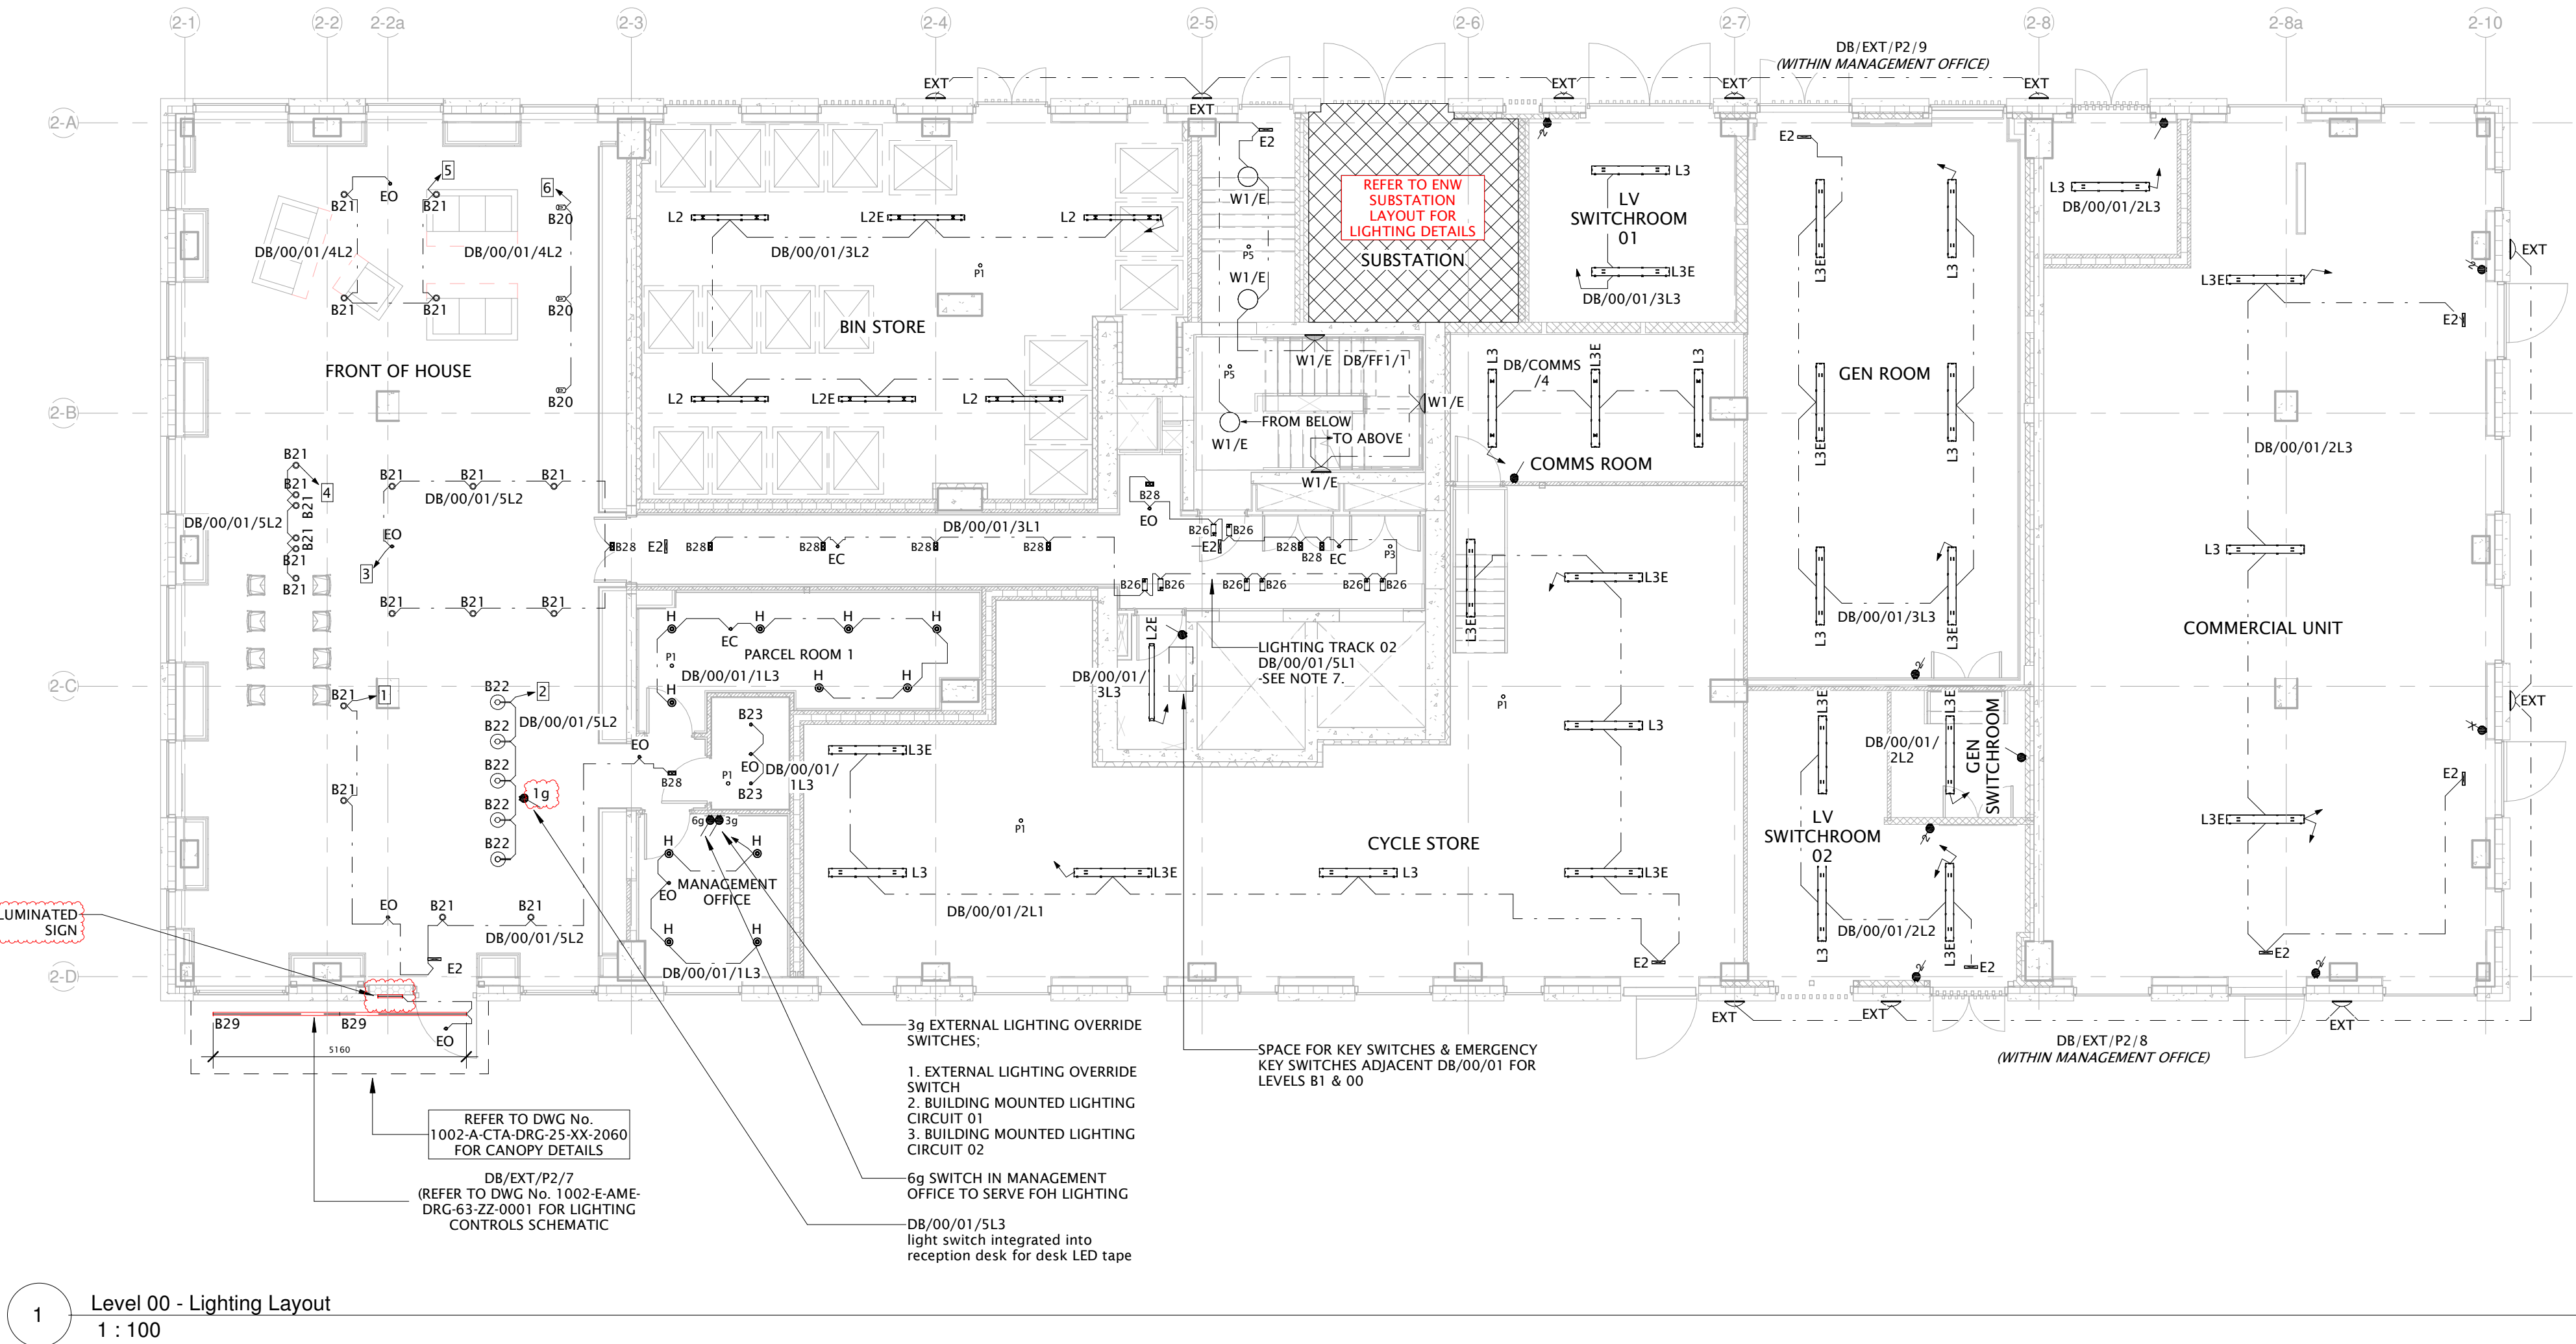

VISUAL SCALE 1:100 @ A1



Angel Meadows Plot 2

LEVEL 00 LIGHTING LAYOUT

Client	Job Title	Drawing Title	Date August 2019
			Scale @ A1 1 : 100
			Drawn by B.W.
			Drawing Number 1002-E-AME-DRG-63-GF-2002
			Revision C06