


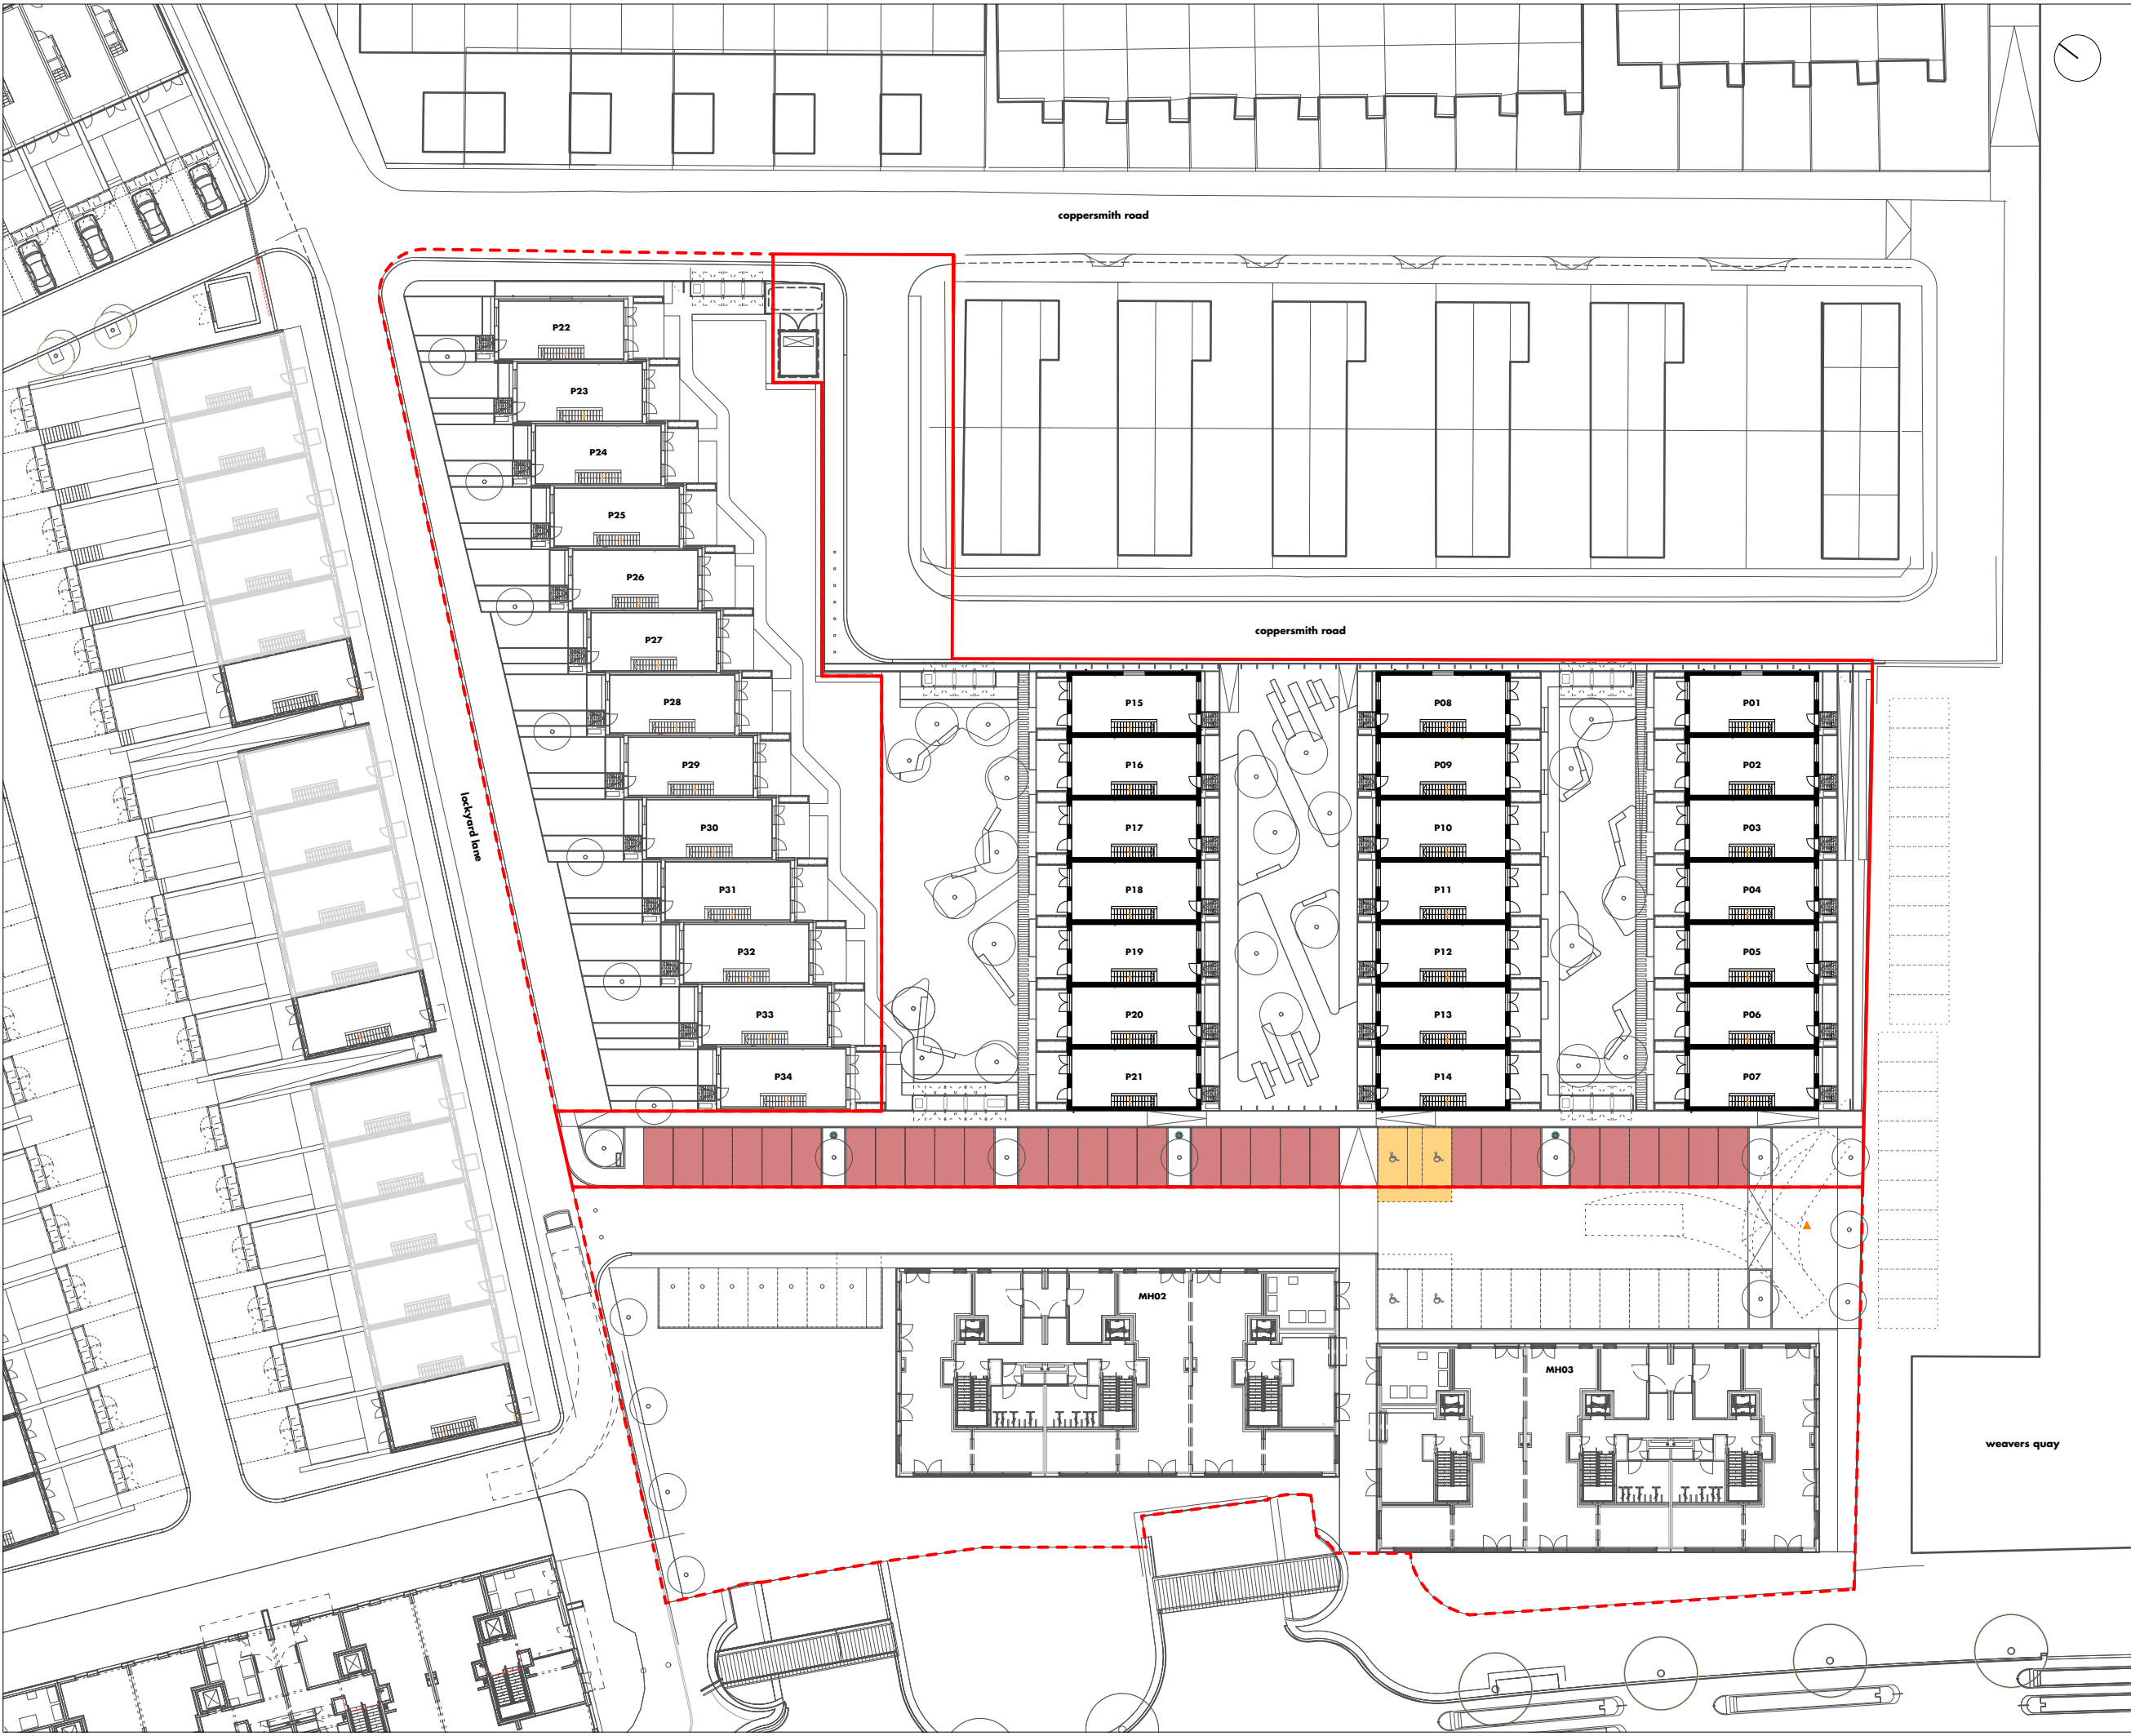

- standard space - 3A residential + visitor parking
- accessible space  
- 1200mm access strip
- electric charge point
- fire tender turning head

shedkm

+44 (0)151 709 8211  
+44 (0)207 253 8881

|                |                |
|----------------|----------------|
| project        | NI3            |
| client         | urban splash   |
| drawing number | NI3 (00) 125 • |
| scale          | 1:500 @ a3     |
| status         | information    |

site plan • 3A parking allocation

do not scale from this drawing • all dimensions are to be set out and checked on site prior to starting construction • any discrepancy found between information given on this drawing and that given elsewhere or recorded on site shall be brought to the attention of the project architect immediately