
 


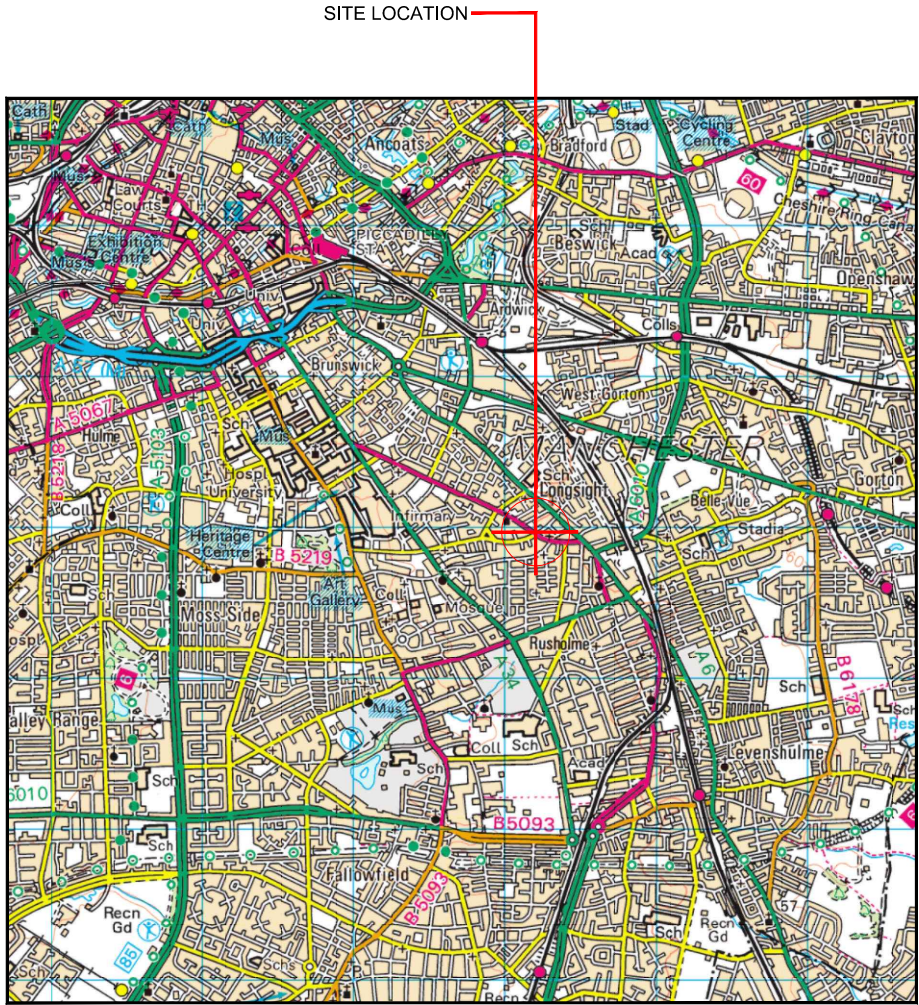


Reproduced by permission of Ordnance Survey on behalf of the Controller of Her Majesty's Stationery Office
All rights reserved. © Crown Copyright licence no. 100022432

SITE AREA PLAN

Scale 1:50000



SITE PHOTOGRAPH

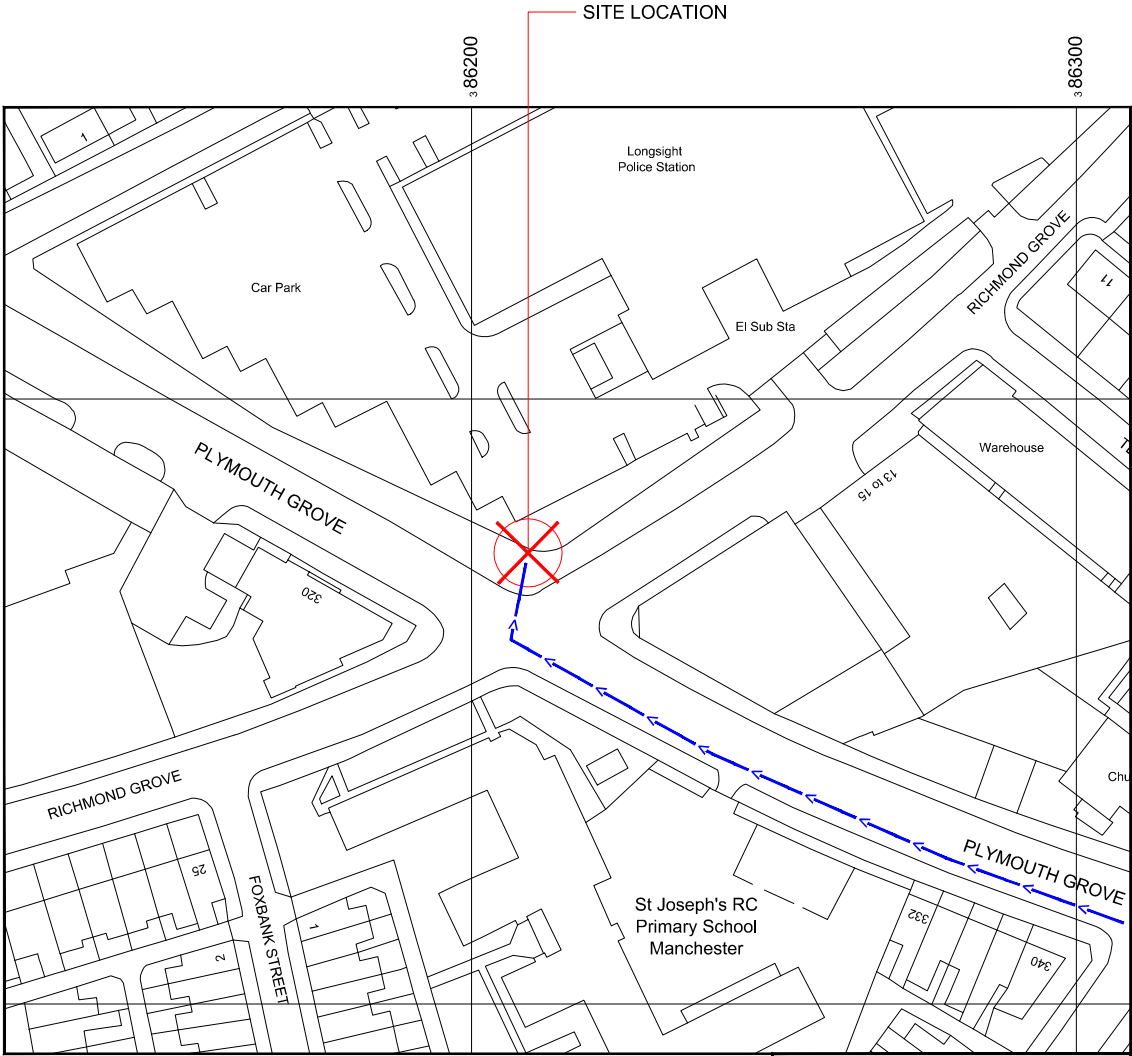


Reproduced by permission of Ordnance Survey on behalf of the Controller of Her Majesty's Stationery Office
All rights reserved. © Crown Copyright licence no. 100022432

NGR E: 386210 N: 395973

SITE LOCATION PLAN

 Scale 1:1250



GOOGLE MAPS QR CODE

 
GOOGLE MAPS - Hyperlink to map of the site

GOOGLE STREETVIEW - Hyperlink to streetview of the site

NOTES:

1. ALL DIMENSIONS IN MM UNLESS OTHERWISE NOTED.
- From the end of the A57(M) take the A6 South. At the first roundabout continue straight on the A6. After approx 1.7km turn right onto the A5184. The site is located on the right hand side after approx 310m.

Site Provider's
Property Boundary:
Access Route To Site:
Access Route:



Master:	MBNL / EE / H3G:	Project:	Purpose of Issue:	Issue:
M001	MBNL	NTQ	Planning	A
Date:	11/06/2021	Revision / Upgrade Description:		
Drawn:	J.BOOTE	First Issue		
Checked:	J.STOCKDALE			
Approved:	J.STOCKDALE			



Hutchison 3G UK Limited
Star House, 20 Grenfell Road
Macclesfield, SK10 1EH
Tel: 01628 765 000
Fax: 01628 765 001



Hatfield Business Park
Hatfield
Hertfordshire
AL10 9BW
Tel: 01707 315000
Fax: 01707 319001



Mobile Broadband Network Limited
Sixth Floor, Thames Tower, Station Road, Reading, RG1 1LX

Design Consultant & Principal Contractor:



WHP Telecoms
Unit 1 Maple Park,
Low Fields Avenue, Leeds
LS12 6HH

Tel: 01133023550
e-mail: info@whptelecoms.com


Site Name:	PLYMOUTH GROVE		
Site ID:	1494015		
Address:	PLYMOUTH GROVE, MANCHESTER, GREATER MANCHESTER, M13 0LB		
Title:	002 SITE LOCATION PLAN		
Project:	NTQ		
Purpose of Issue:	PLANNING		
EE Cell ID:	MBNL Cell ID:	3UK Cell ID:	
75911	MAN396	M0794	
Master Drawing No:			Issue:
1494015_MAN396_75911_M0794_M001			A

Asset Reference	Asset Description:	Asset Status:	Antenna / Dish / MHA / RRU / Equipment Access Description:	Asset Reference	Asset Description:	Asset Status:	Antenna / Dish / MHA / RRU / Equipment Access Description:
CAB1	Cabinet	Proposed	Unrestricted access	A1-A4	Antenna	Proposed	Cherry Picker Access
CAB2	Cabinet	Proposed	Unrestricted access	B1-B4	Antenna	Proposed	Cherry Picker Access
CAB3	Cabinet	Proposed	Unrestricted access	C1-C4	Antenna	Proposed	Cherry Picker Access
CAB4	Cabinet	Proposed	Unrestricted access	TD1	Dish	Proposed	Cherry Picker Access
CAB5	Cabinet	Proposed	Unrestricted access	TD2	Dish	Proposed	Cherry Picker Access
CAB6	Cabinet	Proposed	Unrestricted access				
CAB7	Cabinet	Proposed	Unrestricted access				

NOTES:


1. ALL DIMENSIONS IN MM UNLESS OTHERWISE NOTED.

DEFINED ACCESS ROUTE DESCRIPTION FROM SITE ENTRANCE TO THE EQUIPMENT: N/A

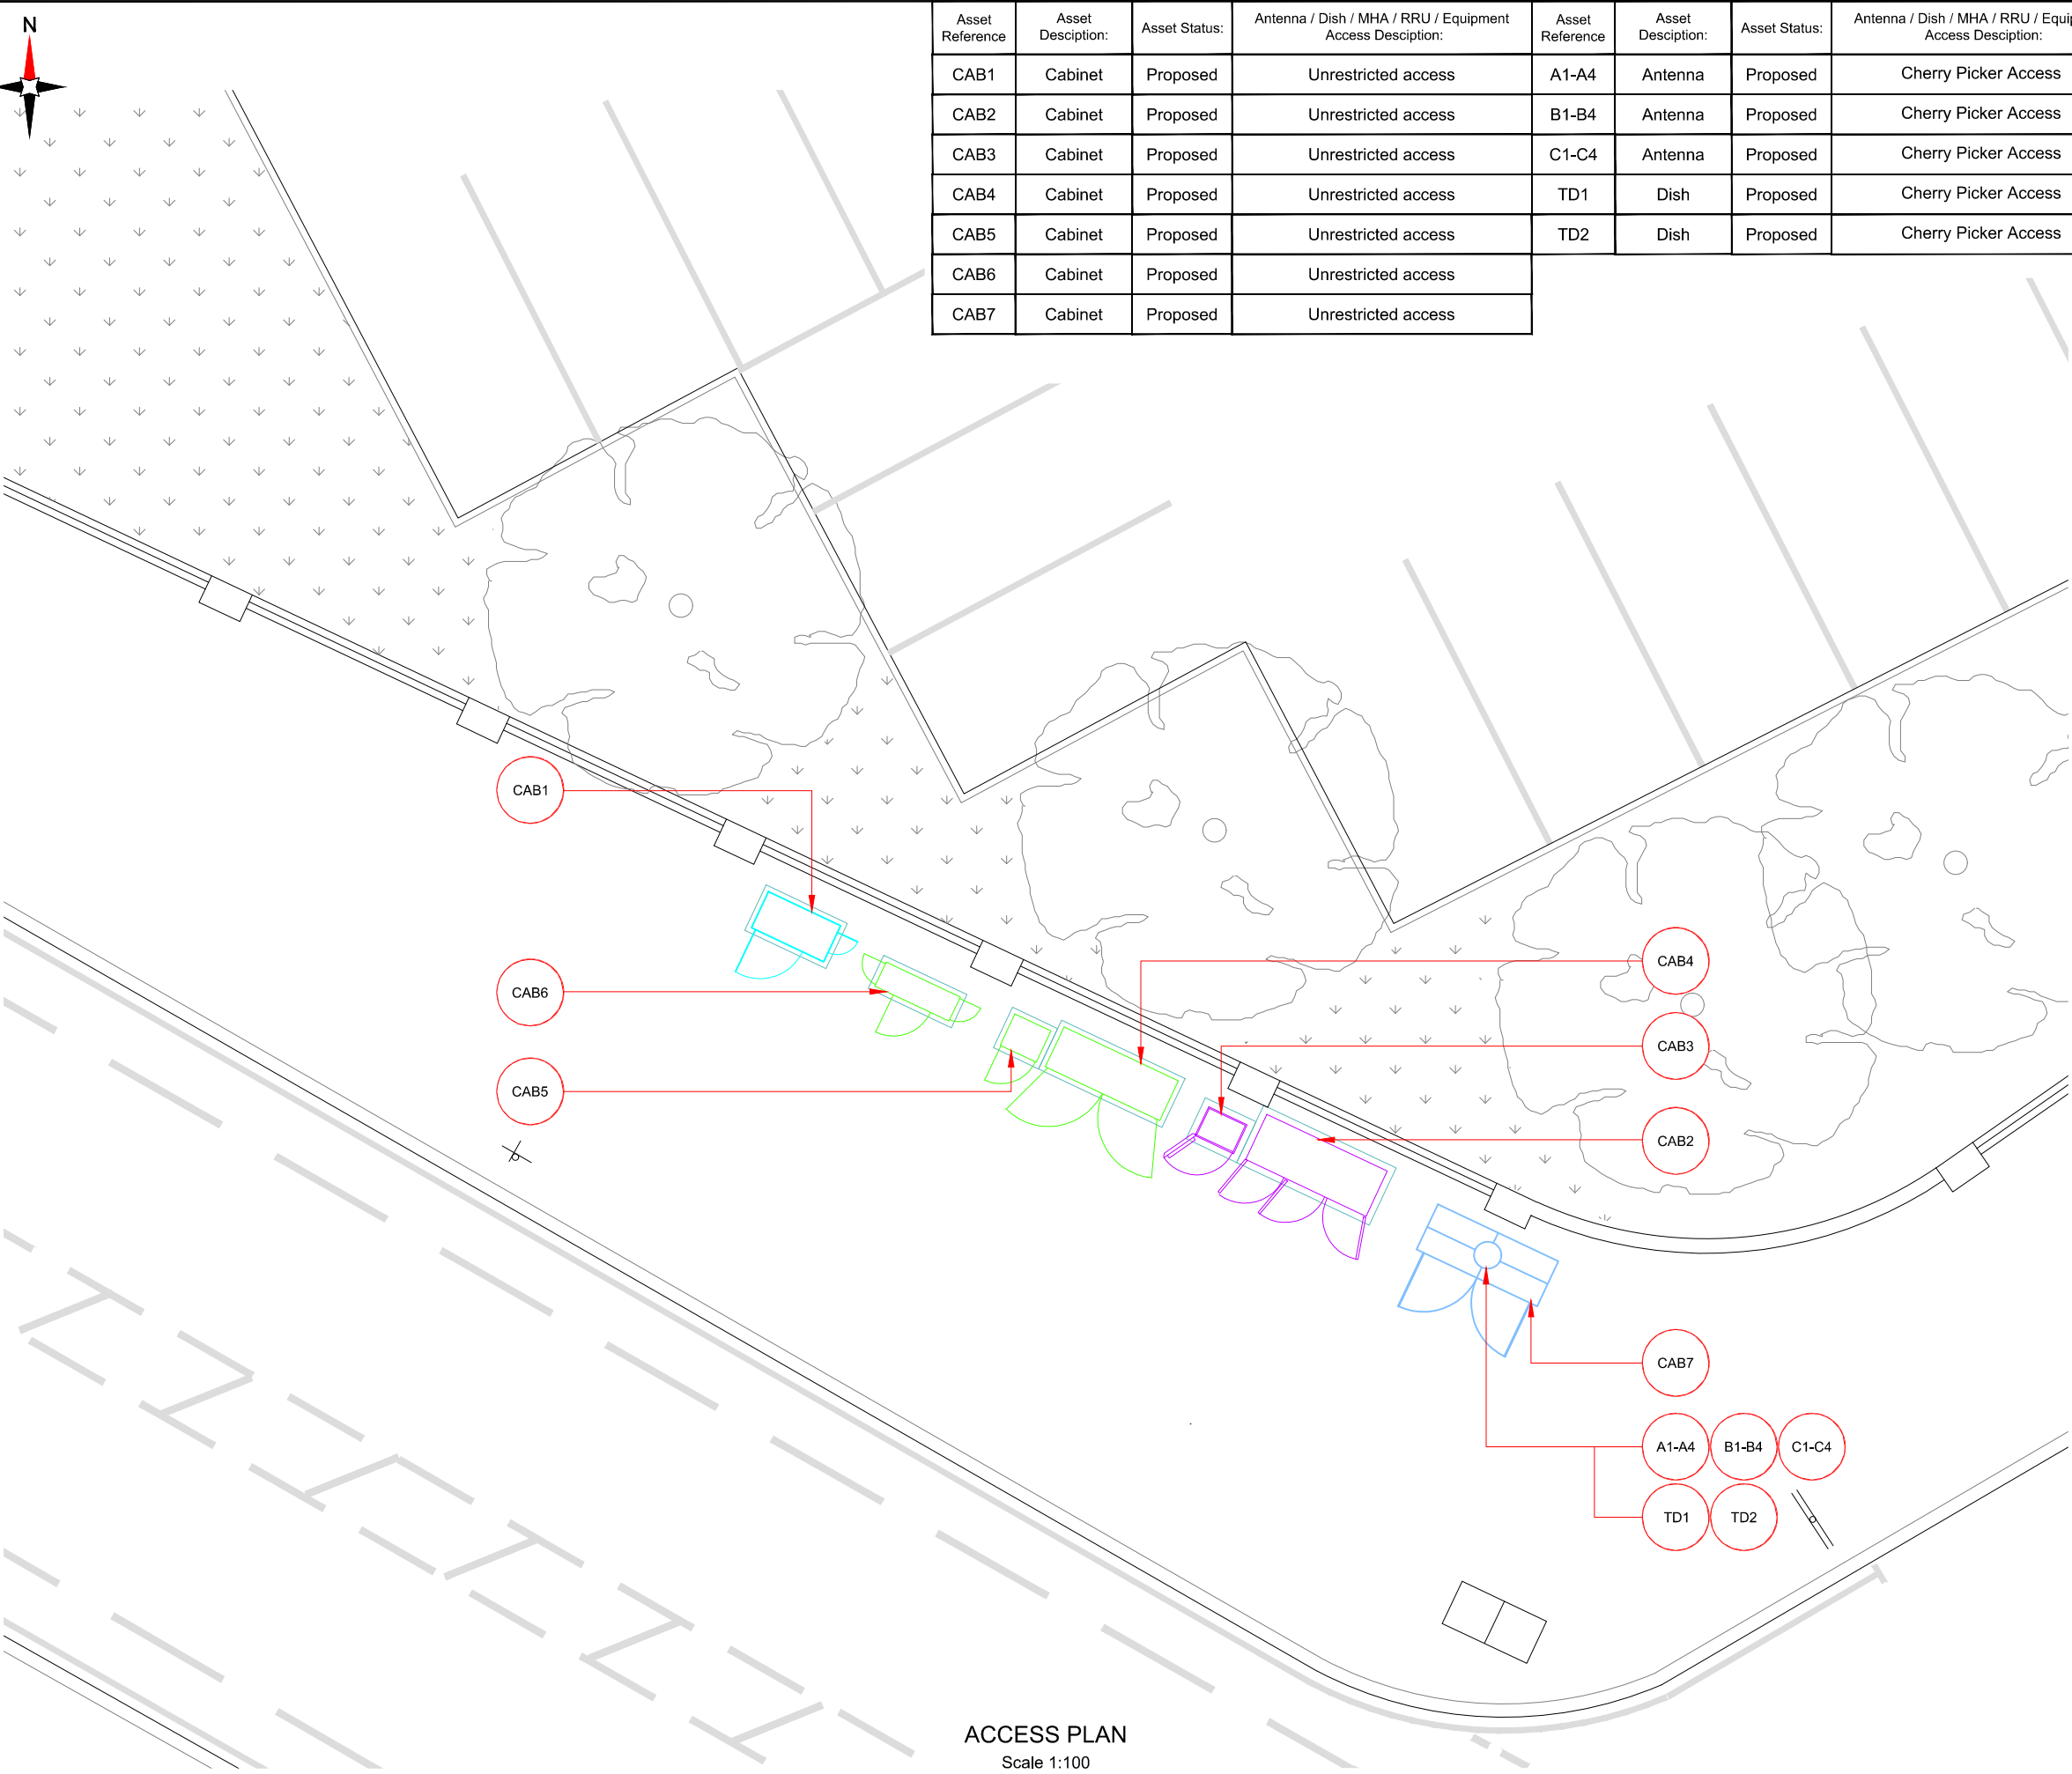

ACCESS PLAN
Scale 1:100

Master:	MBNL / EE / H3G:	Project:	Purpose of Issue:	Issue:
M001	MBNL	NTQ	Planning	A
Date:	11/06/2021	Revision / Upgrade Description:		
Drawn:	J.BOOTE	First Issue		
Checked:	J.STOCKDALE			
Approved:	J.STOCKDALE			
 Hutchison 3G UK Limited Star House, 20 Grenfell Road Mordenhead, SL6 1EH Tel: 01628 765 000 Fax: 01628 765 001 H3G Base Station Information line: 0845 6043000 Available 9am-6pm Monday to Friday		 Hatfield Business Park Hatfield Hertfordshire AL10 9BW Tel: 01707 315000 Fax: 01707 319001		
 Mobile Broadband Network Limited Sixth Floor, Thames Tower, Station Road, Reading, RG1 1LX				
Design Consultant & Principal Contractor:				
 WHP Telecoms Unit 1 Maple Park, Low Fields Avenue, Leeds LS12 6HH Tel: 01133023550 e-mail: info@whptelecoms.com				
Site Name:				
PLYMOUTH GROVE				
Site ID:				
1494015				
Address:				
PLYMOUTH GROVE, MANCHESTER, GREATER MANCHESTER, M13 0LB				
Title:				
003 ACCESS PLAN				
Project:				
NTQ				
Purpose of Issue:				
PLANNING				
EE Cell ID:	MBNL Cell ID:	3UK Cell ID:		
75911	MAN396	M0794		
Master Drawing No:				Issue:
1494015_MAN396_75911_M0794_M001				A

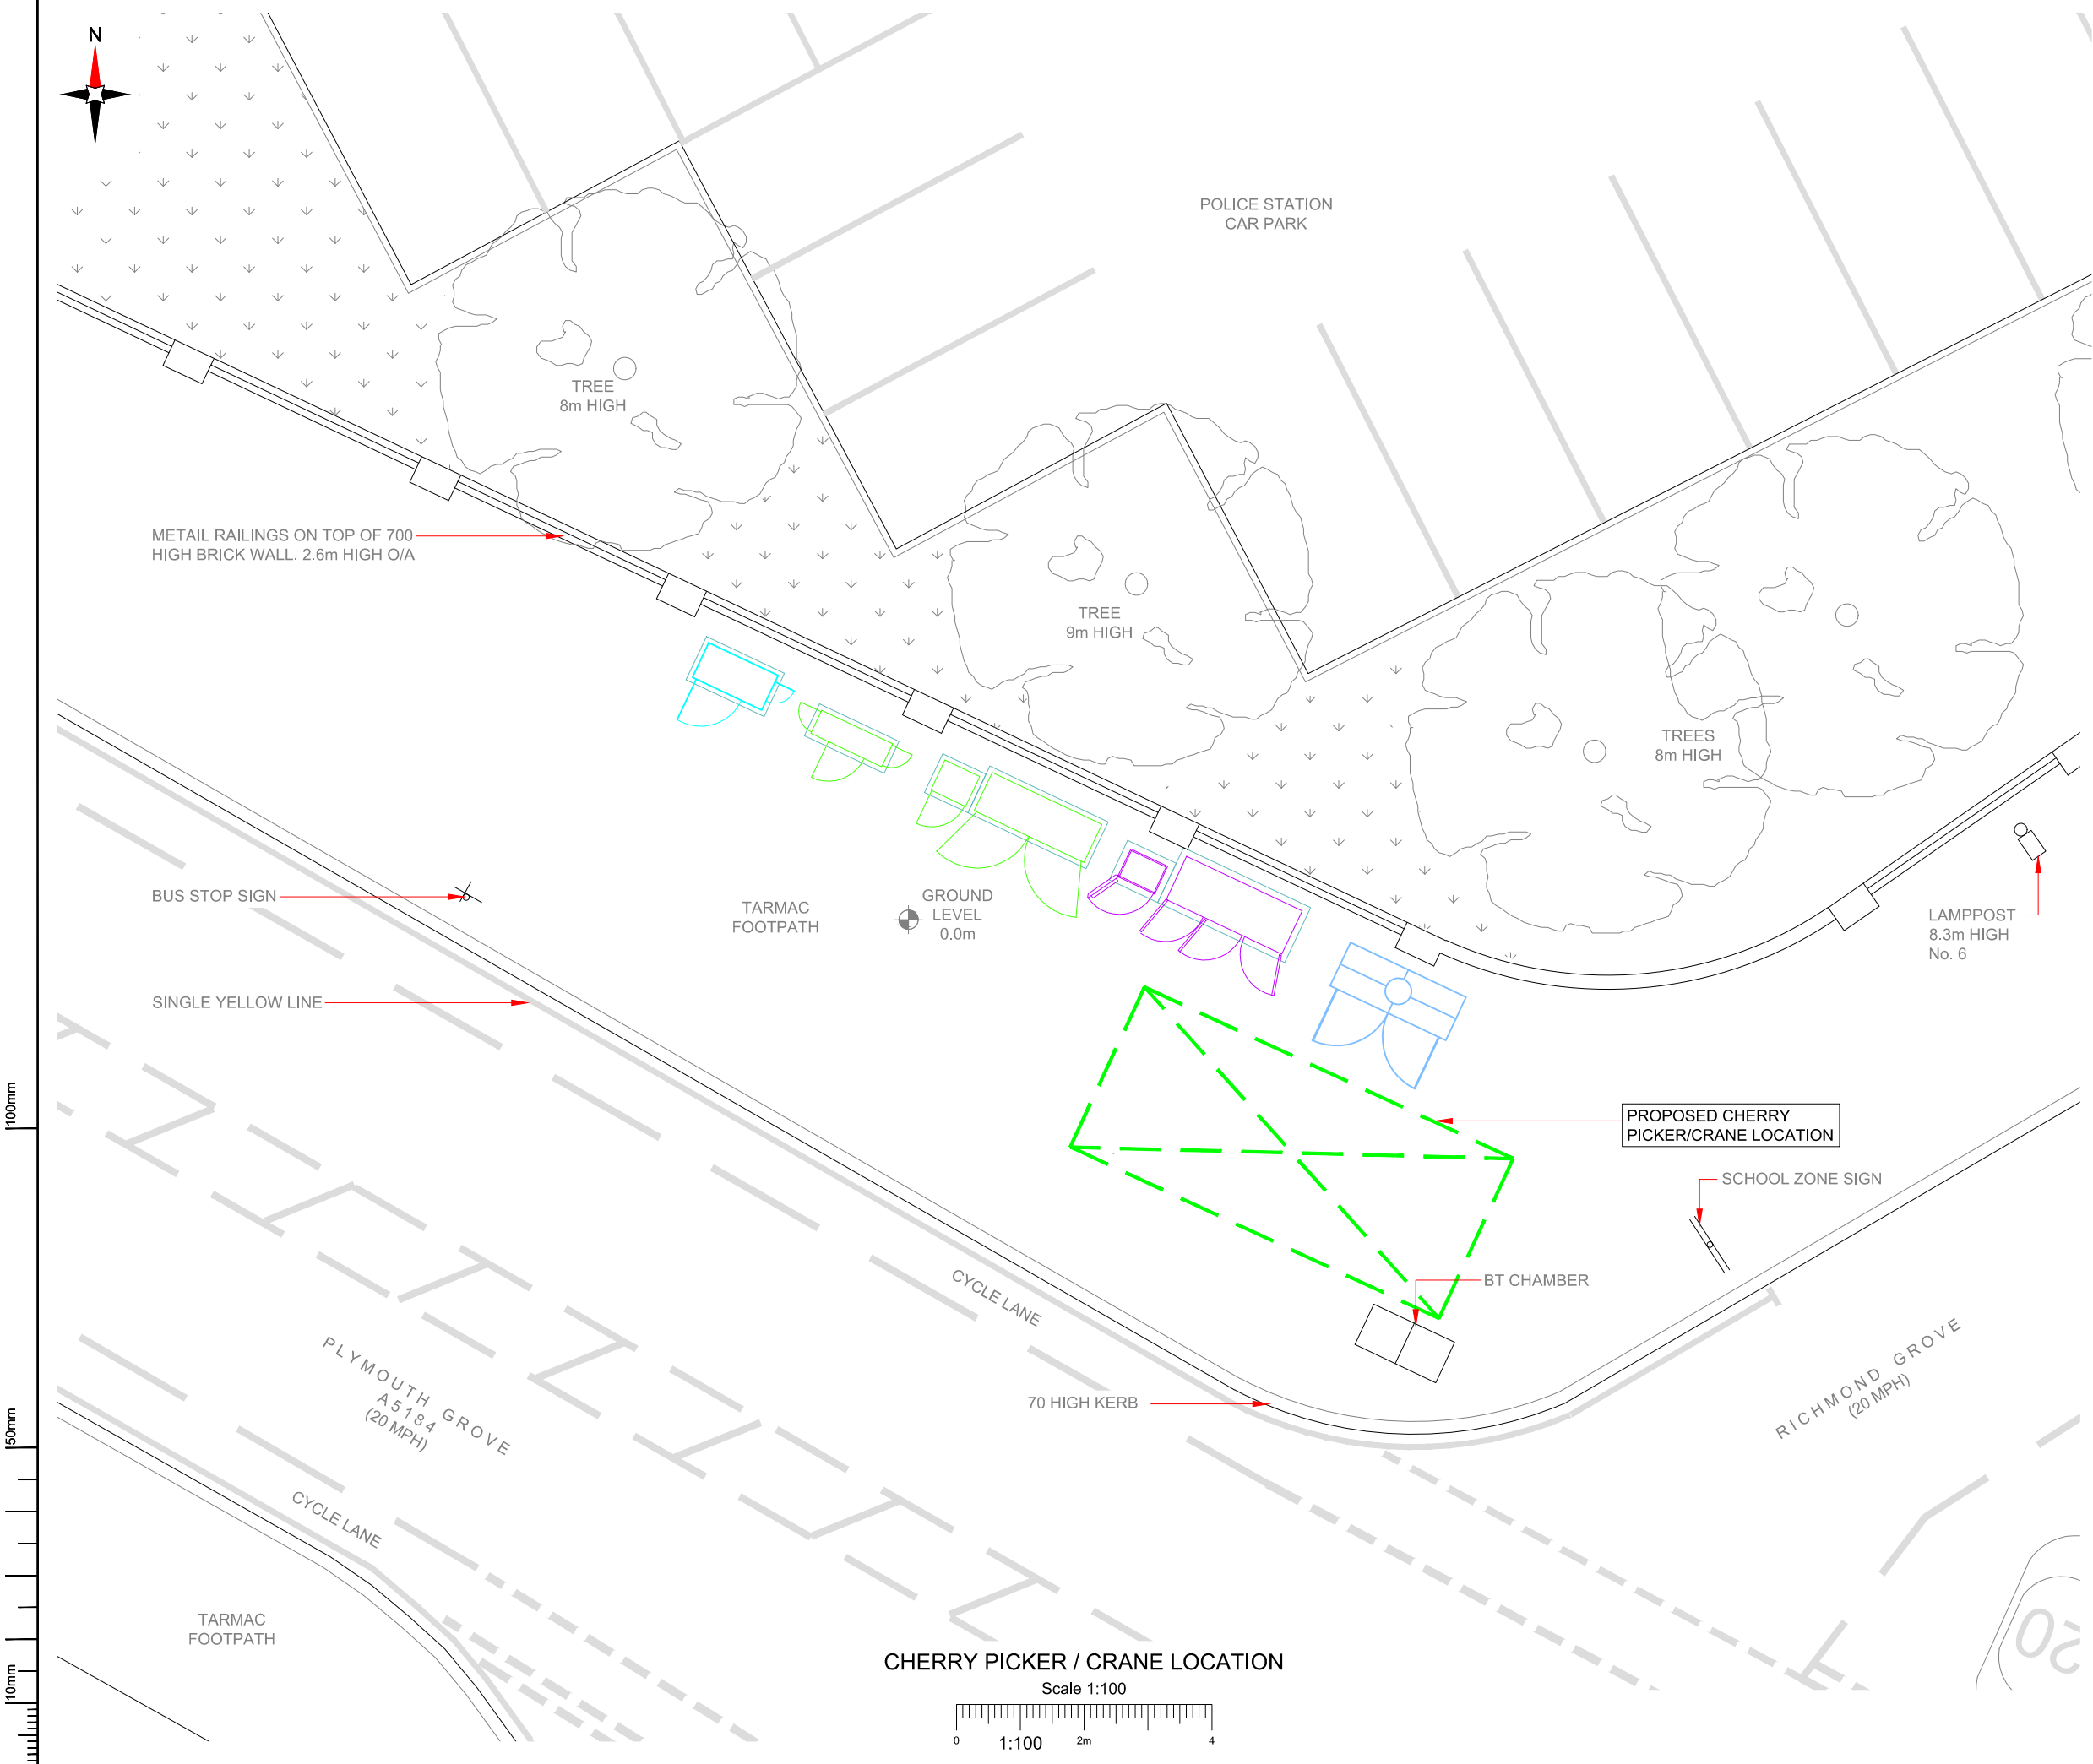

- NOTES:
- ALL DIMENSIONS IN MM UNLESS OTHERWISE NOTED.
- PROPOSED CRANE OR CHERRY PICKER LOCATION:



Master:	MBNL / EE / H3G:	Project:	Purpose of Issue:	Issue:
M001	MBNL	NTQ	Planning	A
Date:	11/06/2021	Revision / Upgrade Description:		
Drawn:	J.BOOTHE	First Issue		
Checked:	J.STOCKDALE			
Approved:	J.STOCKDALE			



Hutchison 3G UK Limited
Star House, 20 Grenfell Road
Mordenhead, SLS 1EH
Tel: 01628 765 000
Fax: 01628 765 001

H3G Base Station Information Line:
0845 6043000
Available 9am-5pm Monday to Friday



Hatfield Business Park
Hatfield
Hertfordshire
AL10 9BW
Tel: 01707 315000
Fax: 01707 319001



Mobile Broadband Network Limited
Sixth Floor, Thames Tower, Station Road, Reading, RG1 1LX

Design Consultant & Principal Contractor:



WHP Telecoms
Unit 1 Maple Park,
Low Fields Avenue, Leeds
LS12 6HH

Tel: 01133023550
e-mail: info@whptelecoms.com

Site Name:
PLYMOUTH GROVE

Site ID:
1494015

Address:
**PLYMOUTH GROVE,
MANCHESTER,
GREATER MANCHESTER,
M13 0LB**


Title:
005 CHERRY PICKER & CRANE LOCATION

Project:
NTQ

Purpose of Issue:
PLANNING

EE Cell ID:	MBNL Cell ID:	3UK Cell ID:
75911	MAN396	M0794

Master Drawing No:	Issue:
1494015_MAN396_75911_M0794_M001	A

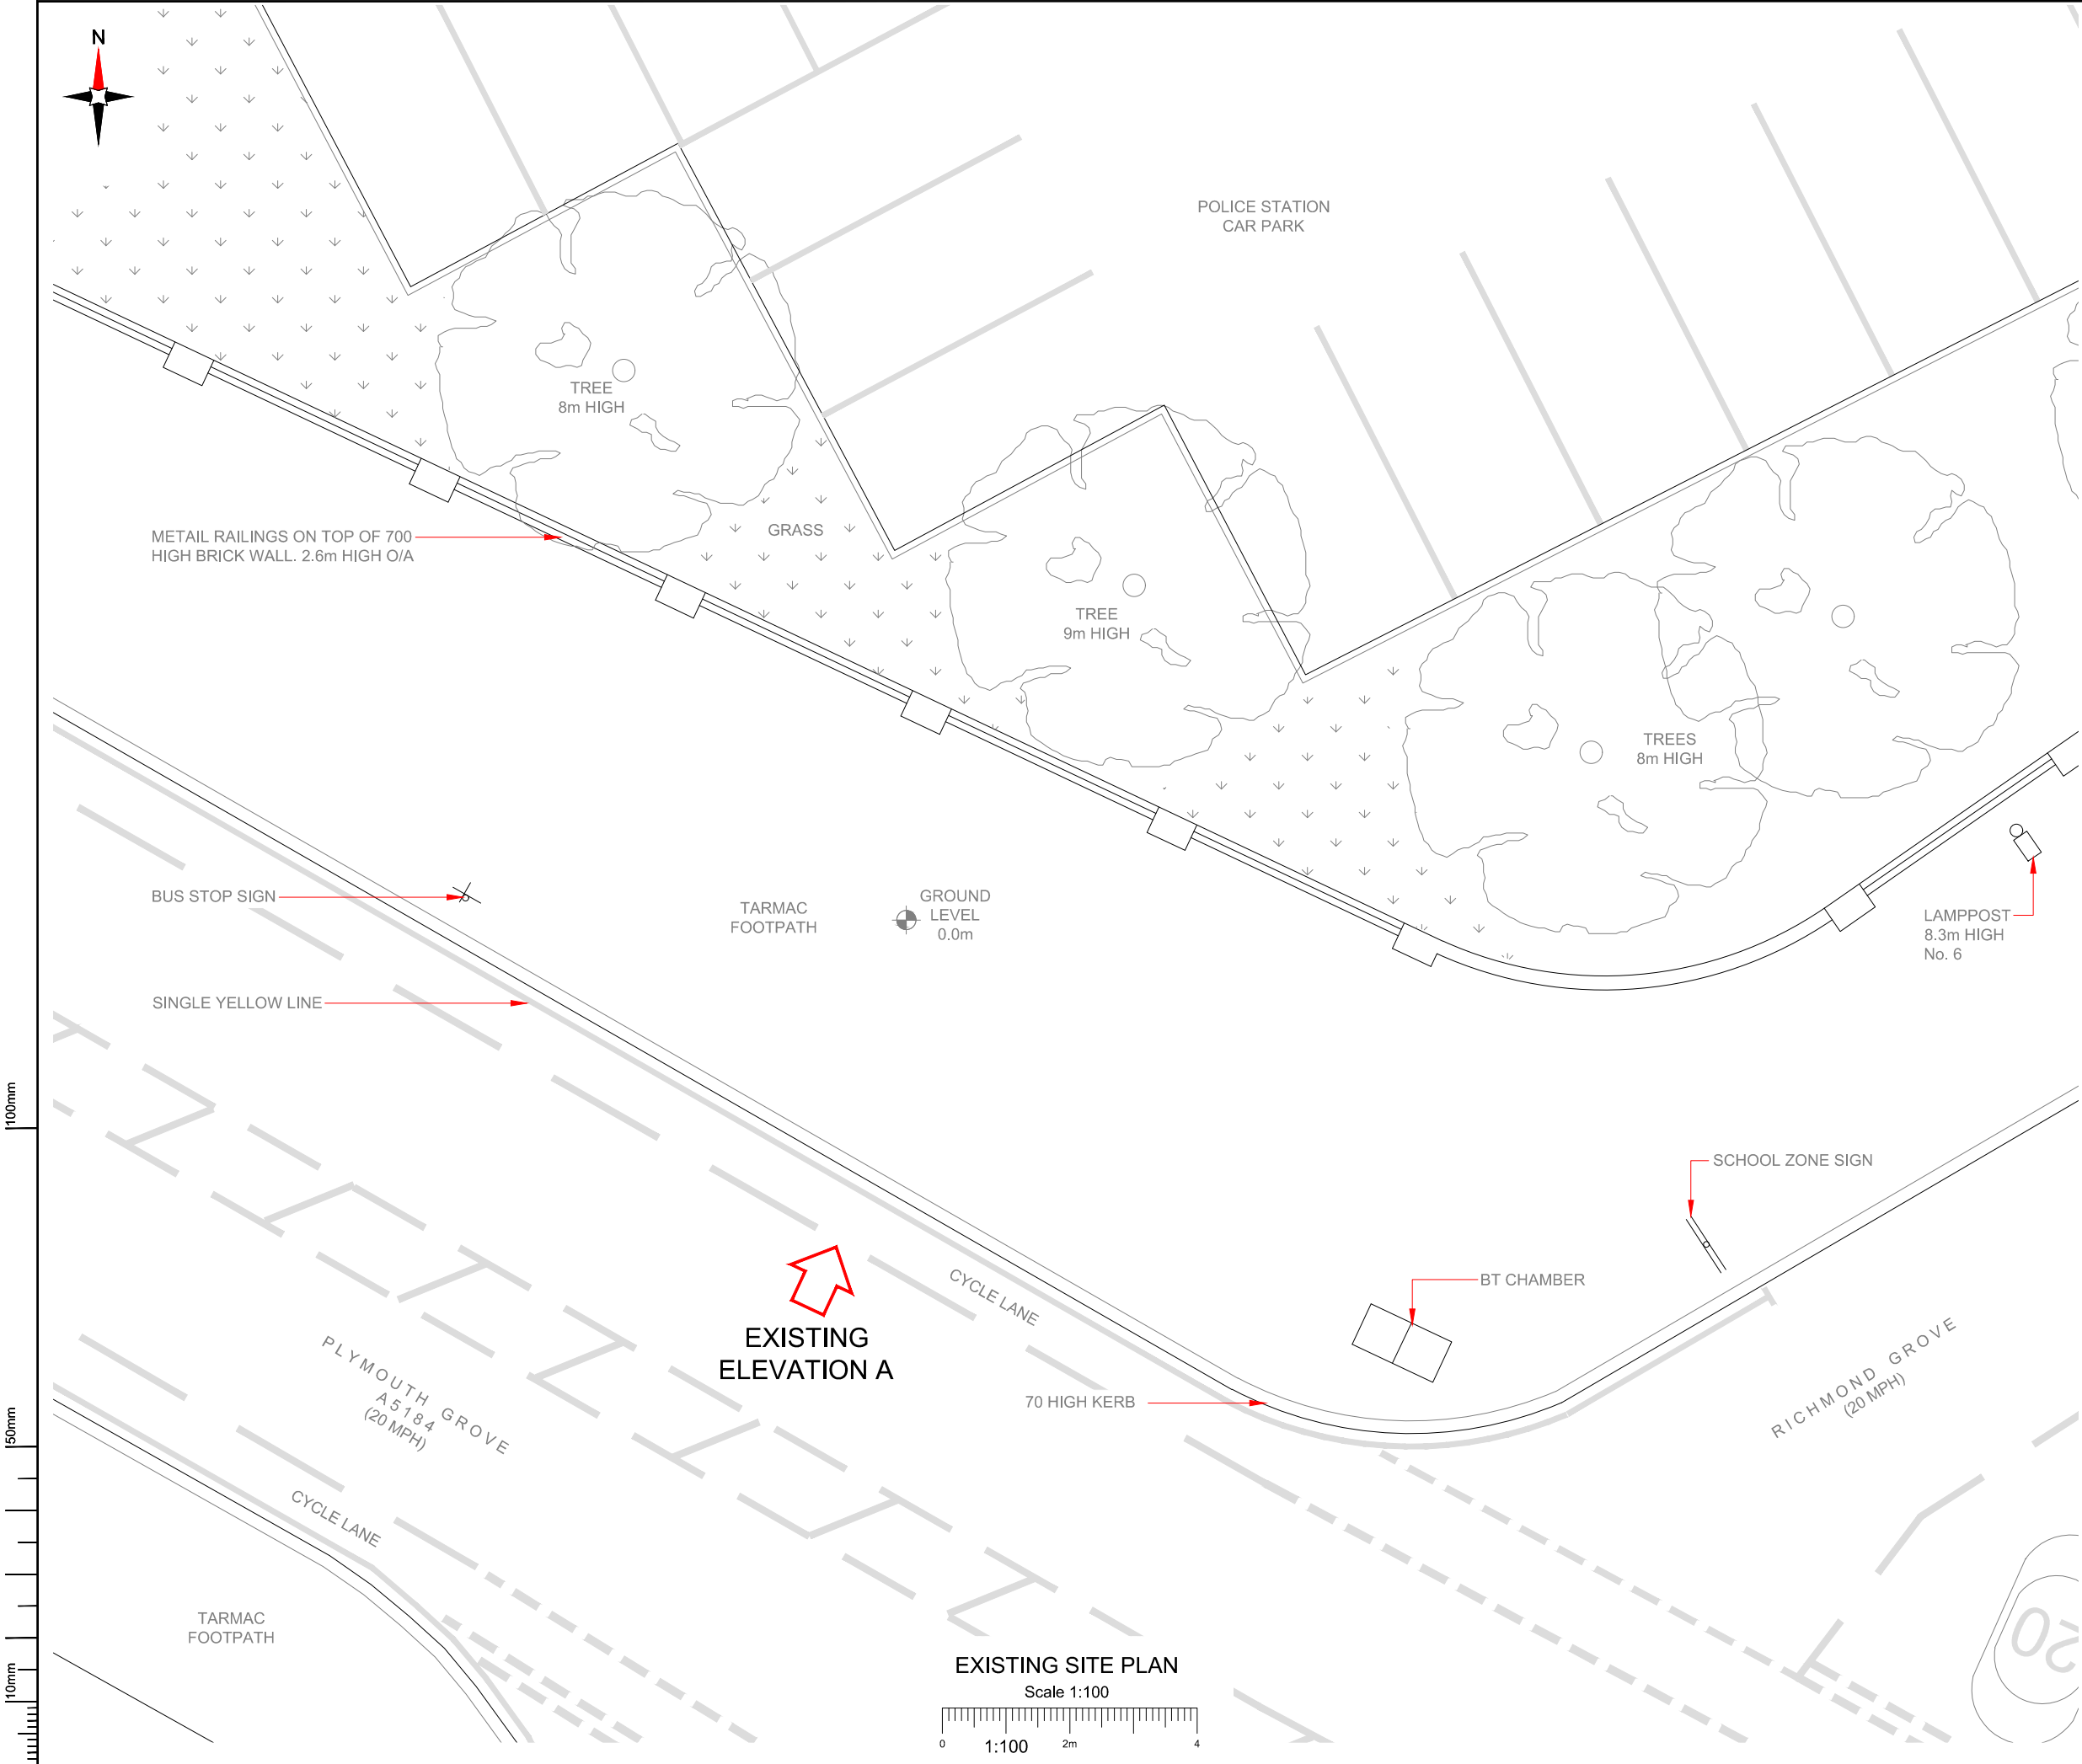

- NOTES:
- ALL DIMENSIONS IN MM UNLESS OTHERWISE NOTED.

Master:	MBNL / EE / H3G:	Project:	Purpose of Issue:	Issue:
M001	MBNL	NTQ	Planning	A
Date:	11/06/2021	Revision / Upgrade Description:		
Drawn:	J.BOOTE	First Issue		
Checked:	J.STOCKDALE			
Approved:	J.STOCKDALE			



Hutchison 3G UK Limited
Star House, 20 Grenfell Road
Mordenhead, SL6 1EH
Tel: 01628 765 000
Fax: 01628 765 001



Hatfield Business Park
Hatfield
Hertfordshire
AL10 9BW
Tel: 01707 315000
Fax: 01707 319001



Mobile Broadband Network Limited
Sixth Floor, Thames Tower, Station Road, Reading, RG1 1LX

Design Consultant & Principal Contractor:



WHP Telecoms
Unit 1 Maple Park,
Low Fields Avenue, Leeds
LS12 6HH

Tel: 01133023550
e-mail: info@whptelecoms.com

Site Name: PLYMOUTH GROVE

Site ID: 1494015

Address: PLYMOUTH GROVE,
MANCHESTER,
GREATER MANCHESTER,
M13 0LB

Title: 100 EXISTING SITE PLAN

Project: NTQ

Purpose of Issue: PLANNING



EE Cell ID:	MBNL Cell ID:	3UK Cell ID:
75911	MAN396	M0794

Master Drawing No:	Issue:
1494015_MAN396_75911_M0794_M001	A

100mm

150mm

10mm

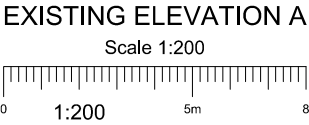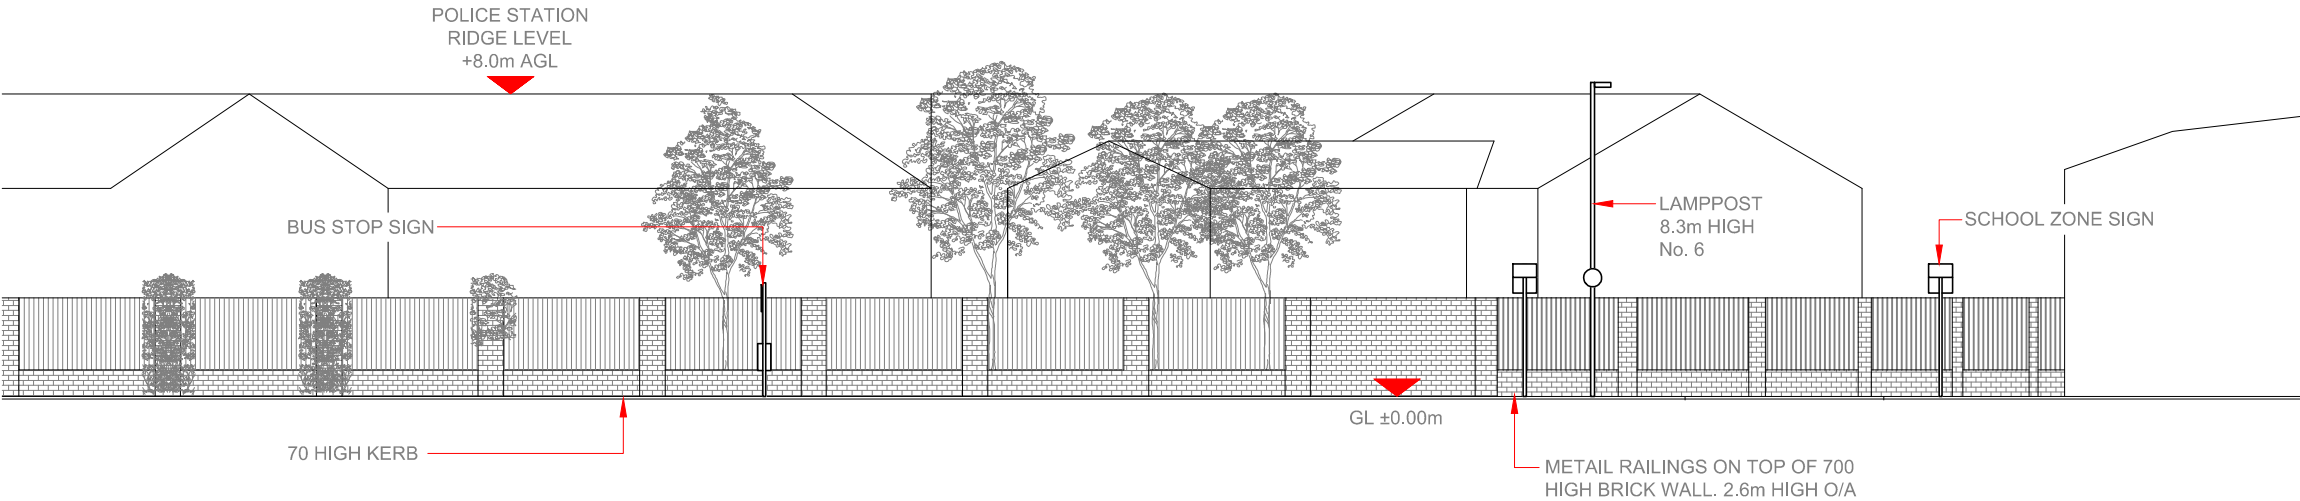

- NOTES:
1. ALL DIMENSIONS IN MM UNLESS OTHERWISE NOTED.

Master:	MBNL / EE / H3G:	Project:	Purpose of Issue:	Issue:
M001	MBNL	NTQ	Planning	A
Date:	11/06/2021	Revision / Upgrade Description:		
Drawn:	J.BOOTE	First Issue		
Checked:	J.STOCKDALE			
Approved:	J.STOCKDALE			



Hutchison 3G UK Limited
Star House, 20 Grenfell Road
Mordenhead, SLS 1EH
Tel: 01628 765 000
Fax: 01628 765 001

H3G Base Station Information line:
0845 6043000
Available 9am-6pm Monday to Friday



Hatfield Business Park
Hatfield
Hertfordshire
AL10 9BW

Tel: 01707 315000
Fax: 01707 319001



Mobile Broadband Network Limited
Sixth Floor, Thames Tower, Station Road, Reading, RG1 1LX

Design Consultant & Principal Contractor:



WHP Telecoms
Unit 1 Maple Park,
Low Fields Avenue, Leeds
LS12 6HH

Tel: 01133023550
e-mail: info@whptelecoms.com

Site Name:

PLYMOUTH GROVE

Site ID:

1494015

Address:

PLYMOUTH GROVE,
MANCHESTER,
GREATER MANCHESTER,
M13 0LB

Title:

150 EXISTING ELEVATION A


Project:

NTQ

Purpose of Issue:

PLANNING

EE Cell ID:	MBNL Cell ID:	3UK Cell ID:
75911	MAN396	M0794
Master Drawing No:		
1494015_MAN396_75911_M0794_M001		
Issue:		
A		

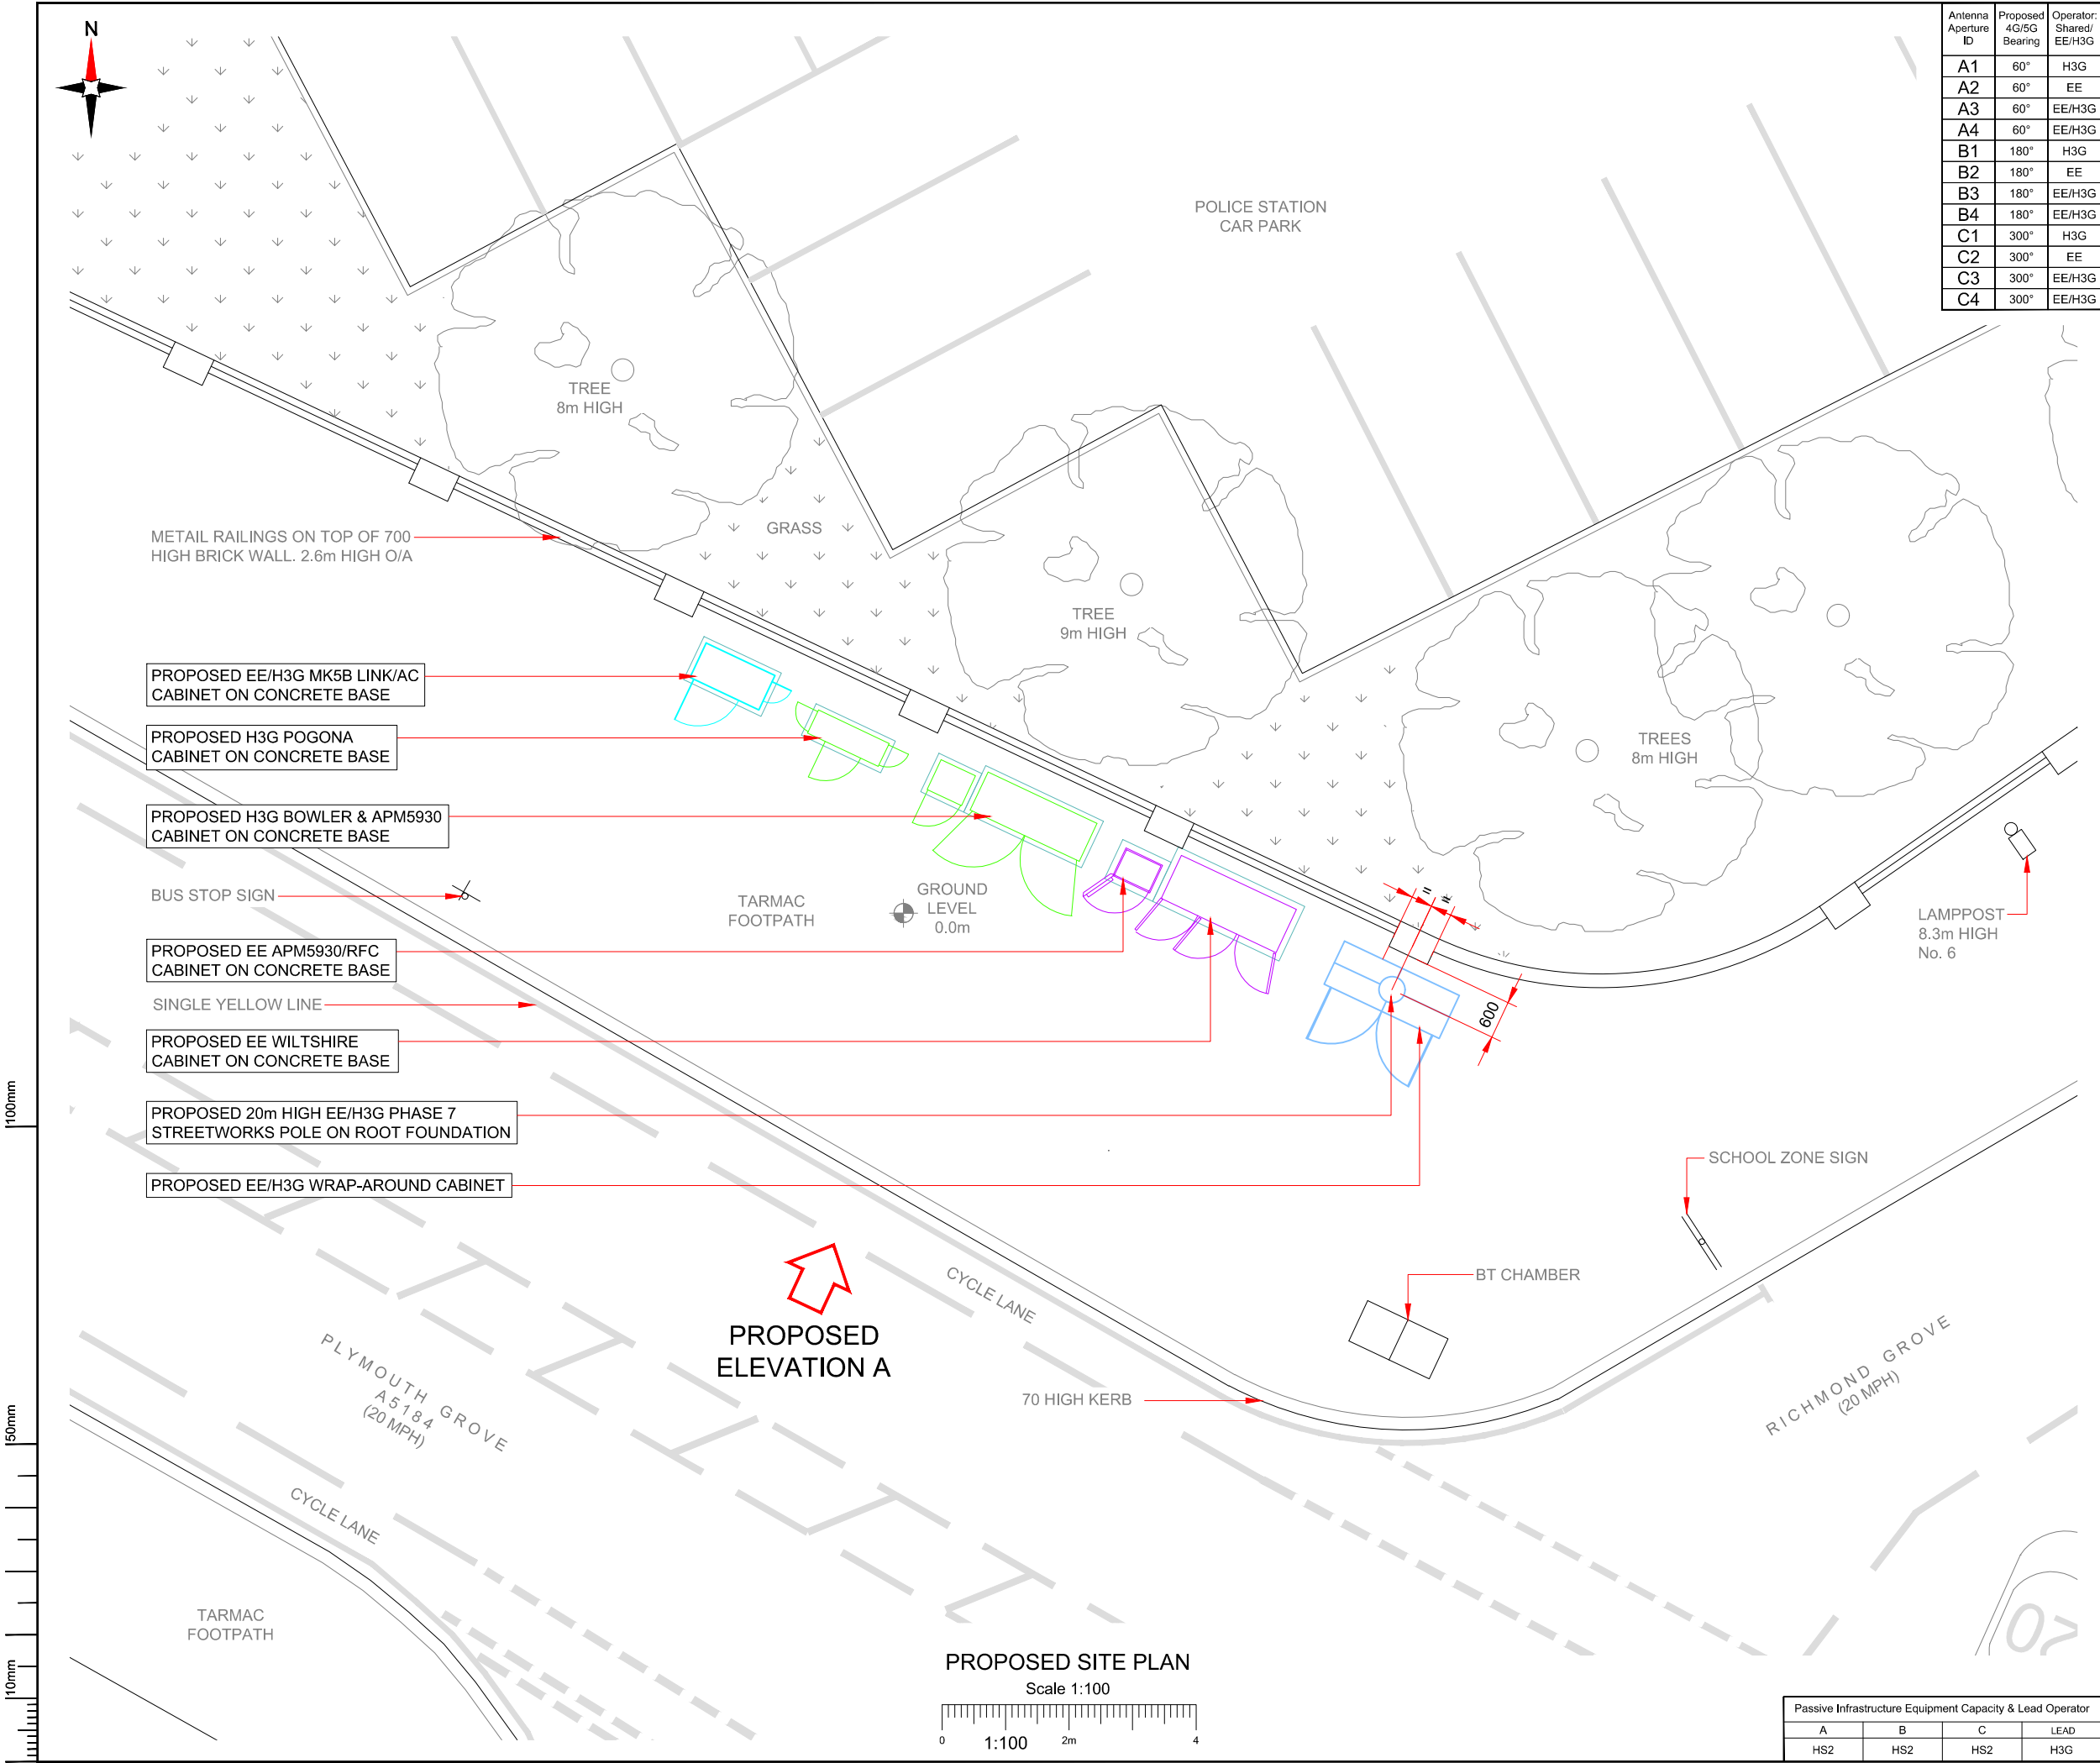

Antenna Aperture ID	Proposed 4G/5G Bearing	Operator: Shared/ EE/H3G
A1	60°	H3G
A2	60°	EE
A3	60°	EE/H3G
A4	60°	EE/H3G
B1	180°	H3G
B2	180°	EE
B3	180°	EE/H3G
B4	180°	EE/H3G
C1	300°	H3G
C2	300°	EE
C3	300°	EE/H3G
C4	300°	EE/H3G

NOTES:

1. ALL DIMENSIONS IN MM UNLESS OTHERWISE NOTED.

Master: M001	MBNL / EE / H3G: MBNL	Project: NTQ	Purpose of Issue: Planning	Issue: A
Date: 11/06/2021	Revision / Upgrade Description: First Issue			
Drawn: J.BOOTE				
Checked: J.STOCKDALE				
Approved: J.STOCKDALE				

Hutchison 3G UK Limited
Star House, 20 Grenfell Road
Maidenhead, SL6 1EH
Tel: 01628 765 500
Fax: 01628 765 501

H3G Base Station Information line:
0845 6043000
Available 9am-5pm Monday to Friday

Hatfield Business Park
Hatfield
Hertfordshire
AL10 9BW

Tel: 01707 315000
Fax: 01707 319001

Mobile Broadband Network Limited
Sixth Floor, Thames Tower, Station Road, Reading, RG1 1LX

Design Consultant & Principal Contractor:

WHP Telecoms
Unit 1 Maple Park,
Low Fields Avenue, Leeds
LS12 6HH

Tel: 01133023550
e-mail: info@whptelecoms.com

Site Name: PLYMOUTH GROVE

Site ID: 1494015

Address: PLYMOUTH GROVE,
MANCHESTER,
GREATER MANCHESTER,
M13 0LB

Title: 215 PROPOSED SITE PLAN

Project: NTQ

Purpose of Issue: PLANNING

EE Cell ID: 75911	MBNL Cell ID: MAN396	3UK Cell ID: M0794
-------------------	----------------------	--------------------

Master Drawing No: 1494015_MAN396_75911_M0794_M001

Issue: A

Passive Infrastructure Equipment Capacity & Lead Operator			
A	B	C	LEAD
HS2	HS2	HS2	H3G

100mm


50mm

10mm

Passive Infrastructure Equipment Capacity & Lead Operator			
A	B	C	LEAD
HS2	HS2	HS2	H3G

PROPOSED SITE ELEVATION

Scale 1:200

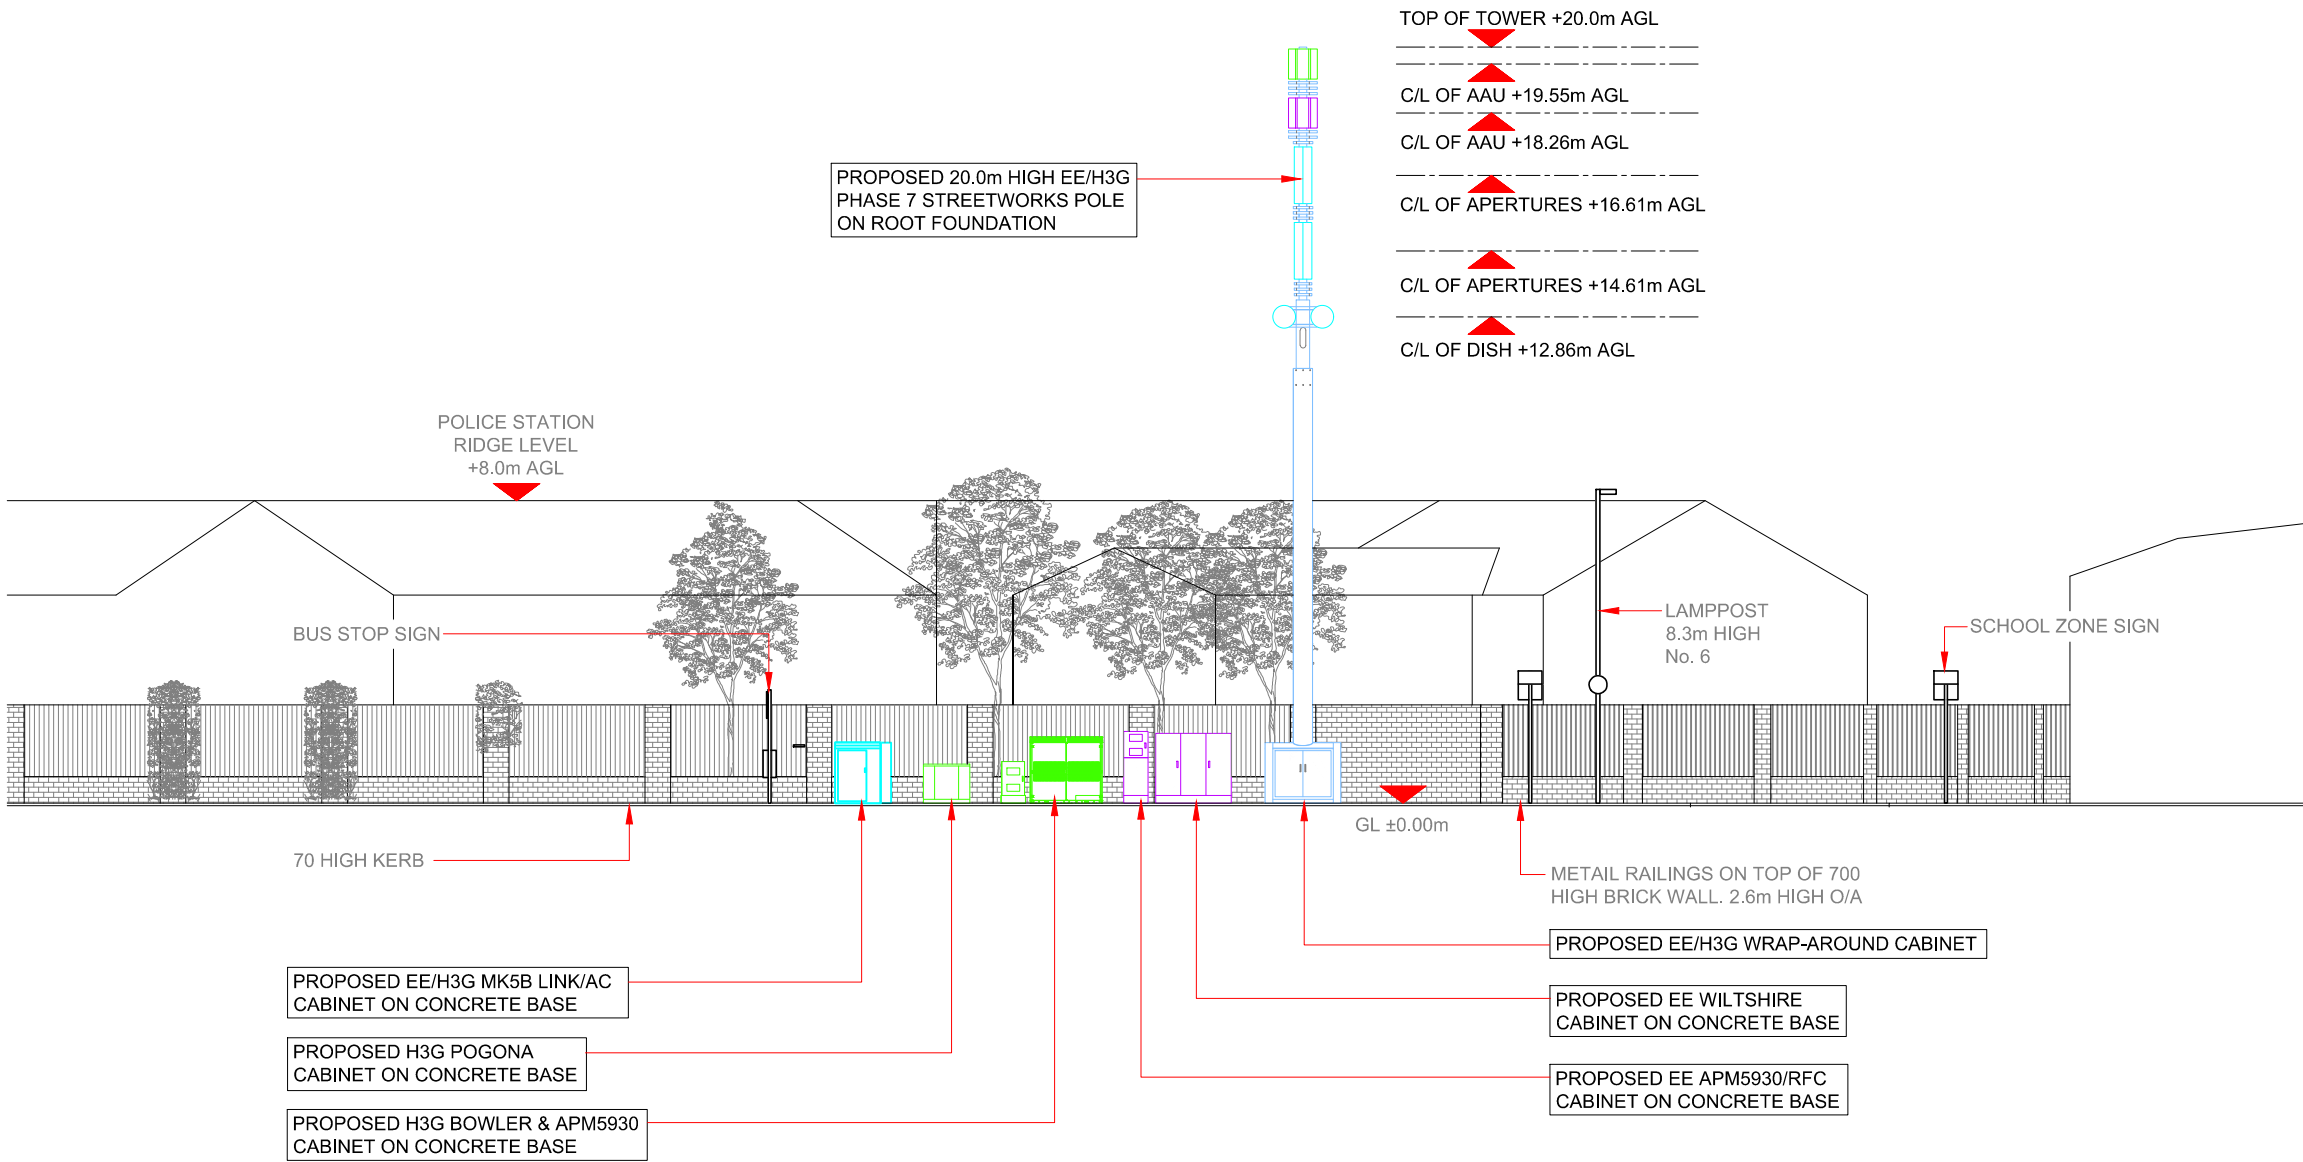

Antenna Aperture ID	Proposed 4G/5G Bearing	Operator: Shared/ EE/H3G
A1	60°	H3G
A2	60°	EE
A3	60°	EE/H3G
A4	60°	EE/H3G
B1	180°	H3G
B2	180°	EE
B3	180°	EE/H3G
B4	180°	EE/H3G
C1	300°	H3G
C2	300°	EE
C3	300°	EE/H3G
C4	300°	EE/H3G

NOTES:

1. ALL DIMENSIONS IN MM UNLESS OTHERWISE NOTED.

Master:	MBNL / EE / H3G:	Project:	Purpose of Issue:	Issue:
M001	MBNL	NTQ	Planning	A
Date:	11/06/2021	Revision / Upgrade Description:		
Drawn:	J.BOOTE	First Issue		
Checked:	J.STOCKDALE			
Approved:	J.STOCKDALE			



Hutchison 3G UK Limited
Star House, 20 Grenfell Road
Madderhead, SL8 1EH
Tel: 01628 765 000
Fax: 01628 765 001

H3G Base Station Information line:
0845 6043000
Available 9am-6pm Monday to Friday



Hatfield Business Park
Hatfield
Hertfordshire
AL10 9BW

Tel: 01707 315000
Fax: 01707 319001



Mobile Broadband Network Limited
Sixth Floor, Thames Tower, Station Road, Reading, RG1 1LX

Design Consultant & Principal Contractor:



WHP Telecoms
Unit 1 Maple Park,
Low Fields Avenue, Leeds
LS12 6HH

Tel: 01133023550
e-mail: info@whptelecoms.com

Site Name:	PLYMOUTH GROVE		
Site ID:	1494015		
Address:	PLYMOUTH GROVE, MANCHESTER, GREATER MANCHESTER, M13 0LB		
Title:	265 PROPOSED SITE ELEVATION		
Project:	NTQ		
Purpose of Issue:	PLANNING		
EE Cell ID:	MBNL Cell ID:	3UK Cell ID:	
75911	MAN396	M0794	
Master Drawing No:			Issue:
1494015_MAN396_75911_M0794_M001			A