



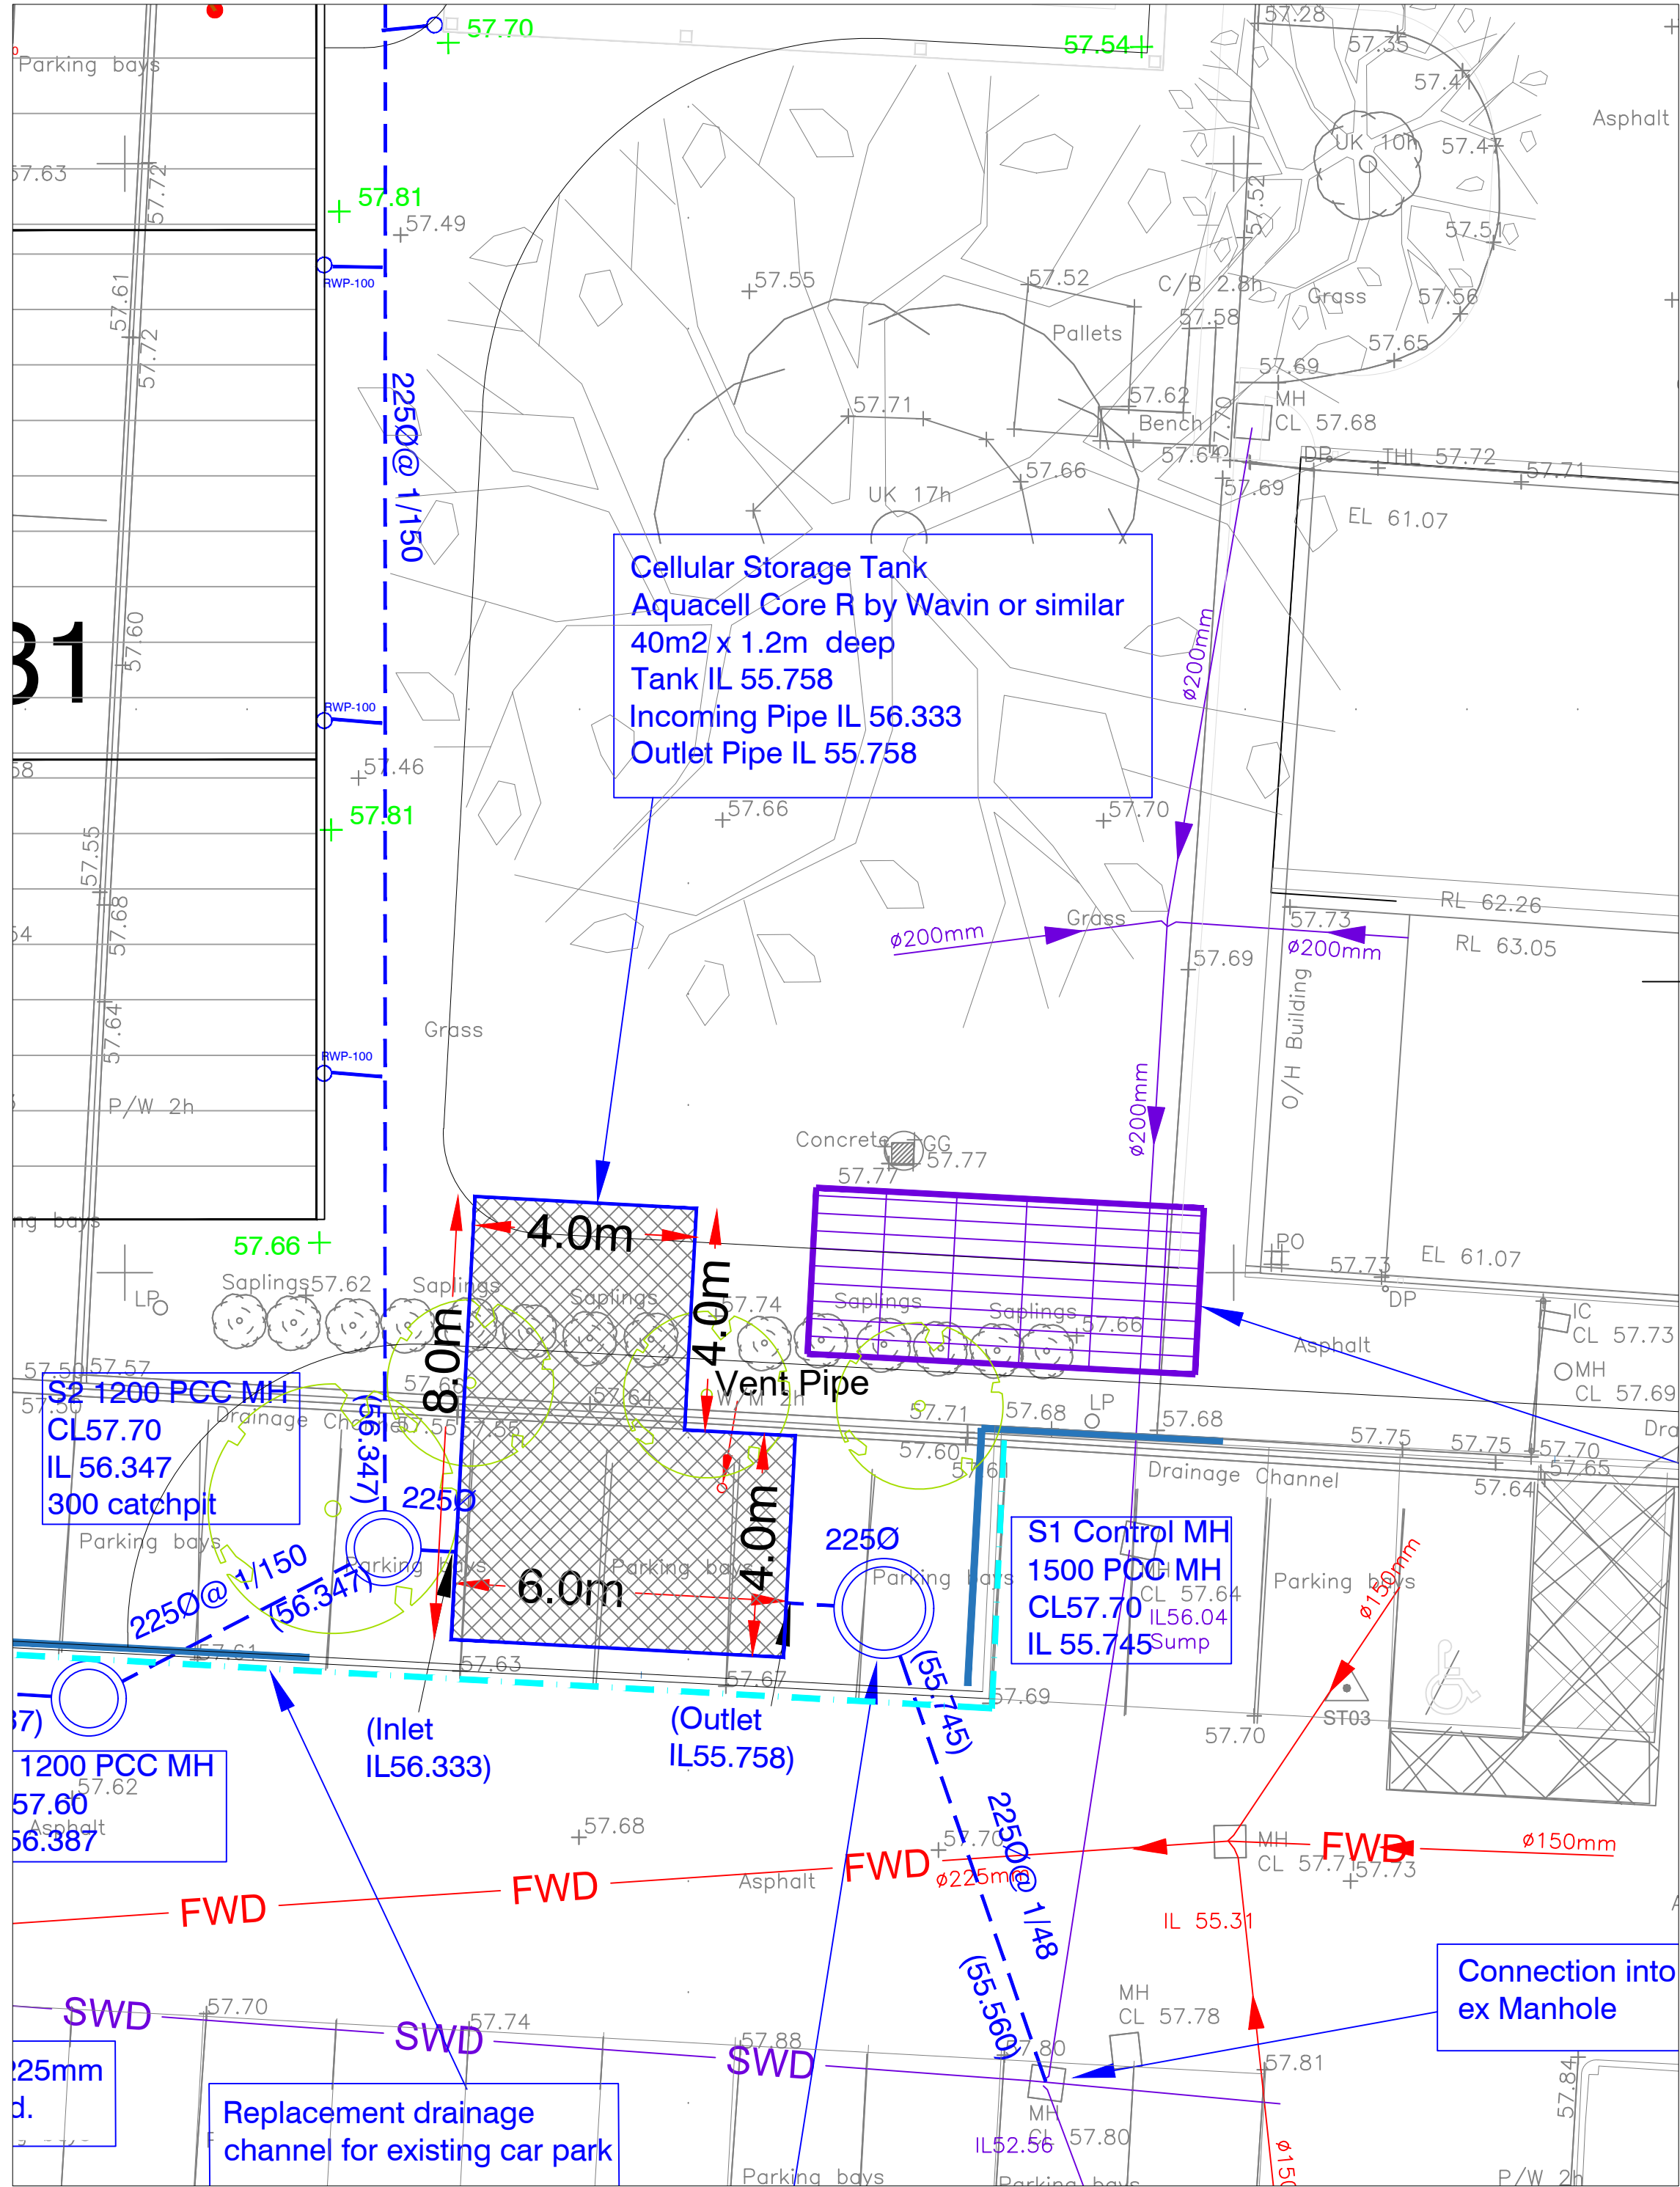

Attenuation Tank Layout
Scale 1:100

NOTES

- All dimensions are in millimetres unless otherwise shown
- All private drainage works are to comply fully with part H of the Building Regulations.
- All existing invert levels to be checked by the contractor at the start of works and any other discrepancies notified to the Engineer. All levels are based on topographical survey information provided by others.
- All materials to bear the relevant B.S. Kitemark and comply fully with the specifications. All concrete & concrete products must use Sulphate resistant cement (unless the site investigation report proves that sulphate attack from soils and groundwater will not occur to withstand a class 3 condition).
- All opening notices etc. as required under highways acts etc. are to be obtained prior to commencement of works. All works are to be inspected by L.A., NHBC or the Network Operator as applicable.
- Where UPVC pipes are used in adoptable drainage they shall be handled and laid in accordance with the specification and guidance issued by the High Performance Pipe Association. A Class S Bed and surround must be used for such pipes.
- Granular material all in accordance with Sewer Sector Guidance
- Modular Units to be supplied by
Wavin Limited
Hazlehead
Crow Edge
Sheffield
S36 4HG
www.wavin.co.uk
or similar approved
Units shall be installed in accordance with the Manufacturers instructions.
- See drainage layout for size of tank and cover/invert levels

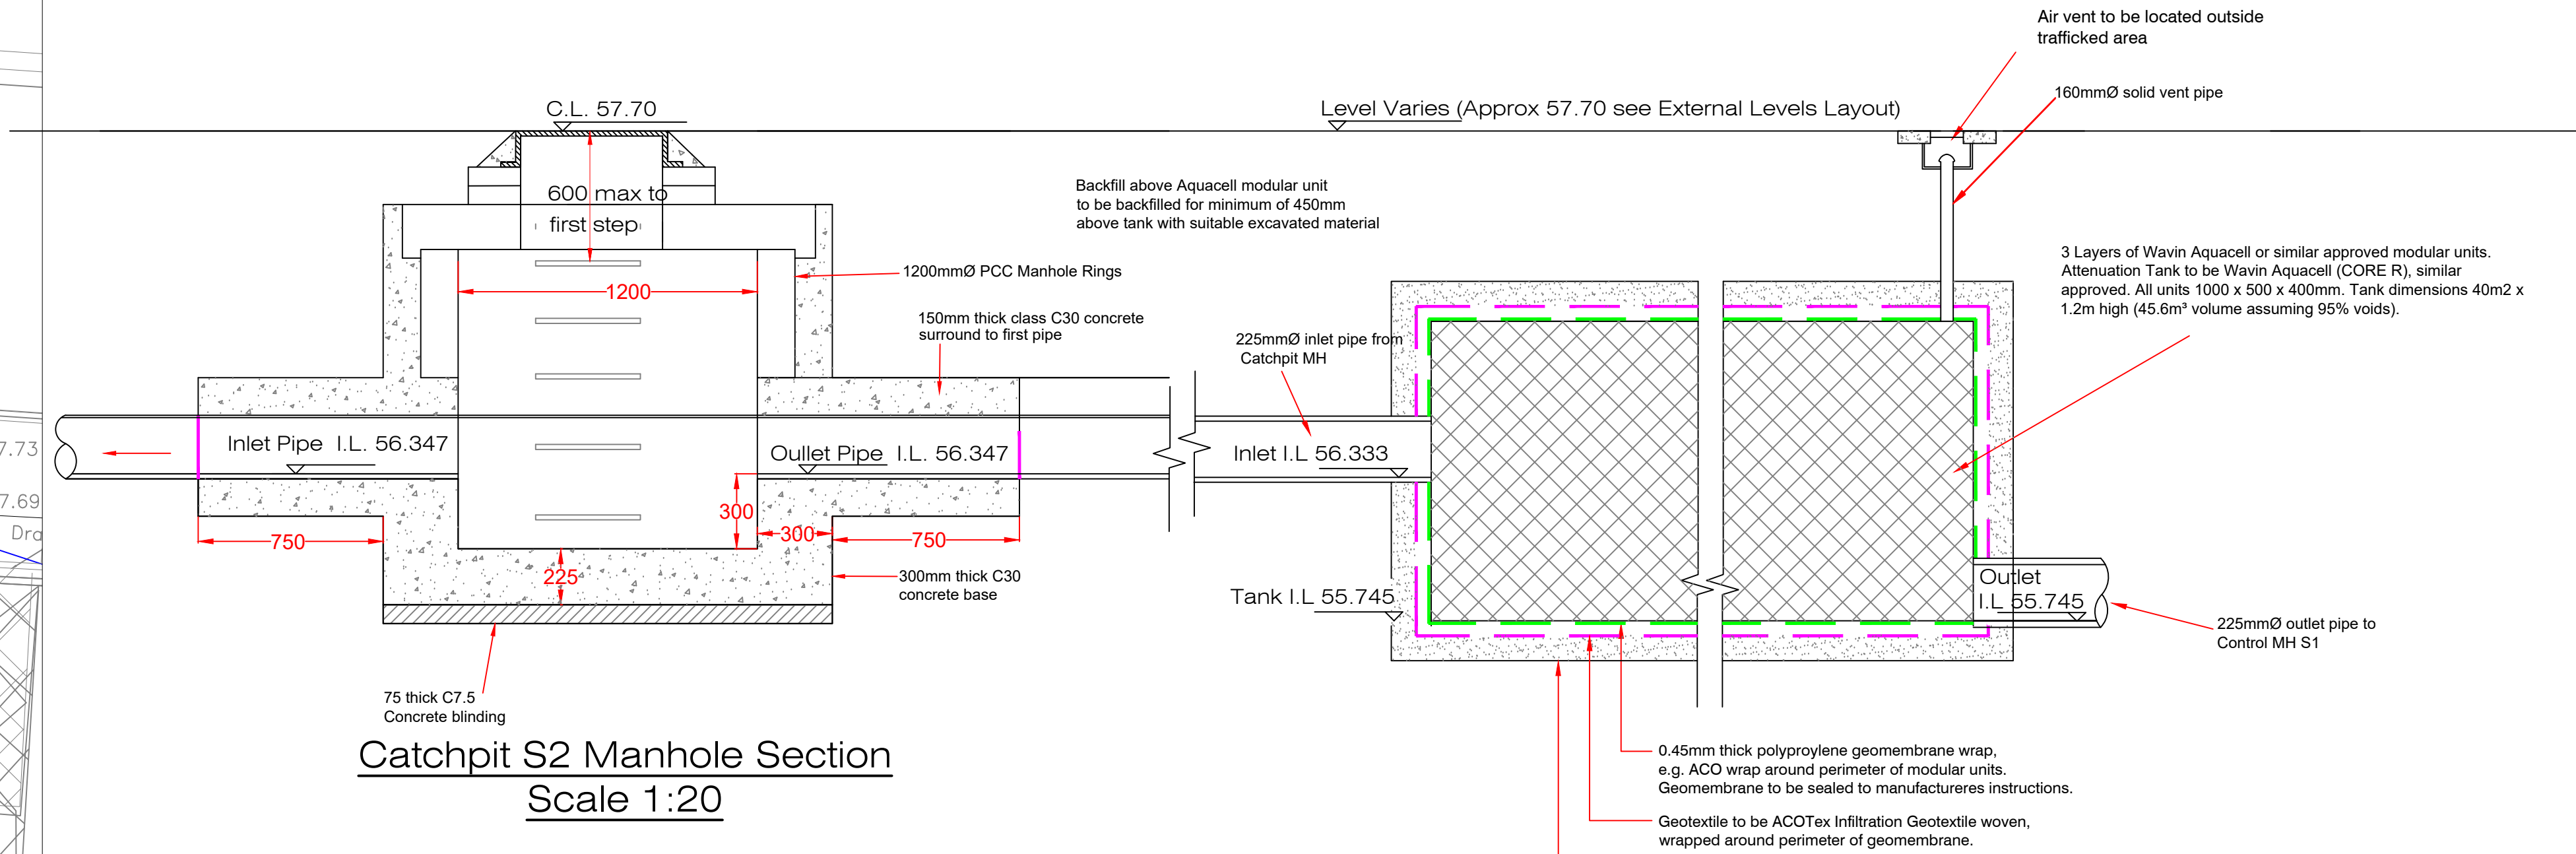

B	09/05/22	SAP	Tank dimensions amended to suit revised car park design
A	21/04/22	SAP	Tank dimensions amended
Rev	Date	Initials	Details
Drawing Revisions			
North Point		Project: Manchester Enterprise Academy Hub 2	
Quality Ass.		Client: Red Tree Building Contractors Ltd	
UKAS 005 Quality Assurance ISO 9001:2008 SGS Certificate GB02/54539		Title: Cellular Attenuation Tank Details	
Original Size	Copyright Acknowledgement	Drawn	Checked By
A1	Ordnance Survey/© Crown Copyright. All rights reserved. Licence No. AL100017966.	SAP	SP
	Date	Scale	As Shown
	April 22		
Drawing No.		Revision	
30544/3		B	

IronsideFarrar

EnvironmentalConsultants

Planners
CivilEngineers
LandscapeArchitects
GraphicDesign

3 Worsley Court
Tel. 0161 703 8801 Fax. 0161 703 8279
manchester@ironsidefarrar.com

EDINBURGH

BELLSHILL