



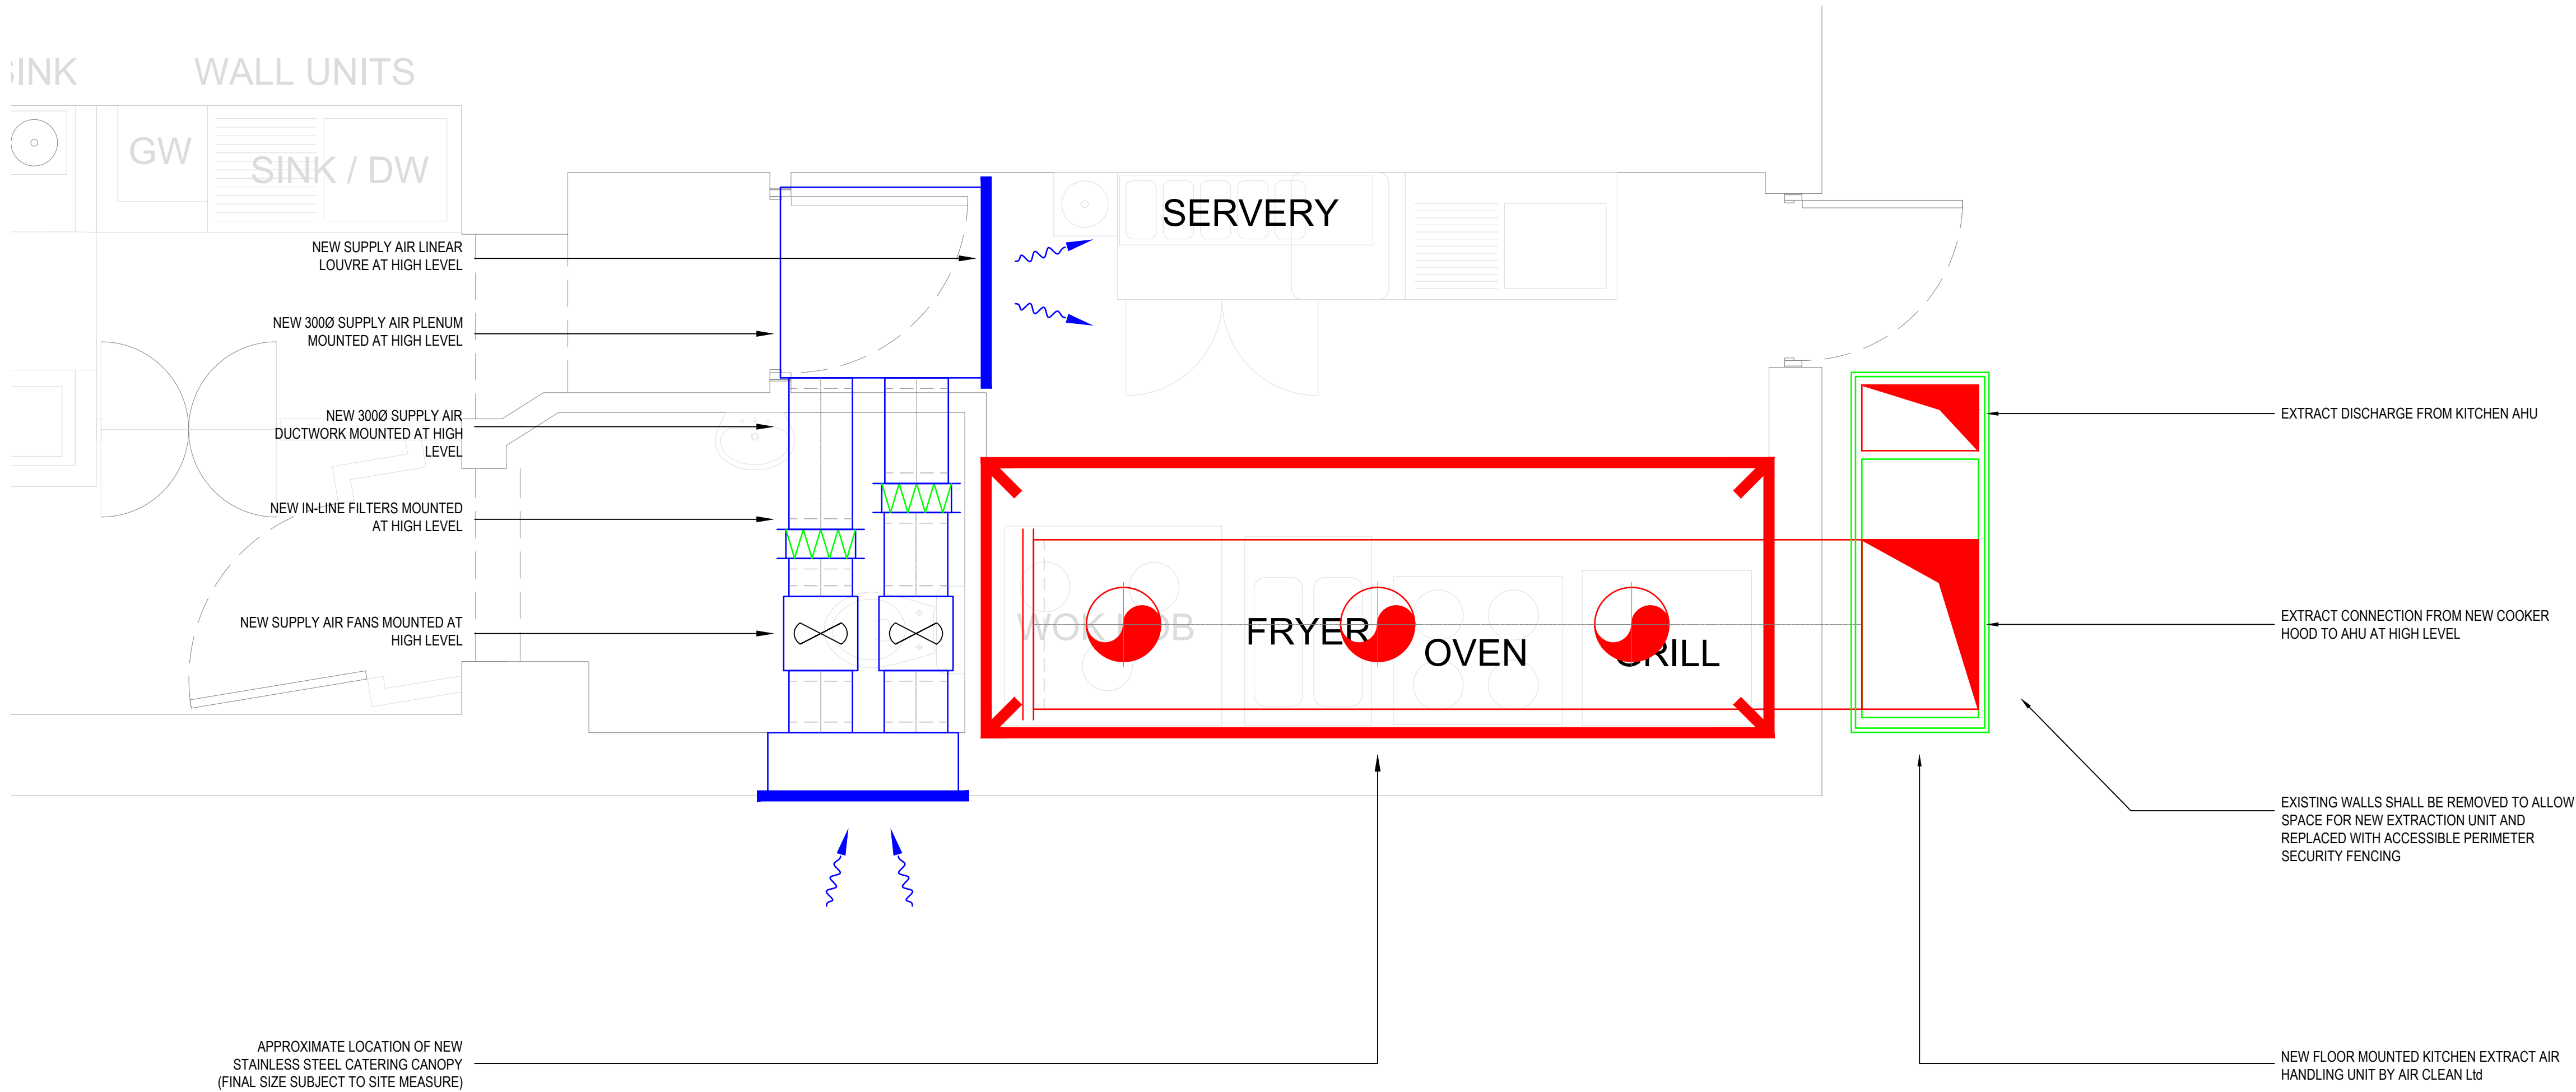

PROPOSED MECHANICAL SERVICES LAYOUT - KITCHEN AREA

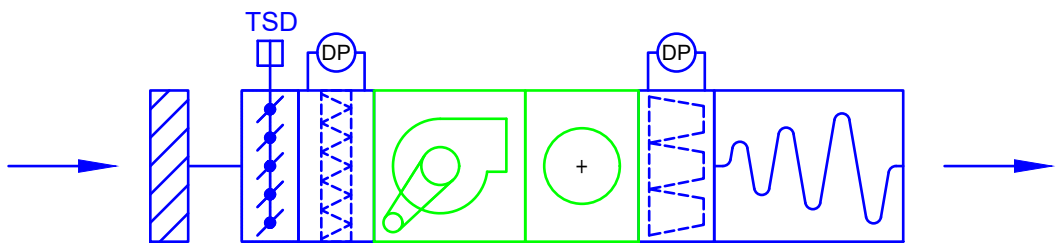

GENERAL SUPPLY AIR FAN SCHEMATIC LAYOUT (NTS)

- NOTES
1. THE CONTRACTOR SHALL VISIT SITE AND CONDUCT A FULL SURVEY TO FAMILIARISE THEMSELVES WITH THE DESIGN INTENTIONS AND THE WORKS THEY ARE REQUIRED TO UNDERTAKE. ANY ERRORS OR ANOMALIES SHALL BE HIGHLIGHTED TO THE ENGINEER OR PRIOR TO TENDER SUBMISSION. THE DRAWING SHALL NOT BE USED TO SCALE OR MEASURE FOR THE CONTRACTORS TENDER PURPOSES NOR SHALL ANY THE ARCHITECTURAL LAYOUTS BE TAKEN AS EXACT OR CORRECT.
 2. ALL INSTALLATIONS SHALL COMPLY WITH THE LATEST APPLICABLE RELEVANT REGULATIONS. CODES OF PRACTICE AND BRITISH STANDARDS INCLUDING ALL RELEVANT CLAUSES WITHIN THE SPECIFICATION.
 3. ALL PROPOSED POSITIONS OF EQUIPMENT & ROUTES OF PIPEWORK ARE INDICATIVE. THE CONTRACTOR SHALL BE RESPONSIBLE FOR THE FINAL SITE CO-ORDINATION & POSITIONING OF ALL EQUIPMENT IN CONJUNCTION WITH THE OTHER SERVICES & STRUCTURAL LAYOUTS.
 4. ALL PIPEWORK & CABLEING SHALL BE CONCEALED BEHIND CEILING VOIDS & OUT OF SIGHT WHERE PRACTICAL. WHERE NOT POSSIBLE THE CONTRACTOR SHALL INCLUDE TO 'BOX IN' ANY EXPOSED PIPEWORK.
 5. THE CONTRACTOR SHALL BE RESPONSIBLE FOR ALL POWER & ELECTRICAL CONTAINMENT.
 6. ON COMPLETION OF THE WORKS THE ELECTRICAL WORKS SHALL BE TESTED, COMMISSIONED & CERTIFIED ACCORDINGLY IN LINE WITH BS7671 & BS5266.
 7. THE CONTRACTOR SHALL INCLUDE FOR ALL BUILDERS WORK ASSOCIATED WITH THE WORKS.
 8. HOLES FOR PIPEWORK & CABLE & CONTAINMENT PASSING THROUGH STRUCTURAL WALLS & CEILINGS SHALL BE MADE GOOD & FIRE STOPPED WITH THE APPROPRIATE APPROVED METHODS.
 9. THE CONTRACTOR SHALL ENSURE THE INSTALLATION OF ALL PLANT & EQUIPMENT IS IN STRICT ACCORDANCE WITH THE MANUFACTURES INSTALLATION LITERATURE.
 10. ALL PIPEWORK SHALL BE FULLY INSULATED.

- DESIGN NOTES
1. FINAL SIZING OF ALL VENTILATION PLANT SUBJECT TO CATERING CANOPY REQUIREMENTS.
 2. FINAL LOCATION OF EQUIPMENT TO BE AGREED ON SITE DUE TO STRUCTURAL CONSTRAINTS.

P1	APR 21	PRELIMINARY ISSUE FOR COMMENT	HR	DM	
Rev	Date	Revision	Drawn	Ch'd	
Client					
Project		2NAKHON, DIDSBURY			
Drawing Title		PROPOSED KITCHEN VENTILATION LAYOUTS			
		McKee Associates Ltd Unity House Westwood Park Wigan WN3 4HE Web : www.mckeeassociates.co.uk Tel : 01942 918 145			
Cad Drawn	HR	Date	APR 21	Scale	1:20@A1
Checked	DM	Date	APR 21	Rev.	P1
Dwg No :		P2041-M-57-002			