



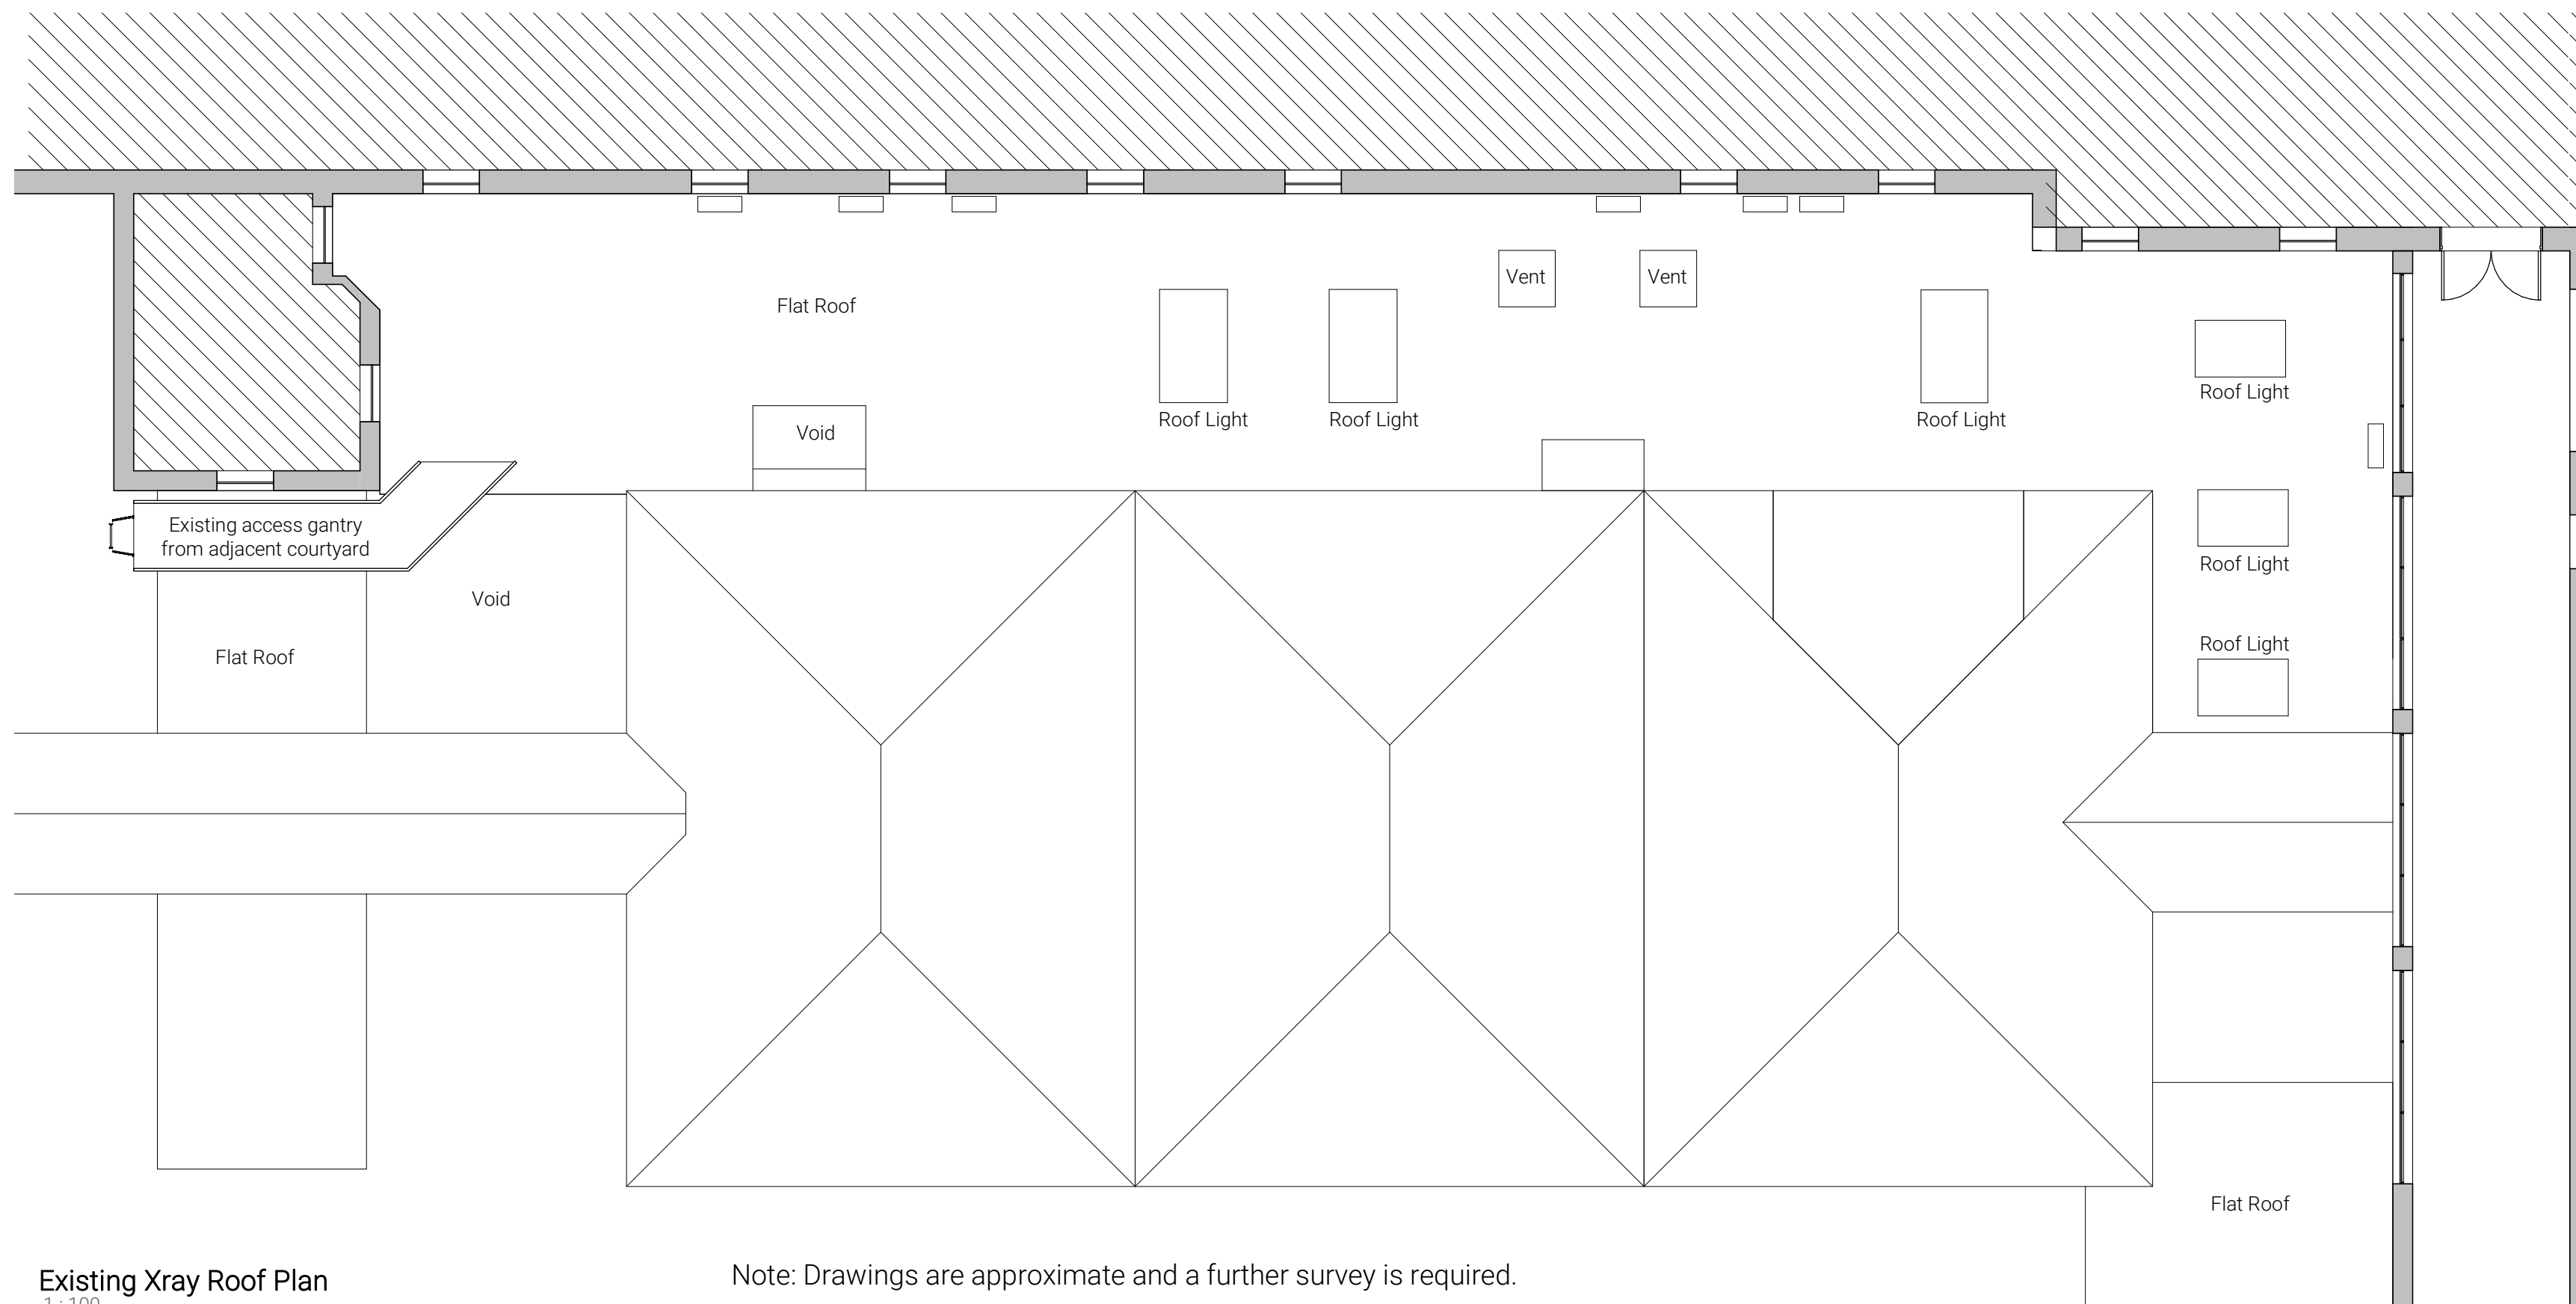

Note: Drawings are approximate and a further survey is required.

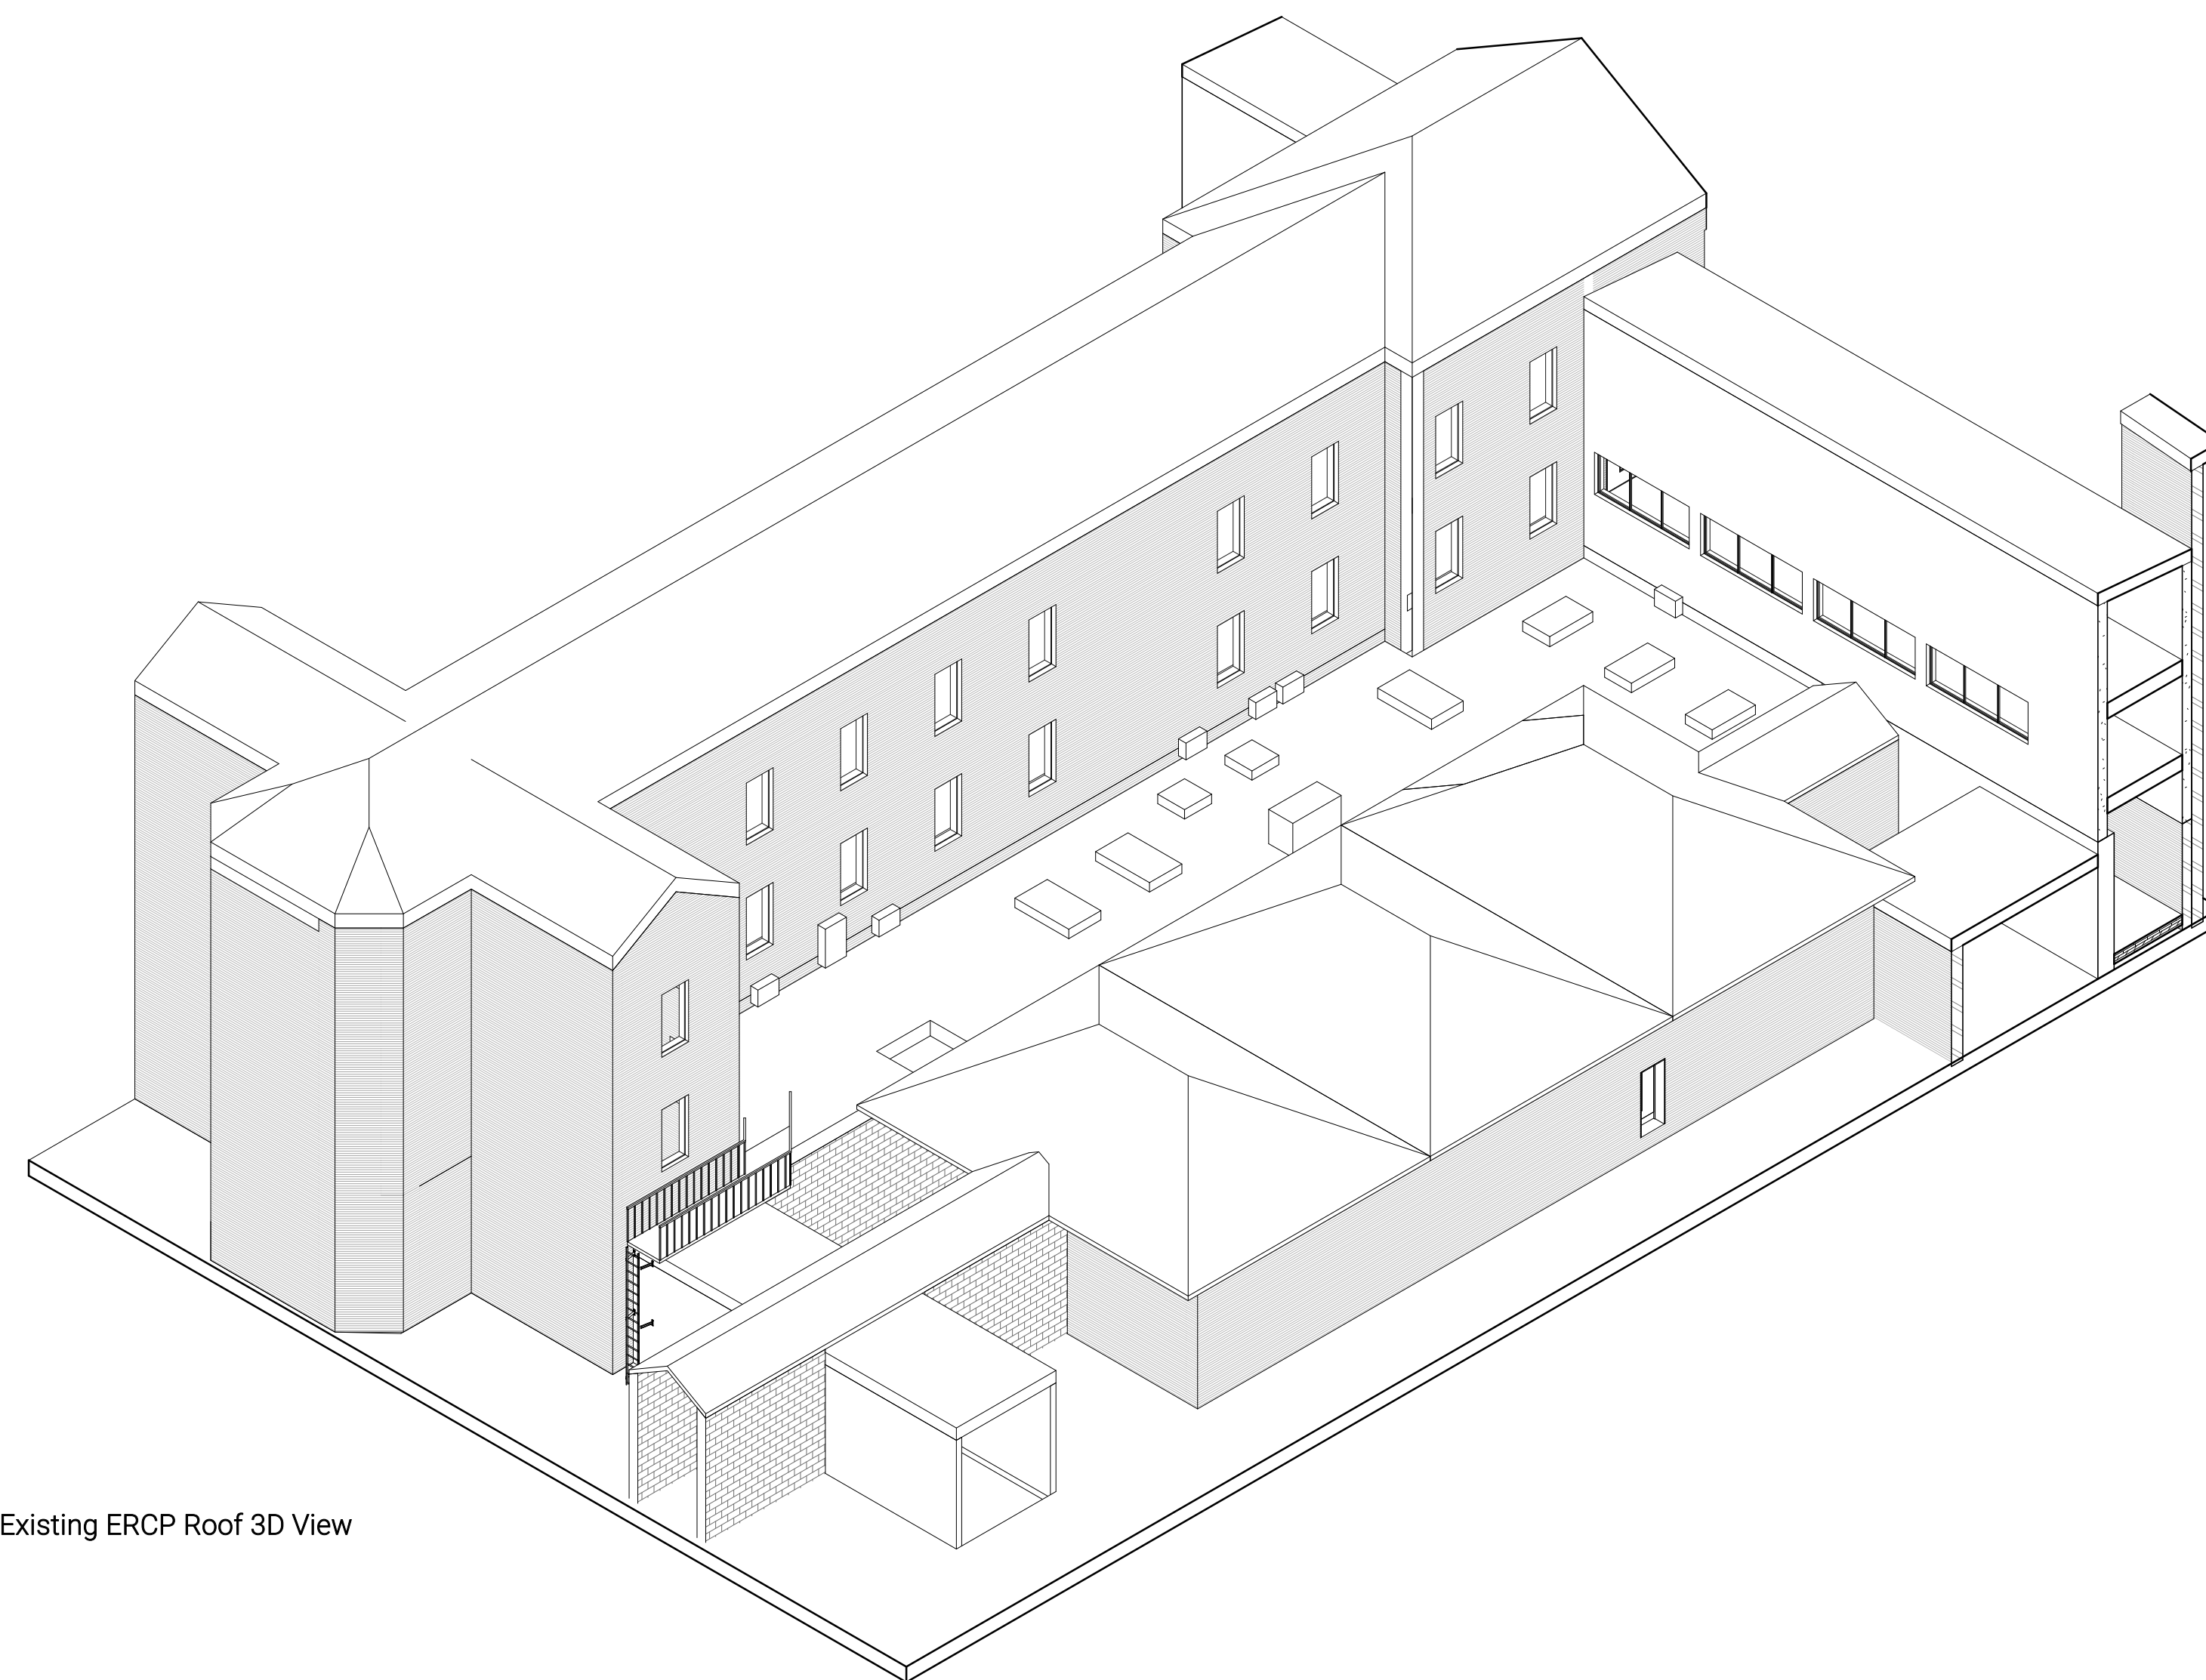

KEYPLAN

P1	PLANNING ISSUE	30/06/21	LPA	DAY
C	ISSUE FOR INFORMATION	22/06/21	Design Team	DAY
B	Issue for Pricing	25/05/21	QS	DAY
A	Issue for Comment	06.05.21	AF	AF
REV.	DESCRIPTION	DATE	DRW.	CHK.

 Manchester University NHS Foundation Trust			
APPOINTED PARTY LOGO/INFORMATION DAY			
PROJECT			
NMGH Endoscopy Refurbishment			
TITLE			
Existing ERCP Roof Plan			
STATUS		PURPOSE OF ISSUE	
		PLANNING	
DRAWN BY		CHECKED BY	DATE
MA		AF	22/06/21
SCALE (@A1)		PROJECT NUMBER	
As indicated		20201	
FILE DRAWING NUMBER			REV.
03-0103			P1