




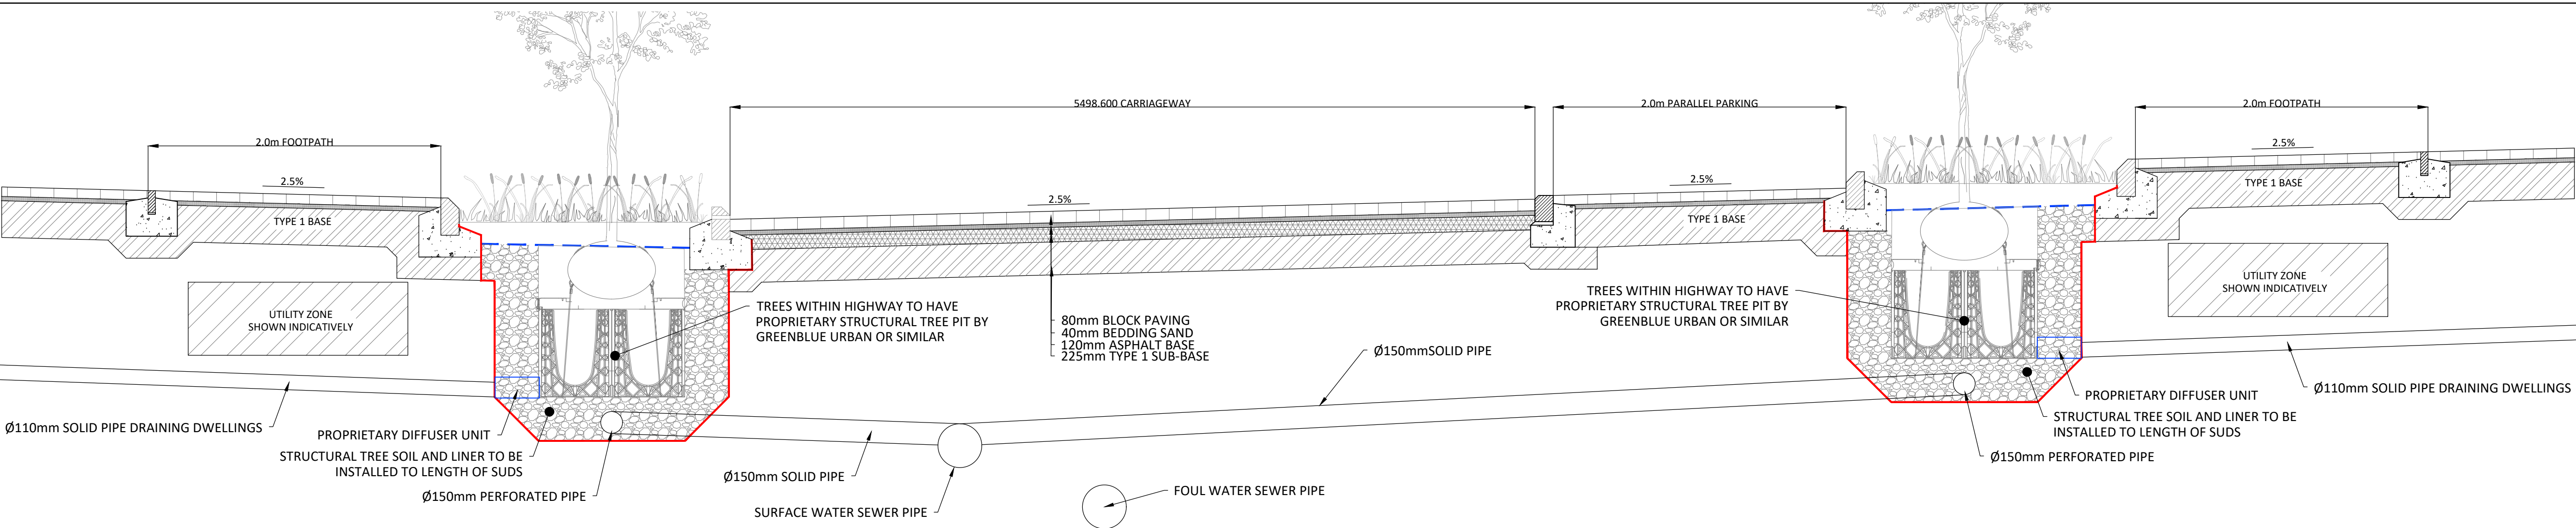


TYPICAL CROSS-SECTION - THROUGH STREET
SCALE 1:25

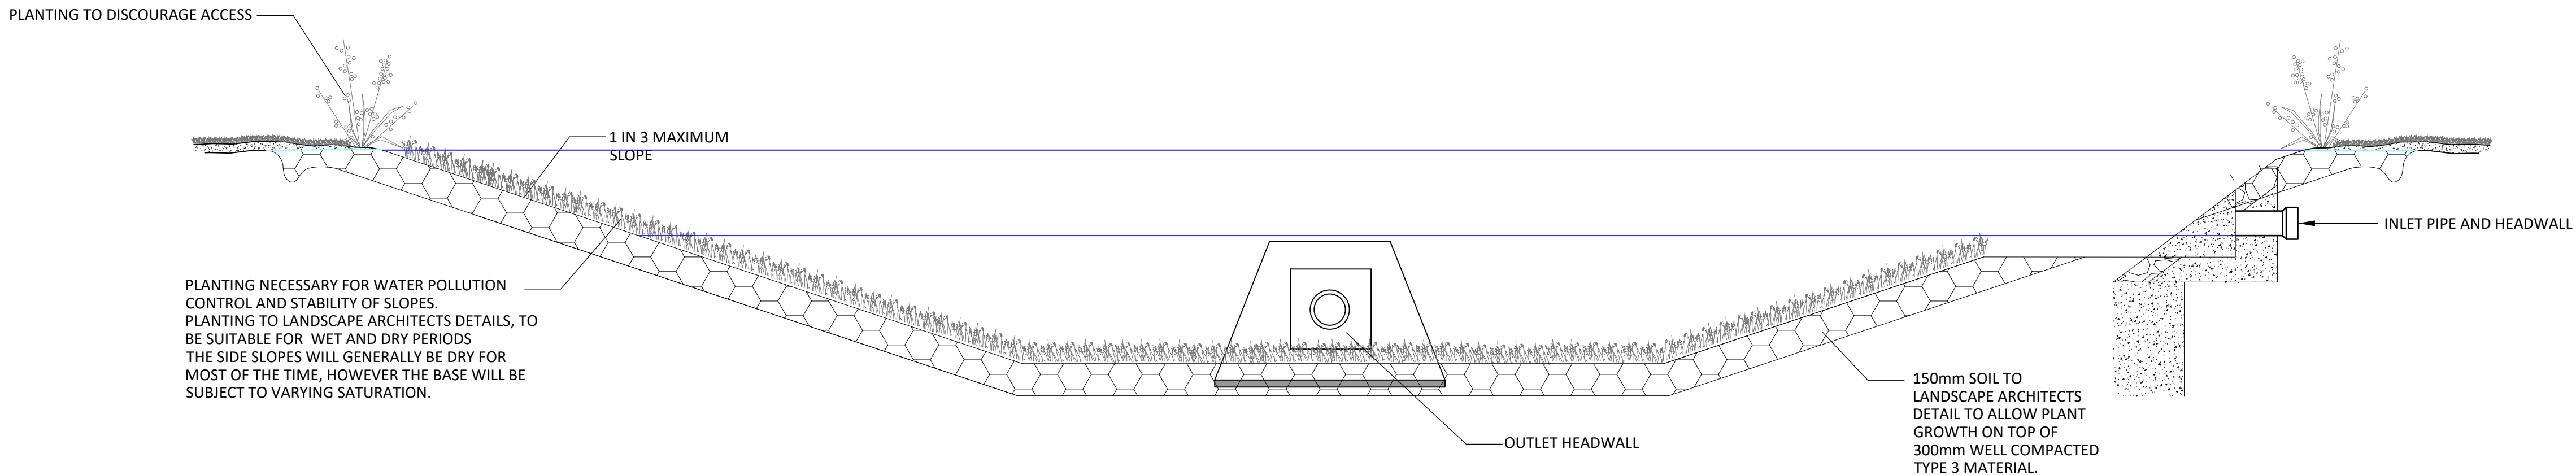


TYPICAL SECTION THROUGH ATTENUATION BASIN

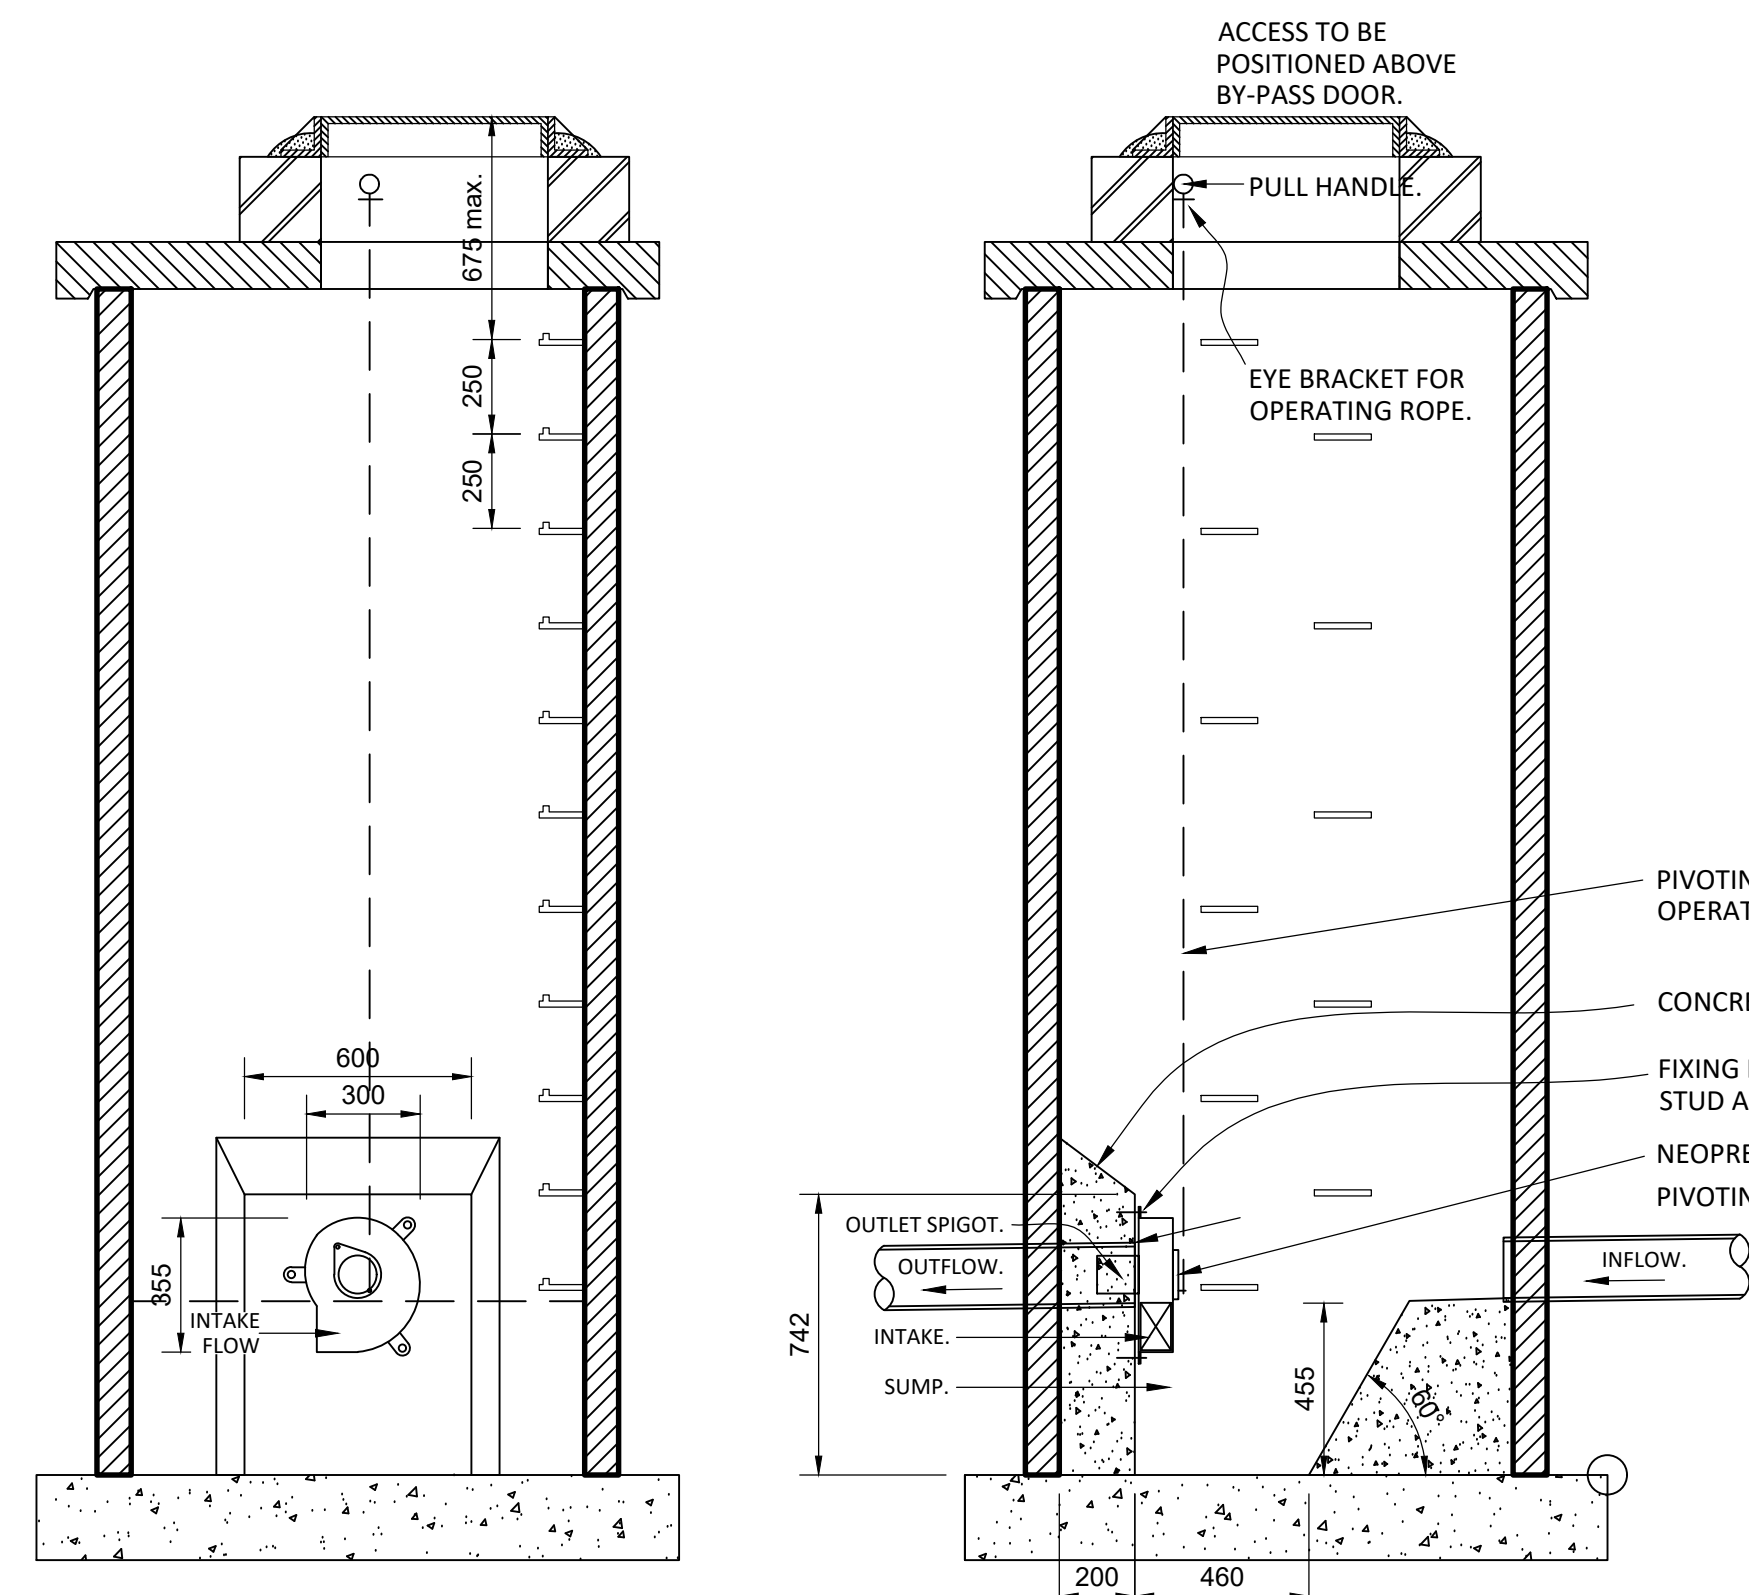


HYDRO-BRAKE
FLOW DESIGN: 8.0 l/s
DESIGN HEAD 1.540 m
CTL-SHE-0123-8000-1542-8000

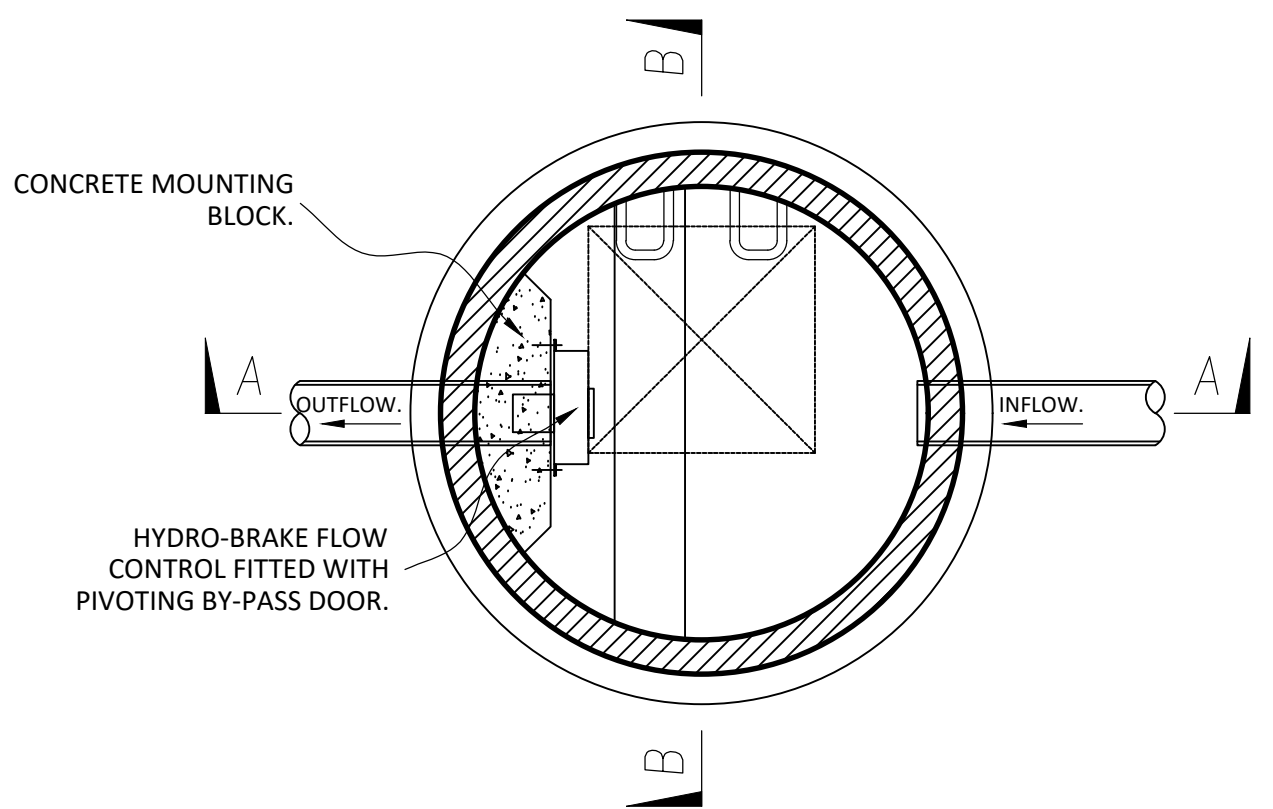

VORTEX FLOW CONTROL MANHOLE.

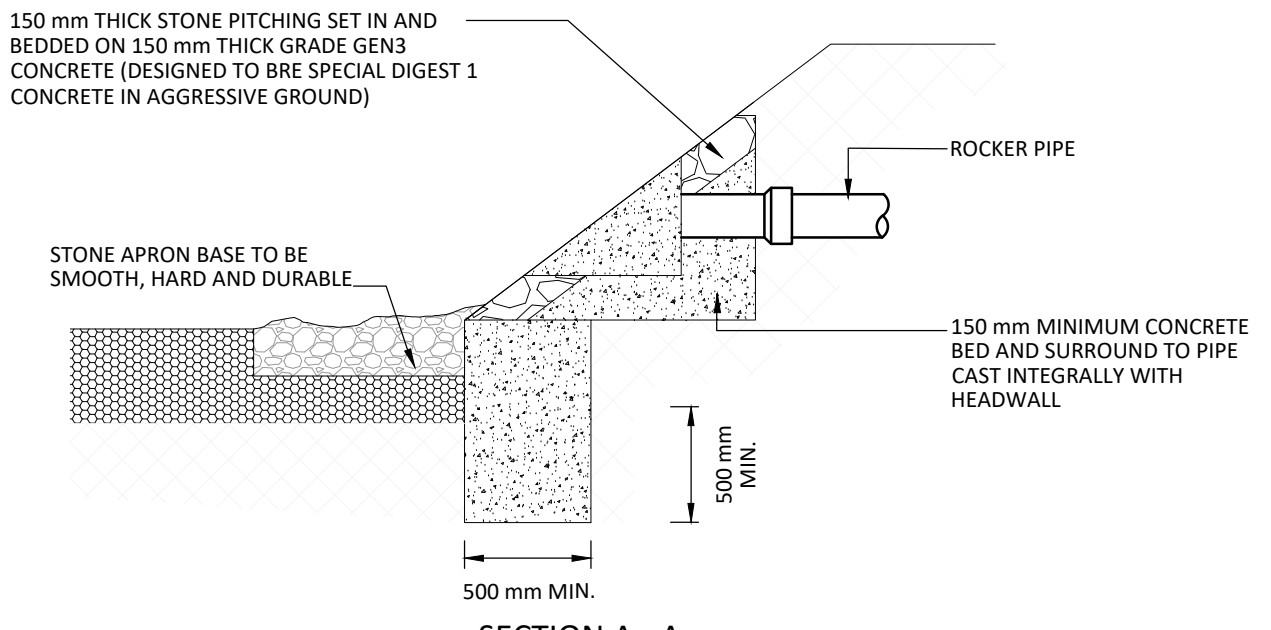

SECTION A - A

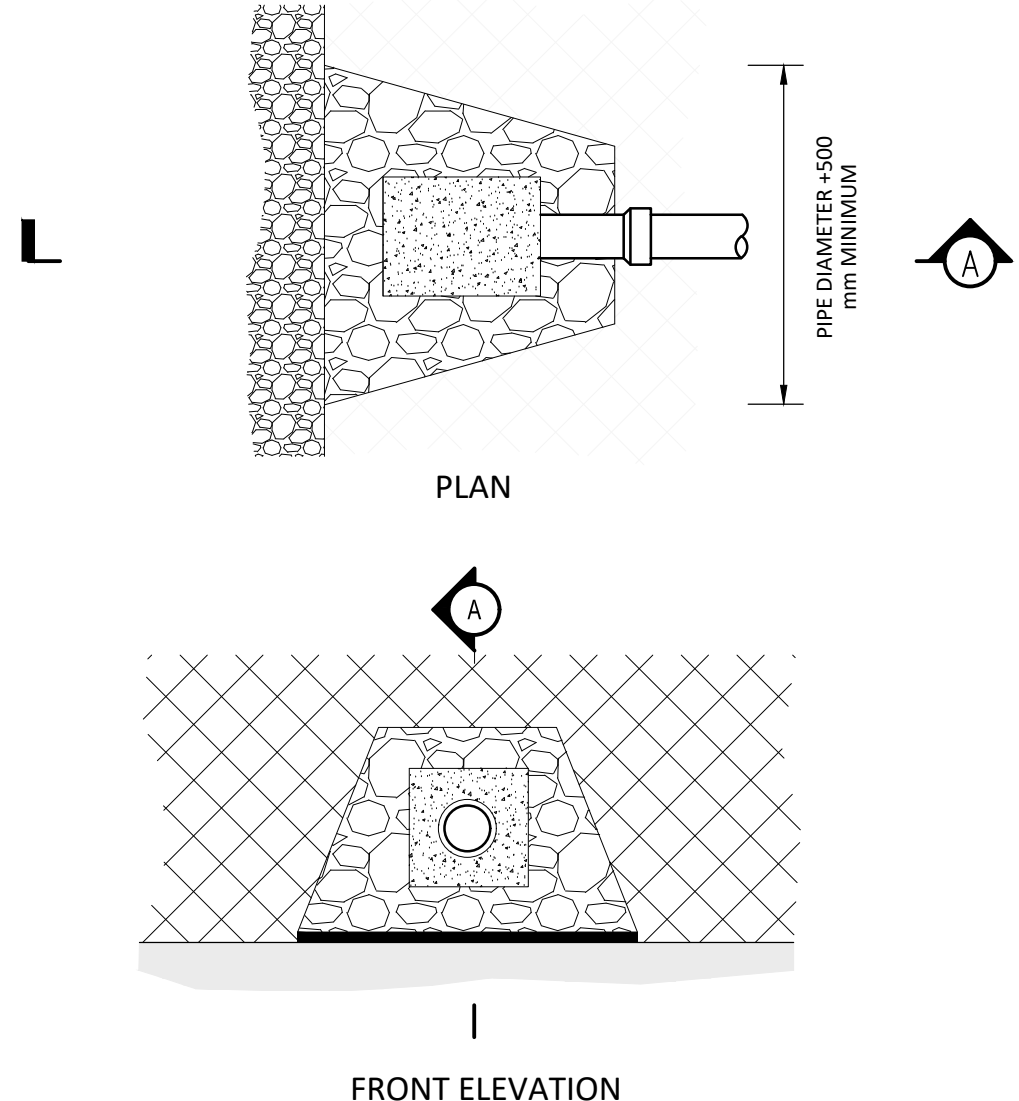

FRONT ELEVATION

TYPICAL DETAIL OF CAST IN-SITU
HEADWALL WITHIN POND

Standard Notes

1. This drawing is to be read in conjunction with all relevant Architect's and Engineer's drawings and the specification.
2. This drawing should not be scaled.
3. All dimensions are to be verified by the contractor on site.
4. All discrepancies should be reported to the C.A. prior to the commencement of the works.

© CIVIC ENGINEERS LIMITED

Notes and Keys

1. TYPICAL DRAINAGE DETAIL DRAWINGS TO BE READ IN CONJUNCTION WITH ALL CIVIC ENGINEER'S DRAWINGS AND ARCHITECTURAL DRAWINGS

Date	Rev	Description	Drawn	Chkd
11.05.21	P01	ISSUED FOR INFORMATION	RSH	CFK

Civic Engineers

MANCHESTER: Carver's Warehouse, 77 Dale Street, Manchester, M1 2HG. Tel: 0161 228 6757
LONDON: Rends Wharf, 83 Mill Street, London SE1 2AQ. Tel: 020 7253 2977
LYDS: Tower Works, Unit 10/11, Golder Road, Lyds, S14 5SD. Tel: 0115 925 130
GLASGOW: Greenhill Chambers, 45 West Nile St, Glasgow, G1 2PP. Tel: 0141 570 1829

www.civicingineers.com

Project: COLLYHURST HOUSING MANCHESTER

Title: TYPICAL DRAINAGE DETAILS SHEET 5

Status: INFORMATION

Project Number	Scale @ A1	Date Created	Drawn	Checked	Suitability
1226-01	1:20	MAY'21	RSH	CFK	-

Drawing Number: 1226-01-CIV-XX-VIL-DR-HI-0554

Revision: P01