



NOTES:
All dimensions must be checked on site and not scaled from this drawing.


Ref.	Date	Revisions	By
P1	21.06.19	PRELIMINARY ISSUE	C.P.
C1	29.08.19	CONSTRUCTION ISSUE	B.C.
C02	27.03.20	EXTERNAL CONDENSER SUPPLIES AMENDED	C.P.
C03	30.03.20	REVISIONS AS CLOUDED	C.P.
C04	09.04.20	EXTERNAL CONDENSER REFS AMENDED	B.C.
C05	02.12.20	EXT CONDENSER POSITIONS AMENDED	B.C.

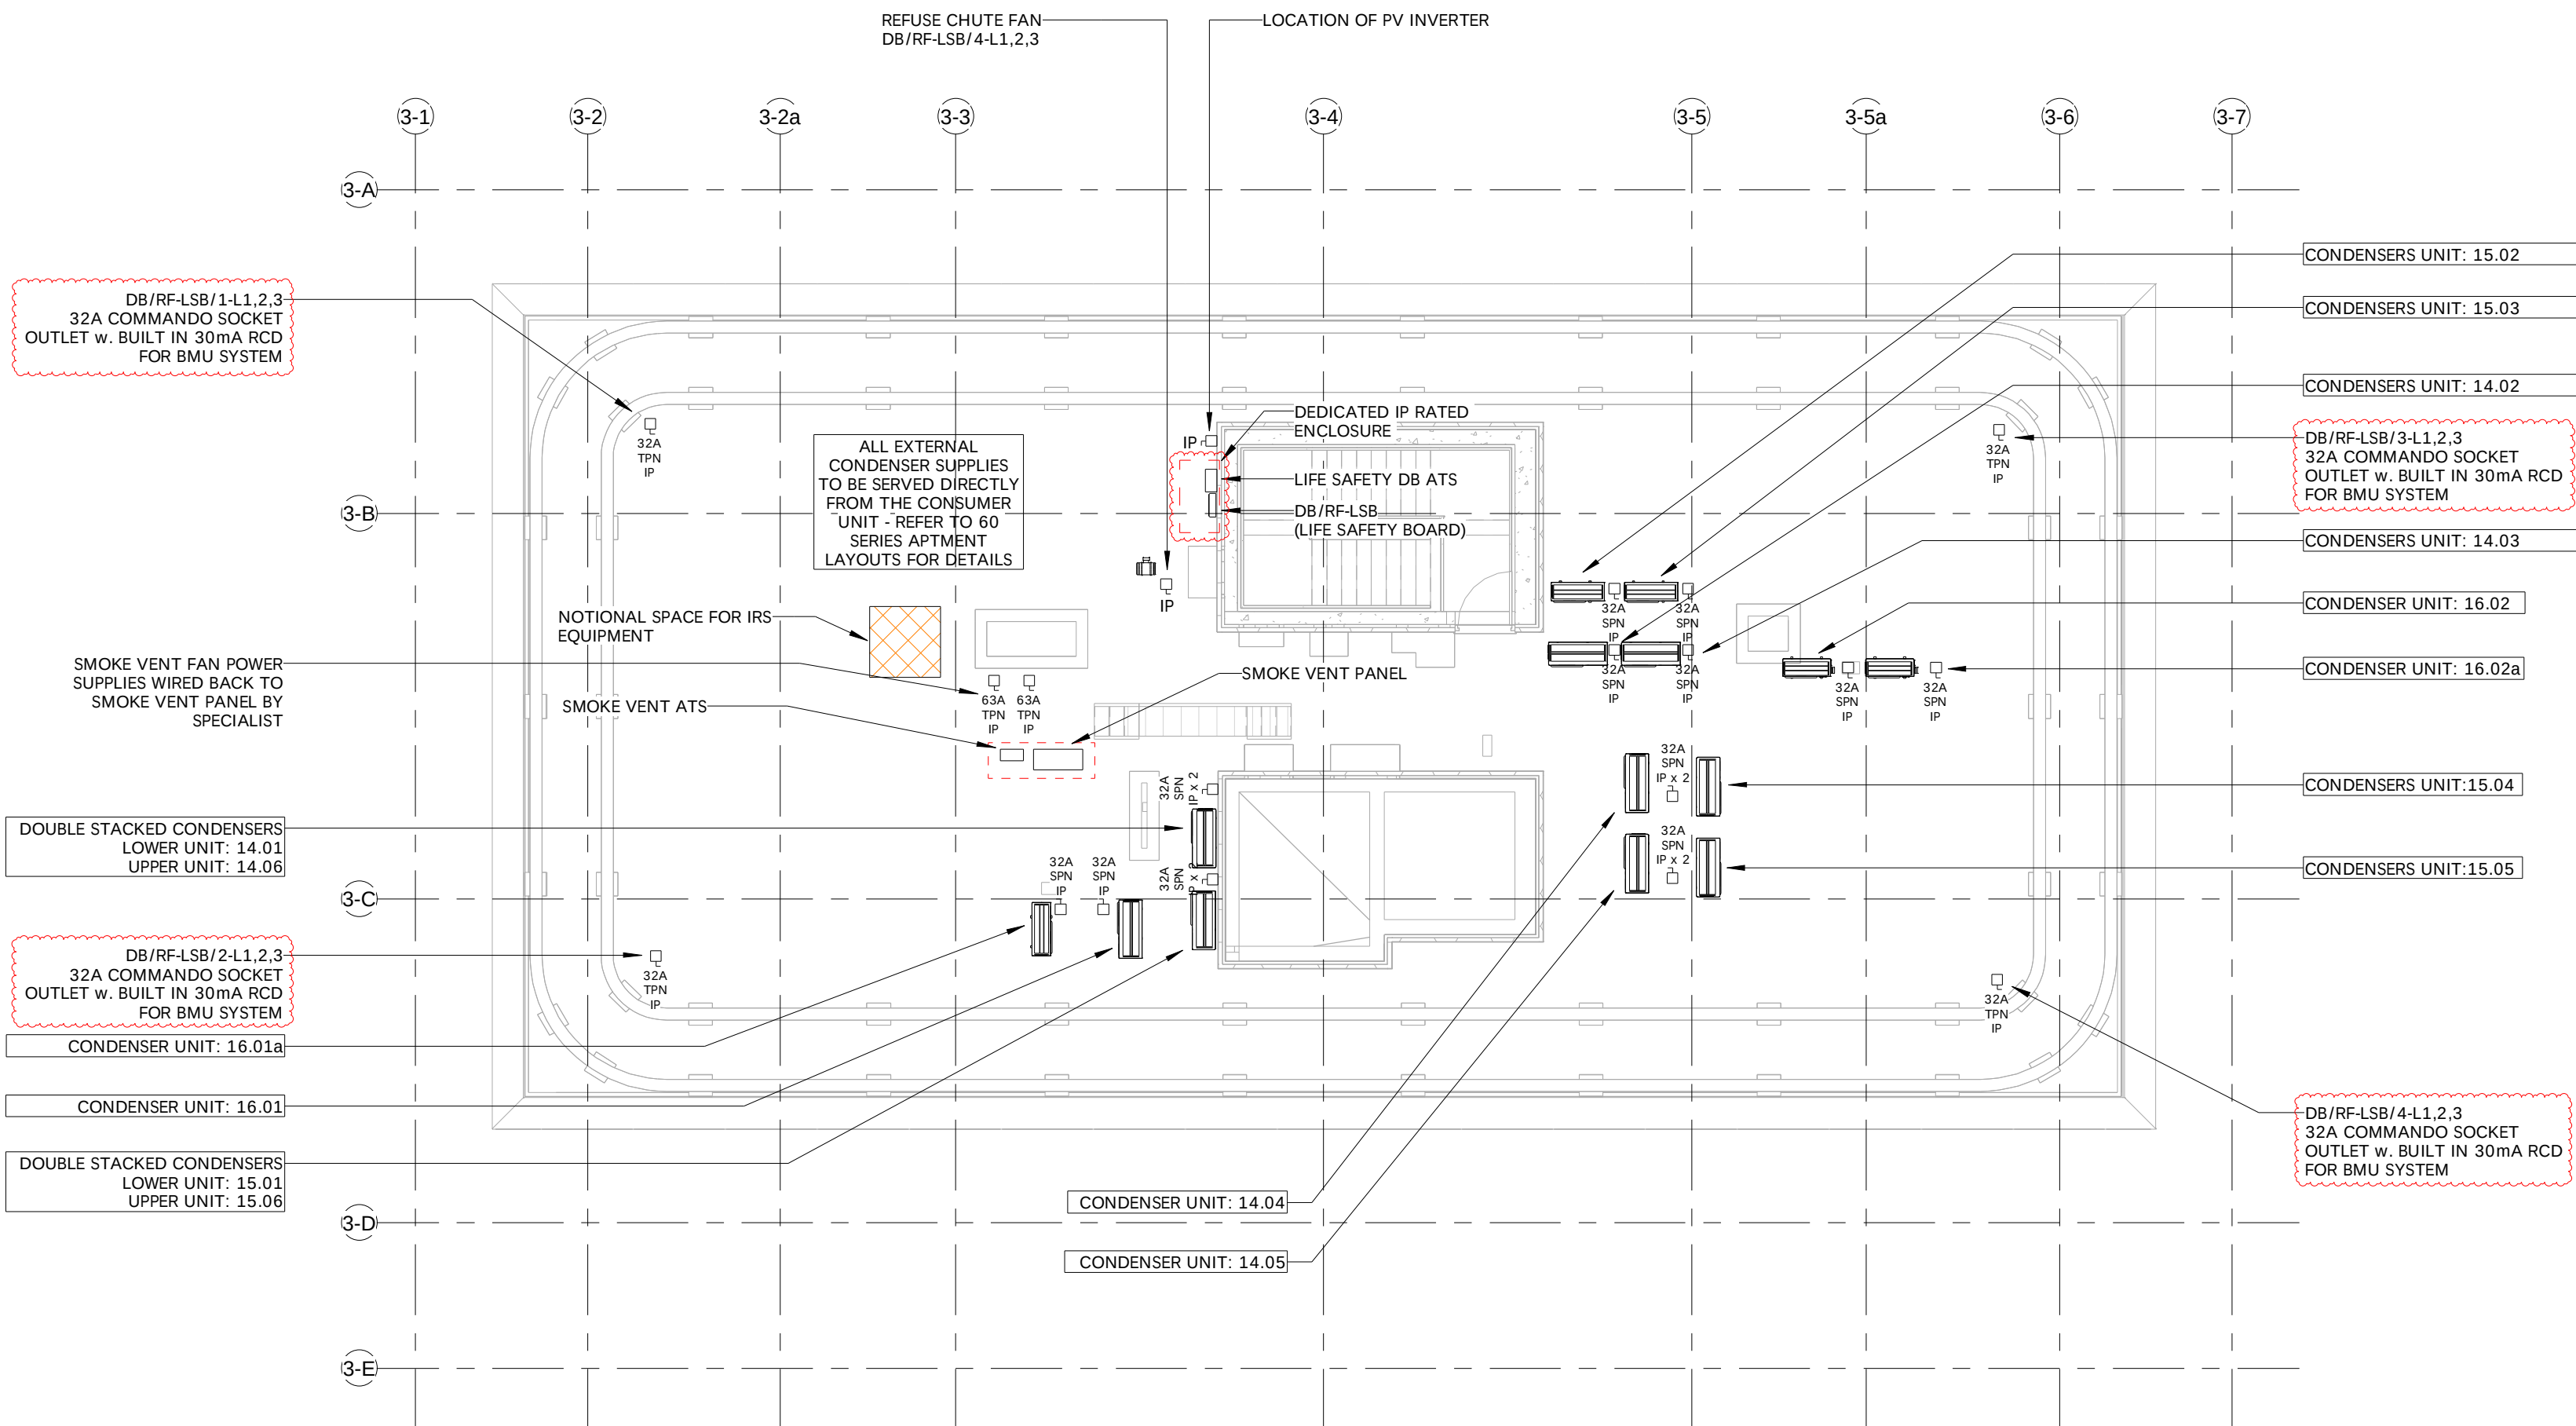


1 Roof Level Small Power & Data Layout
1 : 100

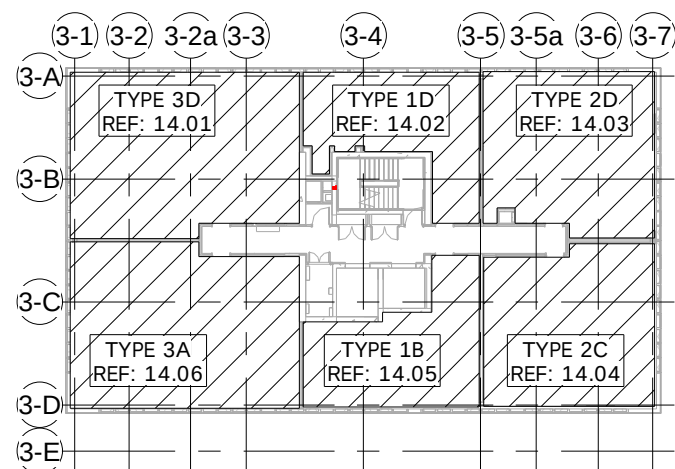

Level 14 - Apartment Condenser Key Plan
1 : 400

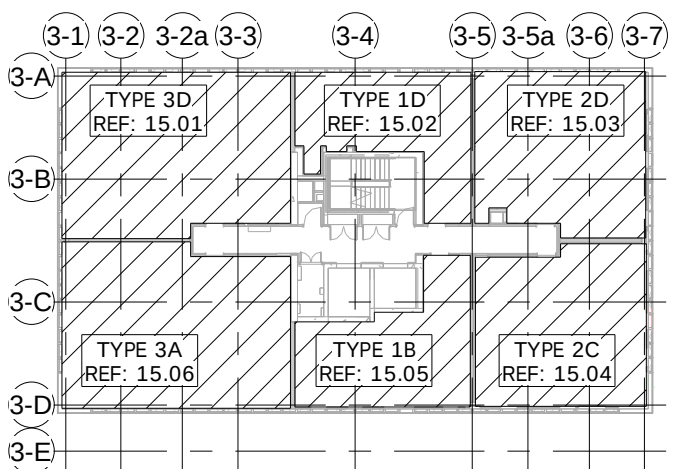

Level 15 - Apartment Condenser Key Plan
1 : 400

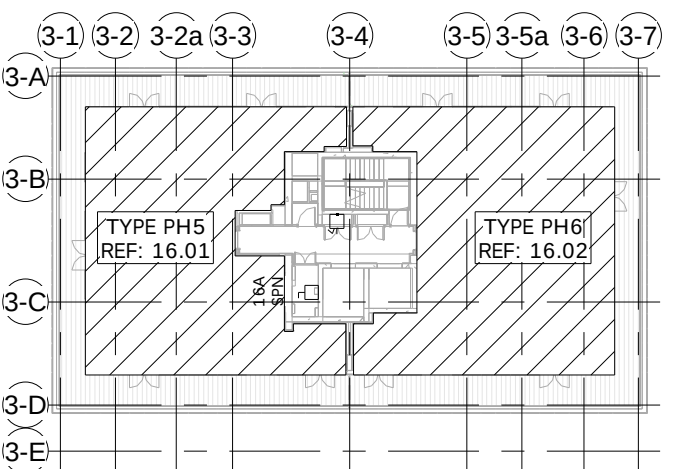

Level 16 - Apartment Condenser Key Plan
1 : 400

SMALL POWER & DATA NOTES

1. ALL DIMENSIONS ARE IN MILLIMETRES UNLESS OTHERWISE STATED.
2. DRAWING SYMBOLS ARE NOT TO SCALE.
3. FOR CIRCUIT REFERENCES, REFER TO DISTRIBUTION BOARD SCHEDULES.
4. POSITIONS OF ACCESSORIES SHOWN ARE TO BE CONFIRMED DURING COMMENTS PERIOD.
5. FOR TYPICAL MOUNTING HEIGHTS, REFER TO DRAWING No. 1002-AME-DRG-62-XX-0001
6. REFER TO THE FOLLOWING RISER LAYOUTS FOR SMALL POWER & DATA:
1002-E-AME-DRG-61-ZZ-3015 ELECTRICAL RISER 3C LEVELS B1-12 (SHEET 1 OF 2)
1002-E-AME-DRG-61-ZZ-3016 ELECTRICAL RISER 3C LEVELS 13-16 (SHEET 2 OF 2)
1002-E-AME-DRG-61-ZZ-3017 ELECTRICAL RISER 3A & MECHANICAL RISER 3B
7. CLEANERS SOCKETS KEYSWITCH OPERATED ADJACENT DB WITHIN RISER.

SMALL POWER & DATA LEGEND

- SINGLE UNSWITCHED SOCKET OUTLET
- SWITCHED SOCKET OUTLET (* DENOTES NO OF GANGS)
- SINGLE SWITCHED SOCKET OUTLET FOR CLEANERS
- UNSWITCHED FUSED SPUR
- SWITCHED FUSED SPUR
- ISOLATOR RATING AND PHASE AS DETAILED
- AUTOMATIC TRANSFER SWITCH
- R145 DATA OUTLET (* DENOTES NO OF GANGS)
- R145 DATA OUTLET FOR WIFI
- CIRCUIT LINE

- FLOOR BOX HOUSING 1No. TSSO
- FLOOR BOX HOUSING 1No. TSSO & 1No. CLEANERS SOCKET
- FLOOR BOX HOUSING 2No. TSSO & 1No. R145 OUTLET
- FLOOR BOX HOUSING 2No. TSSO

EXTERNAL CONDENSER SCHEDULE

REF	APT TYPE	LEVEL	MODEL NUMBER
14.01	3D	LEVEL 14	MCY-MHP0604HS-E
14.02	1D	LEVEL 14	RAS-5M34U2AVG-E
14.03	2D	LEVEL 14	MCY-MHP0406HT-E
14.04	2C	LEVEL 14	MCY-MHP0406HT-E
14.05	1B	LEVEL 14	MCY-MHP0406HT-E
14.06	3A	LEVEL 14	MCY-MHP0604HS-E
15.01	3D	LEVEL 15	MCY-MHP0604HS-E
15.02	1D	LEVEL 15	RAS-5M34U2AVG-E
15.03	2D	LEVEL 15	MCY-MHP0406HT-E
15.04	2C	LEVEL 15	MCY-MHP0406HT-E
15.05	1B	LEVEL 15	MCY-MHP0406HT-E
15.06	3A	LEVEL 15	MCY-MHP0604HS-E
16.01	PH5	LEVEL 16	MCY-MHP0604HS-E
16.01a	PH5	LEVEL 16	RAV-GM1601AT-E
16.02	PH6	LEVEL 16	MCY-MHP0506HT-E
16.02a	PH6	LEVEL 16	RAV-GM1601AT-E

ABBREVIATION LEGEND:


- AB -ACCESS BARRIER
- AD -AUTOMATIC DOOR
- AHU -AIR HANDLING UNIT
- AOV -AUTOMATIC OPENING VENT
- ASP -ASPIRATING SMOKE PANEL
- ATS -AUTOMATIC TRANSFER SWITCH
- BMS -BUILDING MANAGEMENT SYSTEM
- CAT-5 -CAT-5 BOOSTER SET
- CCP -CAR CHARGING POINT
- CCTV -CLOSED CIRCUIT TELEVISION
- DA -DIS WC ALARM
- DAC -ACCESS CONTROL
- DB -DISTRIBUTION BOARD
- DL -DEDICATED LINES
- DW -DISHWASHER
- EF -EXTRACT FAN
- FAP -FIRE ALARM PANEL
- FCU -FAN COIL UNIT
- FF -FRIDGE/FREEZER
- HD -HAND DRYER
- HRU -HEAT RECOVERY UNIT
- HL -HIGH LEVEL
- IP -INGRESS PROTECTION
- MSD -MOTORISED FIRE DAMPER
- ODH -OVER DOOR HEATER
- PH -PANEL HEATER
- PoE -POWER OVER ETHERNET
- RC -RED CARE
- RI -REFUGE INTERCOM
- SPN -SINGLE PHASE NEUTRAL
- TH -TRENCH HEATER
- TPN -THREE PHASE NEUTRAL
- WBP -WATER BOOSTER PUMP
- WF -WATER FOUNTAIN
- WH -WATER HEATER

CONSTRUCTION

ameon
Building Services Engineering

Unit 9-10 Olympic Court, Boardmans Way,
Whitehills Business Park, Blackpool, FY4 5GU
Tel: 01253 760160
Fax: 01253 760150
E-mail: info@ameon.co.uk

Client	Job Title	Drawing Title	Date MAY 2019
	Angel Meadows Plot 3	Roof Level Small Power & Data Layout	Scale @ A1 As indicated
			Drawn by C.P
			Drawing Number 1002-E-AME-DRG-62-R1-3006
			Revision C05

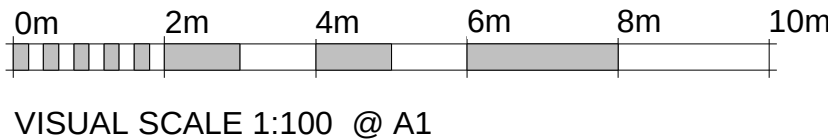

VISUAL SCALE 1:100 @ A1