


- notes:
- DO NOT SCALE FROM THIS DRAWING - USE FIGURED DIMENSIONS ONLY.
 - TO BE READ IN CONJUNCTION WITH ALL OTHER CONSULTANTS / SPECIALISTS DRAWINGS. REPORT ANY DISCREPANCIES BEFORE AFFECTED WORK COMMENCES.
 - ALL SETTING OUT DIMENSIONS TO BE CHECKED ON SITE BY CONTRACTOR BEFORE WORK COMMENCES.

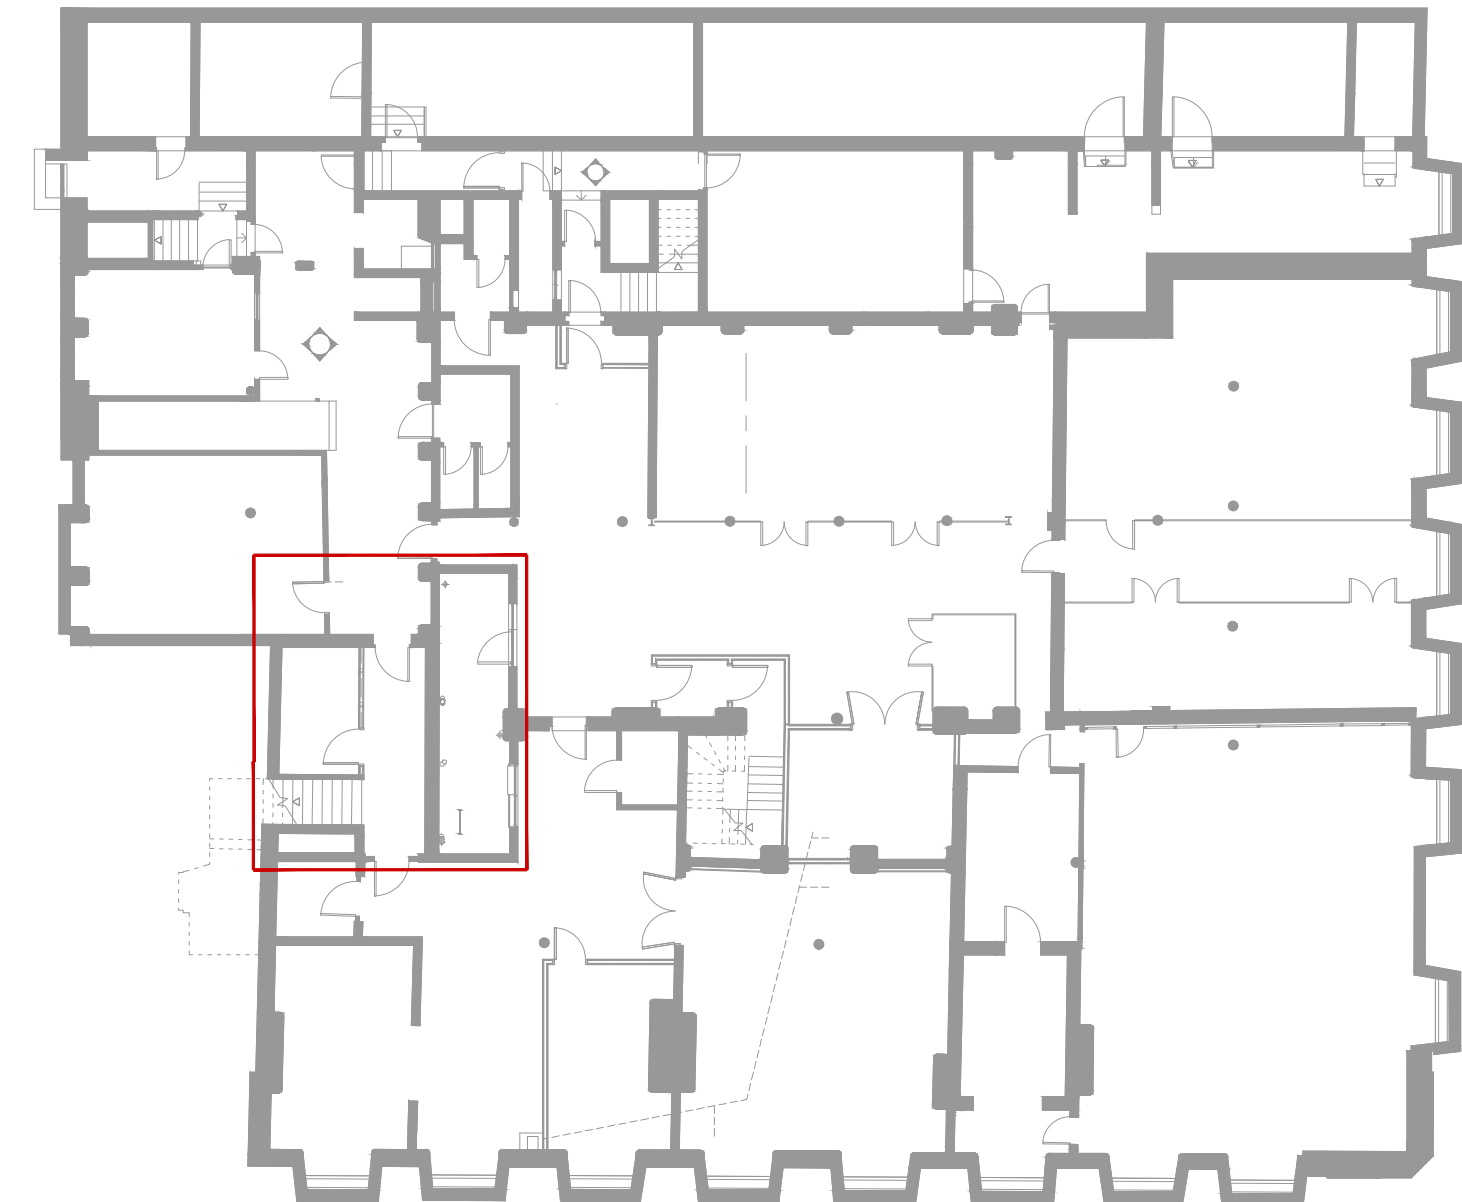

KEY

KEY

SERVICES ON EITHER INDIVIDUAL SCREW RODS OR UNISTRUT.

SERVICES ON SUSPENDED BASKET OR TRAY

CABLE OR PIPE PENETRATIONS THROUGH SLAB




SMOKE OR PIR DETECTOR

SURFACE FIXED LIGHTING WITH CONDUIT

- NOTES:
- ALL SMOKE DETECTORS WILL REQUIRE TEMPORARY REMOVAL FOR REFITTING AGAINST NEW CEILING LINING.
 - UNI STRUT AND SCREW RODS TO REMAIN IN PLACE FOR FITTING NEW CEILING AROUND WITH FR SEALANT AROUND RODS.
 - NEW WALLS AROUND SERVICES WILL REQUIRE SEALING WITH ABLATIVE BATTS AND FR SEALANT.
 - ALL ELECTRICAL PENETRATIONS (UPTO 40MMØ I.E DATA, SMOKE LIGHTING) AROUND EXISTING SERVICES WILL REQUIRE FR SEALANT.
 - ALL MECHANICAL SERVICES ABOVE 40MM Ø (I.E. HEATING PIPES, SOIL/RWP PIPES) WILL REQUIRE A FR60 FIRE COLLAR FITTING IN THE NEW CEILING.

TYPE 2
AREA OF LATH AND PLASTER CEILING TO BE UNDERDRAWN USING:

METAL MESH, (CHICKEN WIRE) FIXED IN ACCORDANCE WITH MANUFACTURER INSTRUCTIONS. 38X38MM SWD BATTENS (OR MF GRID AT 610MM CENTRES), 2 LAYERS OF 12.5MM FIRELINE PLASTERBOARD, ALL BOARD JOINTS AND JUNCTIONS FILLED WITH BONDING.

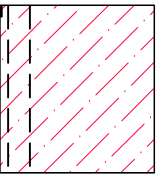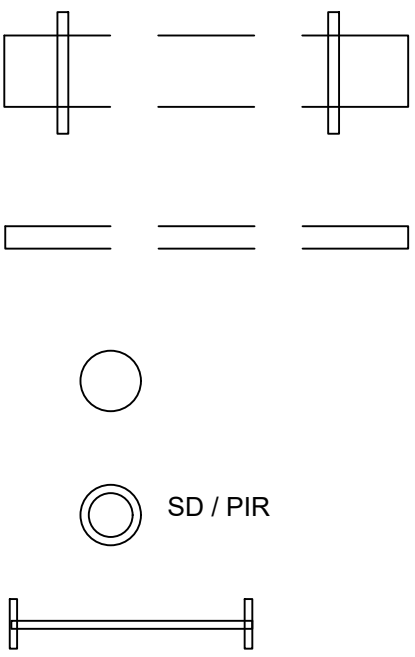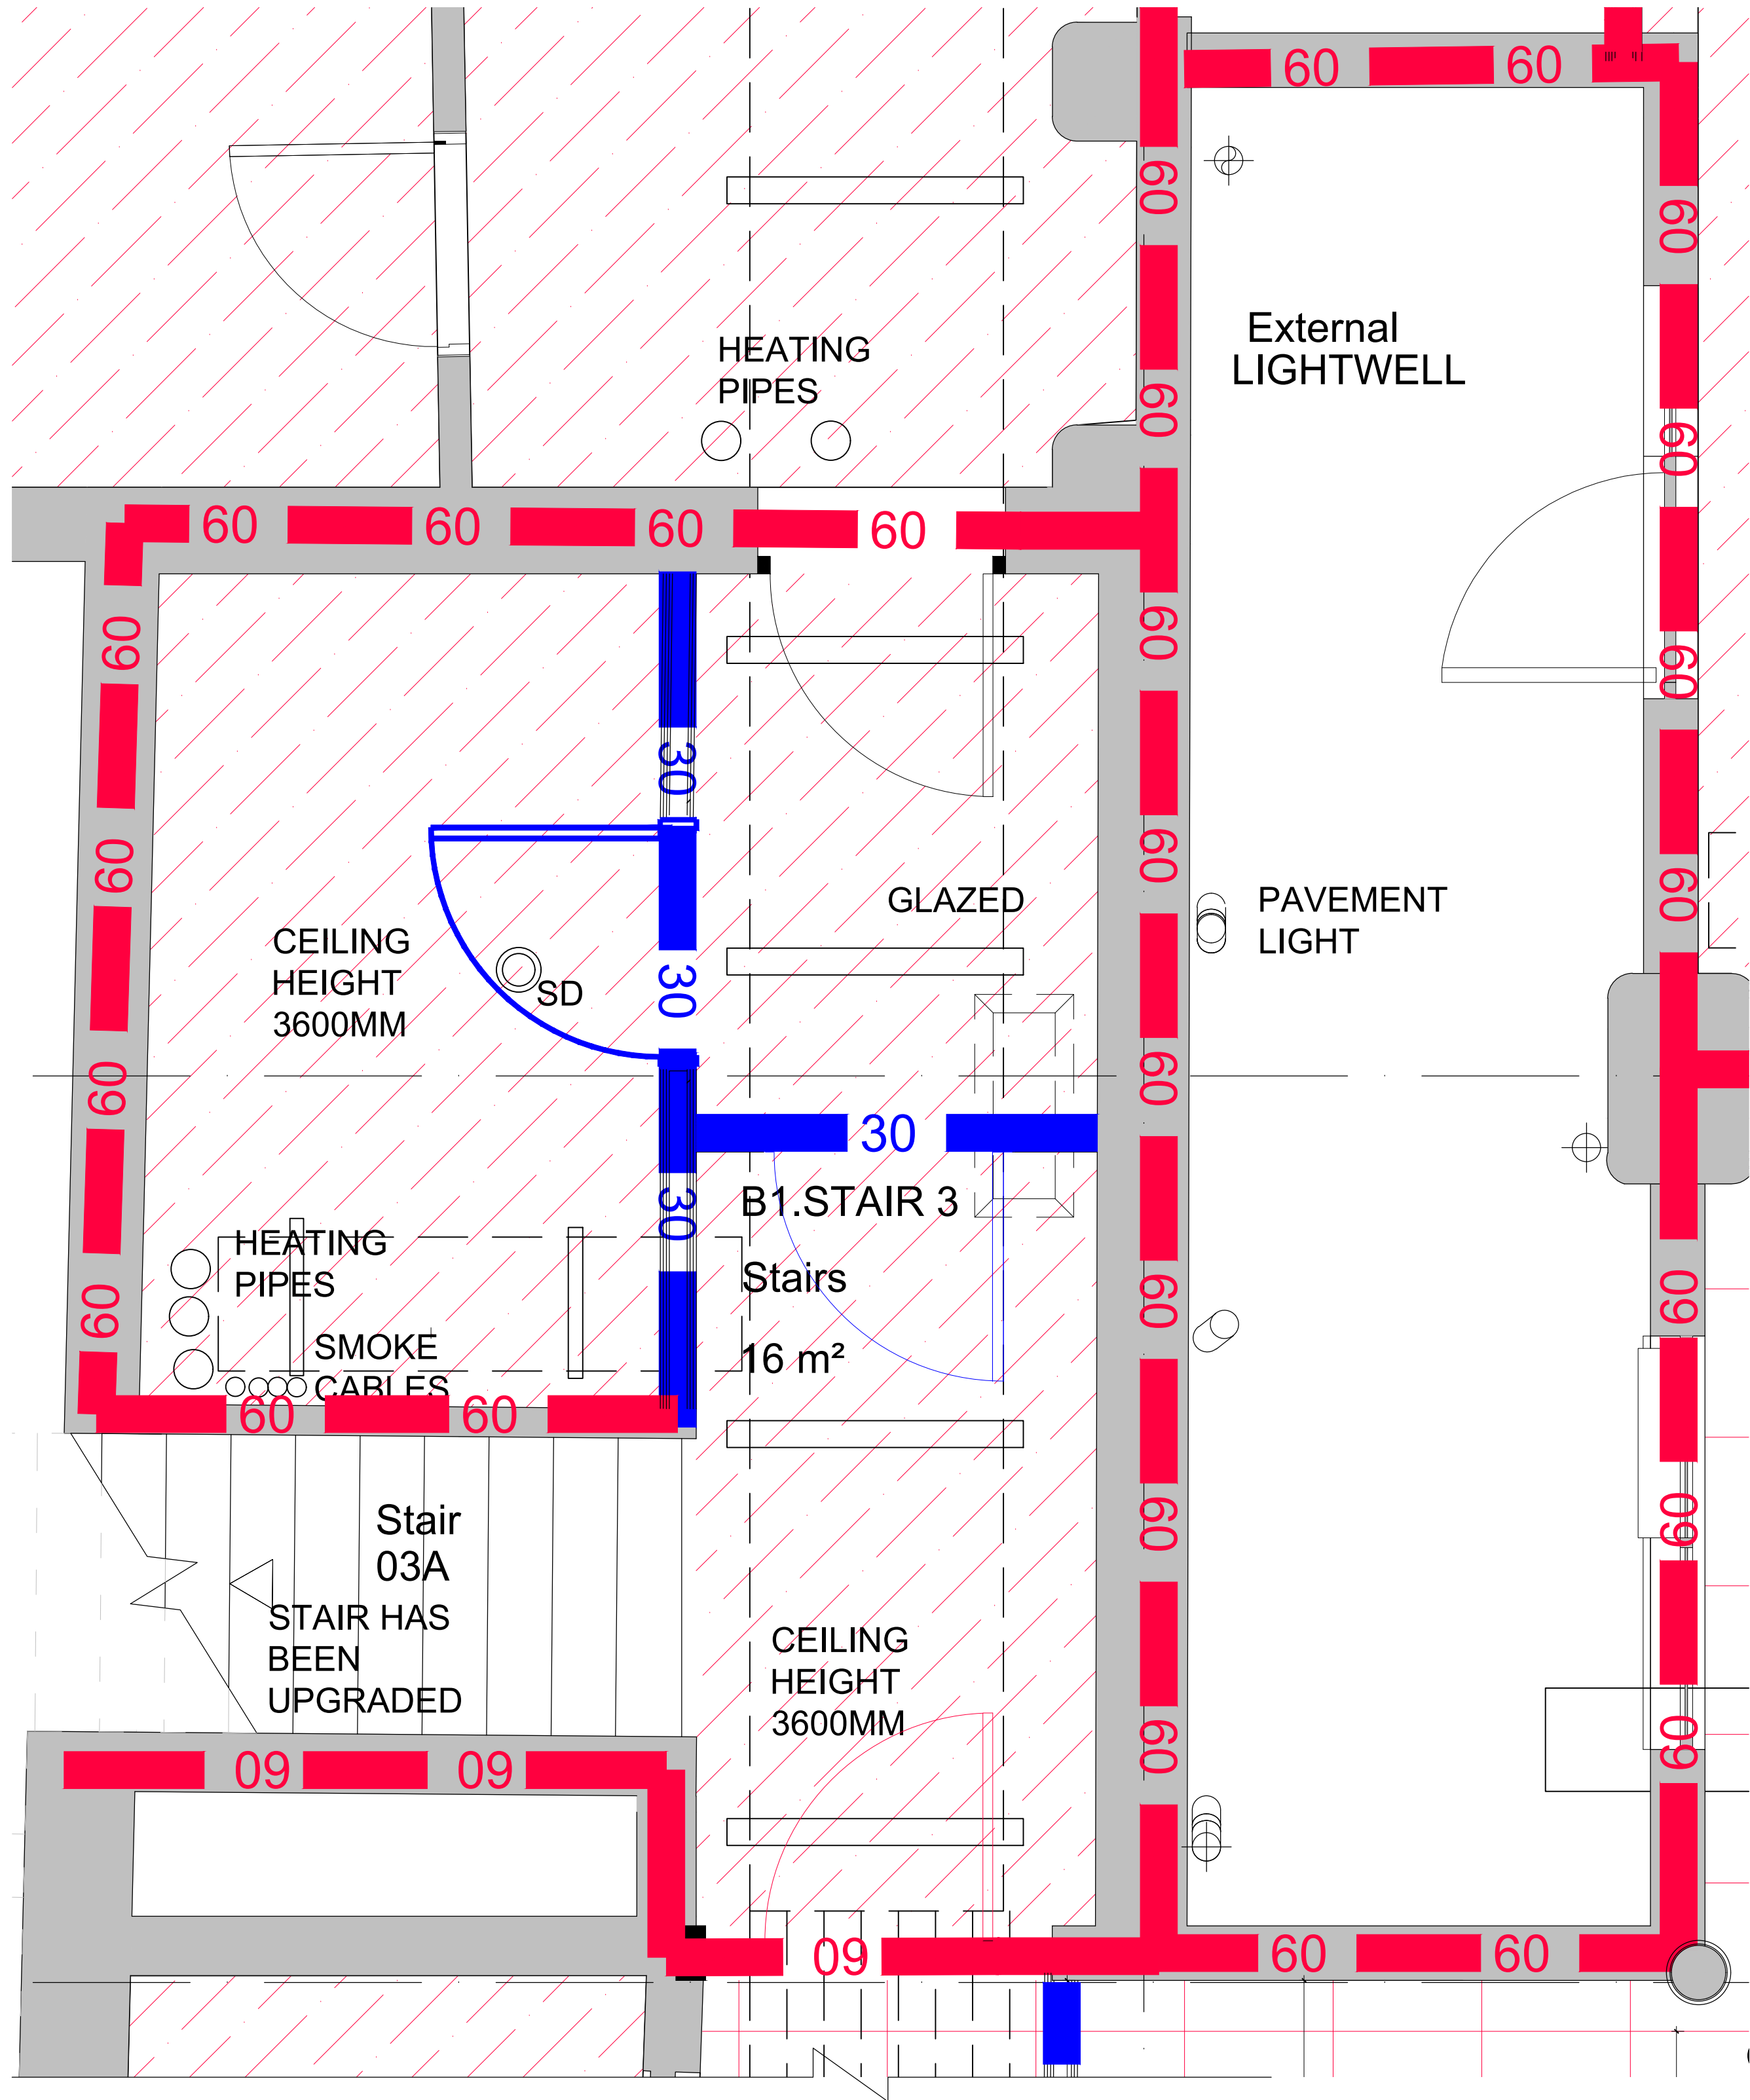

PLAN
1:20

A	NEW_STAIR_PARTITION
REVISIONS	DRAWING_ISSUE

09/04/21 SK LM
31/03/21 SK LM
DATE, DRAWN; CHECK

05/03/21 SK
DRAWN BY
CHECKED BY

CLIENT Manchester Metropolitan University
PROJECT Ormond Building
TITLE PROPOSED REFLECTED CEILING PLAN
B1.STAIR 3
NUMBER 20608_P273

seven.
SEVENARCHITECTURE.CO.UK
Studios at:
61 Oxford Street,
MANCHESTER, M1 6EQ
t: 0161 226 9555
Clarendon House, Victoria Avenue,
HARROGATE, HG1 1DY
t: 01423 709 907
Galeri 6, Doc Victoria,
CAERNARFON, LL55 1SQ
t: 01286 685 253
24 Greville Street,
LONDON, EC1N 6SS
t: 0203 036 0691