


REVISION	DATE	DESCRIPTION
-	06.05.21	PLANNING ISSUE

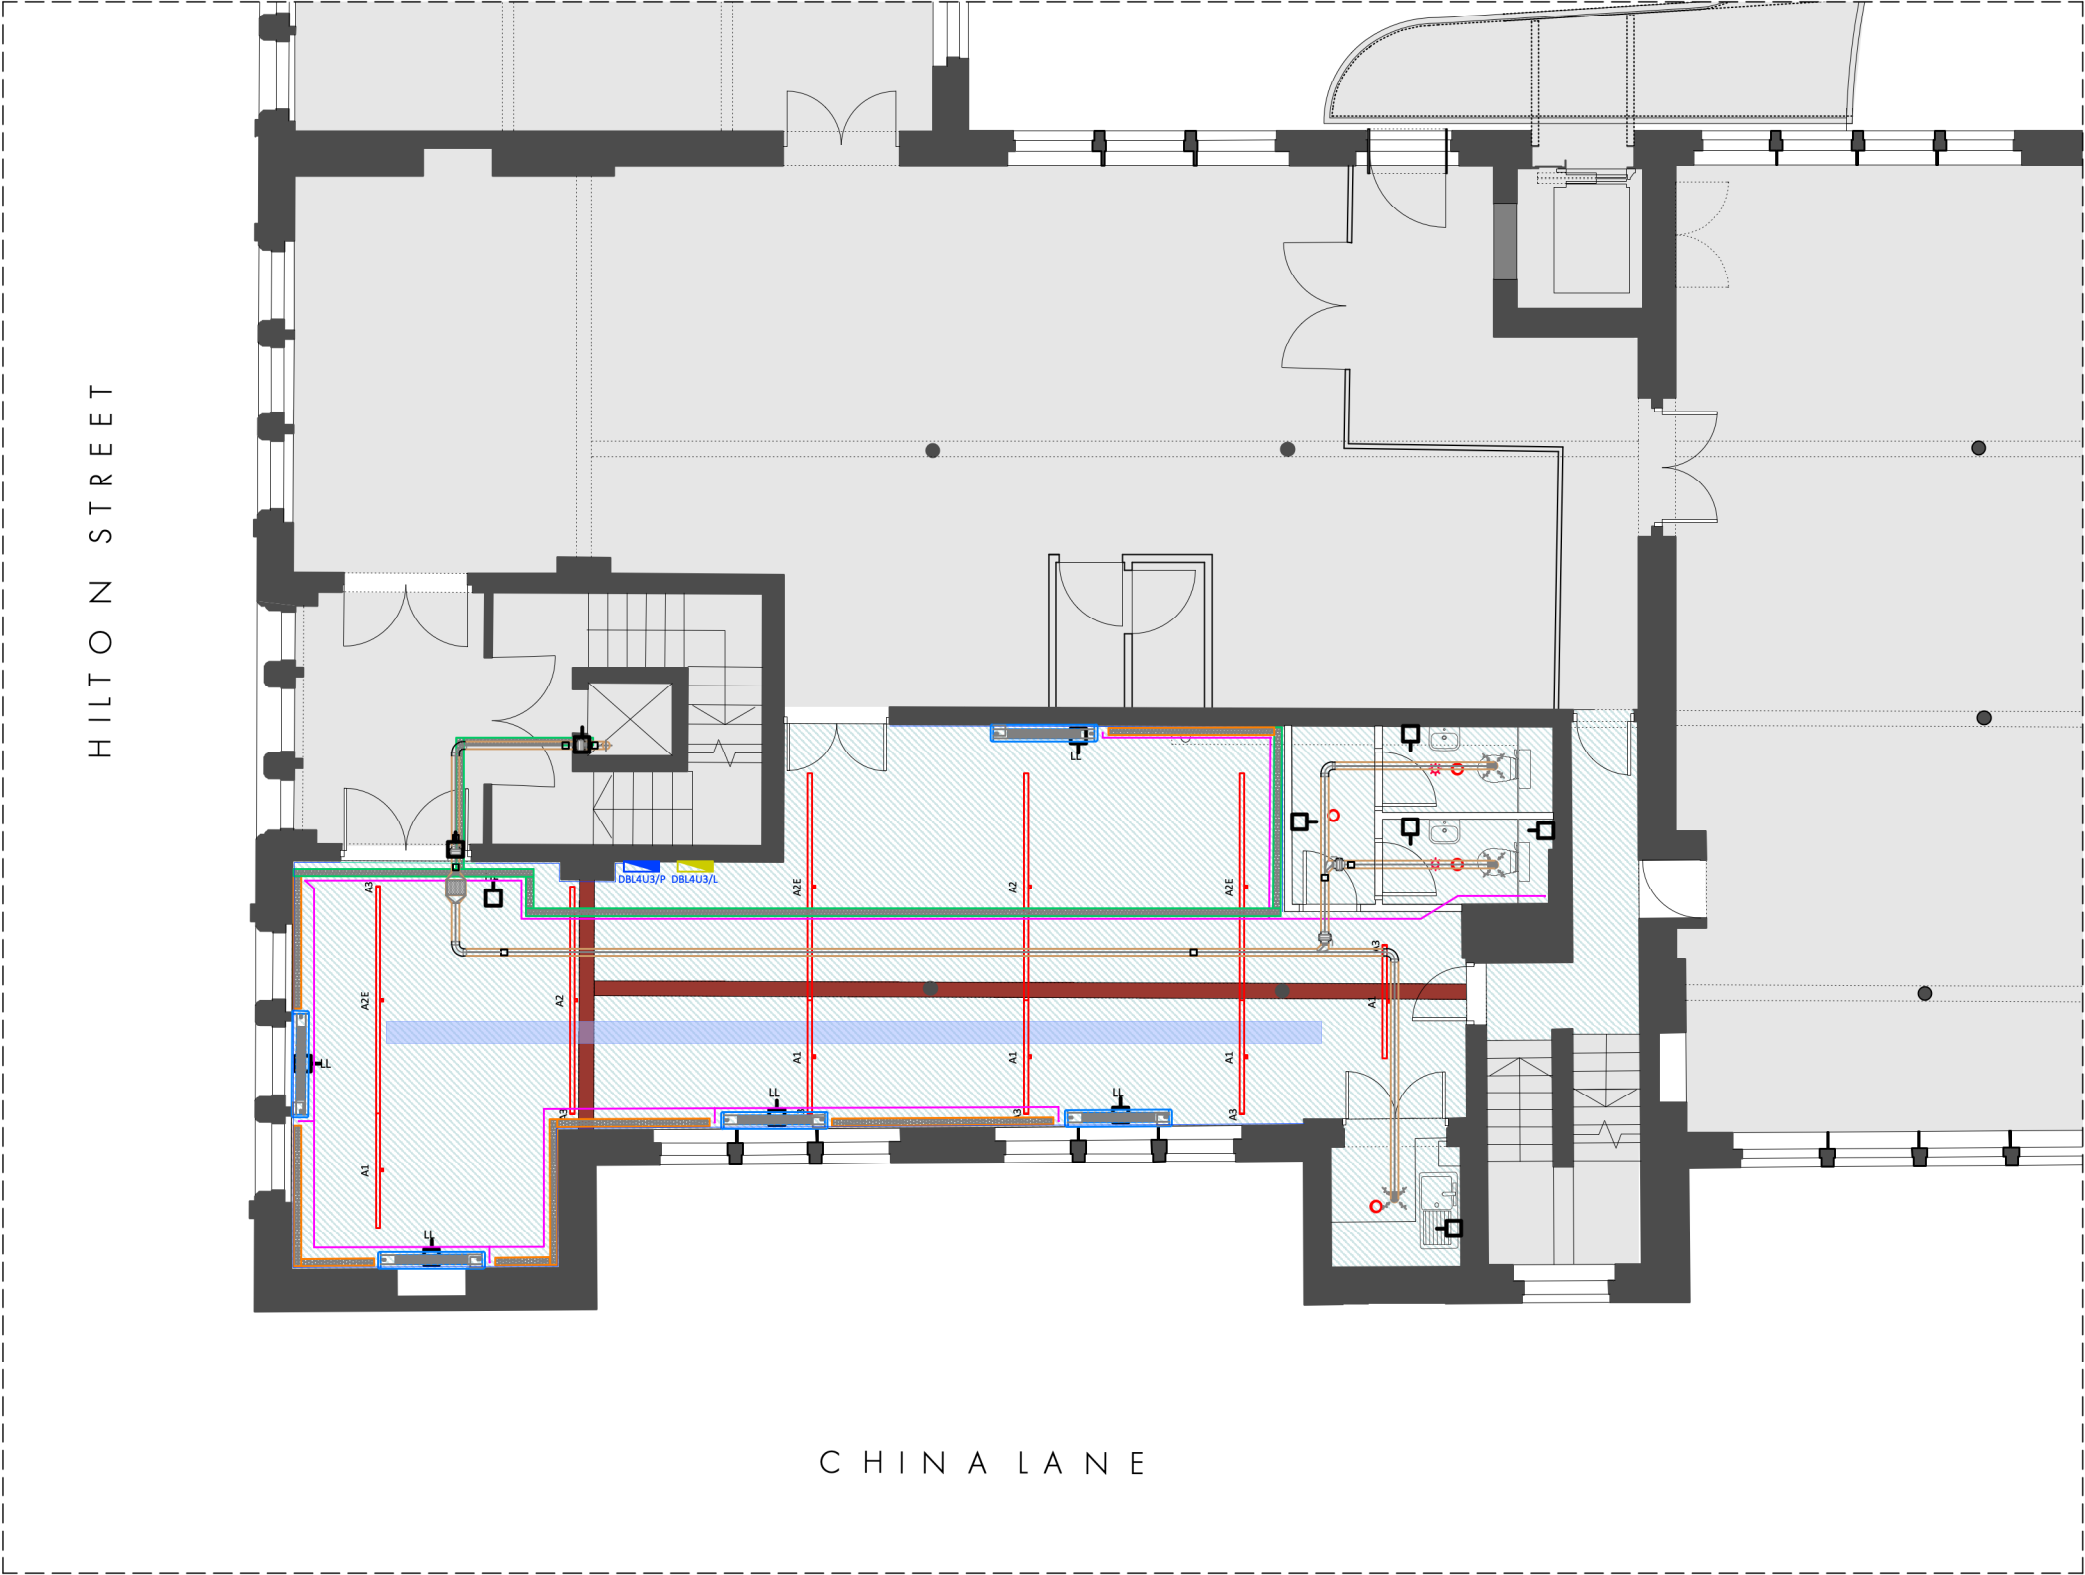

REFLECTED CEILINGS KEY

- EXISTING PLASTERED CEILING
- ORIGINAL BEAM EXPOSED
- AREA NOT SUBJECT OF THIS APPLICATION
SEE APPLICATIONS No.s 122935/LO/2019& 123242/FO/2019

MECHANICAL AND ELECTRICAL KEY

- ELECTRICAL SYMBOL LEGEND:
- Thorlux 30/45w LED 1500mm Hi-Bar Suspended Continuous Luminaire - Smart Scan (Colour TBC)
 - Thorlux 30/45w LED 1500mm Hi-Bar Suspended Continuous Luminaire - Smart Scan Emergency (Colour TBC)
 - Thorlux 60/90w LED 3000mm Hi-Bar Suspended Continuous Luminaire - Smart Scan (Colour TBC)
 - Thorlux 60/90w LED 3000mm Hi-Bar Suspended Continuous Luminaire - Smart Scan Emergency (Colour TBC)
 - Thorlux Hi-Bar Suspended End Kit
 - Thorlux Hi-Bar Suspension Kit
- MECHANICAL SYMBOL LEGEND:
- Floor Standing AC Unit
 - Refrigerant Pipework (Low Level)
 - Refrigerant Pipework (High Level)
 - Condensate Drain
 - 300mm x 25mm Galvanised Cable Tray
- VENTILATION LEGEND:
- Extract Fan
 - Extract Grille
 - Volume Control Damper
 - Smoke & Fire Damper
 - Access Panel



PLANNING

OMI Architects

31 Blackfriars Road, Salford, Manchester, M3 7AQ
+44(0)161 832 3242 / info@omiarchitects.com / www.omiarchitects.com

PROJECT	FOURWAYS HOUSE				
DRAWING	FOURTH FLOOR - PROPOSED CEILINGS PLAN				
DATE	MAR' 21	DRAWN BY	KT	SCALE	1:100@A3
JOB NO.	1412	DWG.NO.	L 2227		

FOURWAYS HOUSE, FOURTH FLOOR
PROPOSED REFLECTED CEILINGS PLAN

1.100 @ A3