


	3G / 4G Antenna ID	Existing Bearing
	uA1	357°
	uA2	36°
	uB1	101°
	uB2	156°
	uC1	230°
	uC2	282°

NOTES:			
1. ALL DIMENSIONS IN MM UNLESS OTHERWISE NOTED.			

NOTE:
ALL EQUIPMENT AND ANTENNAS IN ORANGE
LAYER TO BE REMOVED

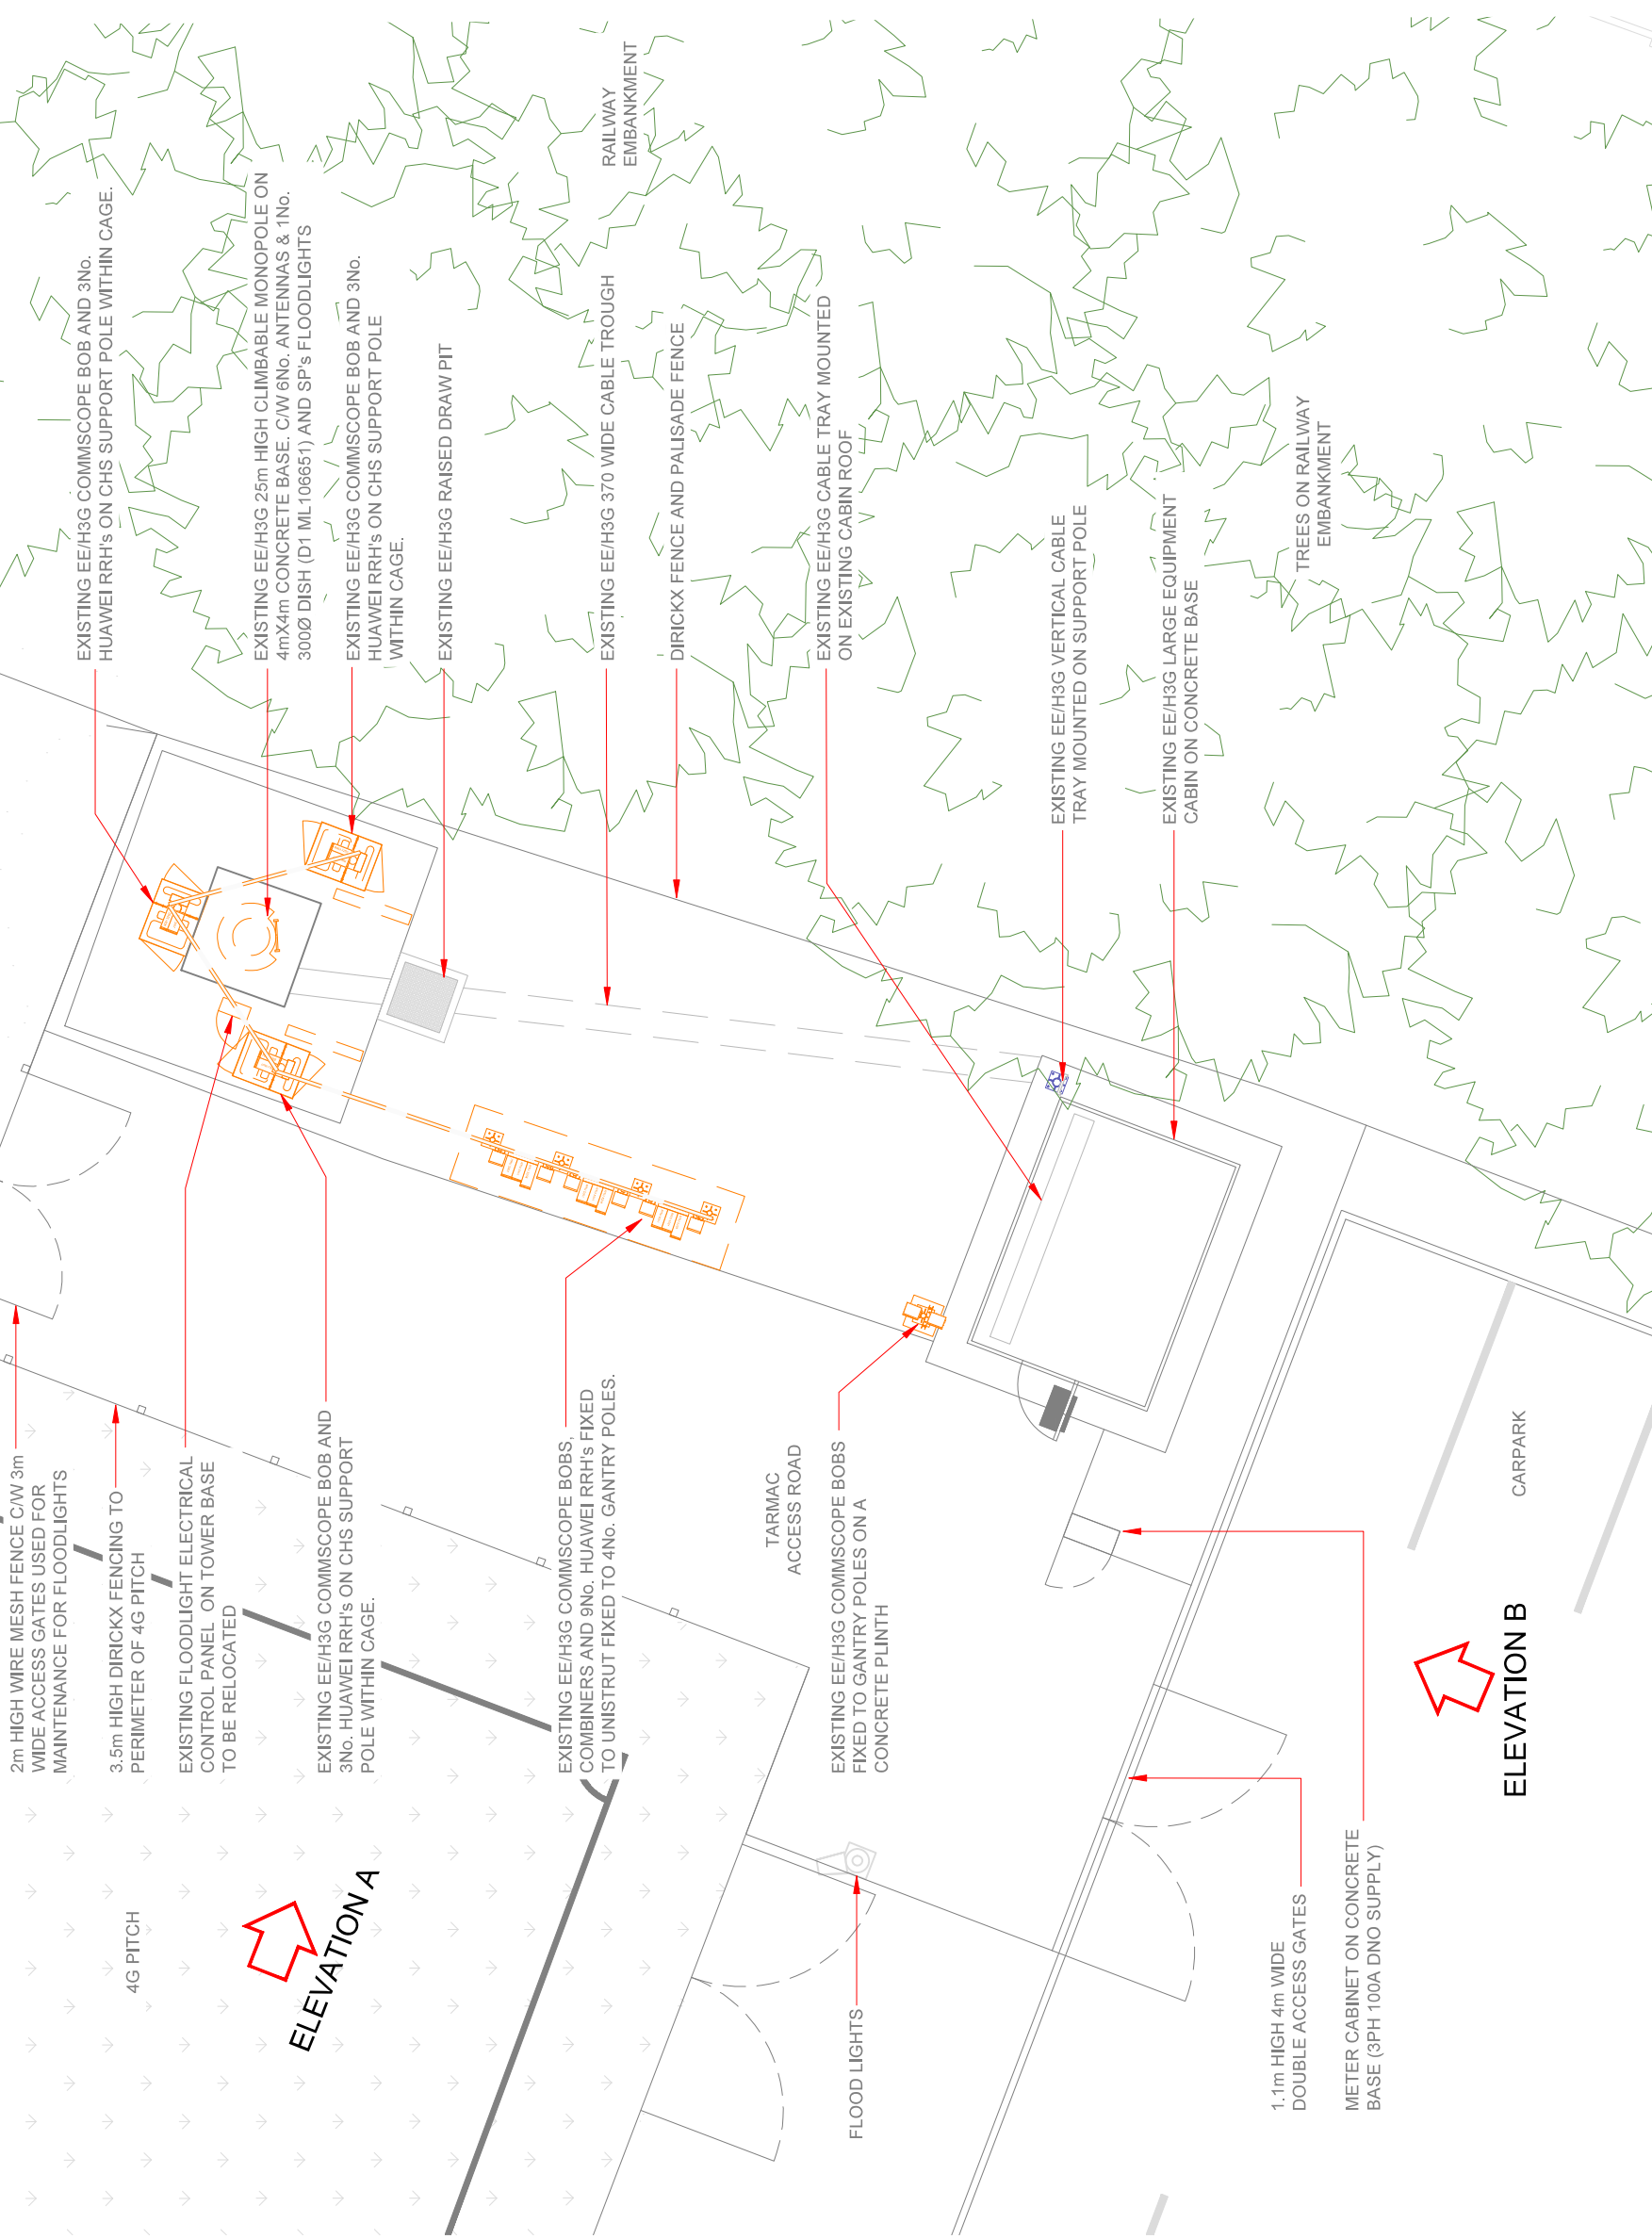

ELEVATION A

ELEVATION B

Master:	MBNL / EE / H3G	Project:	T&A	Purpose of Issue:	Issue:
M004	MBNL	T&A	Planning	Planning	D
Date:	26/04/2021	Revision / Upgrade Description			
Drawn:	MAH	Existing cabin retained for revised cabinet layout. Tower foundation design modified to Overcast concept.			
Checked:	J. Maguire				
Approved:	C Yates				
Master:	MBNL / EE / H3G	Project:	T&A	Purpose of Issue:	Issue:
M003	MBNL	T&A	Planning	Planning	C
Date:	07/04/2021	Revision / Upgrade Description			
Drawn:	J. Howden	Tower location amended			
Checked:	J. Maguire				
Approved:	C Yates				
Master:	MBNL / EE / H3G	Project:	T&A	Purpose of Issue:	Issue:
M002	MBNL	T&A	Planning	Planning	B
Date:	05/02/2021	Revision / Upgrade Description			
Drawn:	W. Reed	Elevation revised			
Checked:	J. Maguire				
Approved:	C Yates				
Master:	MBNL / EE / H3G	Project:	T&A	Purpose of Issue:	Issue:
M001	MBNL	T&A	Planning	Planning	A
Date:	16/01/2021	Revision / Upgrade Description			
Drawn:	W. Reed	First Issue - Site nomination dated: TBC			
Checked:	J. Maguire				
Approved:	C Yates				



Hubtelson 3G UK Limited
Star House, 20 Darnley Road
Maidenhead, SL6 1EH
Tel: 01628 760 000
Fax: 01628 760 001



Hatfield Business Park
Hatfield
Hertfordshire
AL10 9BW
Tel: 01707 315000
Fax: 01707 318001



Mobile Broadband Network Limited
Sixth Floor, Thames Tower, Station Road, Reading, RG1 1LX



WALDON TELECOM
PHOENIX HOUSE
PYRFORD ROAD
WEST BYFLEET
SURREY
KT14 6RA
TEL : 01932 411011
FAX : 01932 411012

Design Consultant & Principal Contractor.

Site Name:
UMIST UMTECH PLAYING FIELDS

Site ID:
708104

Address:
**MEA CENTRAL
60A LYTHAM ROAD
MANCHESTER
M14 6PL**

Title:
100 EXISTING SITE PLAN

Project:
T&A

Purpose of Issue:
GENERAL ARRANGEMENT

EE Call ID:	MBNL Call ID:	3UK Call ID:
93688	MAN111	M0400

Master Drawing No:
708104_MAN111_93688_M0400_M004

Issue:
D